



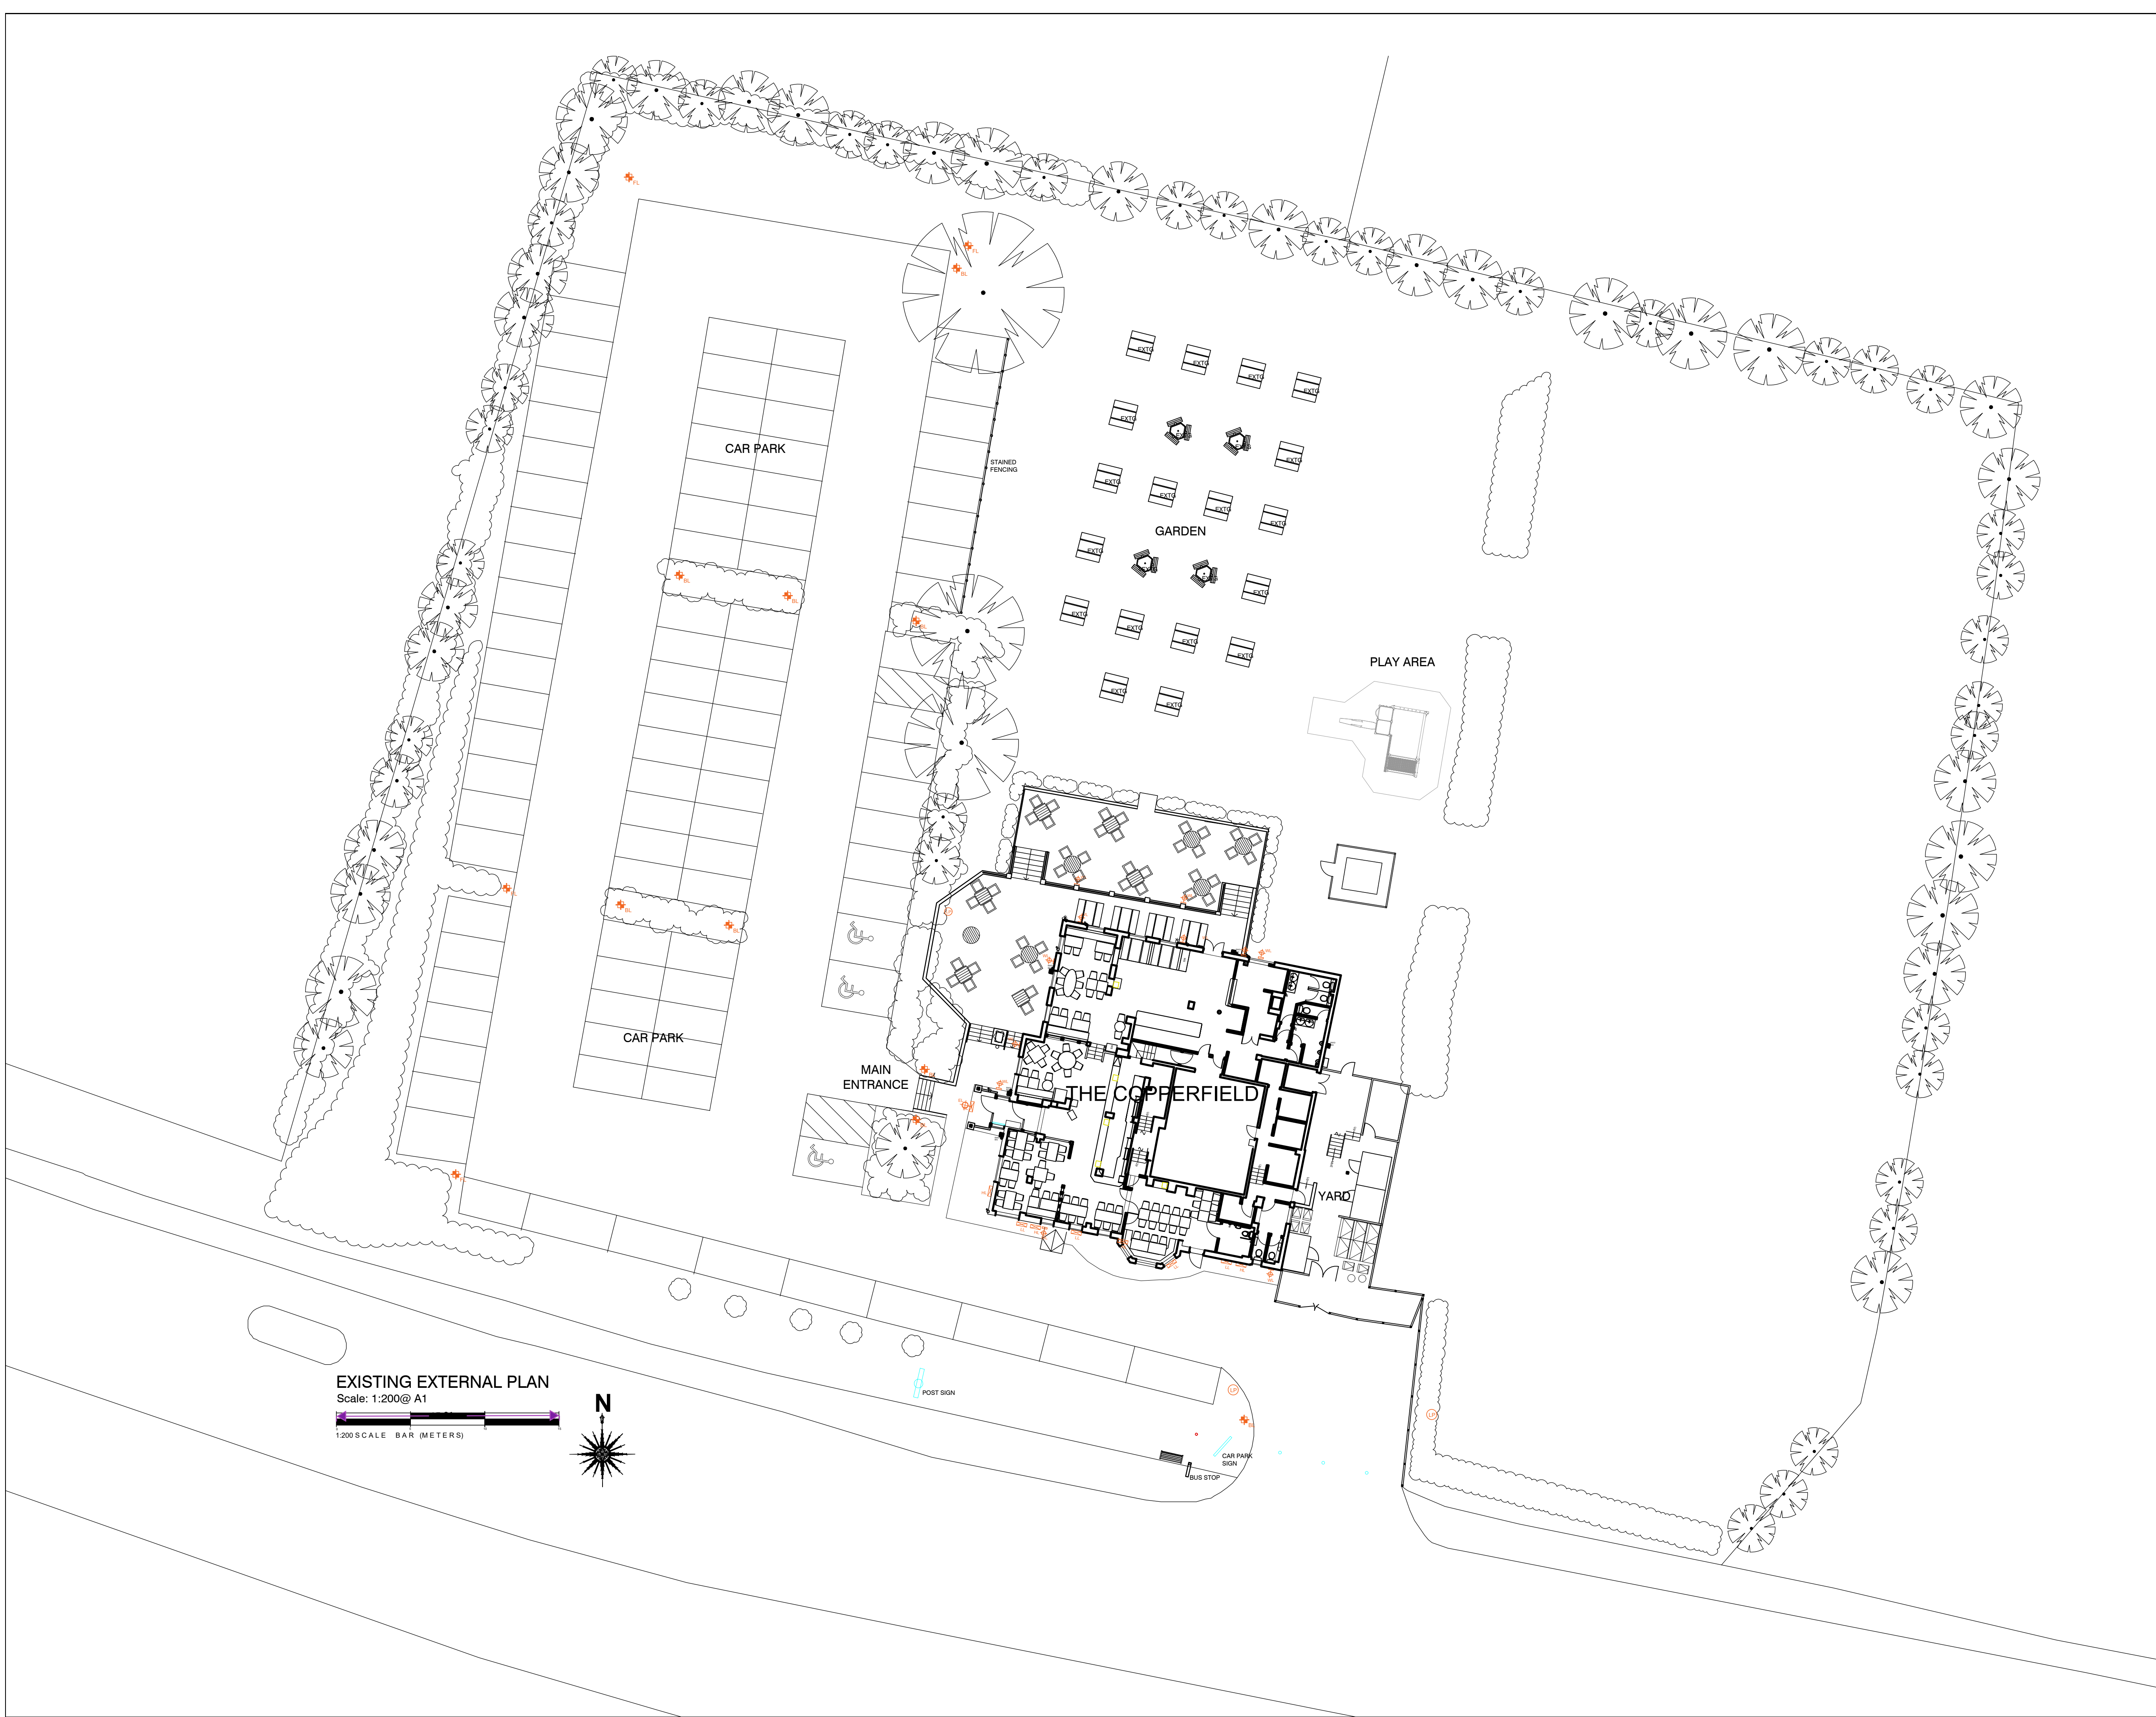

EXISTING EXTERNAL LIGHTING KEY

- EXISTING FLOOD LIGHTS TO BE RELAMPED
HL = HIGH LEVEL LL = LOW LEVEL
- EXISTING ENTRANCE LANTERN
- EXISTING FLOOR MOUNTED FLOOD LIGHTS
TO BE RELAMPED
- EXISTING LAMP POST
- EXISTING BOLLARD LIGHTING
- EXISTING CCTV
- EXISTING SPEAKER

EXISTING EXTERNAL PLAN
Scale: 1:200@ A1
1:200 SCALE BAR (METERS)

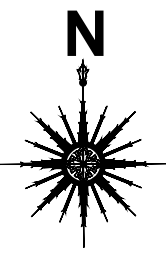

/		FIRST ISSUE	14/04/25	SEA
ALL DIMENSIONS TO BE CHECKED ON SITE BY CONTRACTOR & ALL DISCREPANCIES TO BE REPORTED TO JMDA				
JOB TITLE M&B EGO THE COPPERFIELD GRAVESEND RD, GRAVESEND, DA12 3JW				
DRAWING TITLE EXISTING EXTERNAL SITE PLAN				
DRAWING NUMBER JMDA_1777_PL_091		REVISION /		
SCALE 1:200		SHEET SIZE A1		
DATE APR 25	DRAWN BY SEA	CHECKED BY HF		
 Interior Architecture Graphics JMDA LTD 2 The Holmes Skipwith, York, YO8 5SL T: 01757 288 399 info@jmdaltd.co.uk www.jmdaltd.co.uk Copyright © This drawing is the property of JMDA Ltd. All rights reserved.				