


Rev:	Description:	By:	Date:
------	--------------	-----	-------

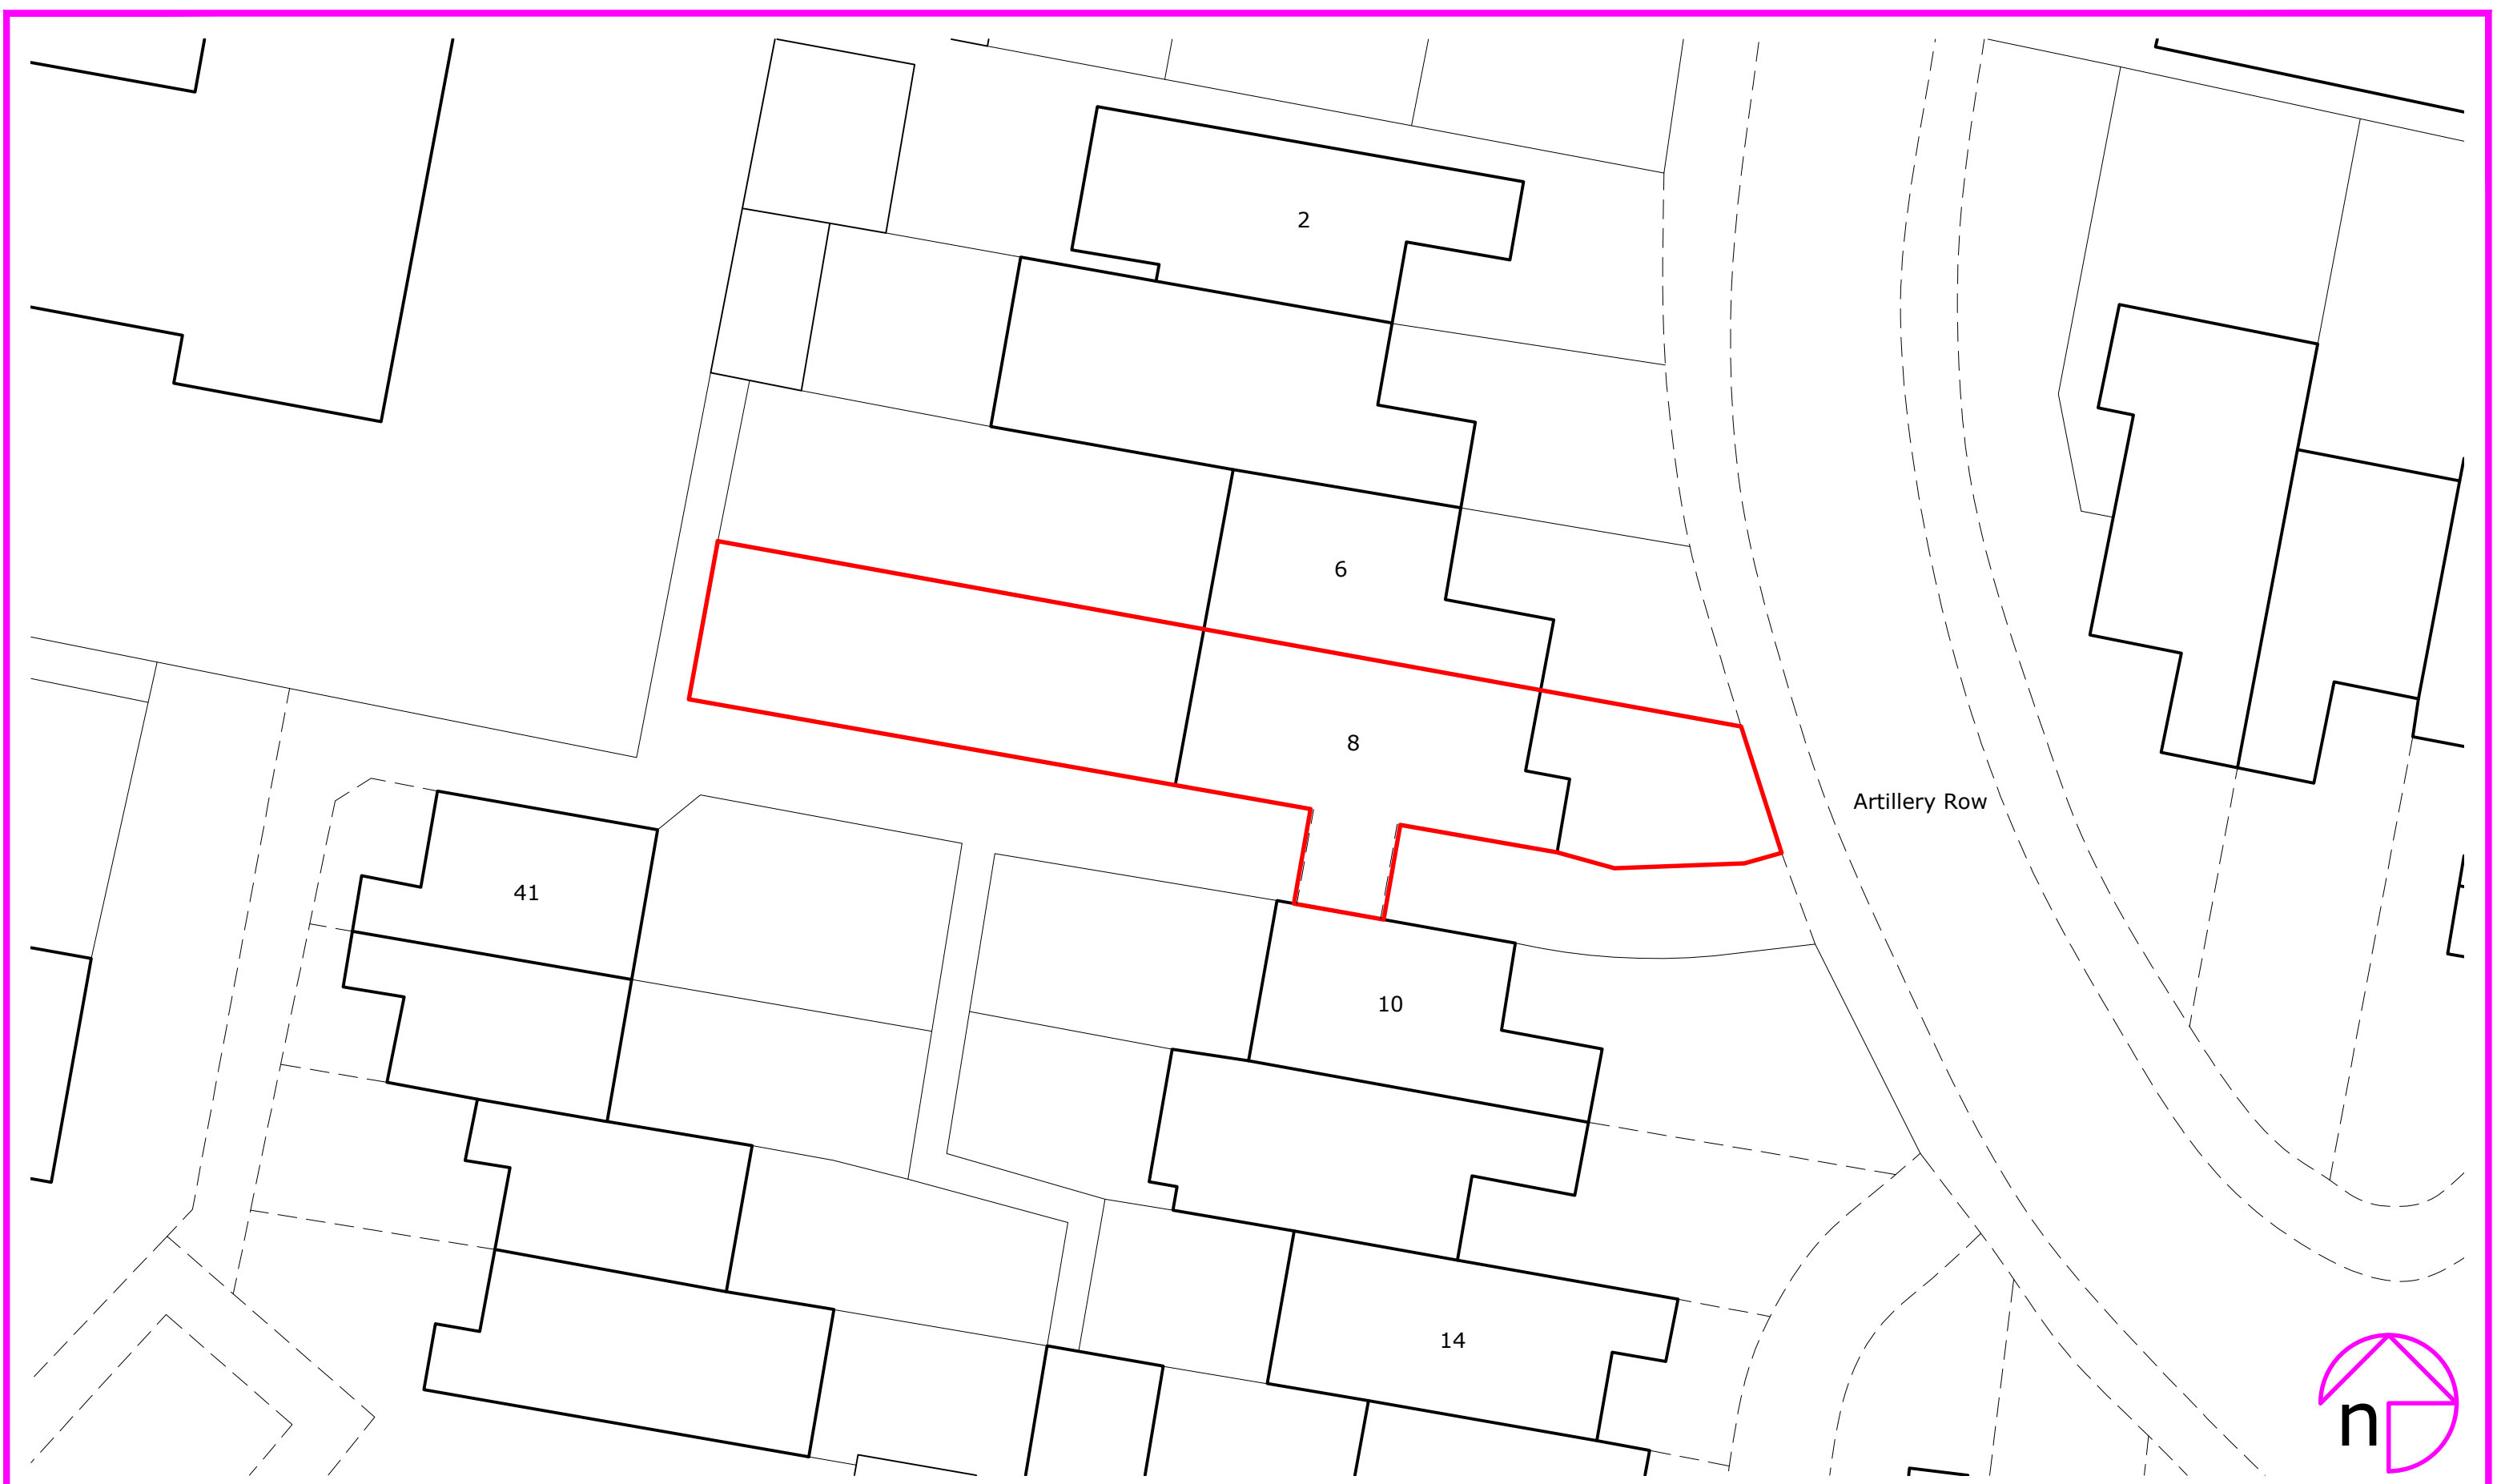

octopusenergy
services

Accredited by:



Client/Project: Kathlyn Thomas, 8 Artillery Row, Gravesend, DA12 1LY	Project status: PLANNING (installation of air source heat pump) Drawing title: Site plan as existing
---	---

Scale: 1:200	Paper Size: A3	Drawn: A Walton	Checked: W Howard
Project ID: J-9505A429	Drawing No: 01	Revision:	Date: 11.08.2024