
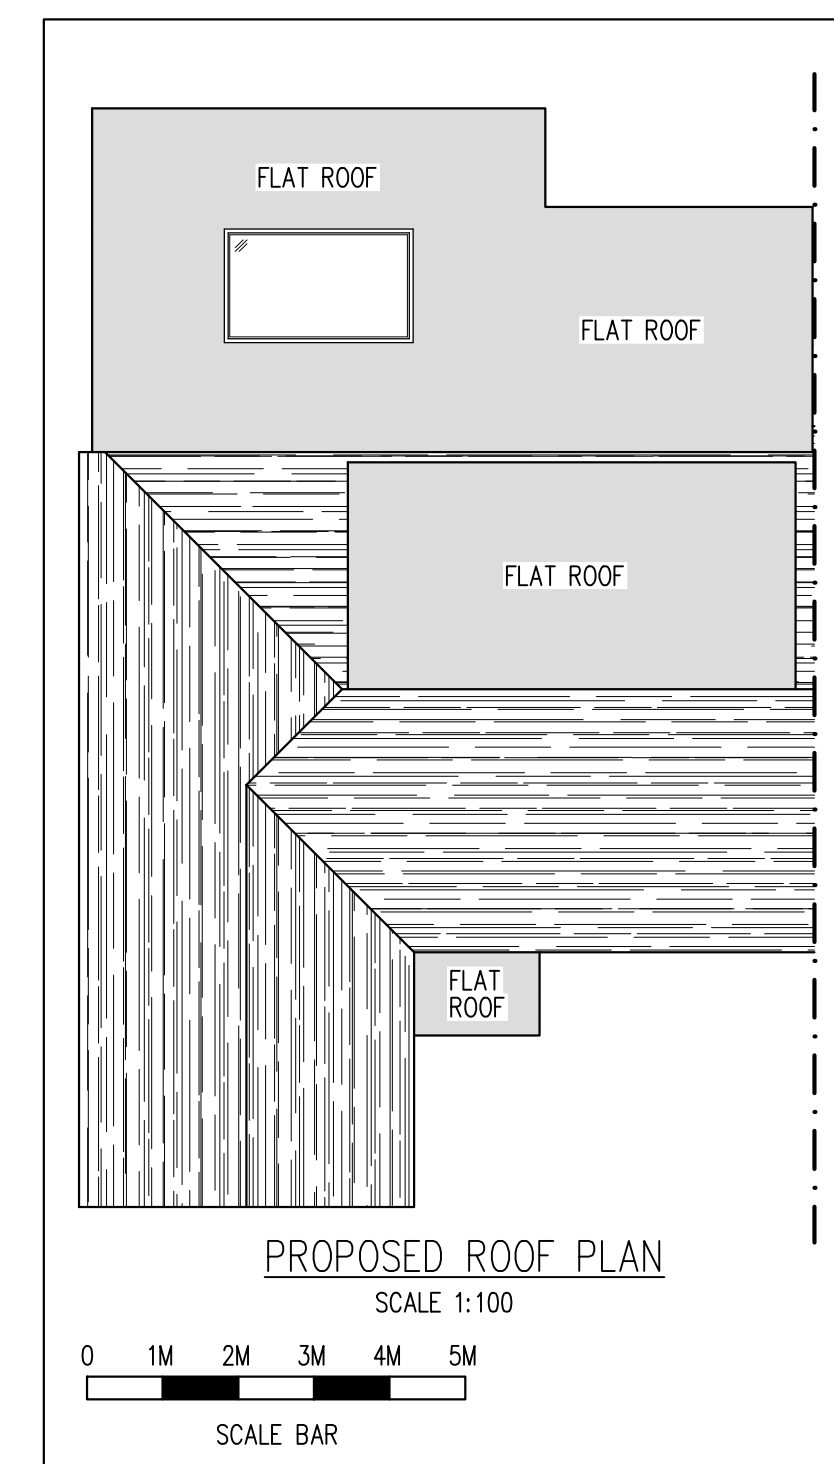


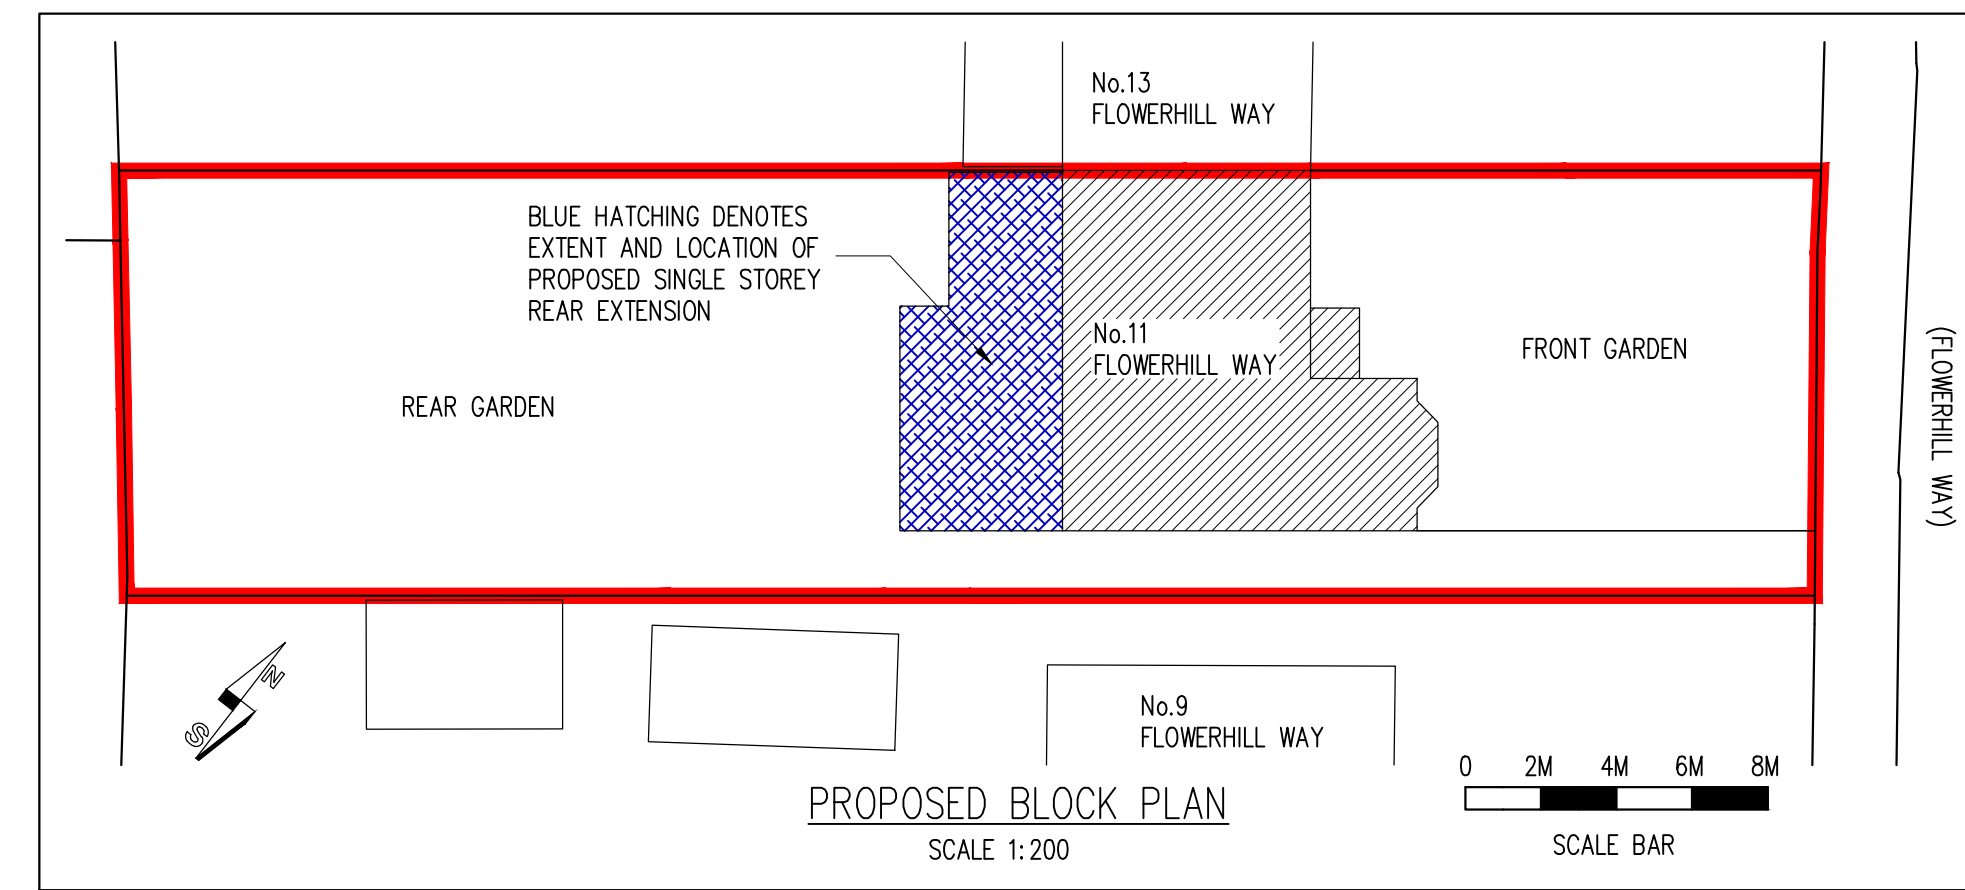

● DENOTES MAINS WIRE LINKED SMOKE ALARMS WITH BATTERY BACK UP AND A SEPARATE FUSE ON THE DISTRIBUTION BOARD

● DENOTES MAINS WIRE LINKED HEAT DETECTOR WITH BATTERY BACK UP AND A SEPARATE FUSE ON THE DISTRIBUTION BOARD

A HEAT DETECTOR IS TO BE PROVIDED TO THE KITCHEN
IN ACCORDANCE WITH B.S. 5839 PART 1 & 6



A SMOKE DETECTOR IS TO BE INSTALLED IN HALLWAY CONNECTED TO THE MAINS ELECTRICAL SUPPLY WITH BATTERY BACK UP INTERCONNECTED WITH THE HEAT DETECTOR.

AN INSTALLATION AND COMMISSIONING CERTIFICATE IS
REQUIRED IN RESPECT OF THE FIRE ALARM

THE OCCUPIERS SHOULD BE PROVIDED WITH DOCUMENTATION ALLOWING THEM TO USE AND MAINTAIN THE FIRE ALARM

NOTE:
IT IS THE CLIENTS RESPONSIBILITY TO OBTAIN
LOCAL WATER BOARD CONSENT TO BUILD
CLOSE TO A PUBLIC SEWER. IF THE SEWER IS
DEEMED PRIVATE THEN A CONFIRMATION
LETTER WILL BE REQUIRED TO TESTIFY THIS BY
LOCAL WATER BOARD. EITHER WAY PROOF OF
AGREEMENT OR CONFIRMATION THAT THE
SEWER IS PRIVATE MUST BE SUBMITTED TO
THE COUNCIL/APPROVED INSPECTOR PRIOR TO
COMMENCEMENT

NOTE:
ALL STRUCTURAL MEMBERS INCLUDING BEAMS,
POSTS, PADSTONES, CONNECTION DETAILS ETC.
TO BE JUSTIFIED & CALCULATED BY A
QUALIFIED STRUCTURAL ENGINEER.
A CONDITIONAL APPROVAL MAY BE GRANTED
FOR ALL STRUCTURAL MEMBERS. THE
CALCULATIONS MUST BE SUBMITTED TO &
APPROVED BY THE COUNCIL PRIOR TO
COMMENCEMENT.

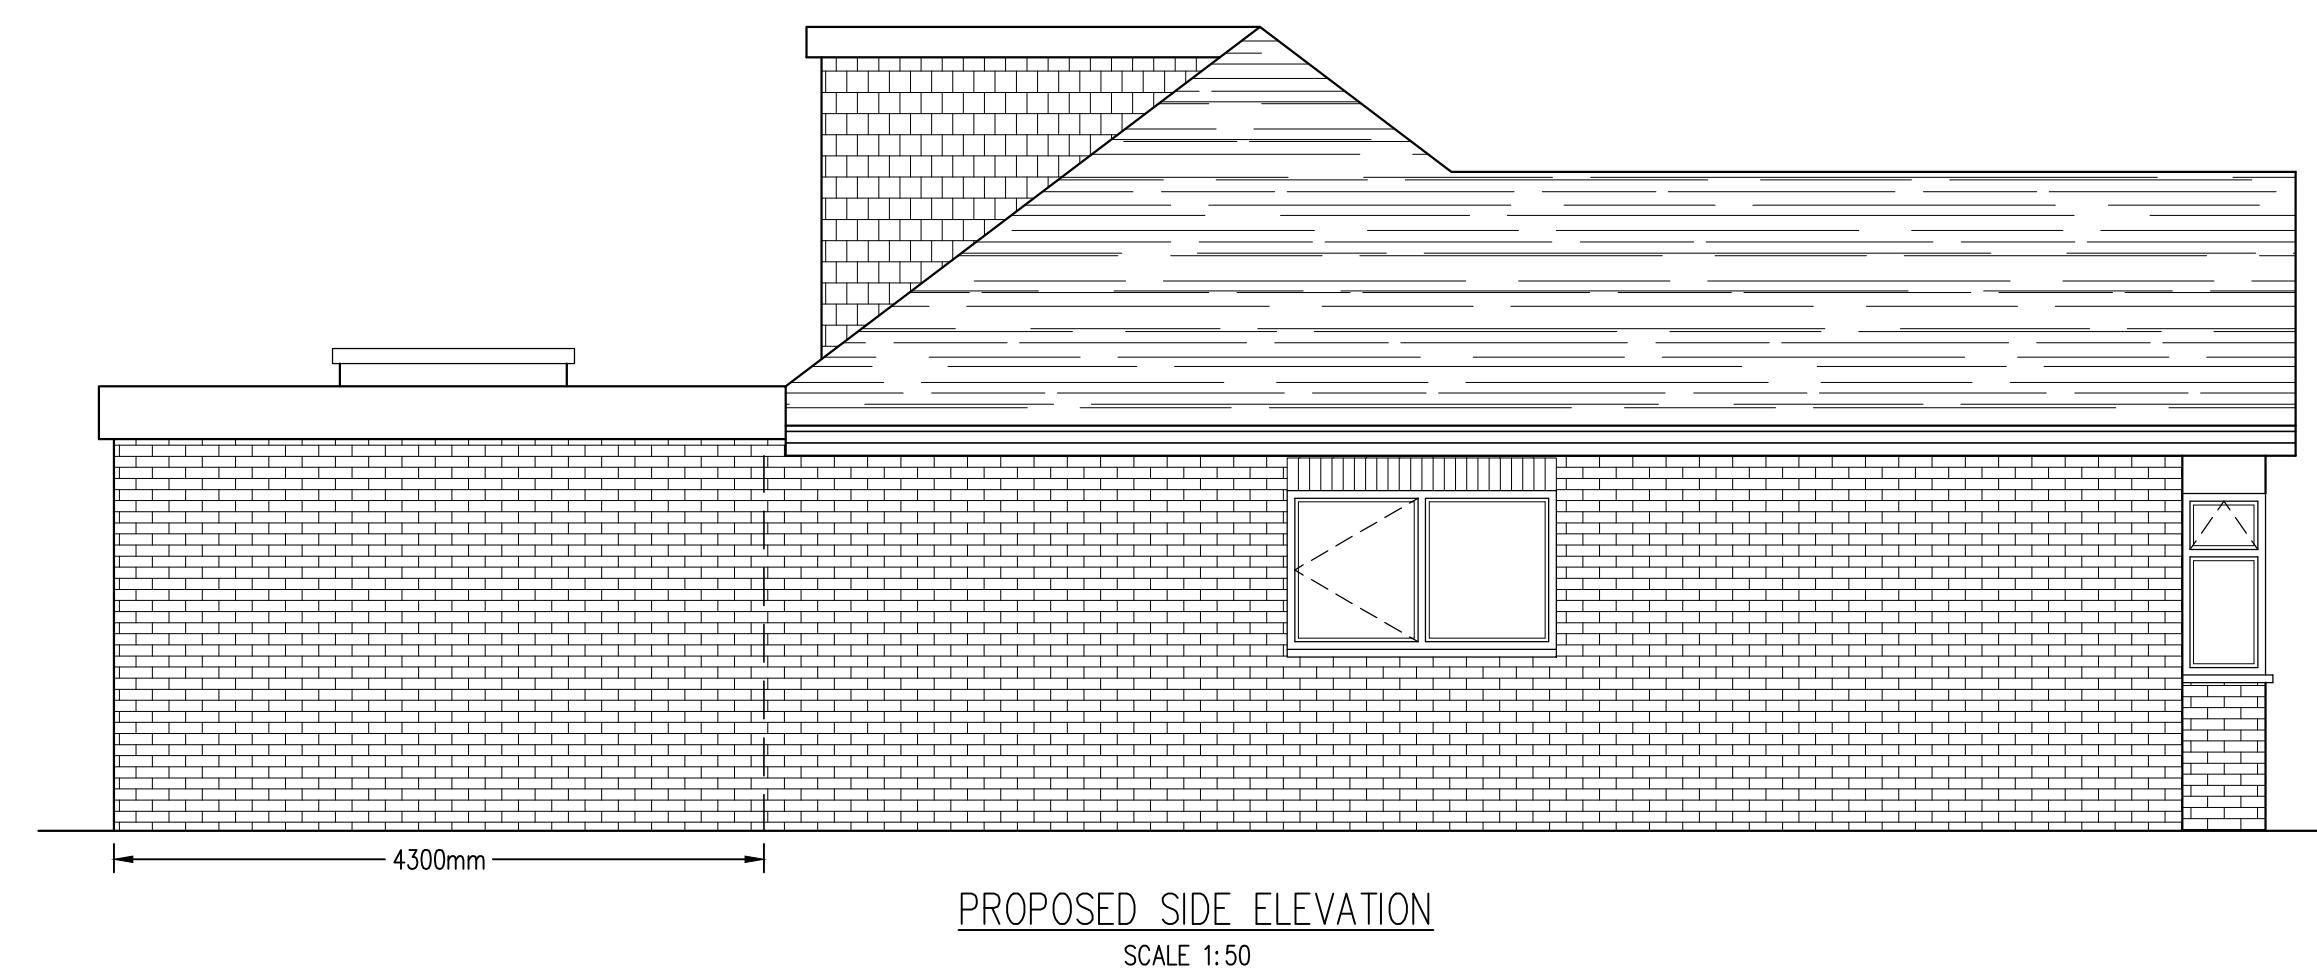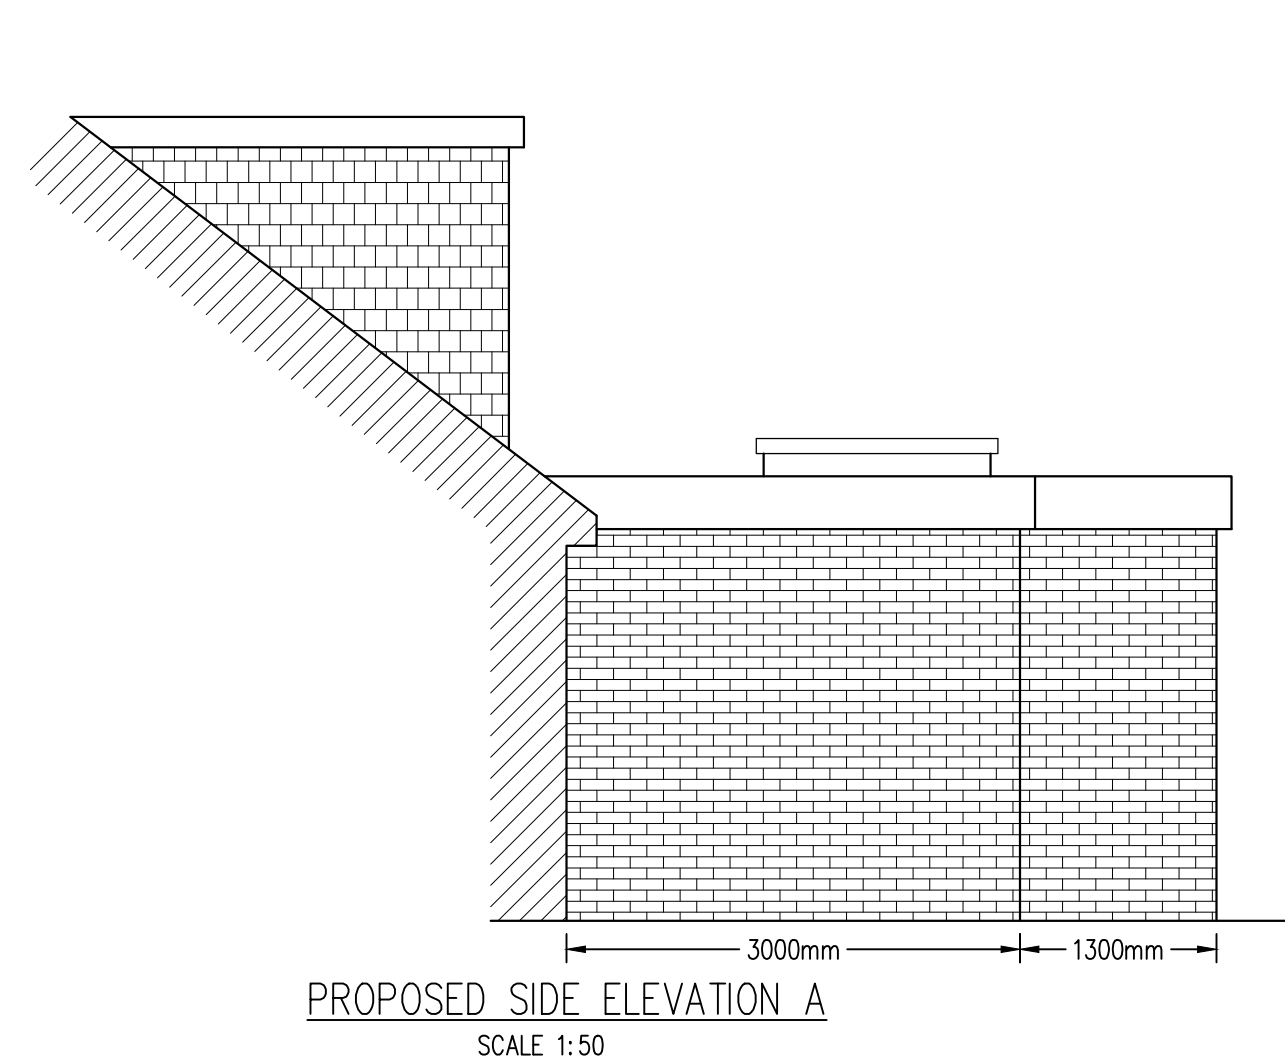


Rev	Date	By	Chkd	Revisions

Client

MR & MRS HAMISH JACK

Job Title
SINGLE STOREY REAR EXTENSION
& INTERNAL ALTERATIONS
AT 11 FLOWERHILL WAY
ISTEAD RISE
GRAVESEND KENT DA13 9DG

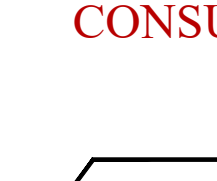

**ARCHITECTURAL
CONSULTANTS**

**ANDERSON
NORTH**

ANDERSON NORTH LIMITED

Glen Lodge
Priory Close, East Farleigh
Kent ME15 0EY
Tel: 01732 522 455
Mob: 07957 627 440

Scale AS SHOWN @ A1	Date 14/09/23
------------------------	------------------

Drawing Title

PROPOSED FLOOR PLAN
AND ELEVATIONS

Drawing No.	Rev.
11-FLOWERHILL-WAY-02	A