




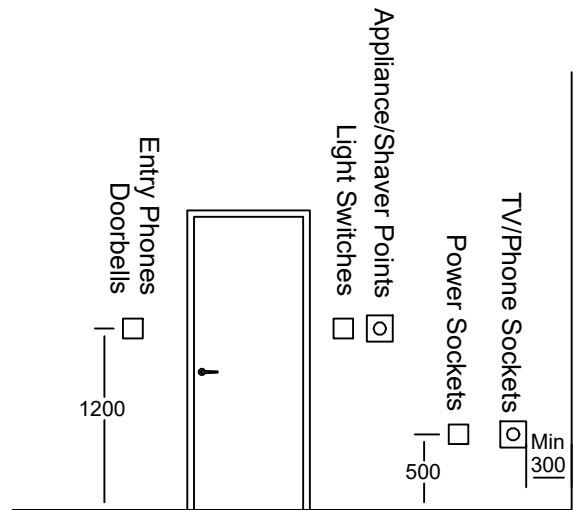

Mounting Heights for Electrical Fittings

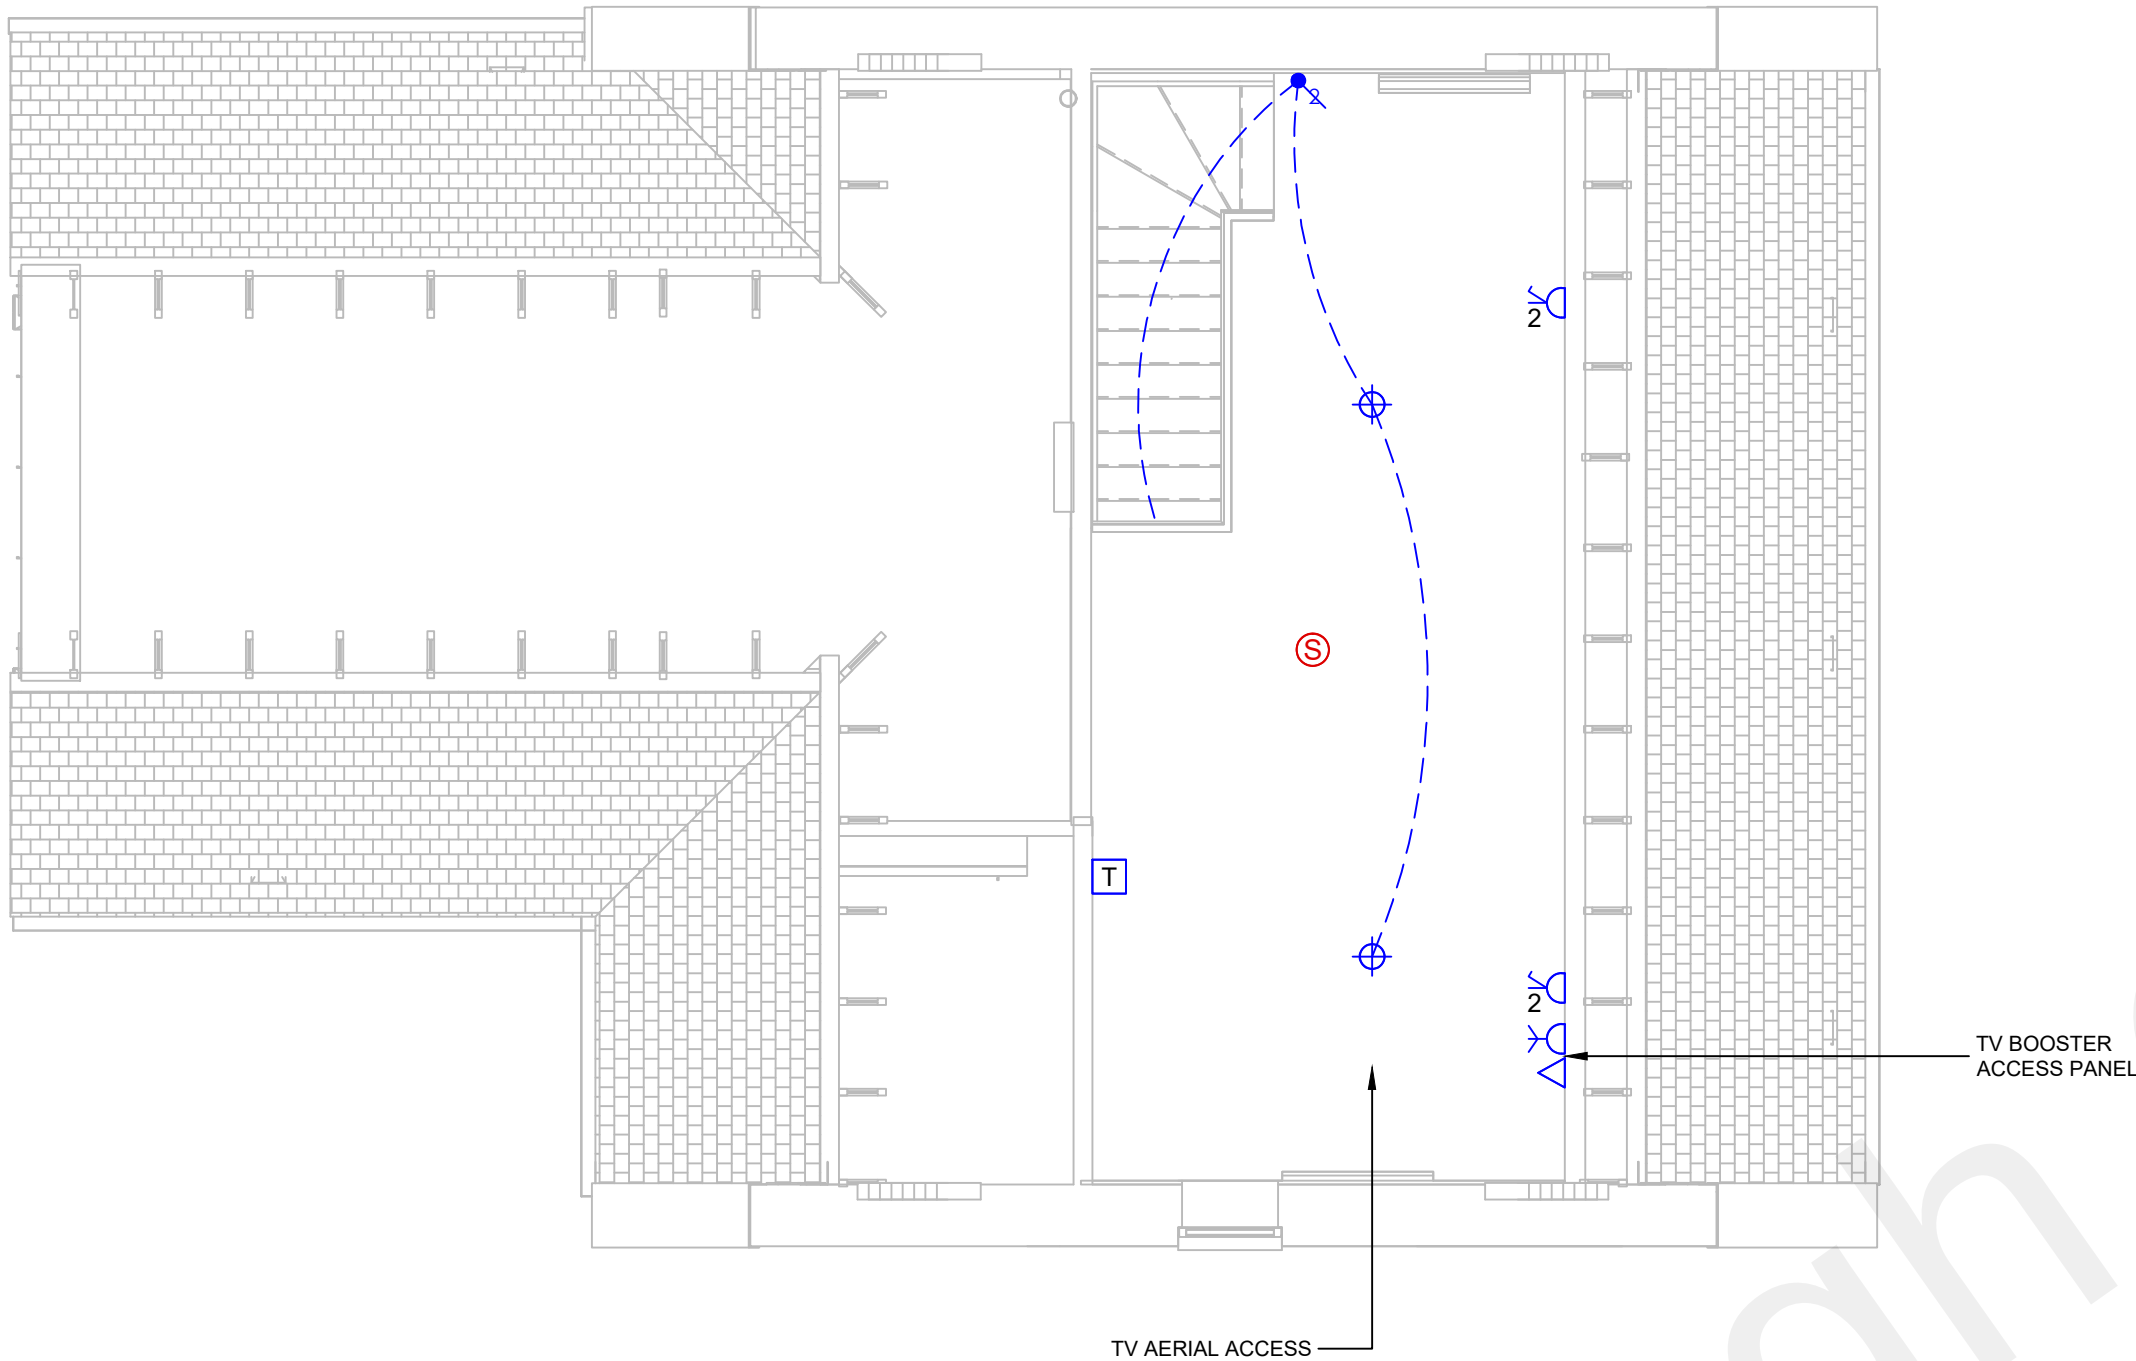

First Floor Plan

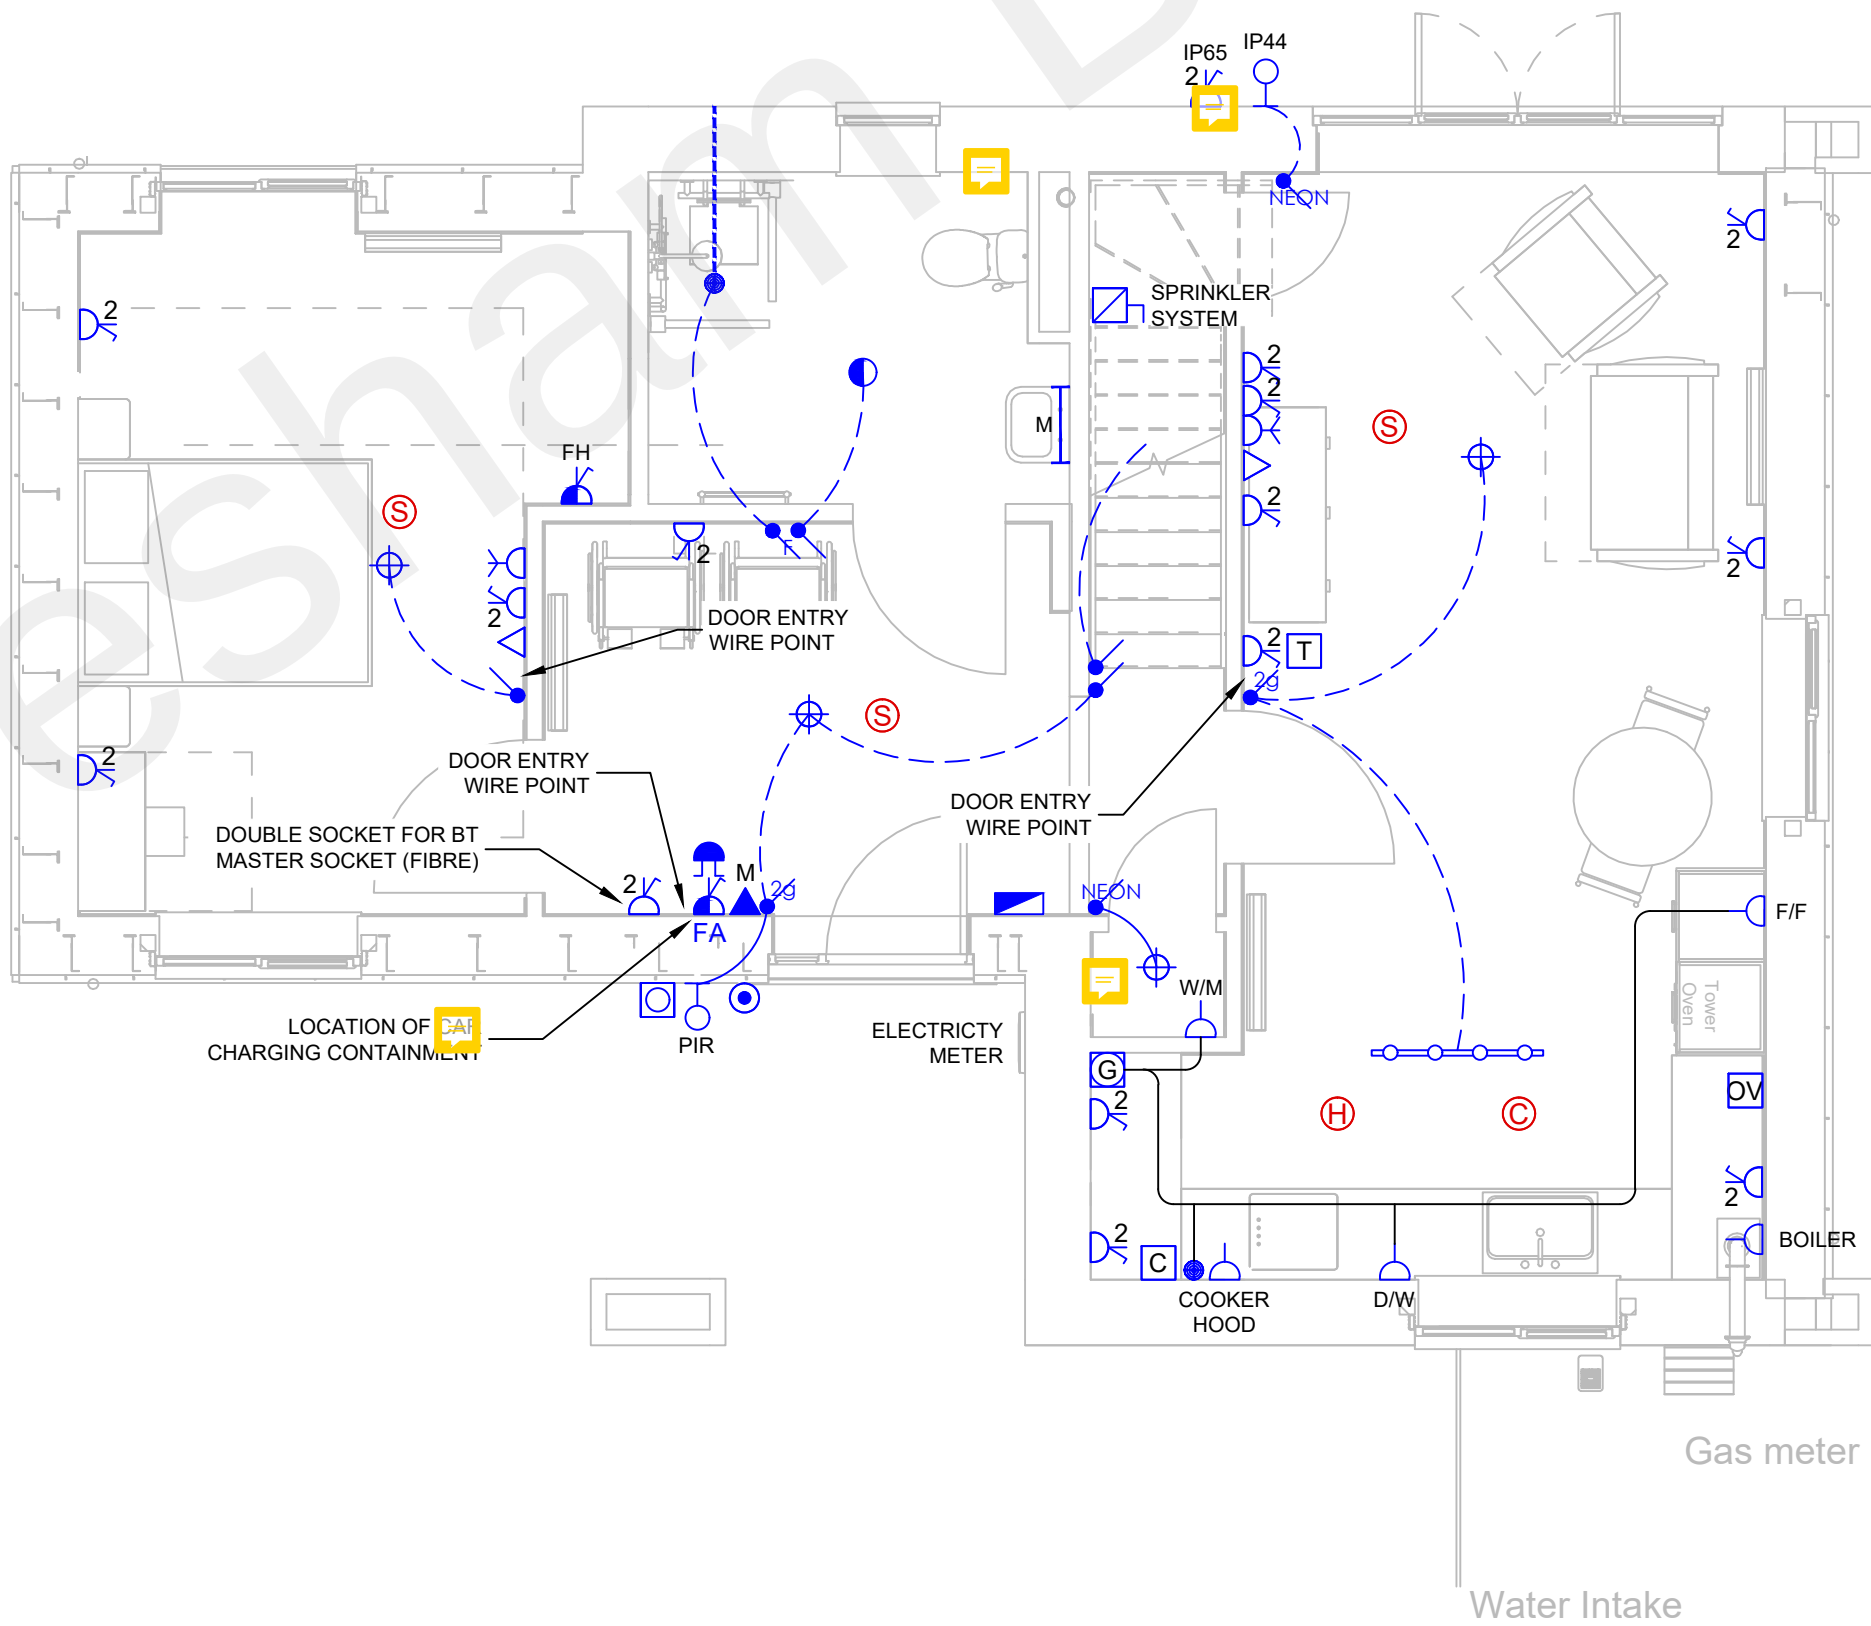

Ground Floor Plan

| ELECTRICAL SERVICES |                                     |
|---------------------|-------------------------------------|
|                     | Single unswitched socket            |
|                     | Twin switched socket                |
|                     | Switched spur                       |
|                     | Telephone outlet                    |
|                     | Master BT point                     |
|                     | Doorbell chime                      |
|                     | Doorbell push                       |
|                     | Consumer unit                       |
|                     | TV aerial outlet                    |
|                     | 45amp hob switch                    |
|                     | 20amp oven switch                   |
|                     | Multi-gang grid switch              |
|                     | Thermostat                          |
|                     | Rotary isolator                     |
|                     | EV charging point                   |
|                     | Aico smoke detector                 |
|                     | Aico heat detector                  |
|                     | Aico carbon monoxide detector       |
|                     | Fire alarm locator switch           |
|                     | Pendant light fitting               |
|                     | JCC Radia 16w LED                   |
|                     | Saxby Amalfi 4 spot                 |
|                     | Mirror light                        |
|                     | Saxby Icarus external light fitting |
|                     | 1 gang 1 way light switch           |
|                     | 1 gang 1 way neon light switch      |
|                     | 1 gang 2 way light switch           |
|                     | 2 gang light switch                 |
|                     | 2 gang light switch                 |
|                     | Fan isolator switch                 |
|                     | Extract fan                         |
|                     | Dishwasher                          |
|                     | Washing machine                     |
|                     | Fridge freezer                      |
|                     | Future alarm                        |
|                     | Future hoist                        |

- THIS DOCUMENT IS COPYRIGHT OF THE ORIGINATOR AND MUST BE TREATED AS CONFIDENTIAL.
- THIS DOCUMENT MUST NOT BE ALTERED, REPRODUCED OR DISTRIBUTED WITHOUT PRIOR WRITTEN CONSENT OF THE ORIGINATOR.
- DO NOT SCALE THIS DOCUMENT. ALL DIMENSIONS MUST BE CHECKED ON SITE PRIOR TO COMMENCEMENT OF ANY RELATED WORKS.
- THIS DOCUMENT MUST BE READ IN CONJUNCTION WITH ALL SUPPORTING DOCUMENTS PRODUCED BY THE ORIGINATOR.
- USERS OF THIS DOCUMENT ARE RESPONSIBLE FOR CHECKING WHICH REVISION IS CURRENT.

Notes & Symbols:

|  |  |  |
|--|--|--|
|  |  |  |
|  |  |  |
|  |  |  |

Rev. Date. Description.



Oak Leaves, Charing Hill, Charing,  
Ashford, Kent TN27 0NL  
Tel: 01622 688334 Email: enquiries@jws Kent.com

Project:  
CONSTABLE ROAD  
NORTHFLEET  
GRAVESEND  
KENT

Drawing Title:  
PLOT 1  
ELECTRICAL SERVICES

|                  |                   |
|------------------|-------------------|
| Scale:<br>NTS@A1 | Date:<br>22/03/22 |
|------------------|-------------------|

Drawing Status:  
AS FITTED

|                             |           |
|-----------------------------|-----------|
| Drawing No.<br>CONSTABLE/01 | Revision: |
|-----------------------------|-----------|