



• THIS DOCUMENT IS COPYRIGHT OF THE ORIGINATOR AND MUST BE TREATED AS CONFIDENTIAL.
• THIS DOCUMENT MUST NOT BE ALTERED, REPRODUCED OR DISTRIBUTED WITHOUT PRIOR WRITTEN CONSENT OF THE ORIGINATOR.
• DO NOT SCALE THIS DOCUMENT. ALL DIMENSIONS MUST BE CHECKED ON SITE PRIOR TO COMMENCEMENT OF ANY RELATED WORKS.
• THIS DOCUMENT MUST BE READ IN CONJUNCTION WITH ALL SUPPORTING DOCUMENTS PRODUCED BY THE ORIGINATOR.
• USERS OF THIS DOCUMENT ARE RESPONSIBLE FOR CHECKING WHICH REVISION IS CURRENT.

Notes & Symbols:


ELECTRICAL SERVICES	
	Single unswitched socket
	Twin switched socket
	Switched spur
	Telephone outlet
	Master BT point
	Doorbell chime
	Doorbell push
	Consumer unit
	TV aerial outlet
	45amp hob switch
	20amp oven switch
	Multi-gang grid switch
	Thermostat
	Rotary isolator
	EV charging point
	Aico smoke detector
	Aico heat detector
	Aico carbon monoxide detector
	Fire alarm locator switch
	Pendant light fitting
	JCC Radia 16w LED
	Saxby Amalfi 4 spot
	Mirror light
	Saxby Icarus external light fitting
	1 gang 1 way light switch
	1 gang 1 way neon light switch
	1 gang 2 way light switch
	2 gang light switch
	2 gang light switch
	Fan isolator switch
	Extract fan
	Dishwasher
	Washing machine
	Fridge freezer
	Future alarm
	Future hoist

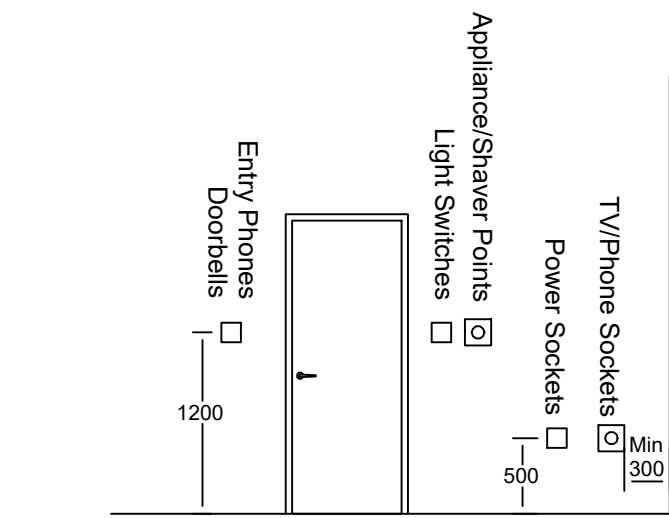

Mounting Heights for Electrical Fittings

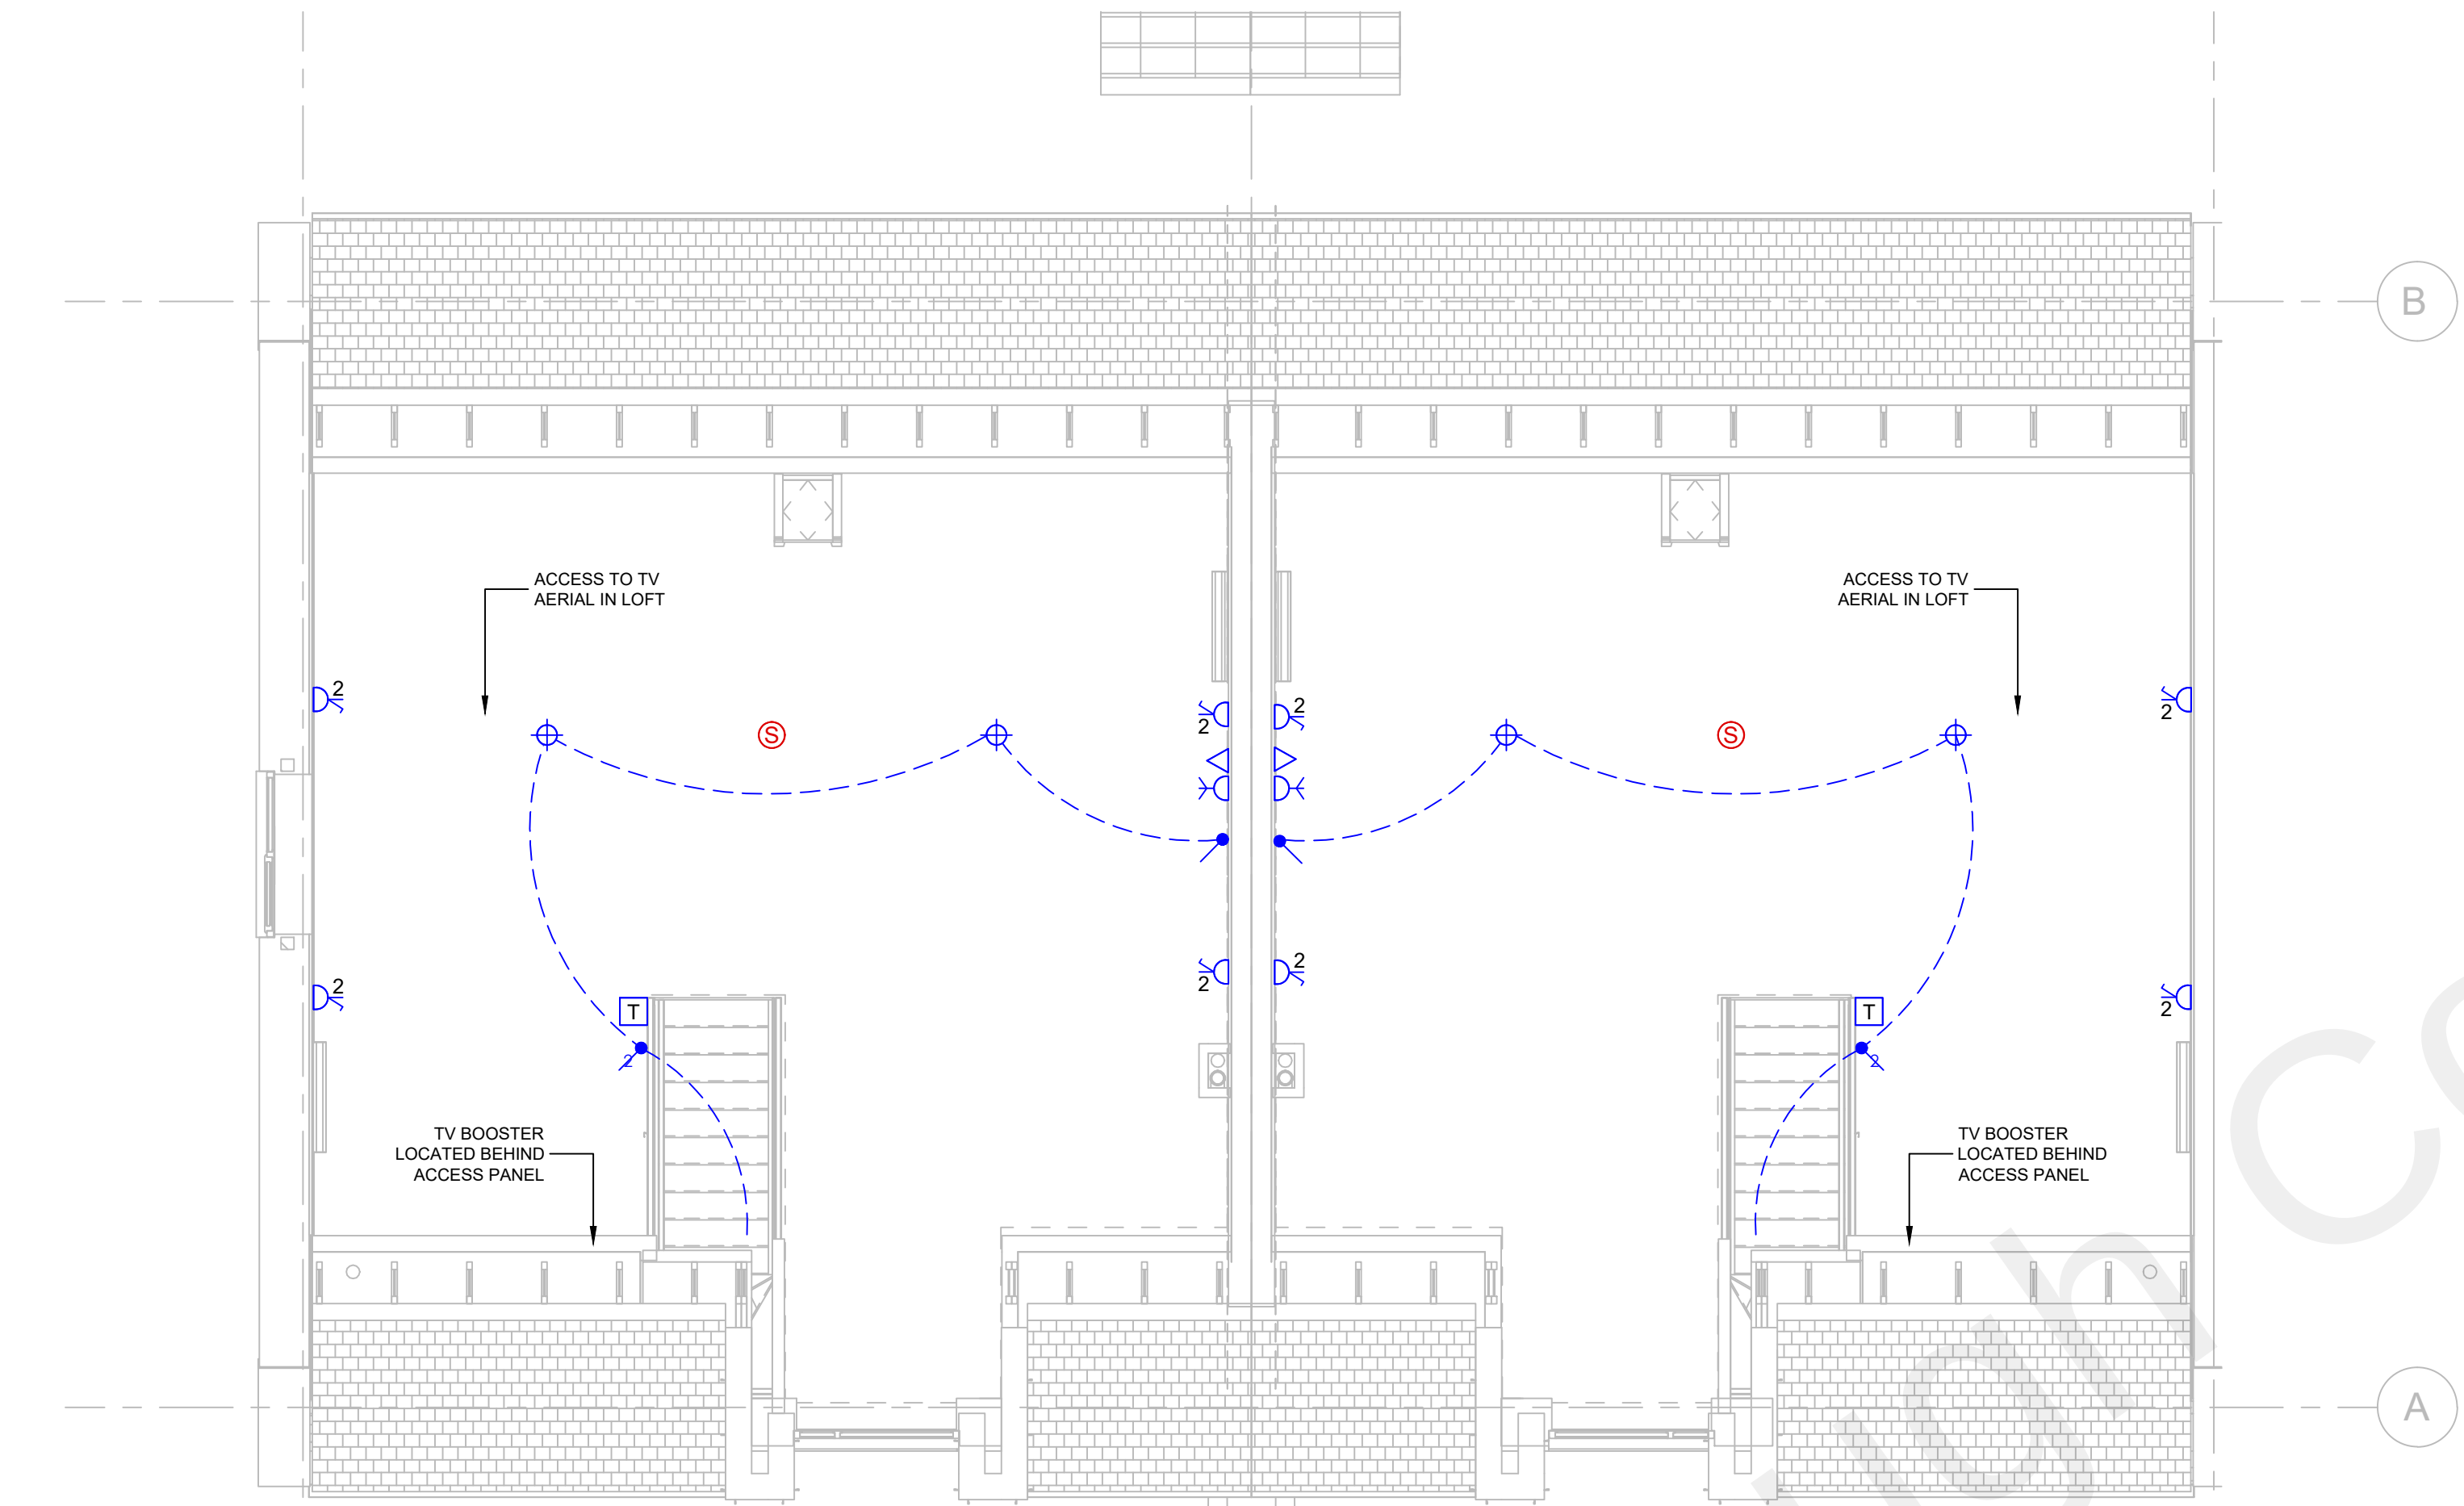

First Floor Plan

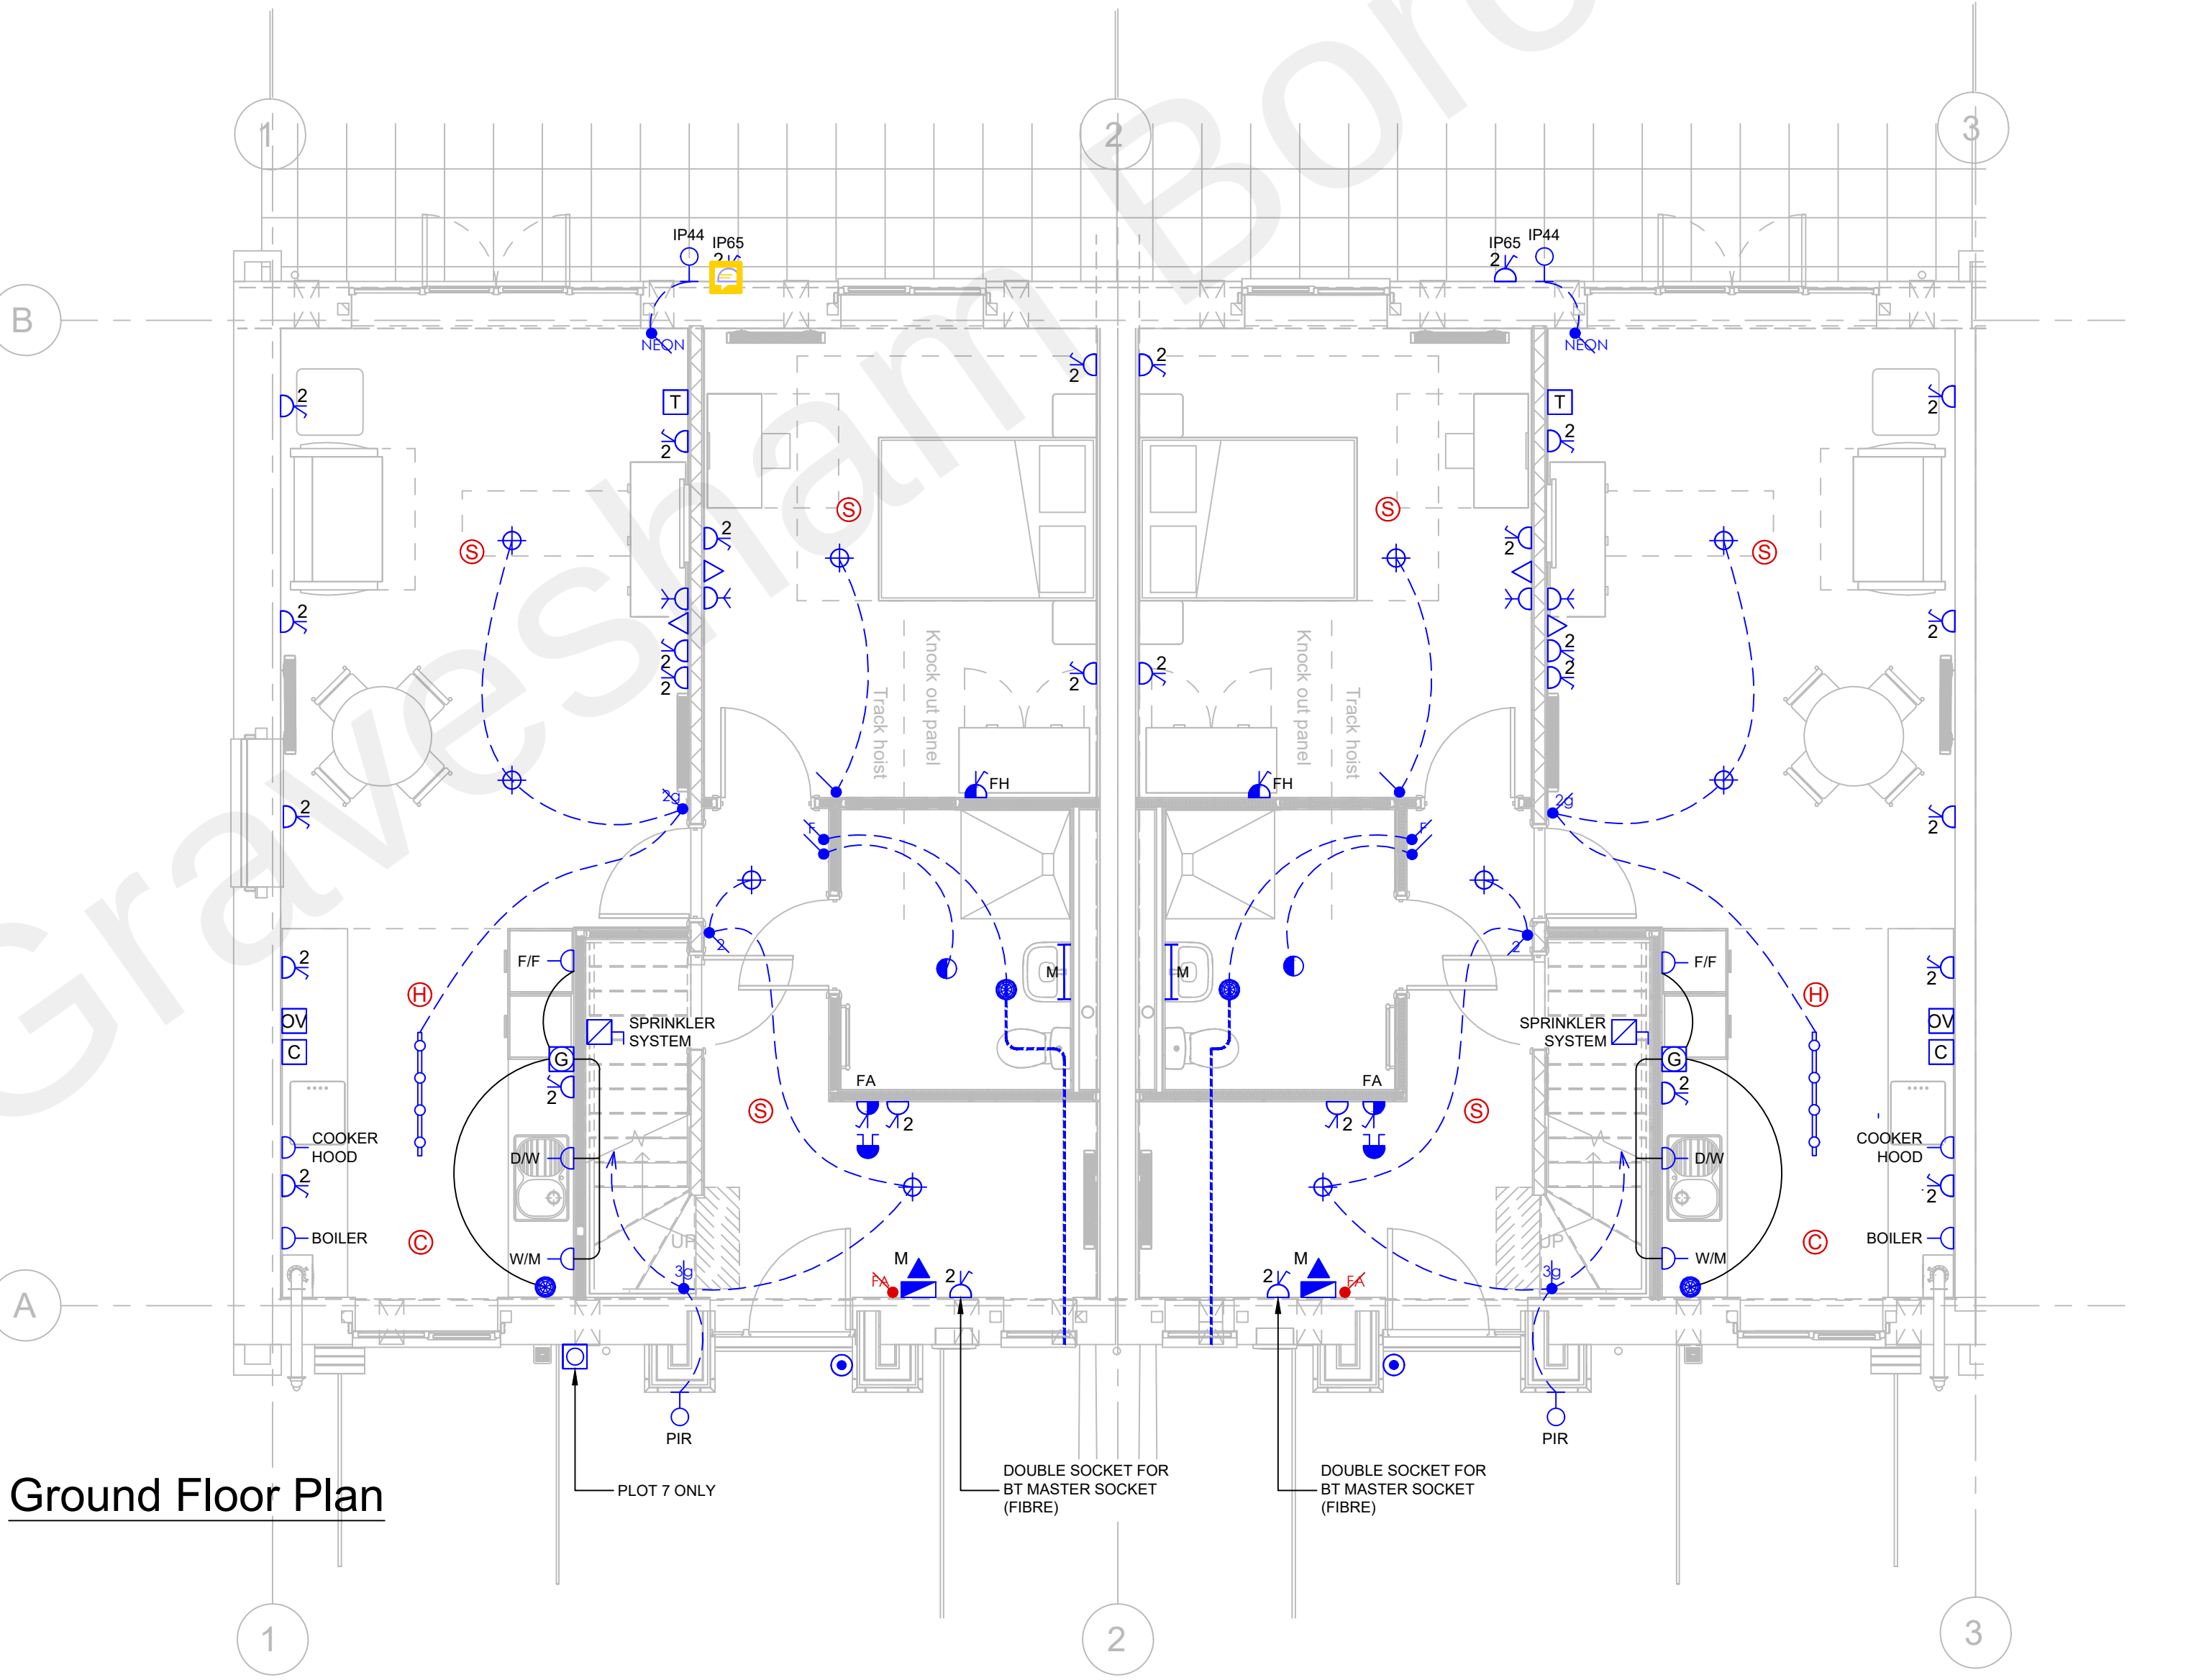

Ground Floor Plan

Rev.	Date.	Description.
 jwskent ELECTRICAL CONTRACTORS www.jwskent.com		
Oak Leaves, Charing Hill, Charing, Ashford, Kent TN27 0NL. Tel: 01622 688334 Email: enquiries@jwskent.com		
Project: CONSTABLE ROAD NORTHFLEET GRAVESEND KENT		
Drawing Title: PLOTS 2 TO 7 ELECTRICAL SERVICES		
Scale: NTS@A1	Date: 22/03/22	
Drawing Status: AS FITTED		
Drawing No. CONSTABLE/02		Revision: