
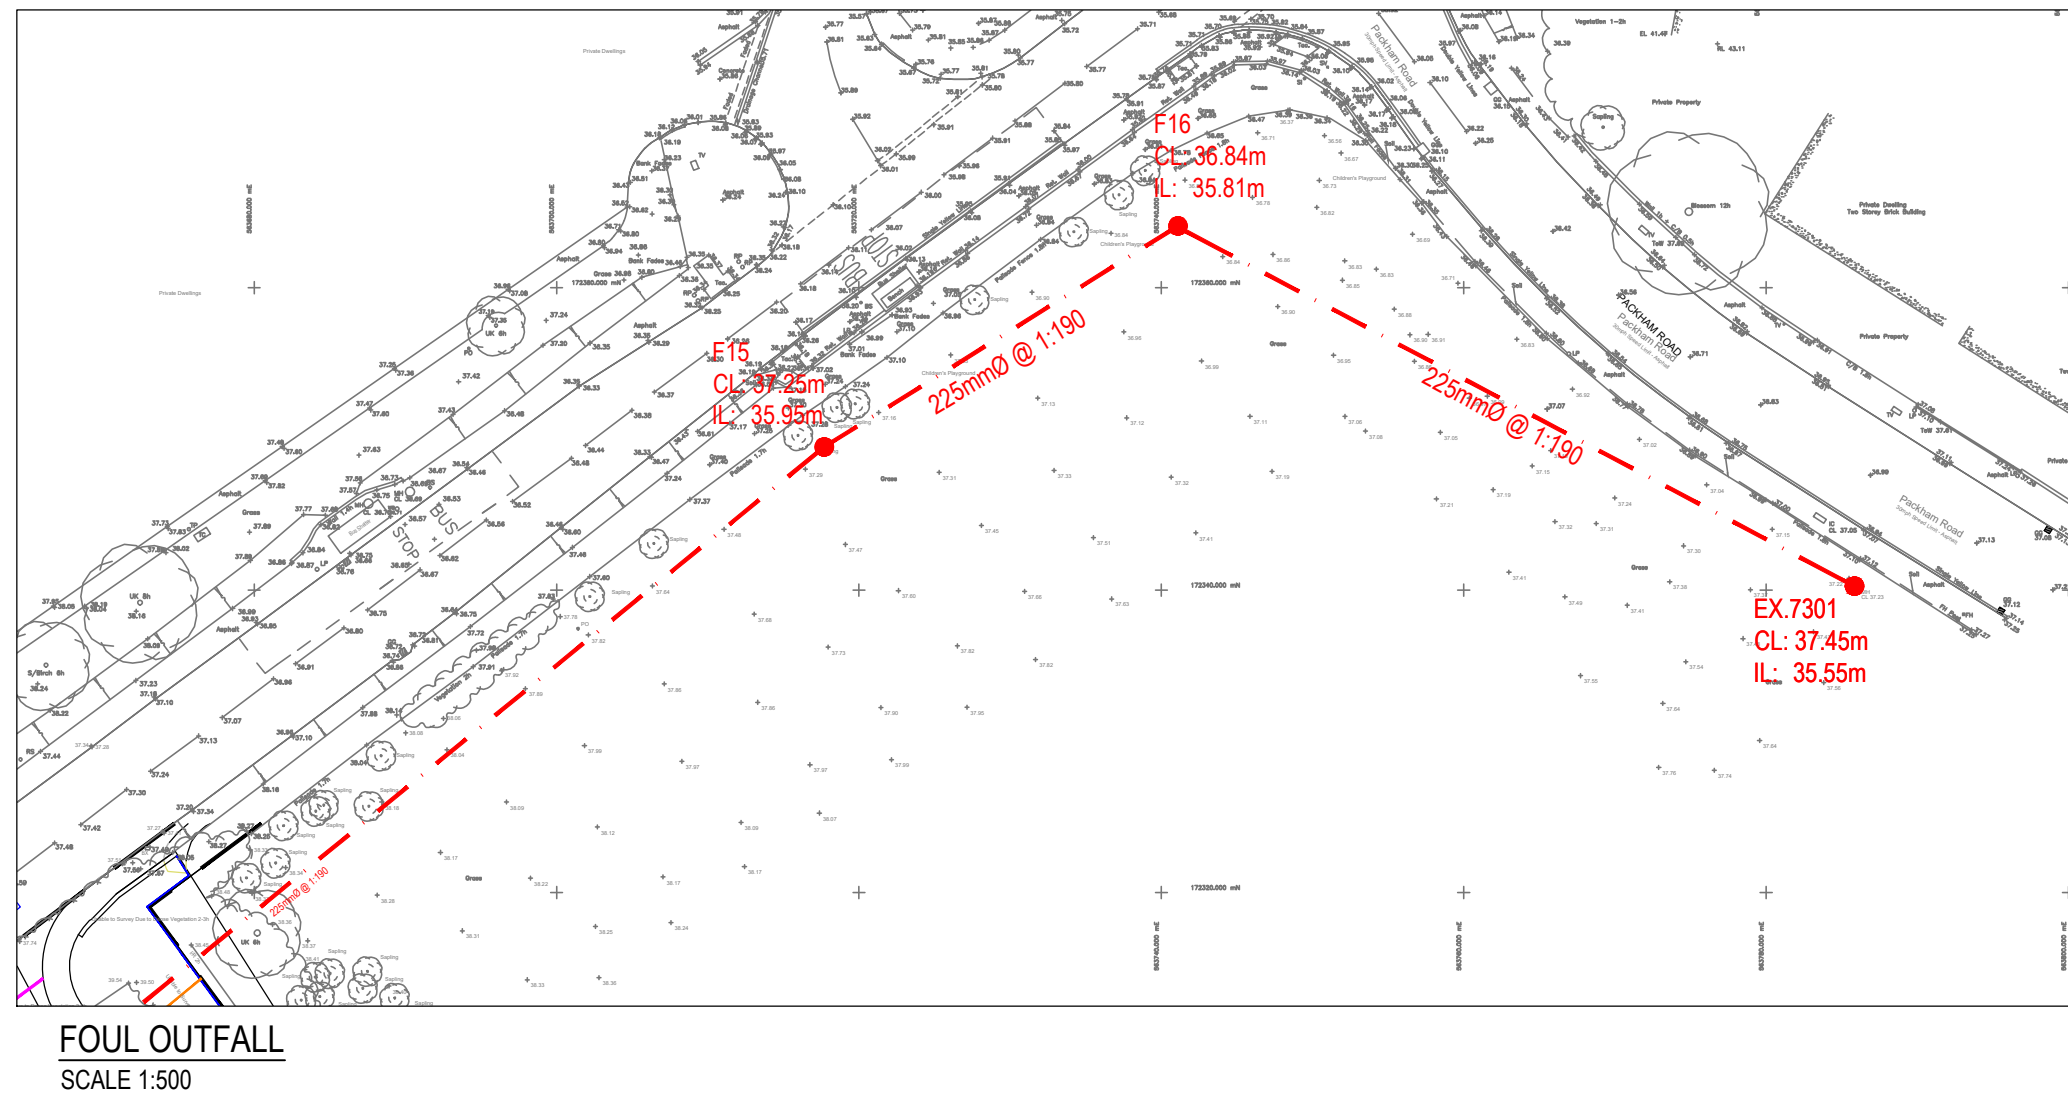
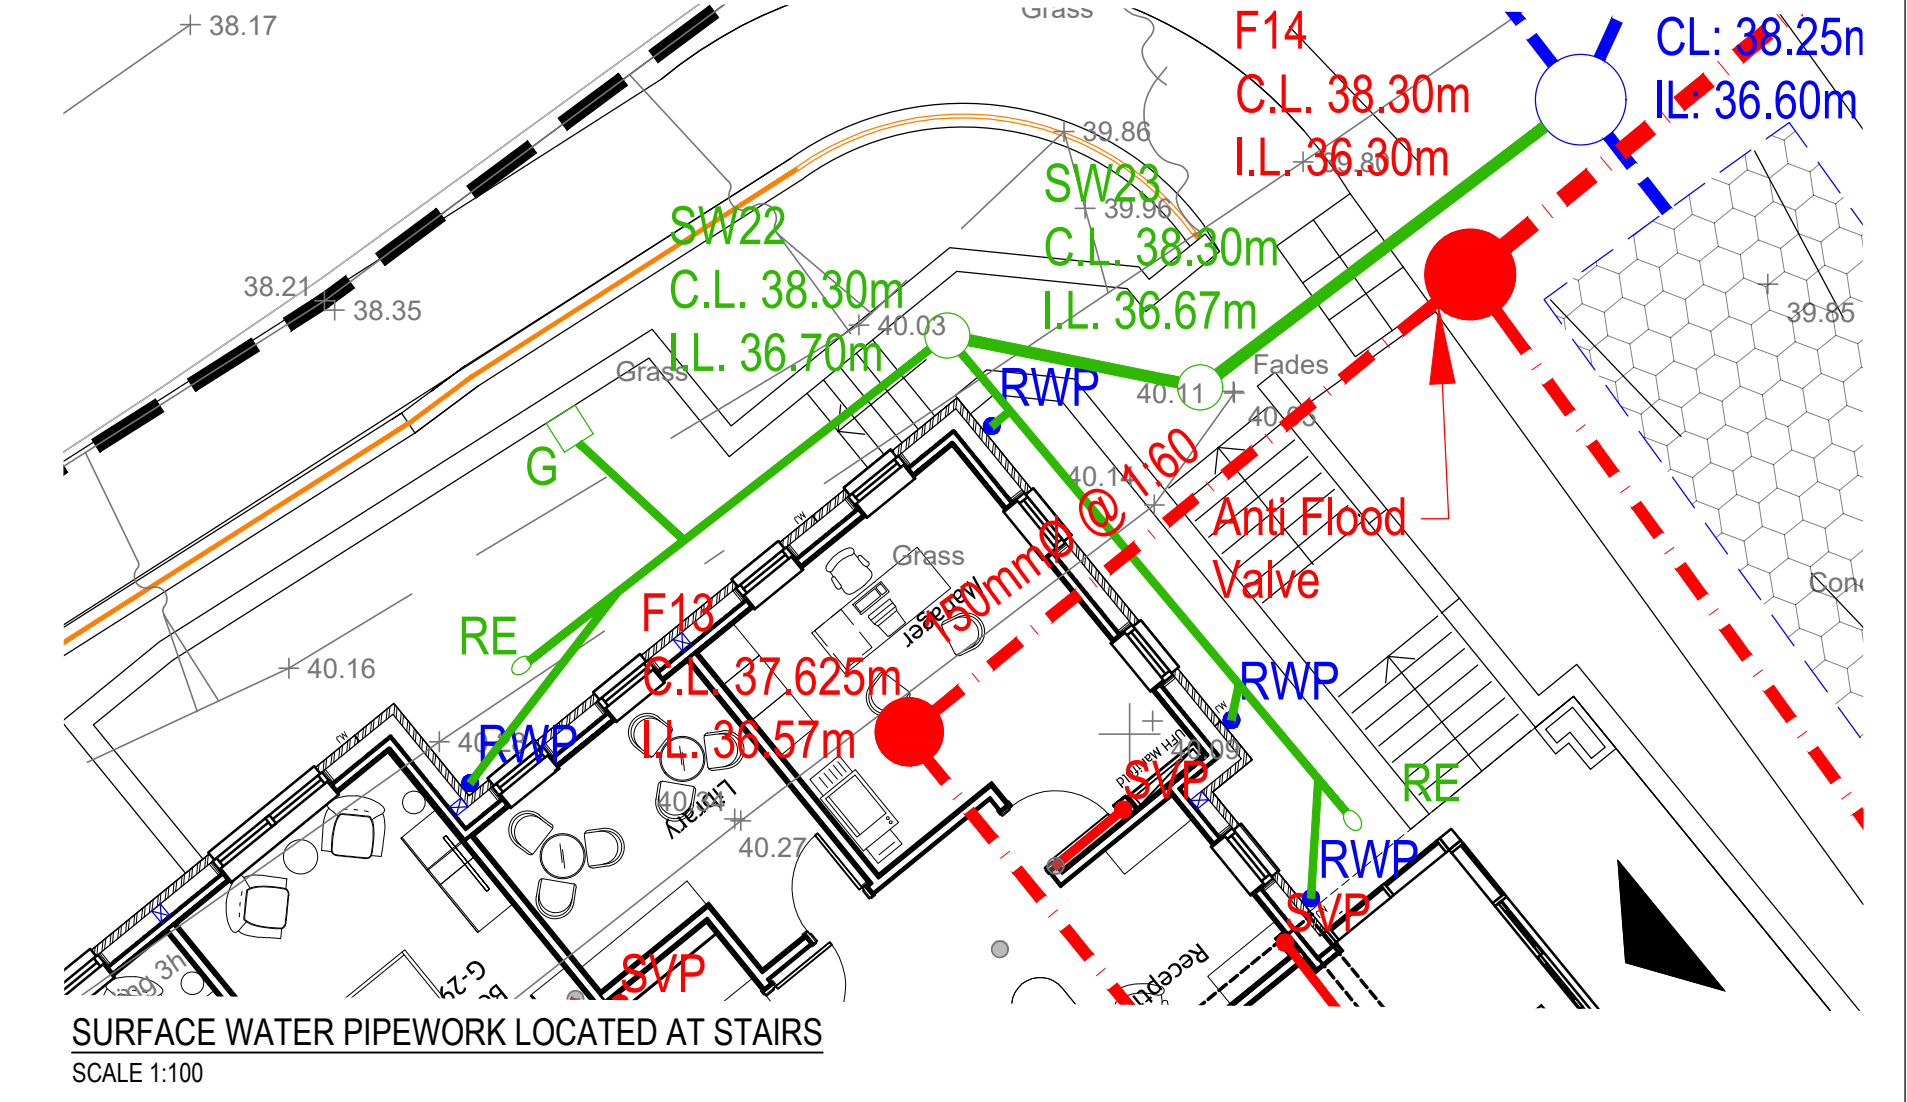


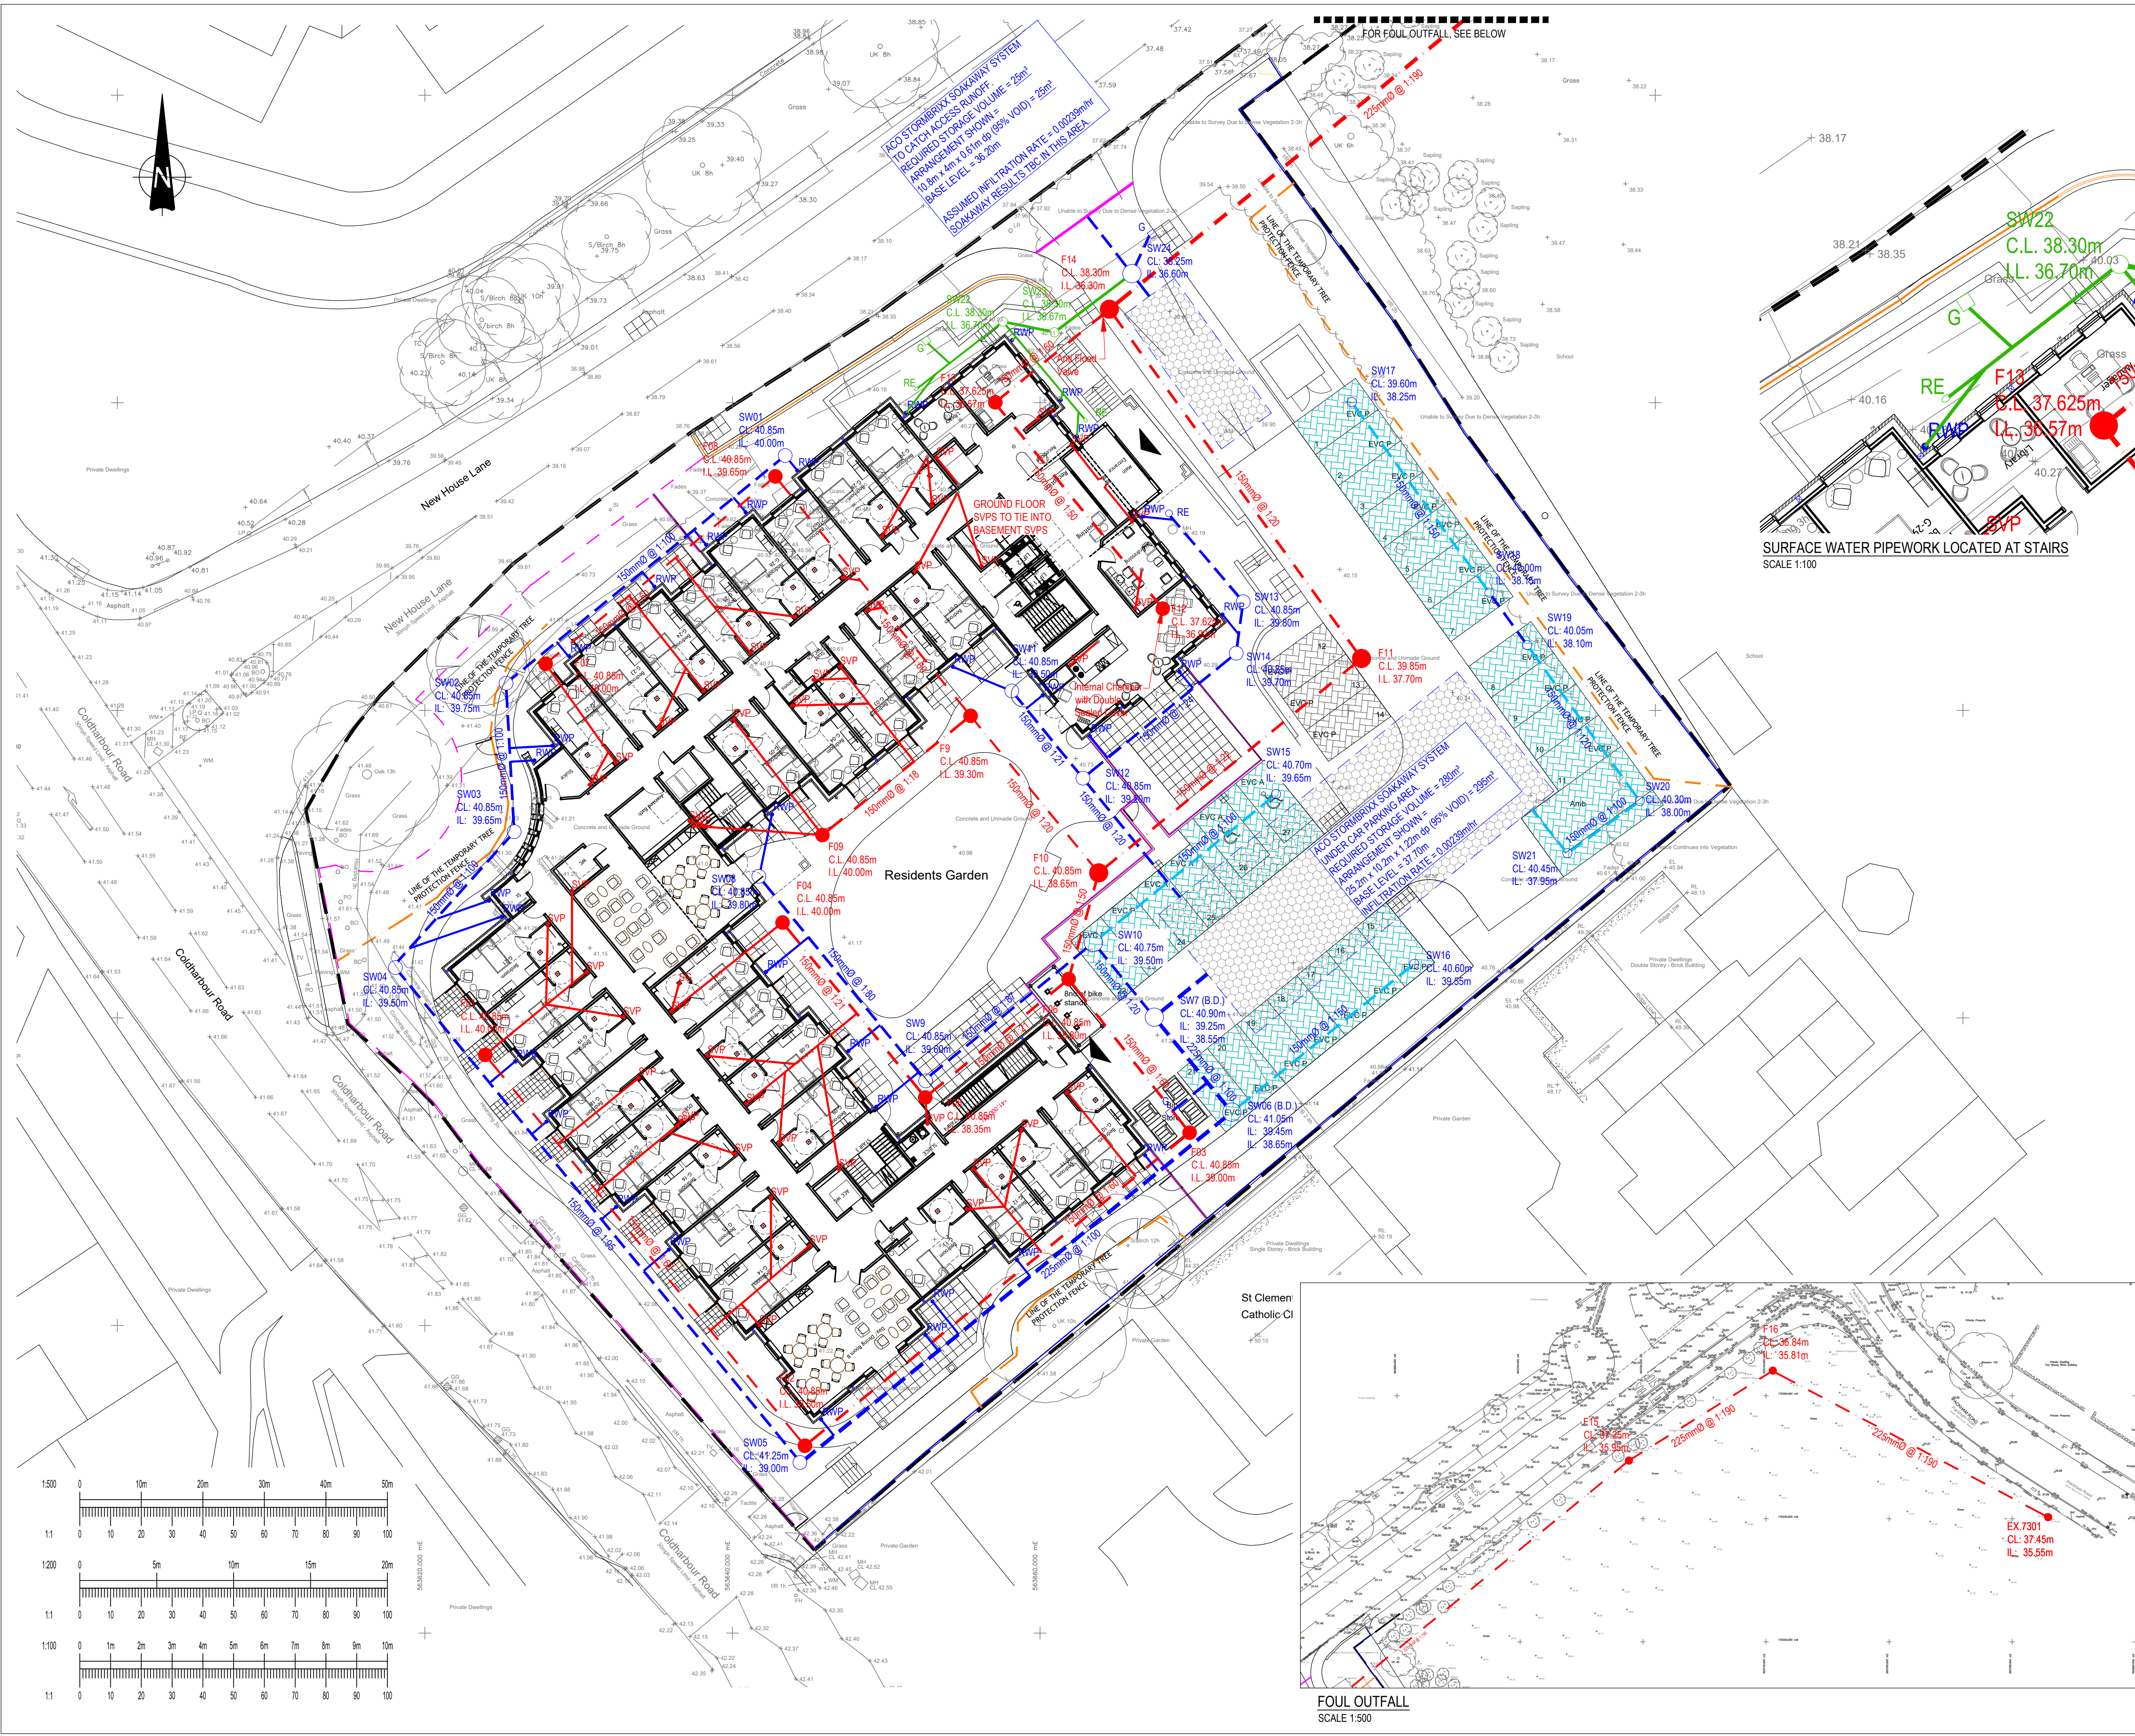

LEGEND:				
—	SURFACE WATER - SOLID WALL PIPEWORK			
---	SURFACE WATER - PERFORATED PIPEWORK			
---	SURFACE WATER - BASEMENT LEVEL PIPEWORK			
---	FOUL PIPEWORK			
RE	RODDING EYE			
	PERMEABLE BLOCK PAVING			
	NON-PERMEABLE BLOCK PAVING			
	ROAD GULLY			

H	COVER & INVERT LEVELS UPDATED	21.05.24	FM	
G	SHOWER GULLIES REMOVED.	15.05.24	FM	BM
F	BASEMENT POP UP LOCATIONS REVISED	14.05.24	FM	BM
E	DRAINAGE BROUGHT WITHIN SITE			
C	CARTILAGE			
D	TAILS & FOUL OUTFALL REVISED	08.05.24	FM	BM
S	SVPS REVISED	24.04.24	FM	BM
C	FOUL DRAINAGE REVISED	28.03.24	EM	FM
B	SUB-STATION REMOVED	27.03.24	FM	BM
A	SV P PIPE LOCATIONS ADDED	18.03.24	EM	FM
Rev.	Description	Date	Initials	Checked
Status COSNSTRUCTION				
Client SIMPLY UK				
Location COLDHARBOUR ROAD, NORTHFLEET, GRAVESEND, DA11 8NT				
Drawing Title DRAINAGE LAYOUT				
Date JAN 24	Drawn by FM	Scale 1:100	Checked BM	Date JAN 24
Project Ref. 9630	Dwg. No. C002	Rev. H		

CHARLES SCOTT & PARTNERS
CONSULTING ENGINEERS

Venlaw Building
349 Bath Street
Glasgow G2 4AA
Tel : 0141-331-2454
Fax 0141-332-2873
www.csandp.co.uk