
 


SITE LOCATION

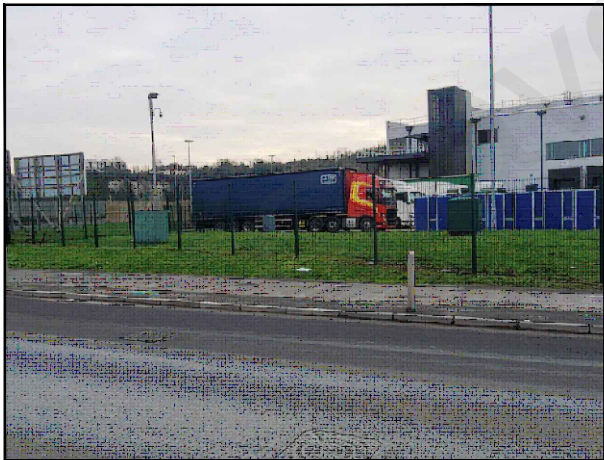


Reproduced by permission of Ordnance Survey on behalf of the Controller of Her Majesty's Stationary Office
All rights reserved. © Crown Copyright licence no. 100062043

SITE AREA PLAN




SITE PHOTOGRAPH

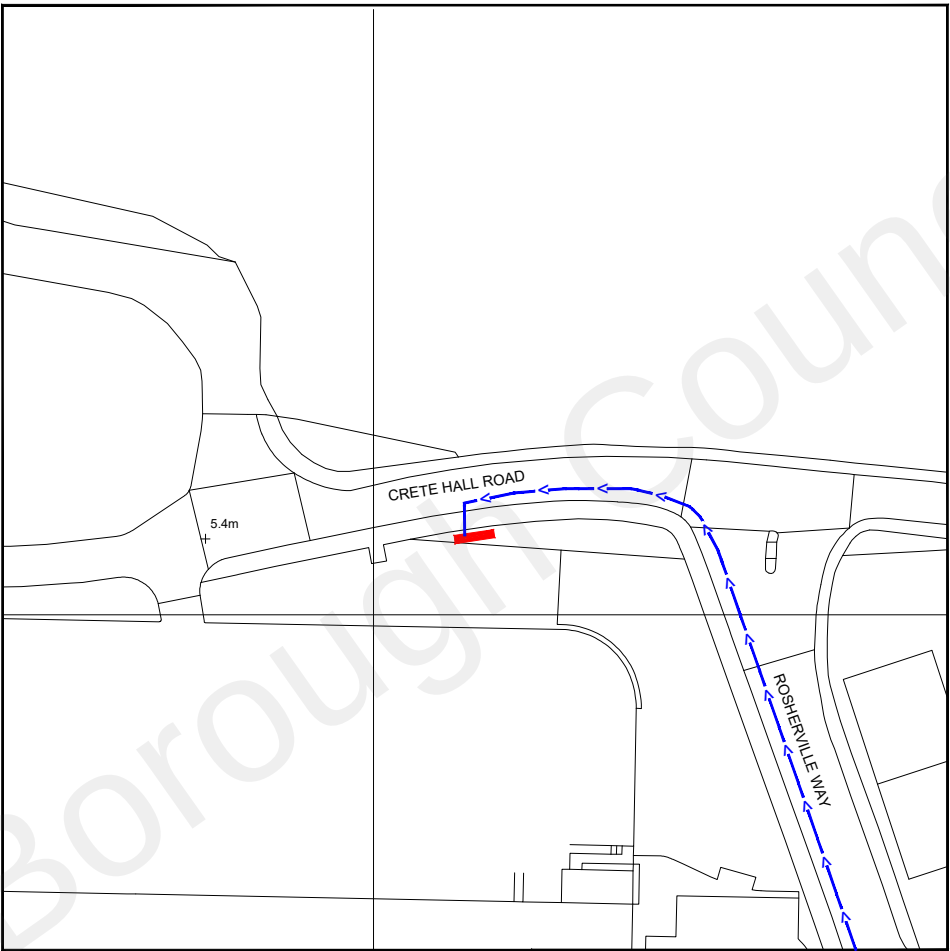

Reproduced by permission of Ordnance Survey on behalf of the Controller of Her Majesty's Stationary Office
All rights reserved. © Crown Copyright licence no. 100062043

 SITE LOCATION PLAN



GOOGLE MAPS QR CODE

GOOGLE MAPS - <https://goo.gl/maps/GacdKKSW7kqvJmb39>

GOOGLE STREETVIEW - <https://goo.gl/maps/geY89zeaoyqBFcbp9>

NOTES:

1. ALL DIMENSIONS IN MM UNLESS OTHERWISE NOTED.

DIRECTIONS TO SITE:

Head northeast on M25. Take the exit toward Dartford/A225/Canterbury/M2. At Darenth Interchange, take the 4th exit onto the A2 ramp to M2/Canterbury. Merge onto A2. Take the A2260 exit toward Northfleet/Gravesend(W)/Ebbseet International. At the roundabout, take the 2nd exit onto the B262 ramp to Northfleet/Gravesend(W)/Longeld/B260. Keep left, follow signs for Northfleet/Gravesend(W)/B262/Longeld/B260 and merge onto Hall Rd/B262. Merge onto Hall Rd/B262. At the roundabout, take the 2nd exit onto Springhead Rd/B262. At the roundabout, take the 3rd exit onto Thames Way/A226. At the roundabout, take the 2nd exit onto Rosherville Way. Turn left onto Crete Hall Rd. Follow Crete Hall Rd and site location is on the left hand side.

Site Provider's

Property Boundary:



Access Route To Site:



Access Route:



Master:	MBNL / EE / H3G:	Project:	Purpose of Issue:	Issue:
M004	MBNL	3UK DNSW	Planning	D
Date:	15/07/2022	Revision / Upgrade Description:		
Drawn:	CDN	Pole Height reduced to 15m.		
Checked:	DH	Vis Splay Plan added		
Approved:	SD			
Master:	MBNL / EE / H3G:	Project:	Purpose of Issue:	Issue:
M003	MBNL	3UK DNSW	Planning	C
Date:	20/05/2022	Revision / Upgrade Description:		
Drawn:	CDN	Amended to standard		
Checked:	DH			
Approved:	SD			
Master:	MBNL / EE / H3G:	Project:	Purpose of Issue:	Issue:
M002	MBNL	3UK DNSW	Planning	B
Date:	15/01/2021	Revision / Upgrade Description:		
Drawn:	CDN	Pole location amended		
Checked:	DH			
Approved:	SD			
Master:	MBNL / EE / H3G:	Project:	Purpose of Issue:	Issue:
M001	MBNL	3UK DNSW	Planning	A
Date:	04/05/2020	Revision / Upgrade Description:		
Drawn:	CDN	First Issue - Site nomination dated: TBC		
Checked:	DH			
Approved:	SD			

CK Hutchison
Networks (UK)
Limited

Great Brighams Mead,
Vastern Road, Reading,
Berkshire, England,
RG1 8DJ

Design Consultant & Principal Contractor:




WHP Telecoms

Unit 1 Maple Park,
Low Fields Avenue, Leeds
LS12 6HH

Tel: 01133023550
e-mail: info@whptelecoms.com

Site Name:	CRETE HALL ROAD		
Site ID:	GVM30742		
Address:	CRETE HALL ROAD, GRAVESHAM, KENT, SOUTH EAST, DA11 9BU		
Title:	002 SITE LOCATION PLAN		
Project:	3UK DNSW		
Purpose of Issue:	PLANNING		
EE Cell ID:	71831	MBNL Cell ID:	GVM071
3UK Cell ID:	DA0500		
Master Drawing No:	GVM30742_M004		Issue:
			D

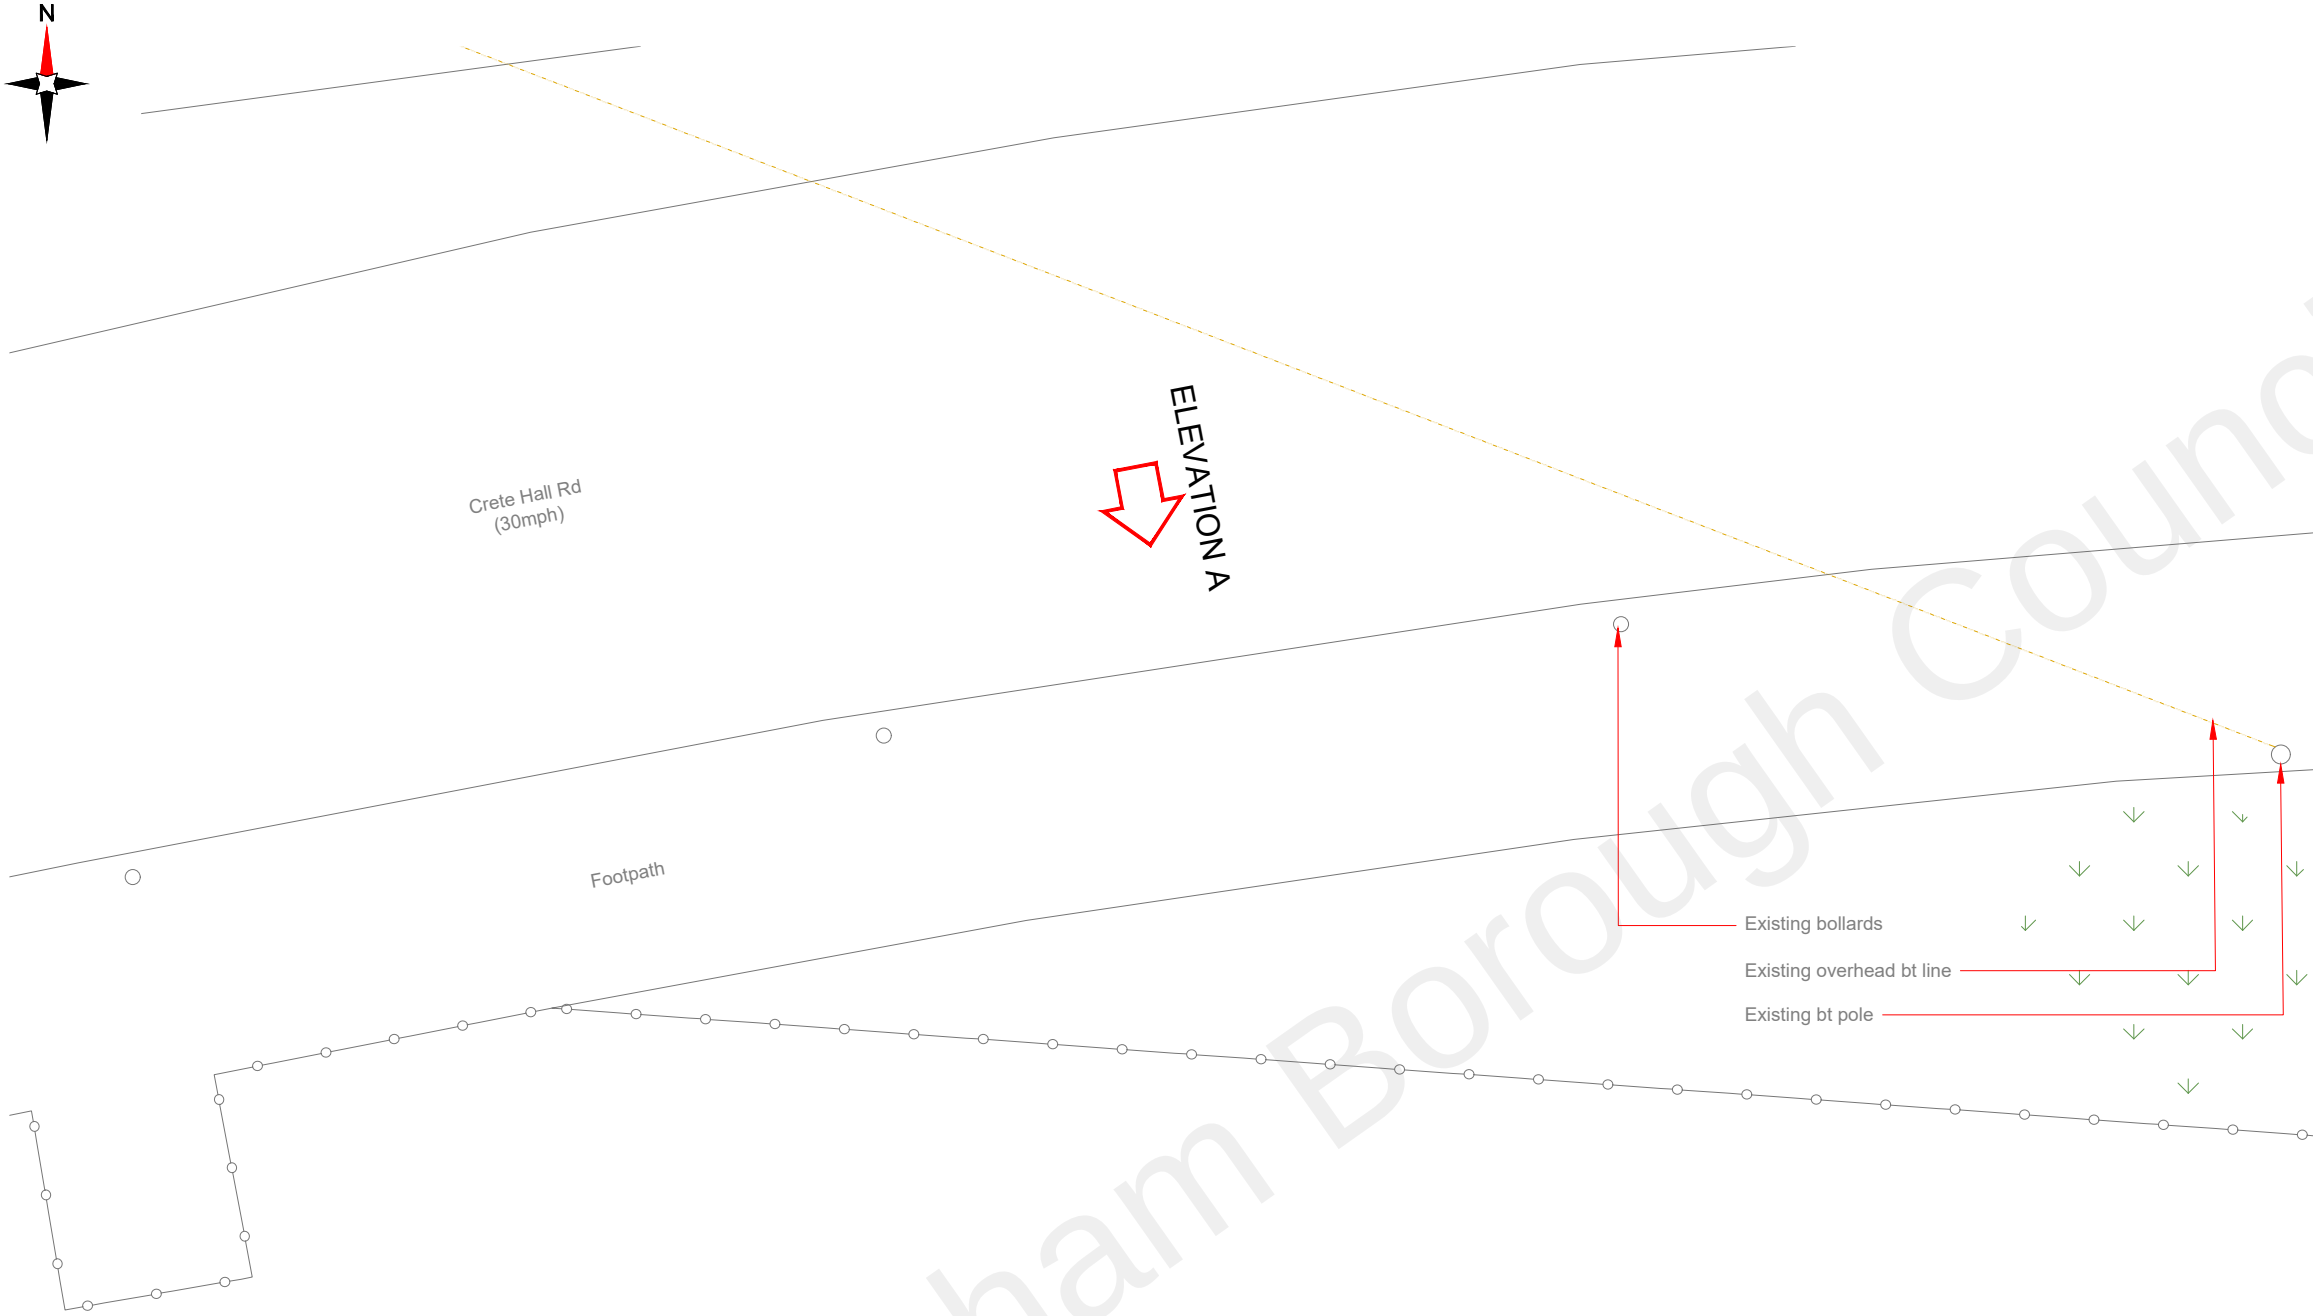

- NOTES:
- ALL DIMENSIONS IN MM UNLESS OTHERWISE NOTED.

Master:	MBNL / EE / H3G:	Project:	Purpose of Issue:	Issue:
M004	MBNL	3UK DNSW	Planning	D
Date:	15/07/2022	Revision / Upgrade Description:		
Drawn:	CDN	Pole Height reduced to 15m.		
Checked:	DH	Vis Splay Plan added		
Approved:	SD			
Master:	MBNL / EE / H3G:	Project:	Purpose of Issue:	Issue:
M003	MBNL	3UK DNSW	Planning	C
Date:	20/05/2022	Revision / Upgrade Description:		
Drawn:	CDN	Amended to standard		
Checked:	DH			
Approved:	SD			
Master:	MBNL / EE / H3G:	Project:	Purpose of Issue:	Issue:
M002	MBNL	3UK DNSW	Planning	B
Date:	15/01/2021	Revision / Upgrade Description:		
Drawn:	CDN	Pole location amended		
Checked:	DH			
Approved:	SD			
Master:	MBNL / EE / H3G:	Project:	Purpose of Issue:	Issue:
M001	MBNL	3UK DNSW	Planning	A
Date:	04/05/2020	Revision / Upgrade Description:		
Drawn:	CDN	First Issue - Site nomination dated: TBC		
Checked:	DH			
Approved:	SD			

**CK Hutchison
Networks (UK)
Limited**
Great Brighams Mead,
Vastern Road, Reading,
Berkshire, England,
RG1 8DJ



WHP Telecoms
Unit 1 Maple Park,
Low Fields Avenue, Leeds
LS12 6HH


Tel: 01133023550
e-mail: info@whptelecoms.com

Site Name:	CRETE HALL ROAD		
Site ID:	GVM30742		
Address:	CRETE HALL ROAD, GRAVESHAM, KENT, SOUTH EAST, DA11 9BU		
Title:	100 EXISTING SITE PLAN		
Project:	3UK DNSW		
Purpose of Issue:	PLANNING		
EE Cell ID: 71831	MBNL Cell ID: GVM071	3UK Cell ID: DA0500	
Master Drawing No: GVM30742_M004			Issue: D

100mm

150mm

10mm

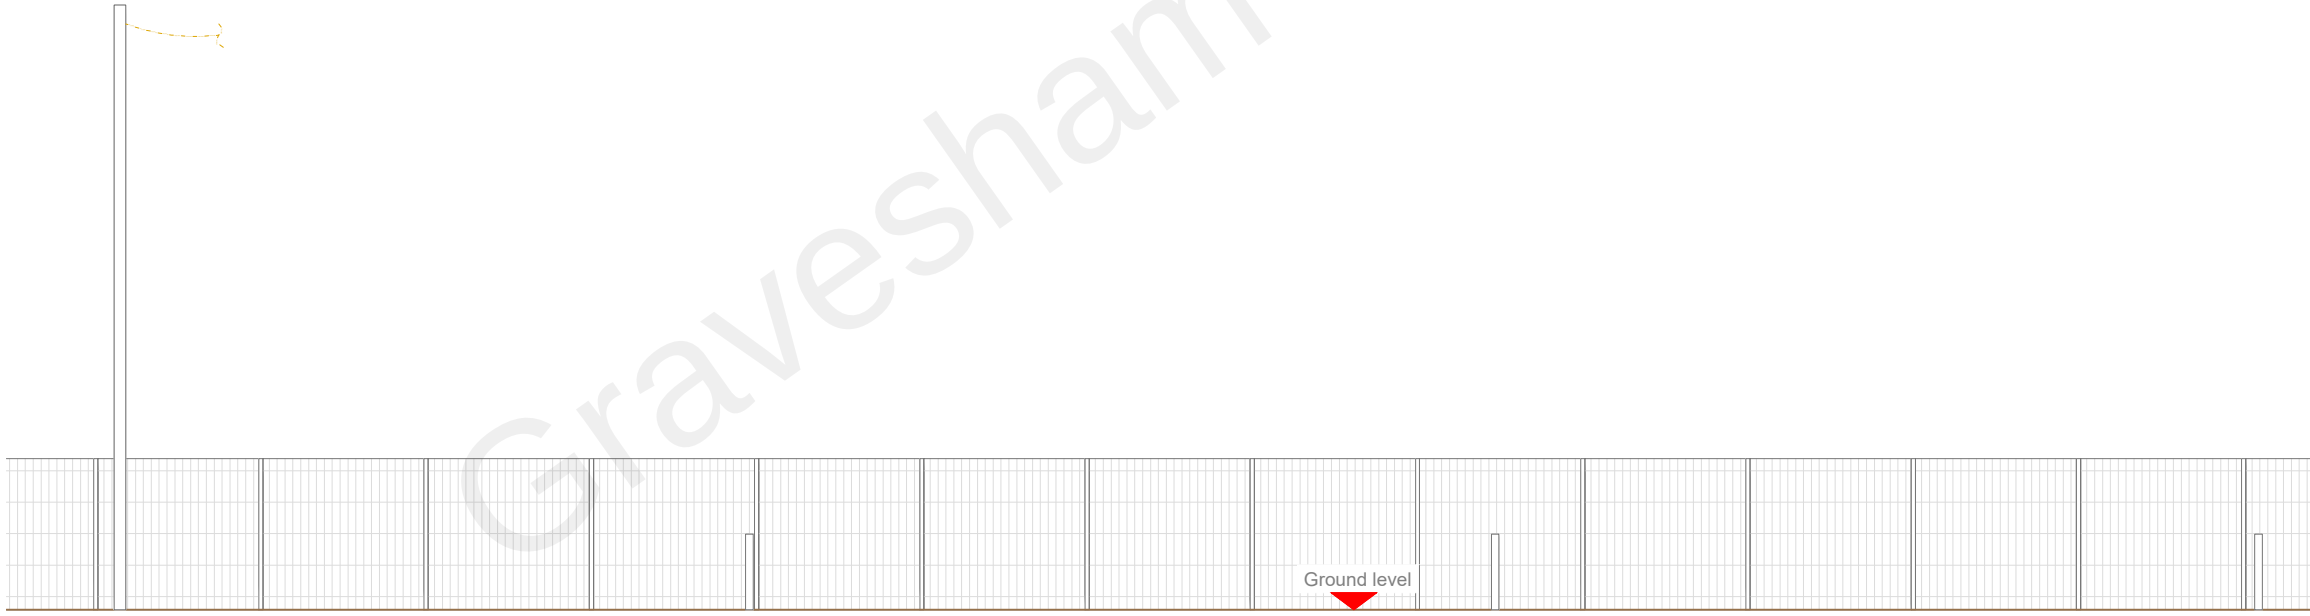

- NOTES:
- ALL DIMENSIONS IN MM UNLESS OTHERWISE NOTED.

Master:	MBNL / EE / H3G:	Project:	Purpose of Issue:	Issue:
M004	MBNL	3UK DNSW	Planning	D
Date:	15/07/2022	Revision / Upgrade Description:		
Drawn:	CDN	Pole Height reduced to 15m.		
Checked:	DH	Vis Splay Plan added		
Approved:	SD			
Master:	MBNL / EE / H3G:	Project:	Purpose of Issue:	Issue:
M003	MBNL	3UK DNSW	Planning	C
Date:	20/05/2022	Revision / Upgrade Description:		
Drawn:	CDN	Amended to standard		
Checked:	DH			
Approved:	SD			
Master:	MBNL / EE / H3G:	Project:	Purpose of Issue:	Issue:
M002	MBNL	3UK DNSW	Planning	B
Date:	15/01/2021	Revision / Upgrade Description:		
Drawn:	CDN	Pole location amended		
Checked:	DH			
Approved:	SD			
Master:	MBNL / EE / H3G:	Project:	Purpose of Issue:	Issue:
M001	MBNL	3UK DNSW	Planning	A
Date:	04/05/2020	Revision / Upgrade Description:		
Drawn:	CDN	First Issue - Site nomination dated: TBC		
Checked:	DH			
Approved:	SD			

CK Hutchison
Networks (UK)
Limited
Great Brighams Mead,
Vastern Road, Reading,
Berkshire, England,
RG1 8DJ

Design Consultant & Principal Contractor:



WHP Telecoms
Unit 1 Maple Park,
Low Fields Avenue, Leeds
LS12 6HH

Tel: 01133023550
e-mail: info@whptelecoms.com

Site Name: CRETE HALL ROAD

Site ID: GVM30742

Address: CRETE HALL ROAD,
GRAVESHAM, KENT,
SOUTH EAST,
DA11 9BU

Title: 150 EXISTING ELEVATION A

Project: 3UK DNSW

Purpose of Issue: PLANNING

EE Cell ID:	MBNL Cell ID:	3UK Cell ID:
71831	GVM071	DA0500
Master Drawing No: GVM30742_M004		
Issue: D		



Crete Hall Rd
(30mph)

ELEVATION A

Footpath

8500

1325

950

Existing bollards



Existing overhead bt line

Existing bt pole


Proposed G-100876 cabinet to be painted Fir Green (RAL6009)

Proposed 2No. cabinets to be painted Fir Green (RAL6009)

Proposed Phase 8 monopole c/w wraparound cabinet at base to be painted Fir Green (RAL6009)

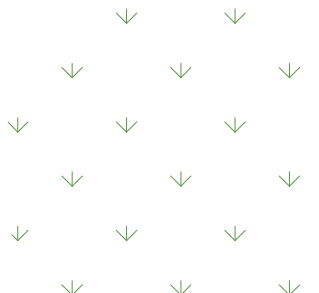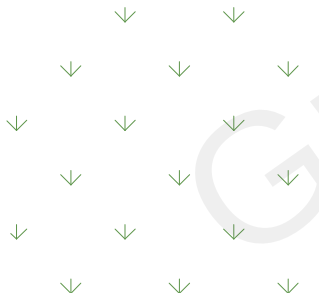

PROPOSED SITE PLAN

 

Antenna Aperture ID	Proposed 4G/5G Bearing	Operator:
A1	340°	-
A2	340°	-
B1	100°	-
B2	100°	-
C1	220°	-
C2	220°	-

NOTES:
1. ALL DIMENSIONS IN MM UNLESS OTHERWISE NOTED.

Master:	MBNL / EE / H3G:	Project:	Purpose of Issue:	Issue:
M004	MBNL	3UK DNSW	Planning	D
Date:	15/07/2022	Revision / Upgrade Description:		
Drawn:	CDN	Pole Height reduced to 15m.		
Checked:	DH	Vis Splay Plan added		
Approved:	SD			
Master:	MBNL / EE / H3G:	Project:	Purpose of Issue:	Issue:
M003	MBNL	3UK DNSW	Planning	C
Date:	20/05/2022	Revision / Upgrade Description:		
Drawn:	CDN	Amended to standard		
Checked:	DH			
Approved:	SD			
Master:	MBNL / EE / H3G:	Project:	Purpose of Issue:	Issue:
M002	MBNL	3UK DNSW	Planning	B
Date:	15/01/2021	Revision / Upgrade Description:		
Drawn:	CDN	Pole location amended		
Checked:	DH			
Approved:	SD			
Master:	MBNL / EE / H3G:	Project:	Purpose of Issue:	Issue:
M001	MBNL	3UK DNSW	Planning	A
Date:	04/05/2020	Revision / Upgrade Description:		
Drawn:	CDN	First Issue - Site nomination dated: TBC		
Checked:	DH			
Approved:	SD			

CK Hutchison
Networks (UK)
Limited

Great Brighams Mead,
Vastern Road, Reading,
Berkshire, England,
RG1 8DJ

Design Consultant & Principal Contractor:



WHP Telecoms

Unit 1 Maple Park,
Low Fields Avenue, Leeds
LS12 6HH

Tel: 01133023550
e-mail: info@whptelecoms.com

Site Name:
CRETE HALL ROAD

Site ID:
GVM30742

Address:
CRETE HALL ROAD,
GRAVESHAM, KENT,
SOUTH EAST,
DA11 9BU

Title:
210 PROPOSED SITE PLAN

Project:
3UK DNSW

Purpose of Issue:
PLANNING

EE Cell ID: 71831	MBNL Cell ID: GVM071	3UK Cell ID: DA0500
----------------------	-------------------------	------------------------

Master Drawing No: GVM30742_M004	Issue: D
-------------------------------------	-------------



Antenna Aperture ID	Proposed 4G/5G Bearing	Operator
A1	340°	-
A2	340°	-
B1	100°	-
B2	100°	-
C1	220°	-
C2	220°	-

NOTES:
1. ALL DIMENSIONS IN MM UNLESS OTHERWISE NOTED.

Master:	MBNL / EE / H3G:	Project:	Purpose of Issue:	Issue:
M004	MBNL	3UK DNSW	Planning	D
Date:	15/07/2022	Revision / Upgrade Description:		
Drawn:	CDN	Pole Height reduced to 15m.		
Checked:	DH	Vis Splay Plan added		
Approved:	SD			
Master:	MBNL / EE / H3G:	Project:	Purpose of Issue:	Issue:
M003	MBNL	3UK DNSW	Planning	C
Date:	20/05/2022	Revision / Upgrade Description:		
Drawn:	CDN	Amended to standard		
Checked:	DH			
Approved:	SD			
Master:	MBNL / EE / H3G:	Project:	Purpose of Issue:	Issue:
M002	MBNL	3UK DNSW	Planning	B
Date:	15/01/2021	Revision / Upgrade Description:		
Drawn:	CDN	Pole location amended		
Checked:	DH			
Approved:	SD			
Master:	MBNL / EE / H3G:	Project:	Purpose of Issue:	Issue:
M001	MBNL	3UK DNSW	Planning	A
Date:	04/05/2020	Revision / Upgrade Description:		
Drawn:	CDN	First Issue - Site nomination dated: TBC		
Checked:	DH			
Approved:	SD			

CK Hutchison
Networks (UK)
Limited

Great Brighams Mead,
Vastern Road, Reading,
Berkshire, England,
RG1 8DJ

Design Consultant & Principal Contractor:



WHP Telecoms

Unit 1 Maple Park,
Low Fields Avenue, Leeds
LS12 6HH

Tel: 01133023550
e-mail: info@whptelecoms.com

Site Name: CRETE HALL ROAD

Site ID: GVM30742

Address: CRETE HALL ROAD,
GRAVESHAM, KENT,
SOUTH EAST,
DA11 9BU


Title: 211 VIS SPLAY PLAN

Project: 3UK DNSW


Purpose of Issue: PLANNING

EE Cell ID: 71831	MBNL Cell ID: GVM071	3UK Cell ID: DA0500
----------------------	-------------------------	------------------------

Master Drawing No: GVM30742_M004	Issue: D
-------------------------------------	-------------

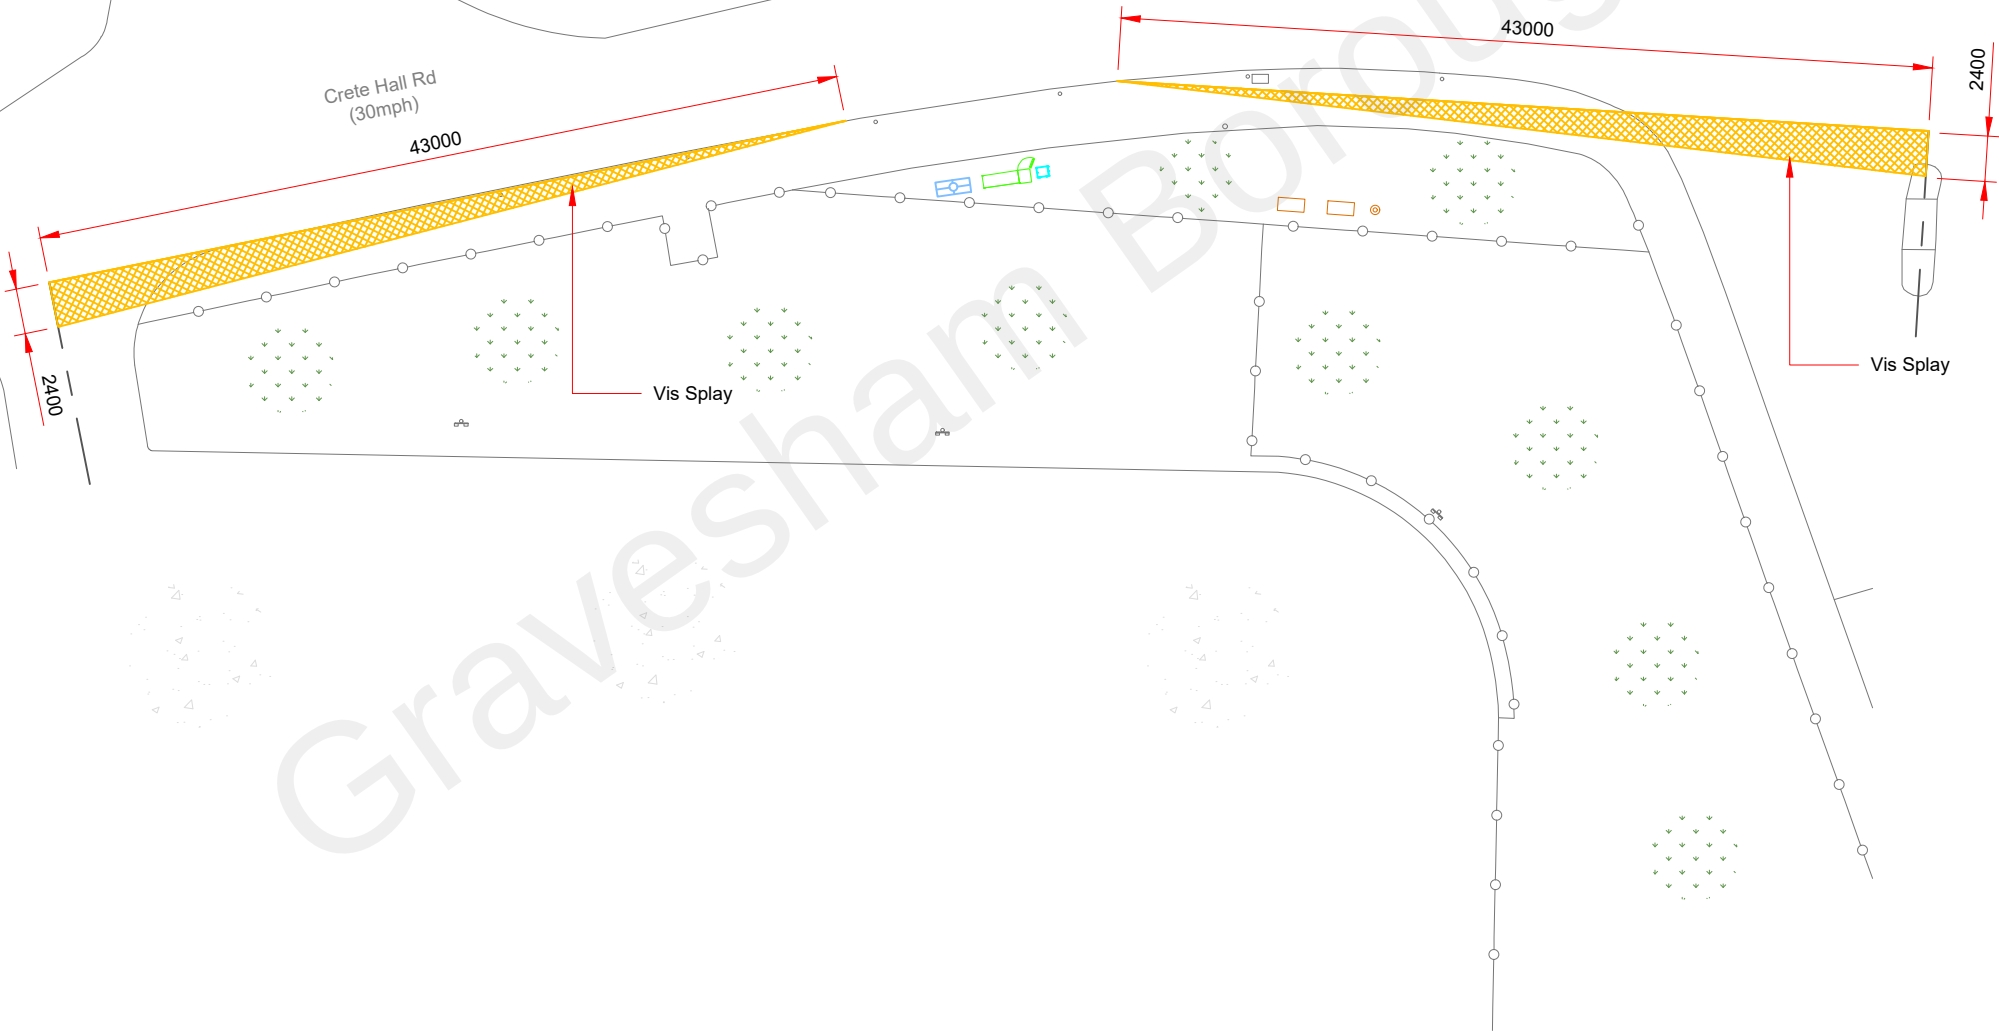

VIS SPLAY PLAN

 


100mm

50mm

10mm

Antenna Aperture ID	Proposed 4G/5G Bearing	Operator:
A1	340°	-
A2	340°	-
B1	100°	-
B2	100°	-
C1	220°	-
C2	220°	-

NOTES:
1. ALL DIMENSIONS IN MM UNLESS OTHERWISE NOTED.

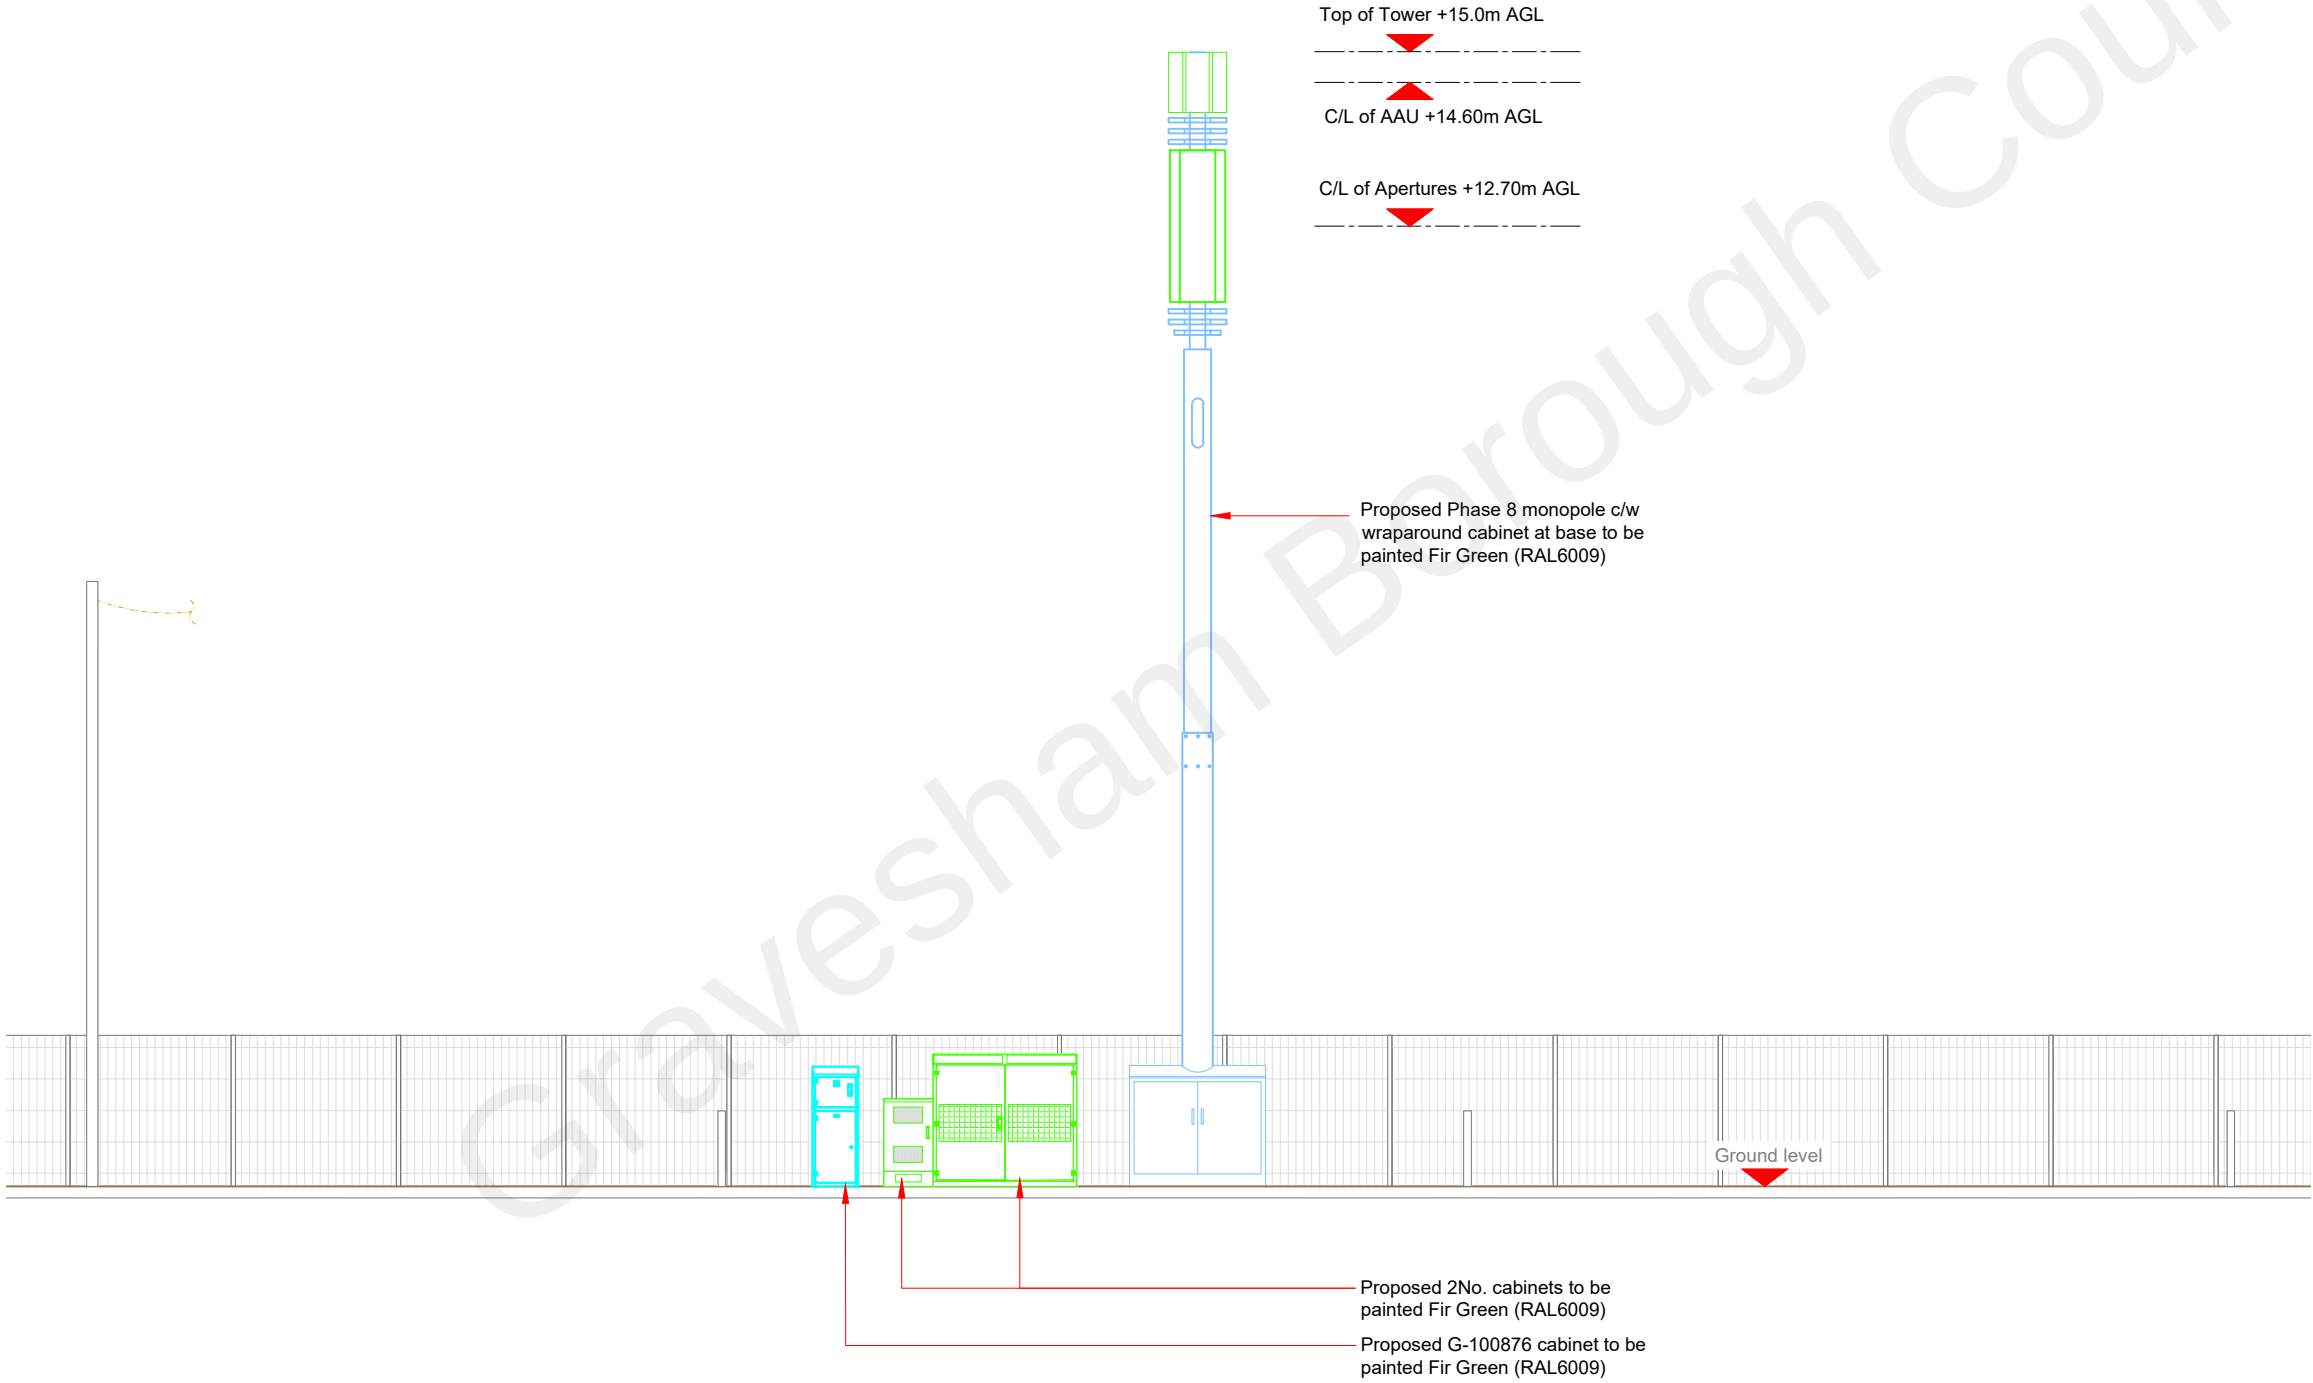

CK Hutchison Networks (UK) Limited
Great Brighams Mead,
Vastern Road, Reading,
Berkshire, England,
RG1 8DJ



WHP Telecoms
Unit 1 Maple Park,
Low Fields Avenue, Leeds
LS12 6HH
Tel: 01133023550
e-mail: info@whptelecoms.com

Site Name: **CRETE HALL ROAD**

Site ID: **GVM30742**

Address: **CRETE HALL ROAD,
GRAVESHAM, KENT,
SOUTH EAST,
DA11 9BU**

Title: **260 PROPOSED ELEVATION**


Project: **3UK DNSW**

Purpose of Issue: **PLANNING**

EE Cell ID: 71831	MBNL Cell ID: GVM071	3UK Cell ID: DA0500
-----------------------------	--------------------------------	-------------------------------

Master Drawing No: GVM30742_M004	Issue: D
--	--------------------

Proposed Antenna Aperture Schedule & RF Equipment Capacity																	
Antenna Aperture ID	Antenna Aperture Size (Length x Width x Depth)	Aperture Height C/L	Aperture Max Weight (kg)	Proposed 4G/5G Bearing	Tech: 4G/5G	Operator:	Antenna Aperture Coordinates		RRU No. Max Size & Weight L=300mm W=400mm D=150mm Weight=25kg	MHA No. Max Size & Weight L=300mm W=300mm D=150mm Weight=10kg	Main Feeder			BOB Max Size & Weight (300x300x250mm & 5kg)		Active Router No. Max Size & Weight (370x260x150mm & 10kg)	Passive Router No. Max Size & Weight (350x220x150mm & 10kg)
							Eastings	Northings			Size	Length	No.	No. Top	No. Bottom		
A1	795x395x220mm	14.60m	45kg	340°	5G	-	-	-	0	0	TBC	TBC	4	1	1	1	1
A2	2009x469x206mm	12.70m	TBC	340°	4G	-	-	-	3	0	TBC	TBC	4	1	1	1	1
B1	795x395x220mm	14.60m	45kg	100°	5G	-	-	-	0	0	TBC	TBC	4	1	1	1	1
B2	2009x469x206mm	12.70m	TBC	100°	4G	-	-	-	3	0	TBC	TBC	4	1	1	1	1
C1	795x395x220mm	14.60m	45kg	220°	5G	-	-	-	0	0	TBC	TBC	4	1	1	1	1
C2	2009x469x206mm	12.70m	TBC	220°	4G	-	-	-	3	0	TBC	TBC	4	1	1	1	1

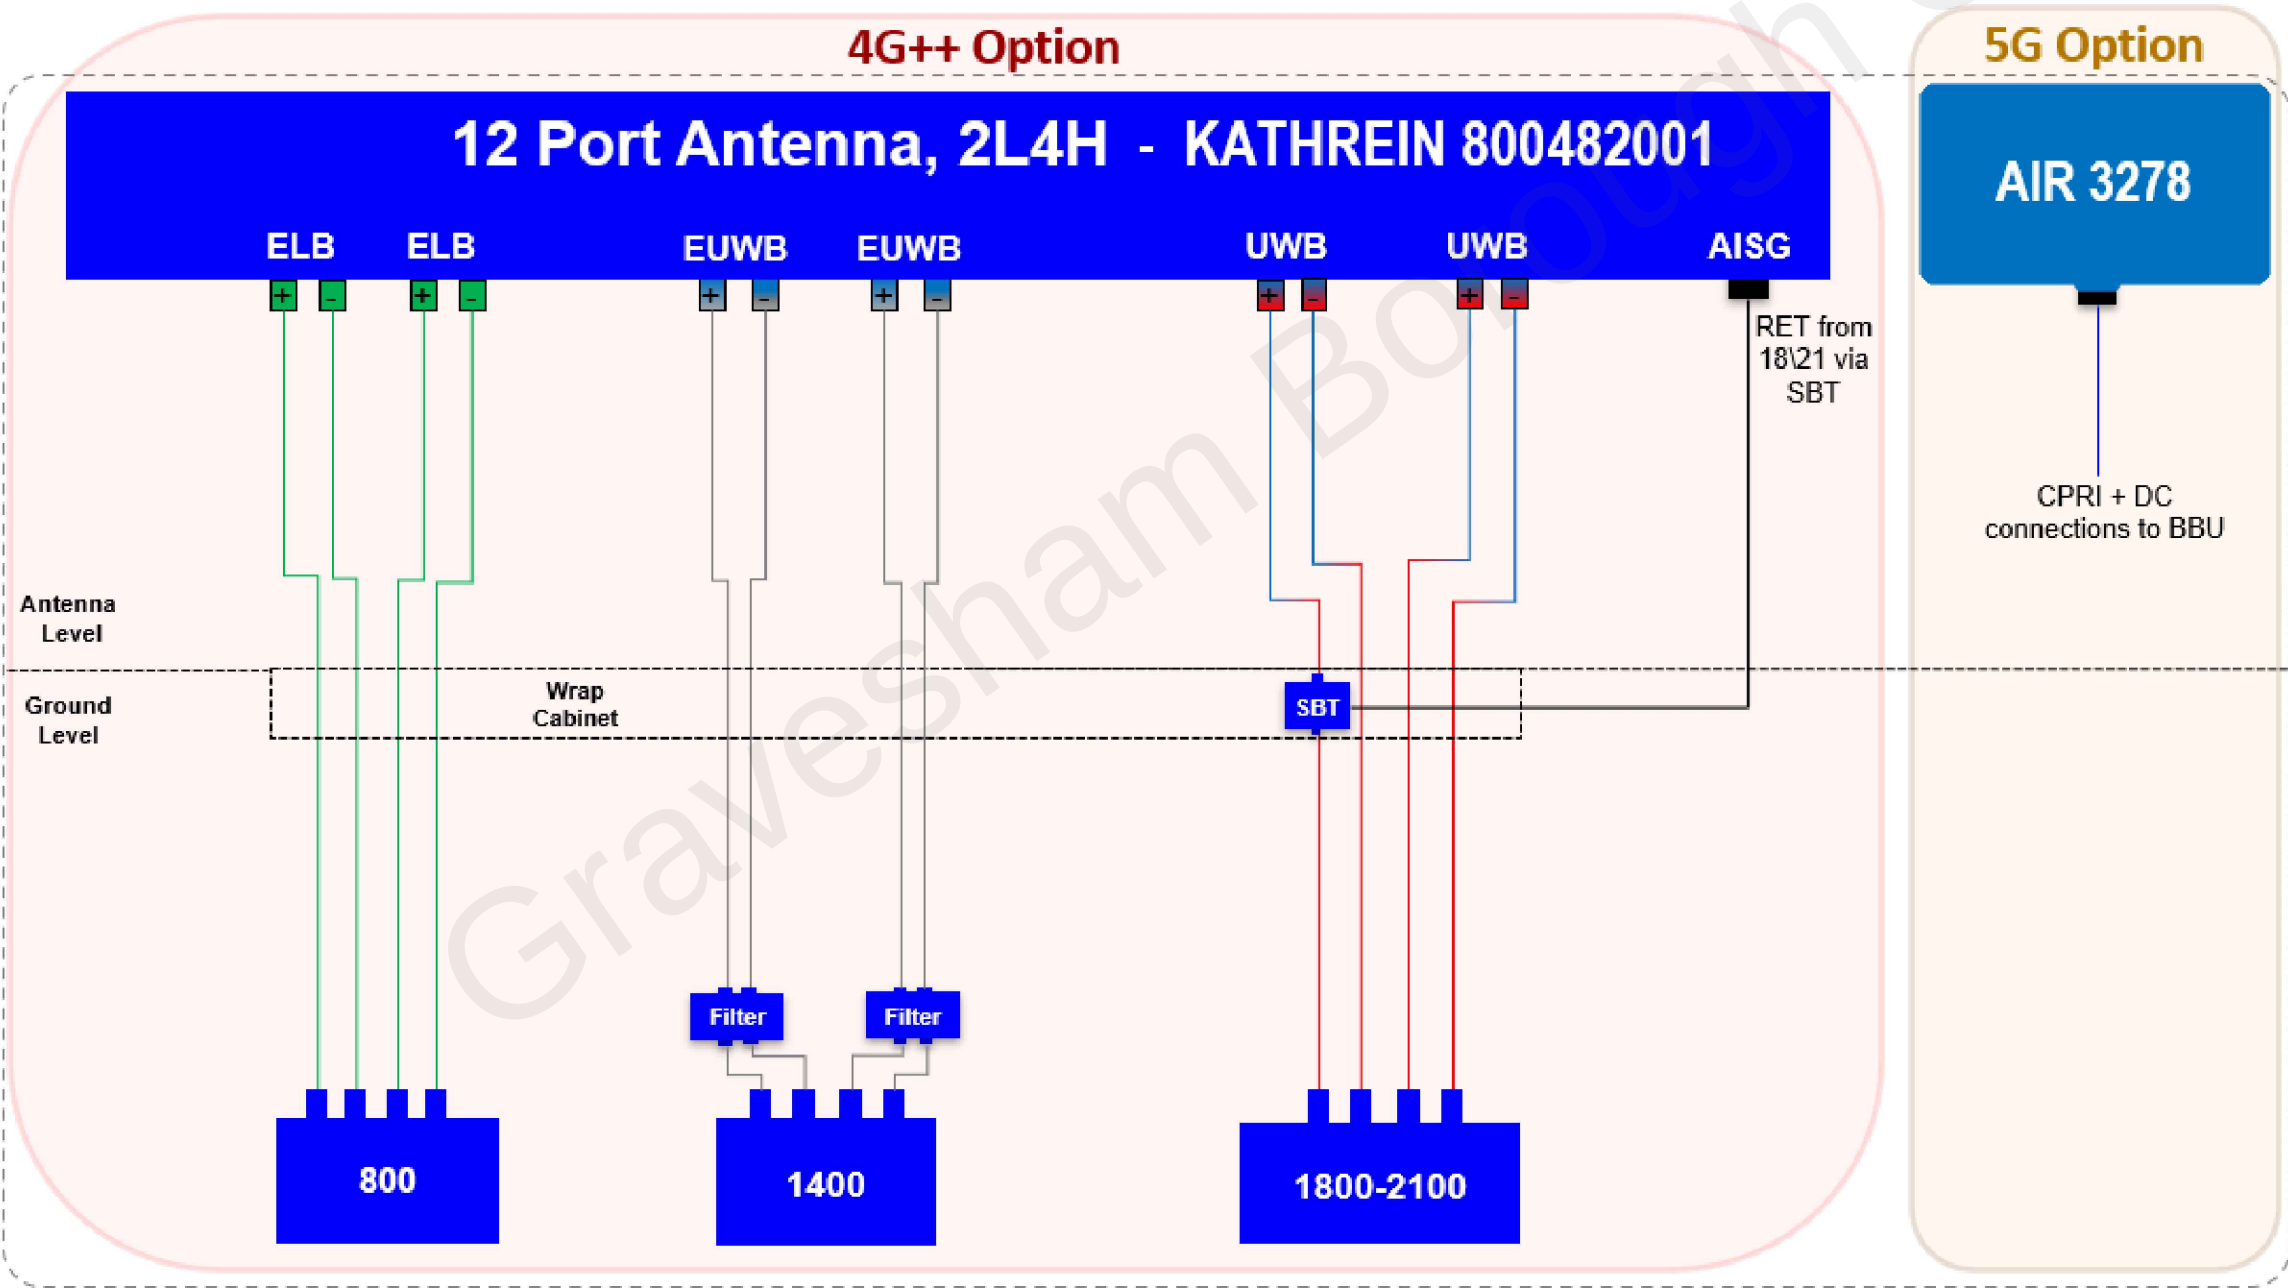

STATUS KEY:

Installed:

Existing

Retain:

Existing and to remain

Relocate:

Existing and to be relocated

Remove:

Existing to be removed from site

Proposed:

New on site

Master:	MBNL / EE / H3G:	Project:	Purpose of Issue:	Issue:
M004	MBNL	3UK DNSW	Planning	D
Date:	15/07/2022	Revision / Upgrade Description:		
Drawn:	CDN	Pole Height reduced to 15m.		
checked:	DH	Vis Splay Plan added		
approved:	SD			
Master:	MBNL / EE / H3G:	Project:	Purpose of Issue:	Issue:
M003	MBNL	3UK DNSW	Planning	C
Date:	20/05/2022	Revision / Upgrade Description:		
Drawn:	CDN	Amended to standard		
checked:	DH			
approved:	SD			
Master:	MBNL / EE / H3G:	Project:	Purpose of Issue:	Issue:
M002	MBNL	3UK DNSW	Planning	B
Date:	15/01/2021	Revision / Upgrade Description:		
Drawn:	CDN	Pole location amended		
checked:	DH			
approved:	SD			
Master:	MBNL / EE / H3G:	Project:	Purpose of Issue:	Issue:
M001	MBNL	3UK DNSW	Planning	A
Date:	04/05/2020	Revision / Upgrade Description:		
Drawn:	CDN	First Issue - Site nomination dated: TBC		
checked:	DH			
approved:	SD			

CK Hutchison Networks (UK) Limited

Great Brighams Mead,
Vastern Road, Reading,
Berkshire, England,
RG1 8DJ

Design Consultant & Principal Contractor:

WHP

WHP Telecoms
Unit 1 Maple Park,
Low Fields Avenue, Leeds
LS12 6HH

Tel: 01133023550
e-mail: info@whptelecoms.com

Site Name:	CRETE HALL ROAD				
Site ID:	GVM30742				
Address:	CRETE HALL ROAD, GRAVESHAM, KENT, SOUTH EAST, DA11 9BU				
Title:	303 PROPOSED ANTENNA SCHEDULE & LINE CONFIGURATION				
Project:	3UK DNSW				
Purpose of Issue:	PLANNING				
EE Cell ID:	71831	MBNL Cell ID:	GVM071	3UK Cell ID:	DA0500
Master Drawing No:					Issue:
GVM30742_M004					D

