

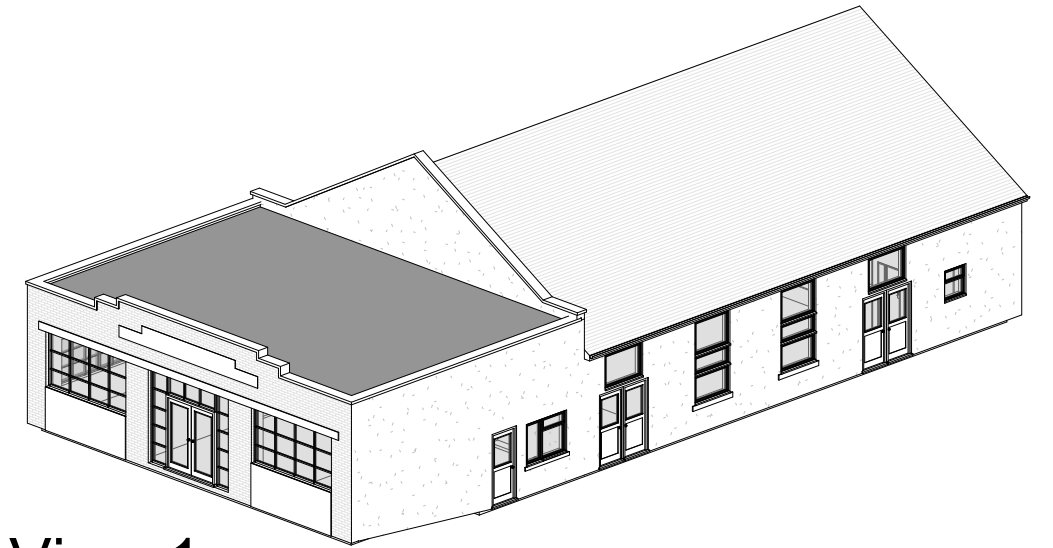
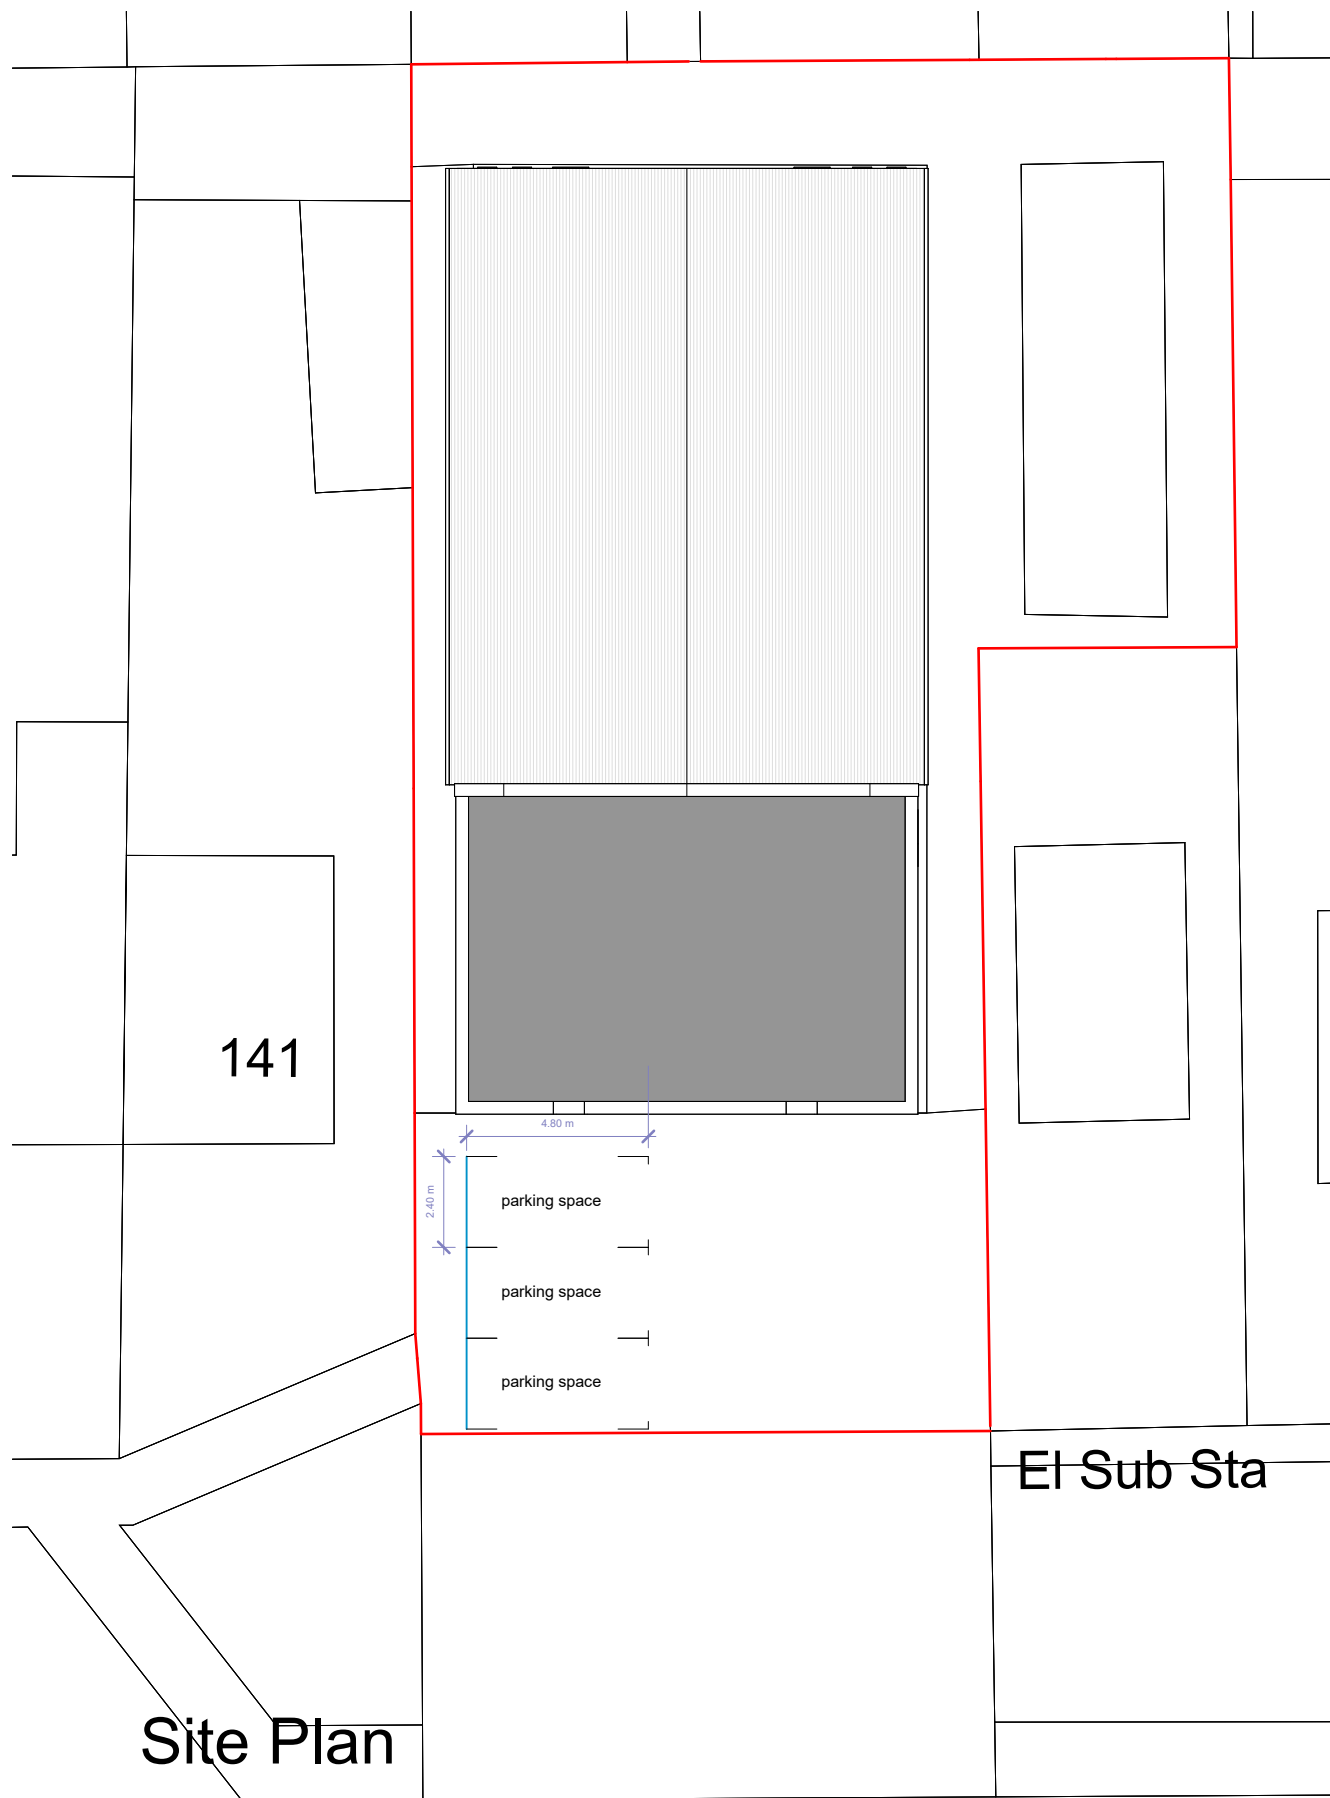


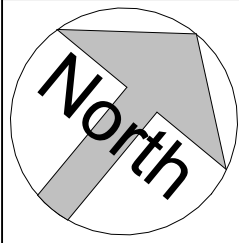

3D View 1

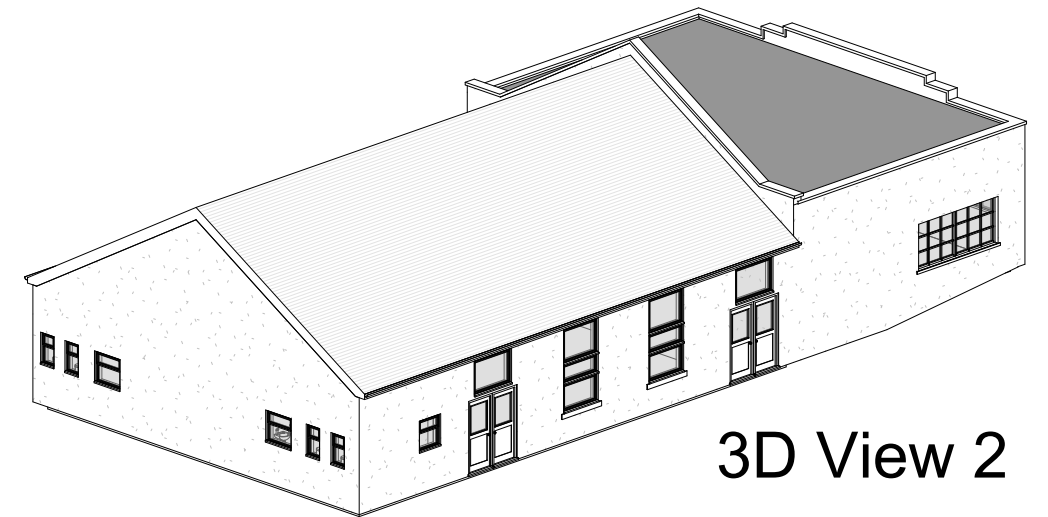

3D View 2

Site Plan



FLUENT
ARCHITECTURAL DESIGN SERVICES
TEL: 0800 043 8838
E-MAIL: INFO@FLUENT-ADS.CO.UK
WEB: FLUENT-ADS.CO.UK

St John Ambulance Memorial Hall, Hall Road

Proposed Site Plan and 3D Views

Scale @ A3
1 : 200

Date
20.08.25

Drawn by
NM

 
Drawing number
P.M.400

Project number
2411

Rev
C

Key:

Existing Proposed SVP Boundary line
Existing drainage Proposed drainage Overhead



No.	Description	Date
0	First Draft	
A	Client's comments (1)	02.09.25
B	Client's comments (3)	08.04.26
C	Drawing amended	25.09.26