


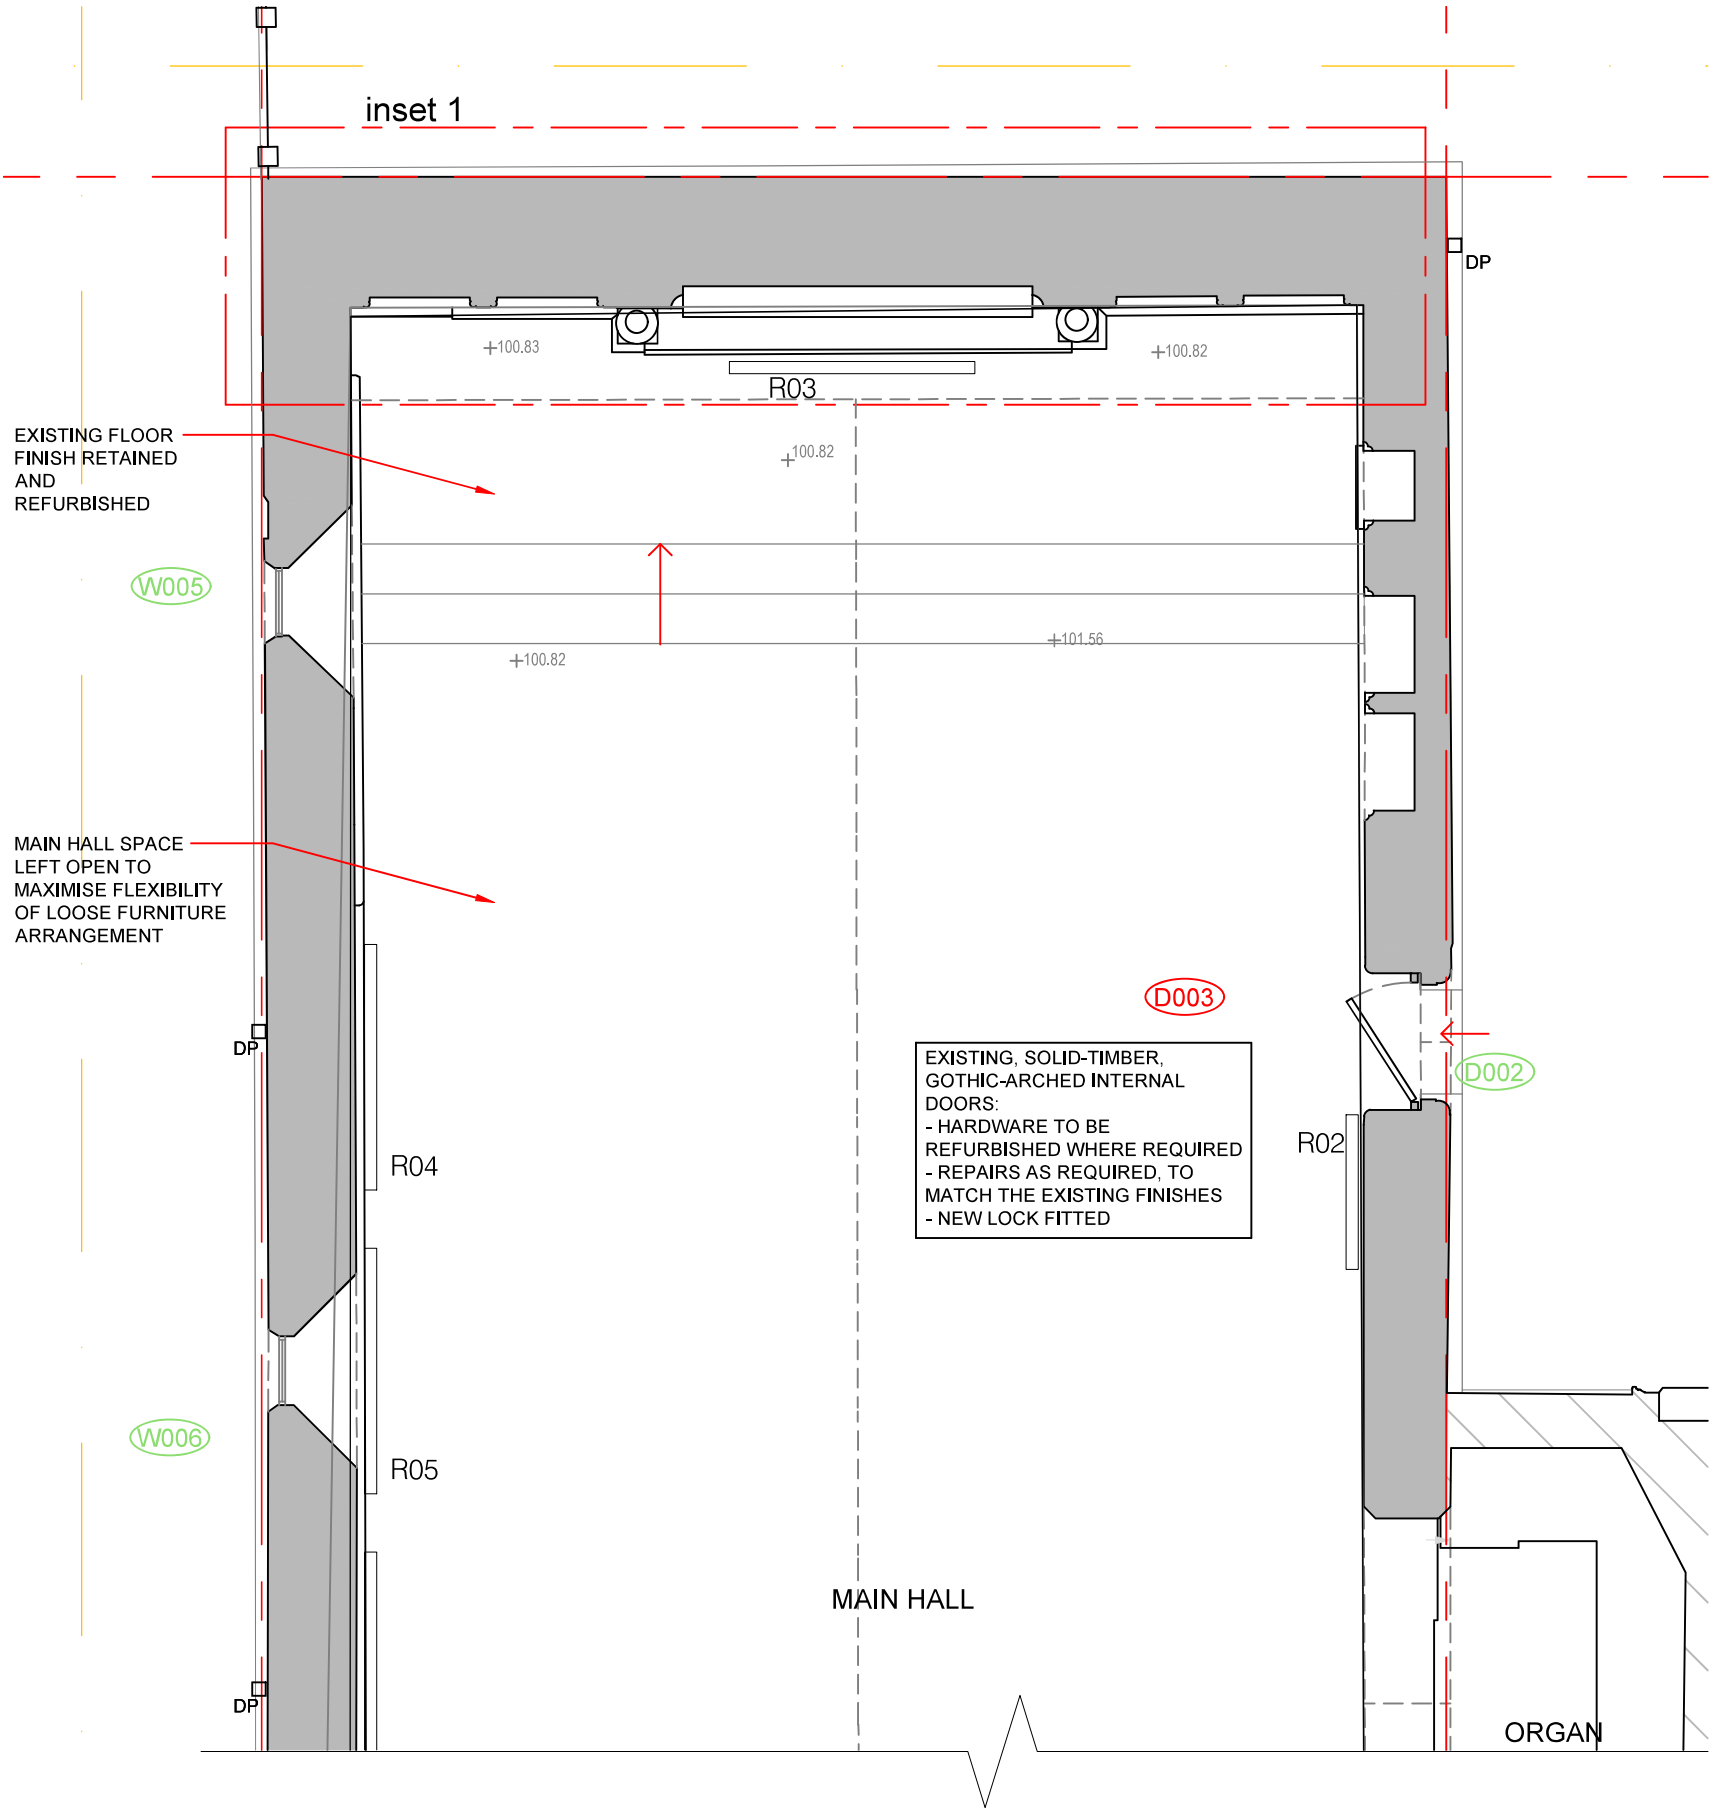

RADIATOR SCHEDULE
Heating system to consist of 7no. ChurchEcoMiser Ltd radiators, installed in positions as noted on plans and internal elevations.

R01	HALL	990(l) x 630(h) x 80(d)
R02	HALL	990 x 630 x 80
R03	HALL	1625 x 630 x 80
R04	HALL	1625 x 630 x 80
R05	HALL	1625 x 630 x 80
R06	HALL	1625 x 630 x 80
R07	WC01	410 x 630 x 80

- NOTES:
1. All dimensions to be checked and verified on site prior to construction commencing: any discrepancies to be reported to client.
 2. This drawing is for planning purposes only.
 3. No dimensions to be scaled from drawing except for the purposes of Planning Applications. The contractor should check all dimensions on site. It is the contractors responsibility to ensure compliance with Building Regulations.


CDM 2015 Health and Safety Information:
This information relates only to 'Significant Hazards' identified on this drawing and is to be read in conjunction with the Designer's Risk Assessment Register.

SAFETY, HEALTH AND ENVIRONMENTAL INFORMATION
In addition to the hazards / risks normally associated with the types of work detailed on this drawing, note the following:

- CONSTRUCTION:**
- MAINTENANCE/ CLEANING:**
- DECOMMISSIONING/ DEMOLITION:**
- ENVIRONMENT:**
- It is assumed that all works will be carried out by a competent contractor working, where appropriate, to an approved method statement

LEGEND

	EXISTING WALL
	PROPOSED WALL
	TILED FLOOR FINISH
	ENTRANCE MATTING
	EXISTING DOOR REMOVED
	PROPOSED NEW DOOR
	EXISTING DOOR RETAINED

 

P4	MAY 2026	Reduced scope after 30/04/26 site meeting with planners	TP	SL
P3	JAN 2026	Whole-building proposal - issued to client for discussion	TP	SL
P2	OCT 2025	ISSUED FOR PLANNING	TP	SL
P1	JULY 2025	ISSUED FOR INFORMATION	TP	SL
Rev	Rev. Date	Purpose of revision	Drawn	Checked

Stuart James Associates
planning and development consultants

4th Floor, Rex House
4-12 Regent Street
London SW1Y 4PE

Phone: 020 7228 8522
Email: office@stuartjamesassociates.co.uk
Website: www.stuartjamesassociates.co.uk
Twitter: @SJAconsultants
Company Number: 7327582 Registered in England & Wales
VAT Number: 135 6259 09

Project	ST ANDREW'S ARTS CENTRE 19 ROYAL PIER ROAD GRAVESEND DA12 2BD		
Drawing title	PROPOSED GROUND FLOOR PLAN - REAR at 1:50		
Drawing status	PLANNING		
Scale	1:50 @ A3	DO NOT SCALE	
Client no.			
Drawing number	SJA3472/PL 11b		Rev P4