



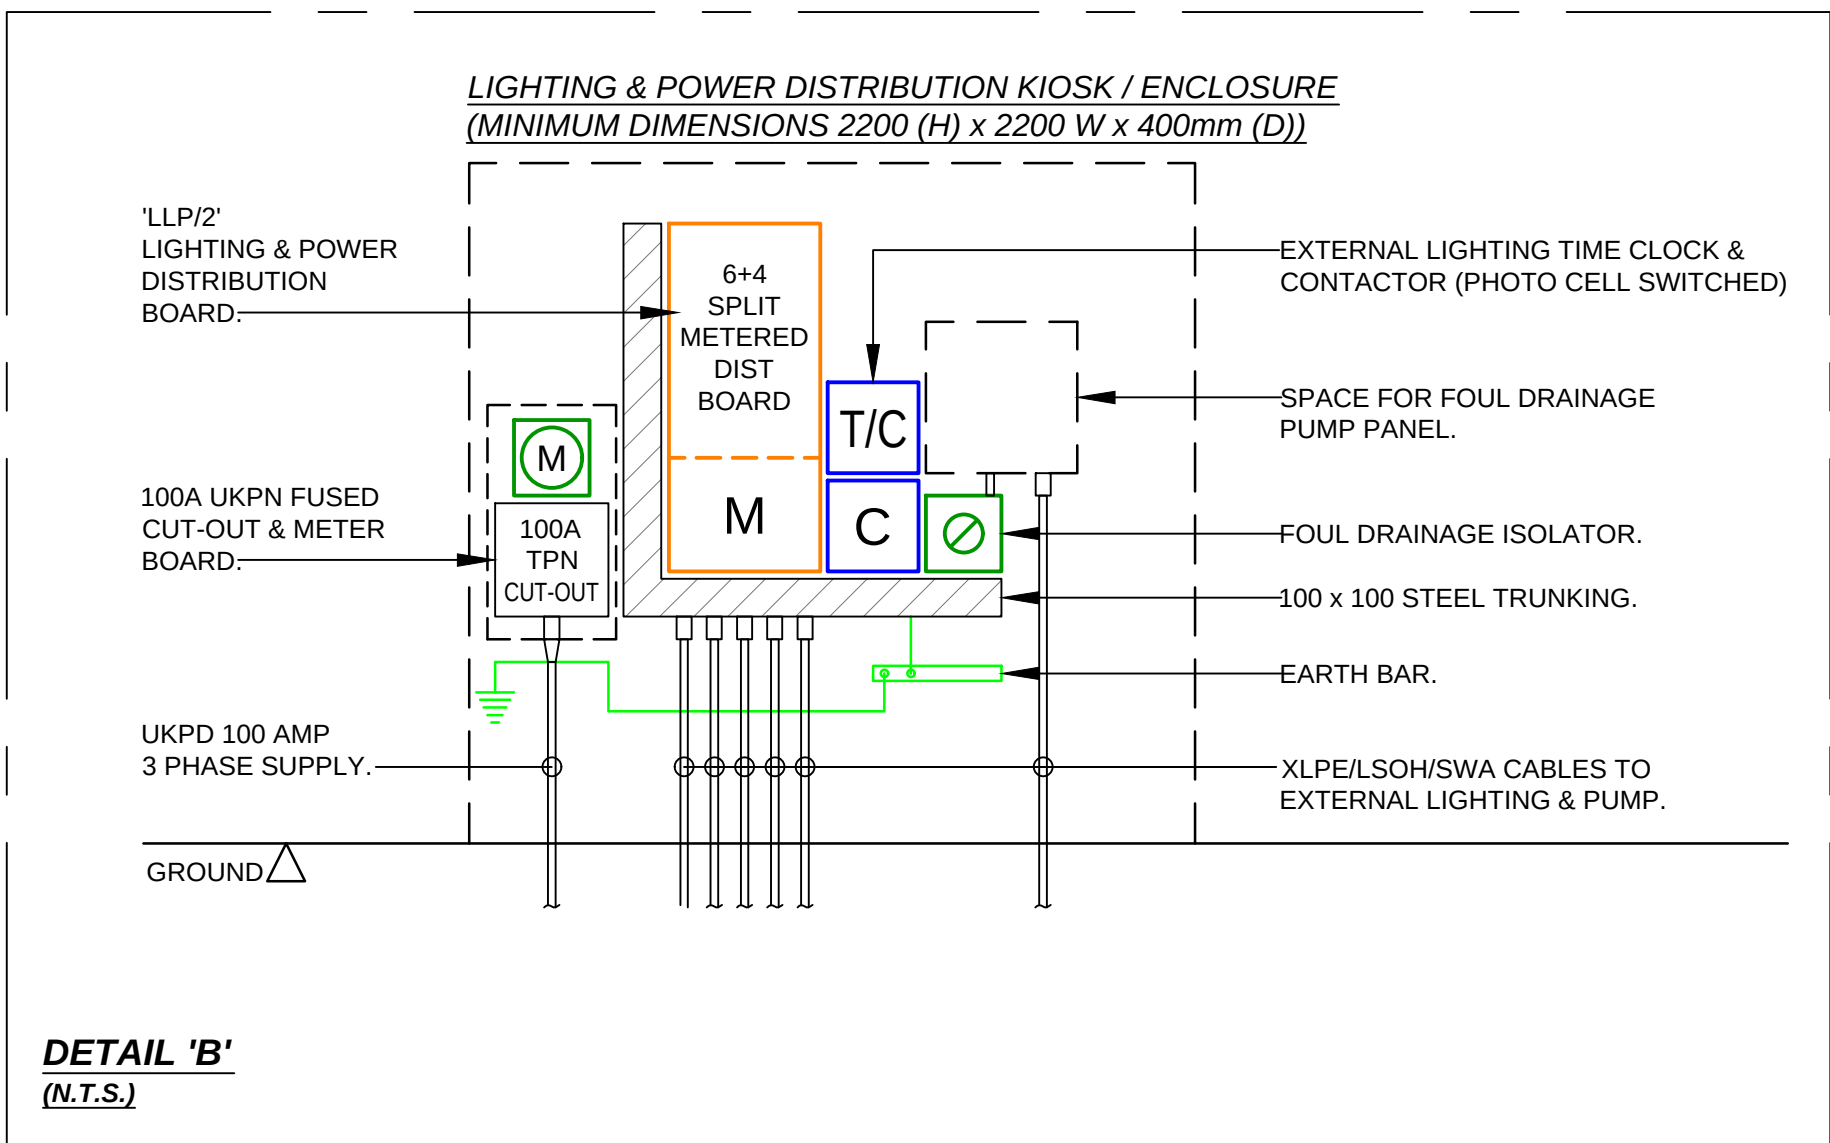

Electrical Legend:	
	MCB Distribution Board (As noted).
	Utility company smart meter.
	Electronic time clock Sangamo S254 (or similar).
	20A / 230V multipole contactor c/w enclosure.
	7.2kW Electric vehicle charging station. (Contractor to carefully select type & support).
	Foul drainage pump. (Contractor to connect to pump panel within kiosk / enclosure).
	Bulkhead lights (Served & switched from local building).
	11W LED 3000K IP65 Bulkhead, black polycarbonate body with opal diffuser.
	14W LED 3000K IP65 Bulkhead, black polycarbonate body with opal diffuser.
	5mt column c/w 30W LED 4000k, IP66 street light c/w Nema socket (future).
	G&S Photocell operated dusk-til-dawn lighting controller. Nema socket compatible.
	'PIR' Denotes internal PIR controller.
	'E' Denotes 3HR battery backed.

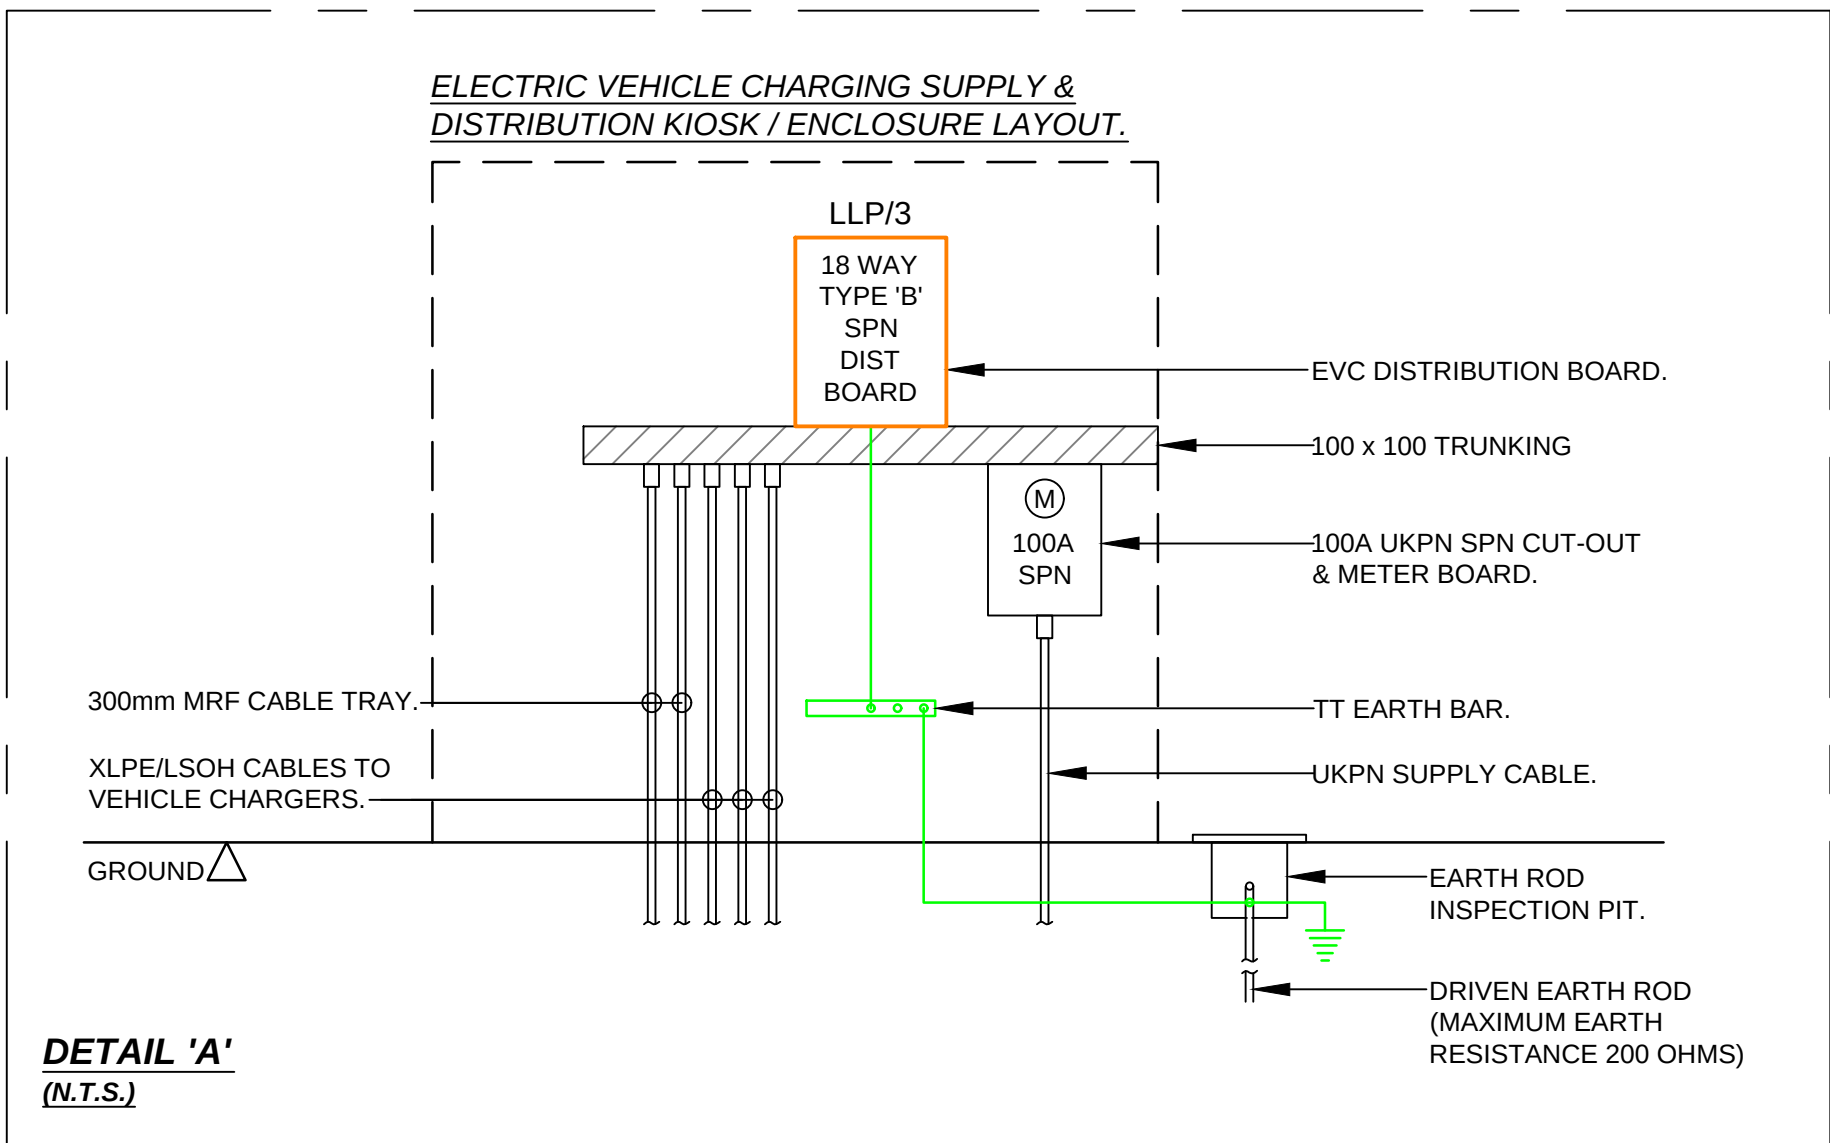

DO NOT SCALE FROM DRAWING

THIS DRAWING IS CONFIDENTIAL AND IS THE PROPERTY OF ACY, AND MUST BE RETURNED UPON REQUEST. IT MUST NOT BE COPIED, LENT OR EXHIBITED WITHOUT THE WRITTEN CONSENT OF ACY.

THIS DRAWING HAS BEEN COMPILED USING THE FOLLOWING INFORMATION:
TURNER JACKSON DAY
1735 101 C3

NOTES:
1. THE ELECTRICAL INSTALLATION MUST COMPLY IN FULL WITH THE REQUIREMENTS OF BS7671: AMMENDMENT 3 2024 IET WIRING REGULATIONS, INCLUDING ANY ASSOCIATED GUIDANCE NOTES ETC
2. REFER TO DISTRIBUTION BOARD SCHEDULE FOR CIRCUIT REFERENCES.
3. LIGHTING SHALL BE CO-ORDINATED WITH ALL OTHER ELECTRICAL & MECHANICAL SERVICES INSTALLATIONS.
4. FINAL SETTING OUT OF EQUIPMENT SHALL BE TO THE ARCHITECTS ROOM LAYOUT & REFLECTIVE CEILING PLANS.

P1	ISSUED FOR APPROVAL.	26/04/25
REF	REVISION	DATE

FOR APPROVAL

Client:
-

Project:
Custom House
The Terrace
Gravesend, DA12 2BW

Title:
EXTERNAL
LIGHTING, POWER &
ANCILLARY SERVICES

Date:
March 2025

Cad Ref:
-

Project No.:
E241031

Scale:
1:200 @ A1

Eng.:
MK

Drawn:
SL

Drawing No.:
EXT/XX/DR/E/61/016

Rev.:
P1