




KEY

Type 1


Type 2

Type 3

Type 4

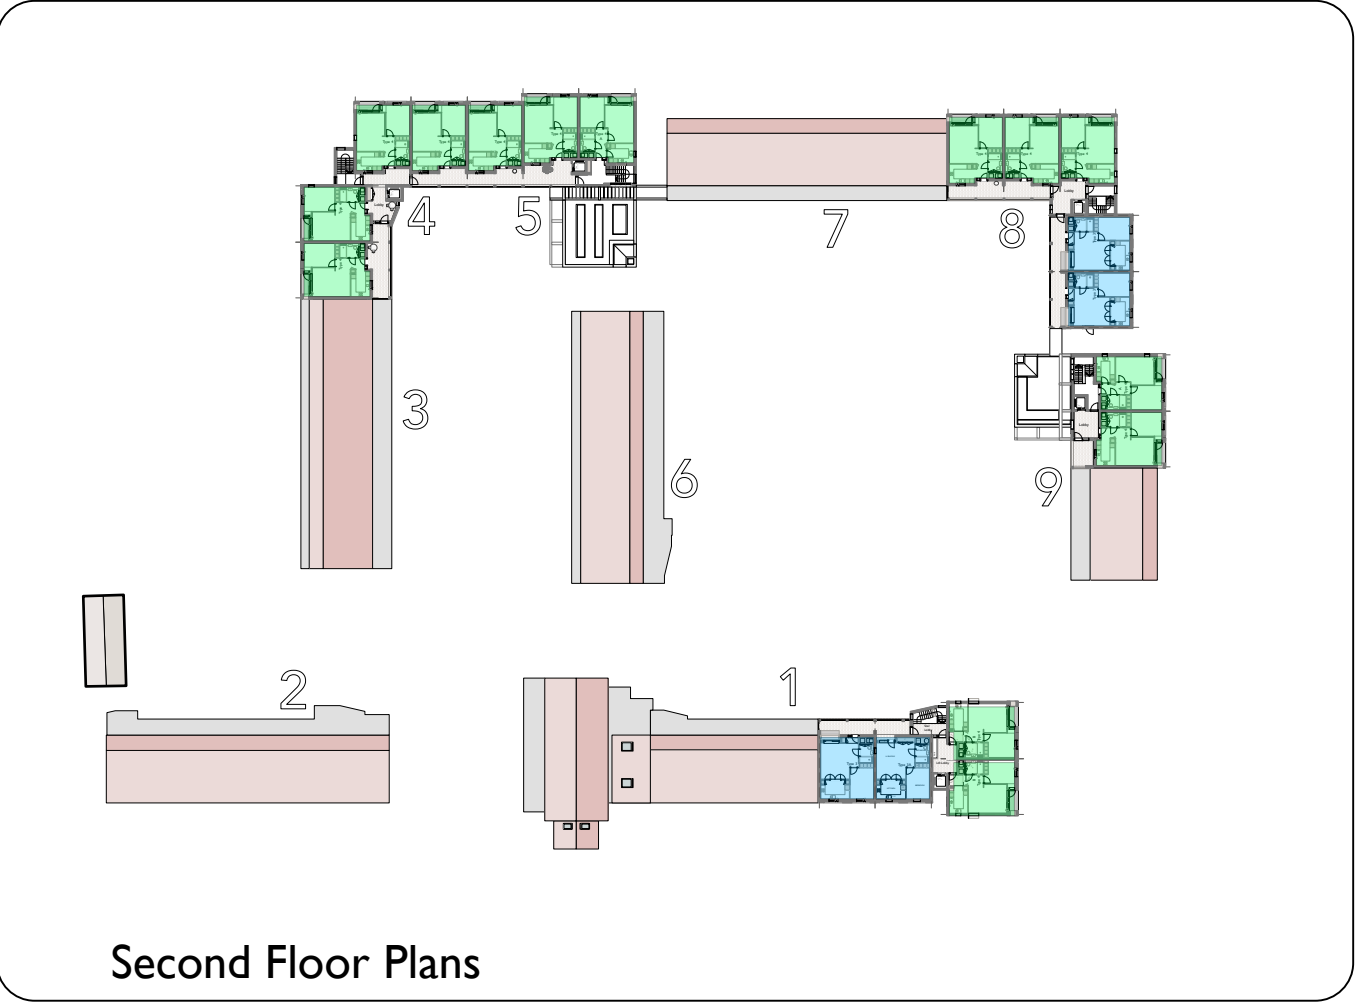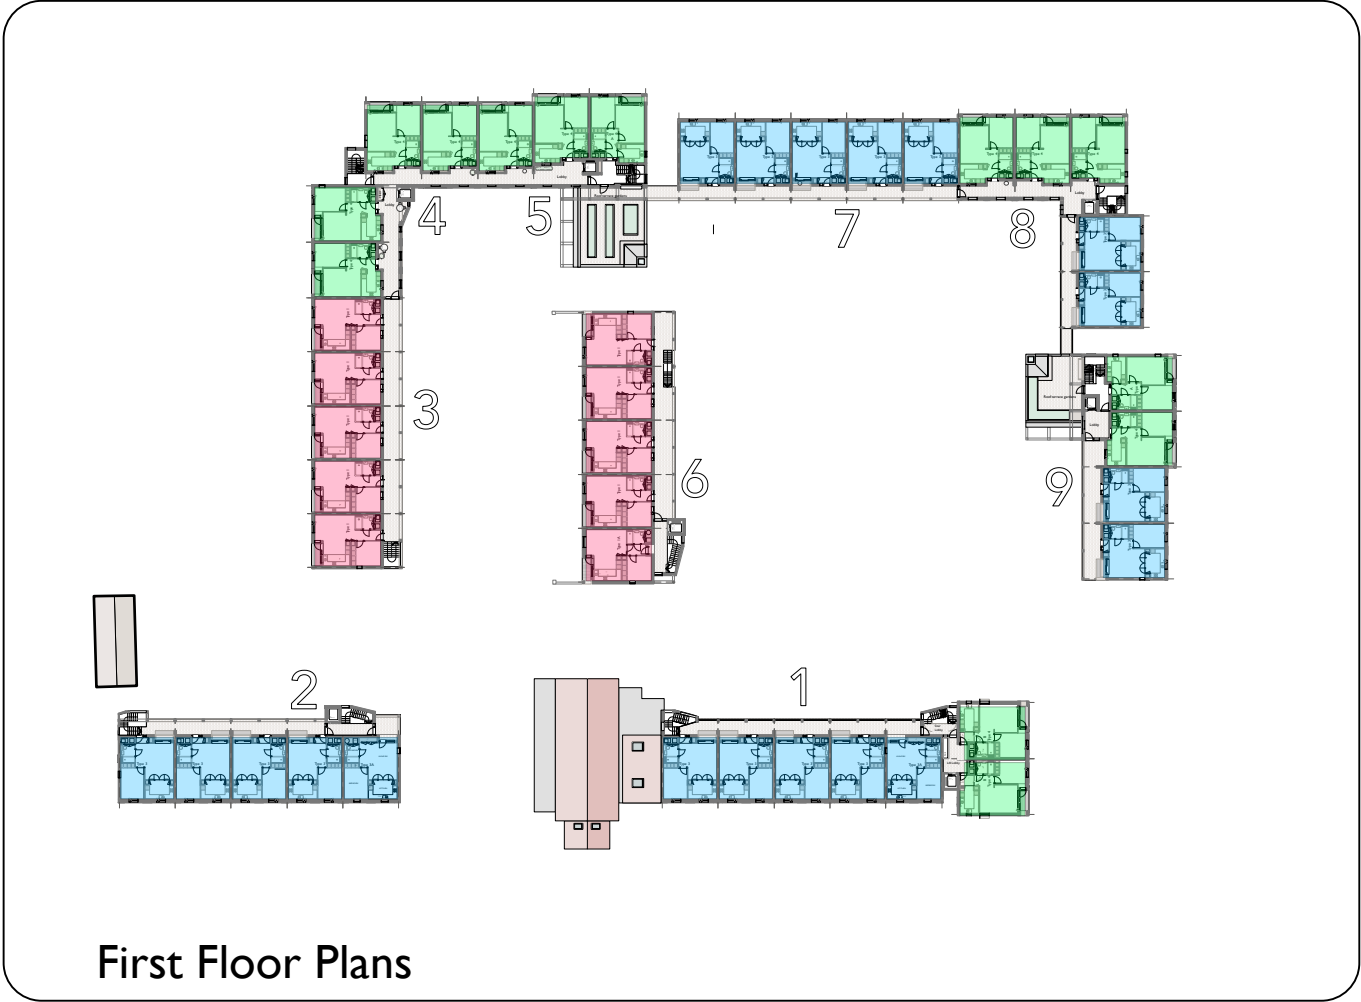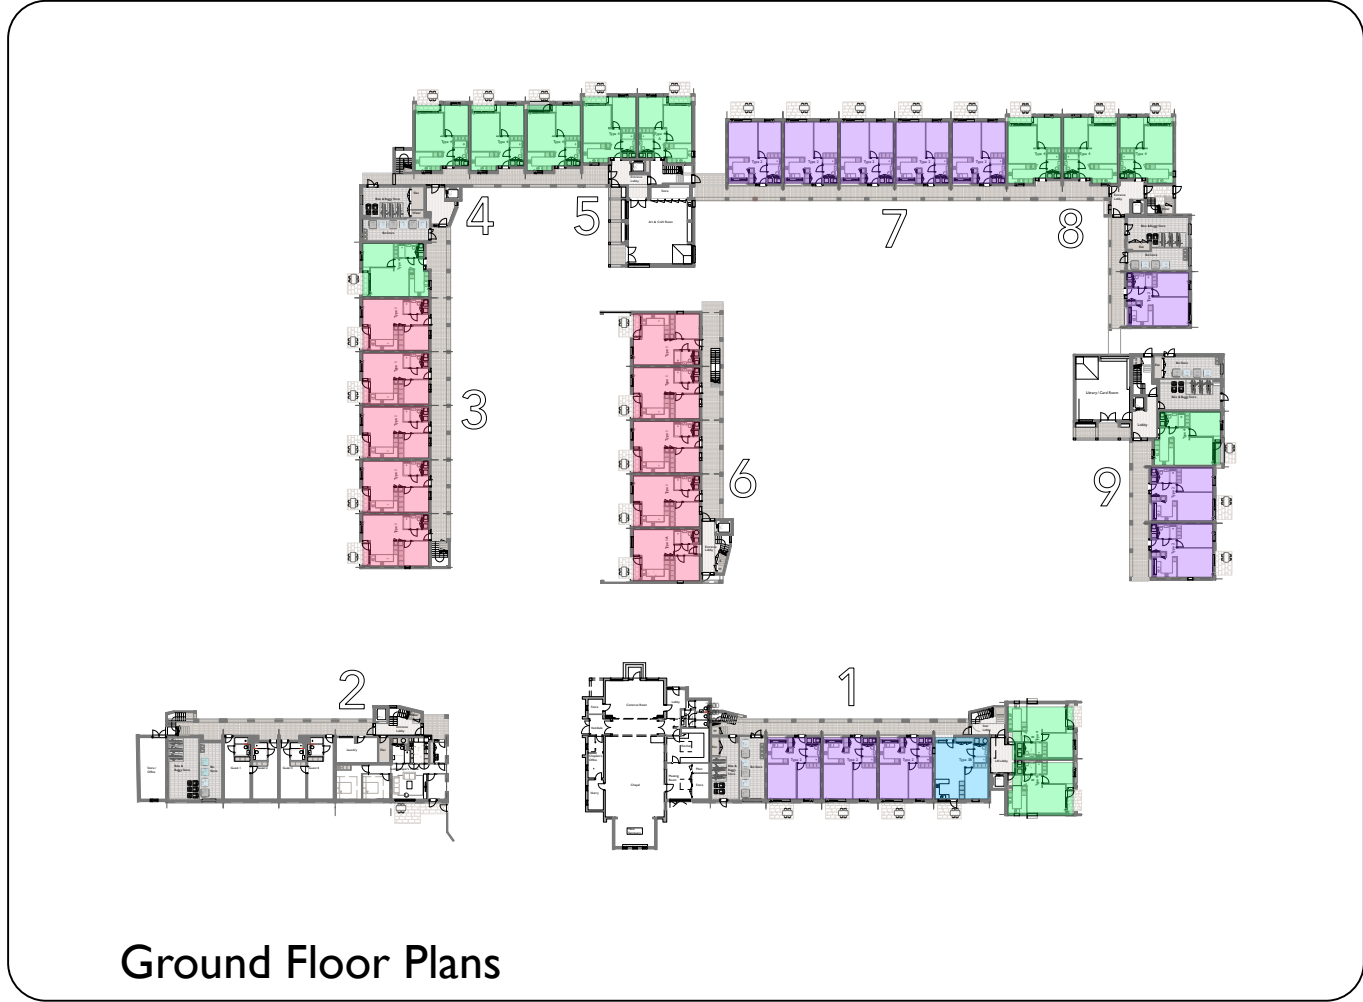

House Type Reference KEY

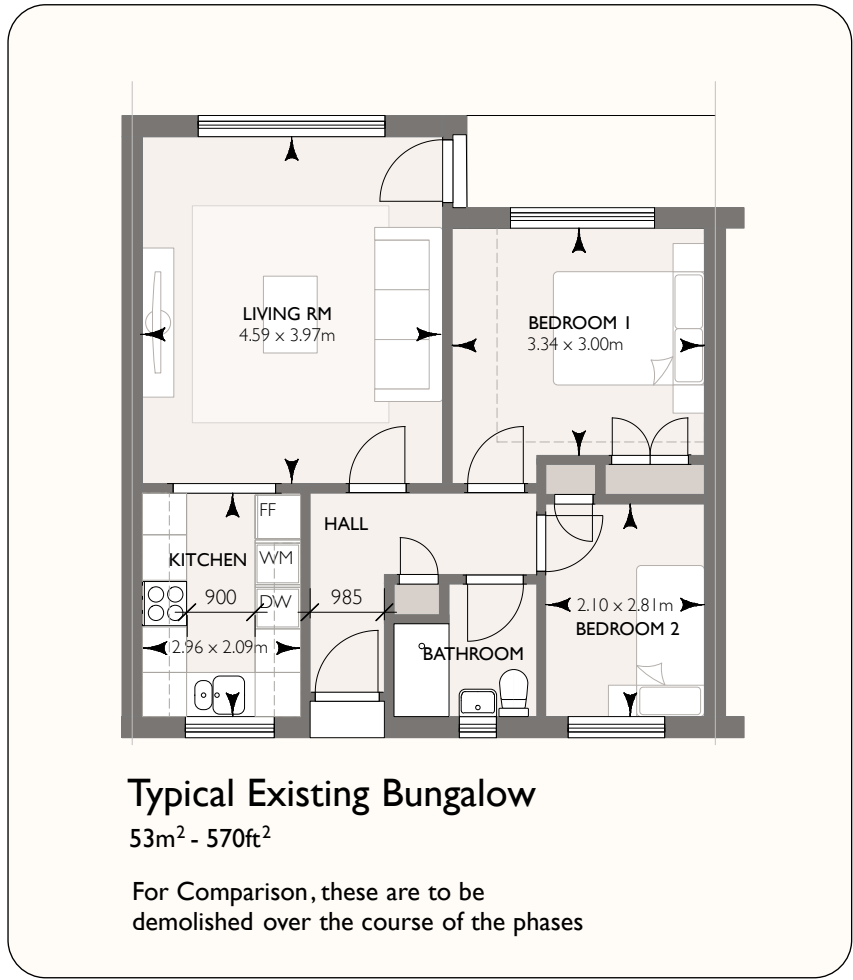

KEY

S

WM

C

B

L

FF

W

Service cupboard, including cylinder linked to Air Source Heat Pump, and Mechanically Ventilated Heat Recovery Unit

Washing Machine, located in Utility / Airing cupboard, 800mm deep with 3 sets of 900mm wide slatted shelved fitted 900mm above the washing machine





Coats cupboard, 600w x 600d in the hall, with hanging rail and shelf above and shelf below for shoes

Broom cupboard, 600w x 600d to take broom, mop & ironing board, with shelves above

Larder Unit, either built in, or part of the kitchen fittings

Fridge Freezer

Wardrobe, could be built in, or ordered as a set from a wardrobe supplier (IKEA, or similar). If latter then it could be added to by resident.

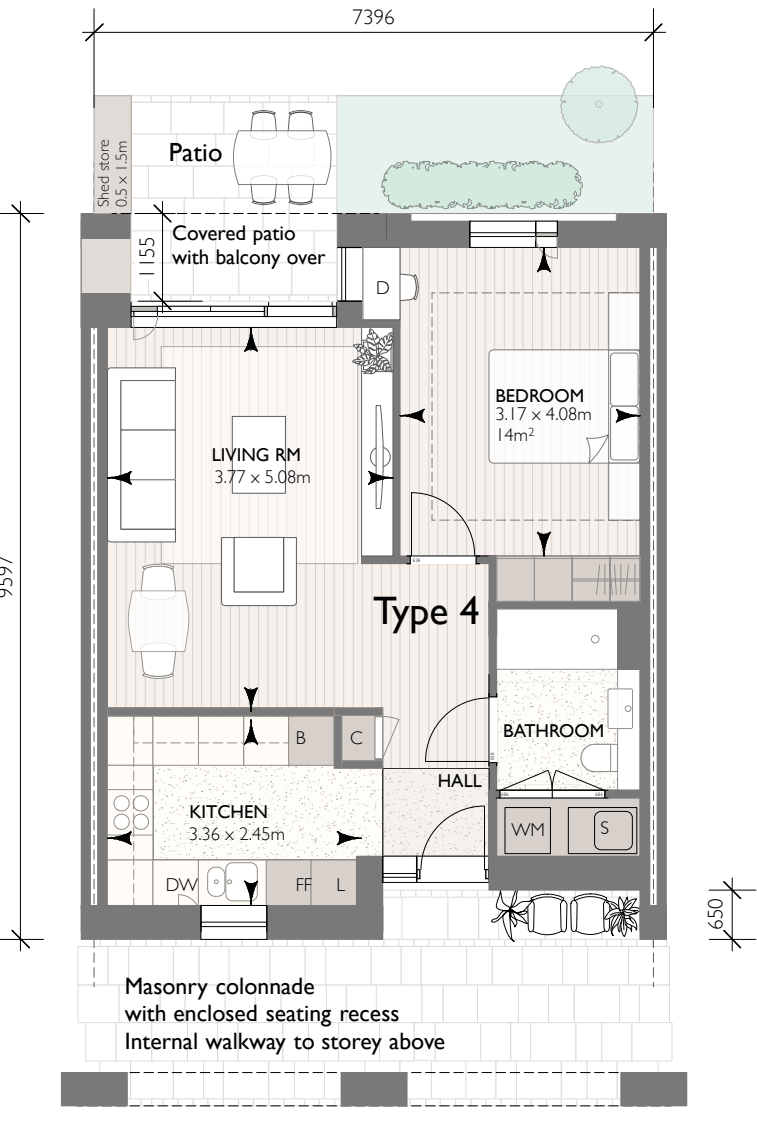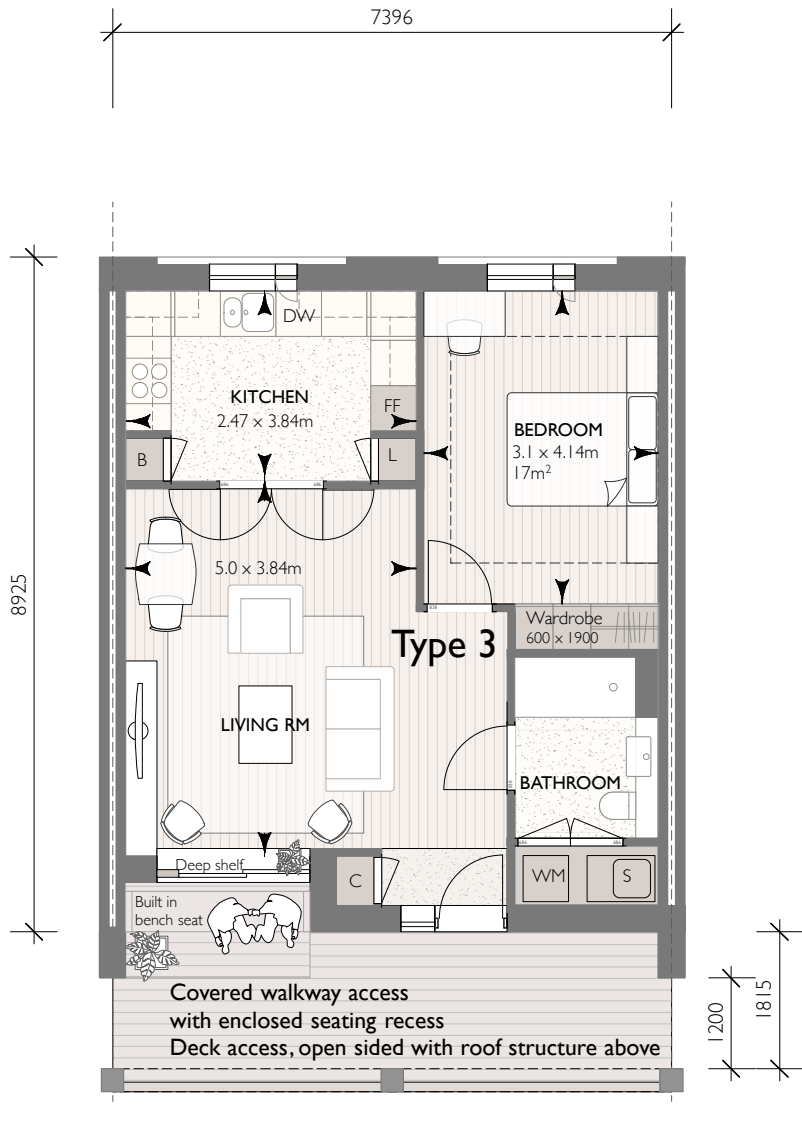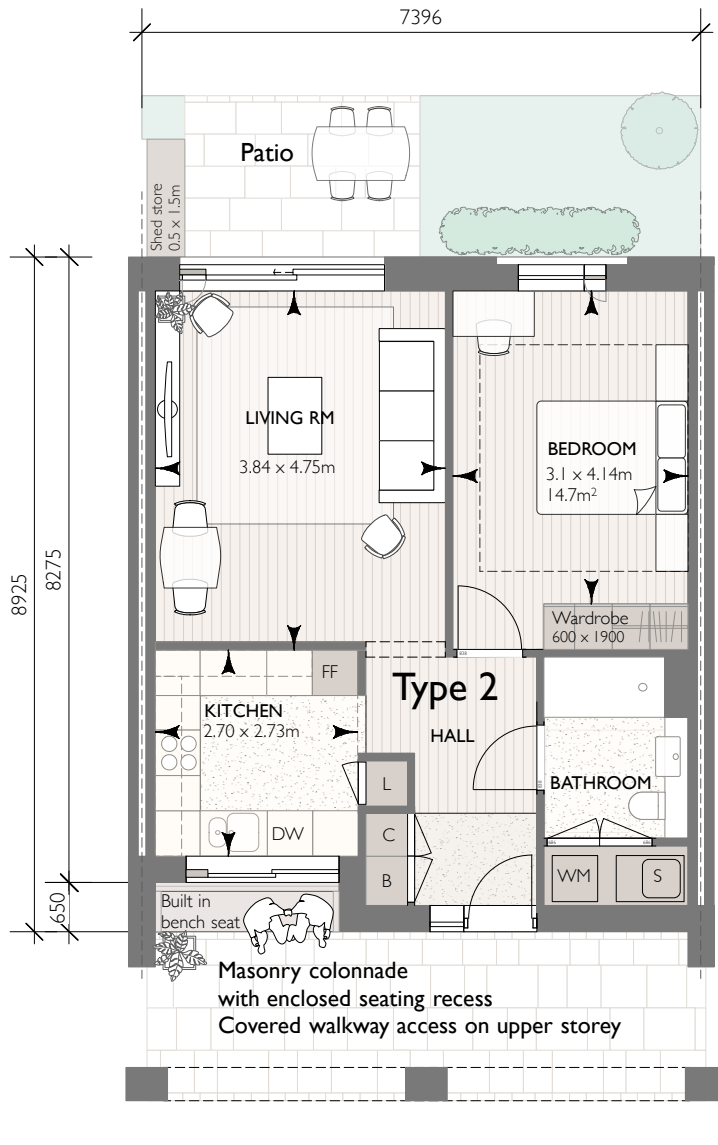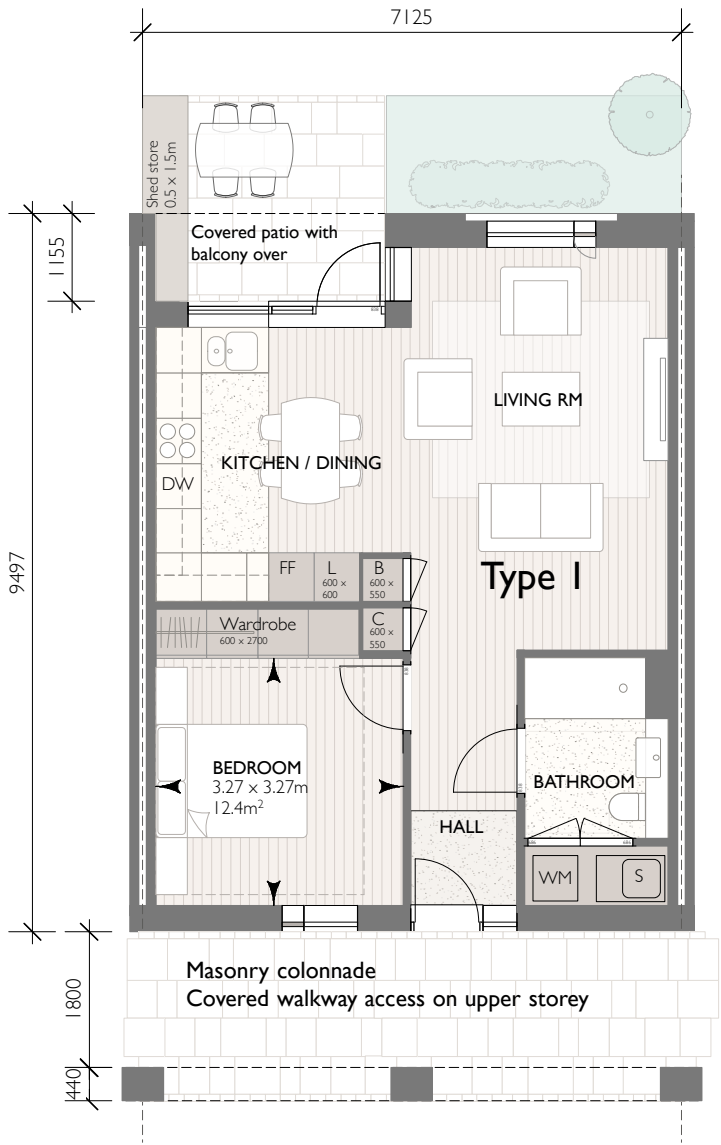

House Type Floor Plans
Scale 1:100 at A101 cm

Notes				Revs				HaysomWardMiller Architects				Proposed House Types			
1: This drawing must not be scaled - work only to figured dimensions				2: Dimensions must be verified on site by the contractor before preparation of shop drawings				20 Birdge Street Cambridge CB2 1UF				Job no. 23.709			
3: The architect must be notified of any discrepancies immediately				4: This drawing applies only to this job and site				T : 01223 578545				Drawing no. P 10			
5: This information on this drawing is copyright protected								email : info@haysomwardmiller.co.uk				Revision no. C			
								Project				Huggens College Almshouses			
								For				Huggens College			
								Scale				1:100 at A1			