


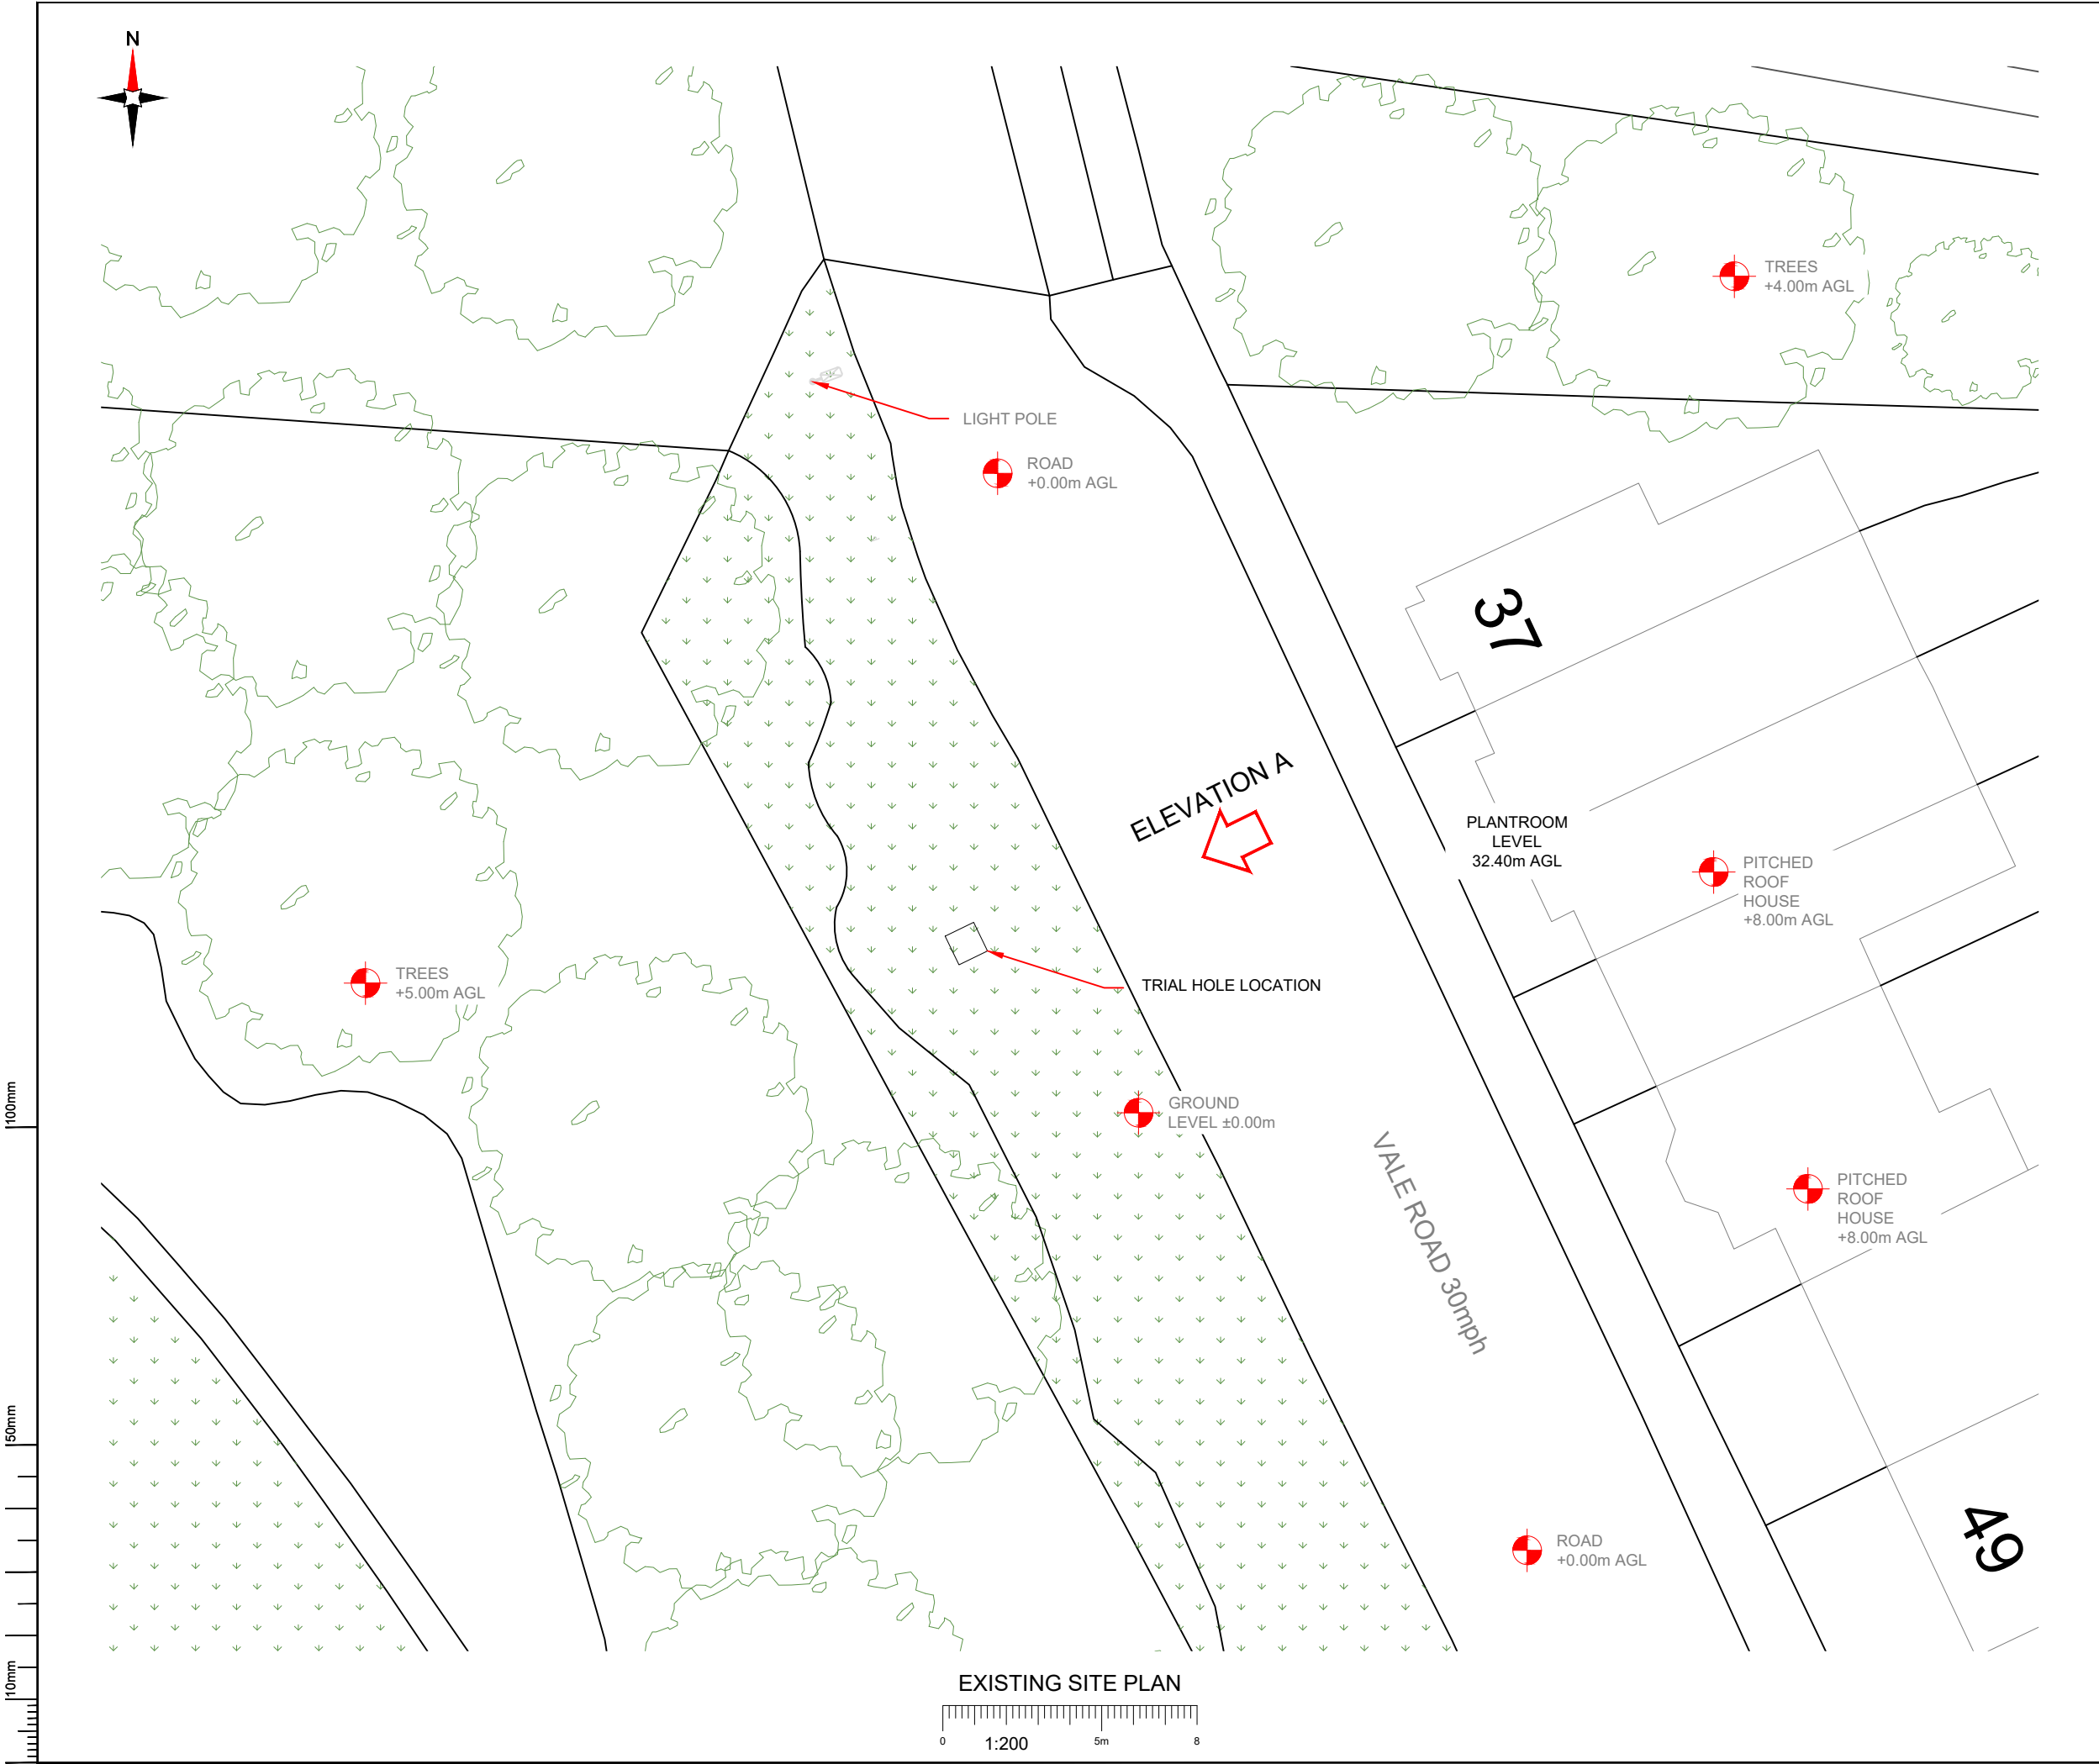

- NOTES:
1. ALL DIMENSIONS ARE IN MM UNLESS OTHERWISE STATED
  2. DRAWING TO BE READ IN CONJUNCTION WITH ALL RELEVANT DRAWINGS AND SPECIFICATIONS
  3. DO NOT SCALE DRAWINGS. ALL DIMENSION TO BE CHECKED ON SITE. ALL DIMENSIONS SHOWN ON EXISTING STRUCTURES ARE APPROXIMATE AND THE CONTRACTOR IS TO OBTAIN ALL EXACT SITE DIMENSIONS NECESSARY TO CARRY OUT PROPOSED WORKS
  4. DUCT ROUTES ARE SHOWN INDICATIVELY, ACTUAL ROUTES TO BE DETERMINED ON SITE
  5. ALL DISCREPANCIES TO BE REPORTED TO THE DESIGN ENGINEER

|           |                  |                                 |                   |        |
|-----------|------------------|---------------------------------|-------------------|--------|
| Master:   | MBNL / EE / H3G: | Project:                        | Purpose of Issue: | Issue: |
| M001      | MBNL             | NTQR                            | GA                | A      |
| Date:     | 01/08/2023       | Revision / Upgrade Description: |                   |        |
| Drawn:    | F. Borlina       | First Issue                     |                   |        |
| Checked:  | T. Clifford      |                                 |                   |        |
| Approved: | M. Venner        |                                 |                   |        |



Hutchison 3G UK Limited  
Green Park, 450 Longwater Avenue  
Reading, RG30 3UR  
Tel: 01628 765 000  
Fax: 01628 765 001

H3G Base Station Information line:  
0845 6043000  
Available 8am-8pm Monday to Friday



Hatfield Business Park  
Hatfield  
Hertfordshire  
AL10 9BW

Tel: 01707 315000  
Fax: 01707 319001

**MBNL** Mobile Broadband Network Limited  
Sixth Floor, Thames Tower, Station Road, Reading, RG1 1LX



**BEACONCOMMS**

UNIT E3 PITTS CLEAVE INDUSTRIAL ESTATE, TAVISTOCK, DEVON, PL19 0PW  
sales@beaconcomms.co.uk

Tel: +44 (0)1822 610610

|                           |                                            |              |        |
|---------------------------|--------------------------------------------|--------------|--------|
| Site Name:                | VALE ROAD                                  |              |        |
| Site ID:                  | 1707938                                    |              |        |
| Address:                  | VALE ROAD<br>GRAVESHAM<br>KENT<br>DA11 9RE |              |        |
| Title:                    | 100 EXISTING SITE PLAN                     |              |        |
| Project:                  | MBNL NTQR                                  |              |        |
| Purpose of Issue:         | GENERAL ARRANGEMENT                        |              |        |
| EE Cell ID:               | MBNL Cell ID:                              | 3UK Cell ID: |        |
| 30702                     | GVM091                                     | -            |        |
| Master Drawing No:        |                                            |              | Issue: |
| 1707938_GVM091_30702_M001 |                                            |              | A      |

 
100mm

50mm

10mm



EXISTING ELEVATION A



- NOTES:
1. ALL DIMENSIONS ARE IN MM UNLESS OTHERWISE STATED
  2. DRAWING TO BE READ IN CONJUNCTION WITH ALL RELEVANT DRAWINGS AND SPECIFICATIONS
  3. DO NOT SCALE DRAWINGS, ALL DIMENSION TO BE CHECKED ON SITE. ALL DIMENSIONS SHOWN ON EXISTING STRUCTURES ARE APPROXIMATE AND THE CONTRACTOR IS TO OBTAIN ALL EXACT SITE DIMENSIONS NECESSARY TO CARRY OUT PROPOSED WORKS
  4. DUCT ROUTES ARE SHOWN INDICATIVELY, ACTUAL ROUTES TO BE DETERMINED ON SITE
  5. ALL DISCREPANCIES TO BE REPORTED TO THE DESIGN ENGINEER

|           |                  |                                 |                   |        |
|-----------|------------------|---------------------------------|-------------------|--------|
| Master:   | MBNL / EE / H3G: | Project:                        | Purpose of Issue: | Issue: |
| M001      | MBNL             | NTQR                            | GA                | A      |
| Date:     | 01/08/2023       | Revision / Upgrade Description: |                   |        |
| Drawn:    | F. Borlina       | First Issue                     |                   |        |
| Checked:  | T. Clifford      |                                 |                   |        |
| Approved: | M. Venner        |                                 |                   |        |



Hutchison 3G UK Limited  
Green Park, 450 Longwater Avenue  
Reading, RG30 3UR  
Tel: 01628 765 000  
Fax: 01628 765 001



Hatfield Business Park  
Hatfield  
Hertfordshire  
AL10 9BW  
Tel: 01707 315000  
Fax: 01707 319001



Mobile Broadband Network Limited  
Sixth Floor, Thames Tower, Station Road, Reading, RG1 1LX



BEACONCOMMS

UNIT E3 PITTS CLEAVE INDUSTRIAL ESTATE, TAVISTOCK, DEVON, PL19 0PW  
sales@beaconcomms.co.uk Tel: +44 (0)1822 610610

Site Name: VALE ROAD

Site ID: 1707938

Address: VALE ROAD  
GRAVESHAM  
KENT  
DA11 9RE

Title: 150 EXISTING ELEVATION A


Project: MBNL NTQR

Purpose of Issue: GENERAL ARRANGEMENT

|             |               |              |
|-------------|---------------|--------------|
| EE Cell ID: | MBNL Cell ID: | 3UK Cell ID: |
| 30702       | GVM091        | -            |

Master Drawing No: 1707938\_GVM091\_30702\_M001

Issue: A

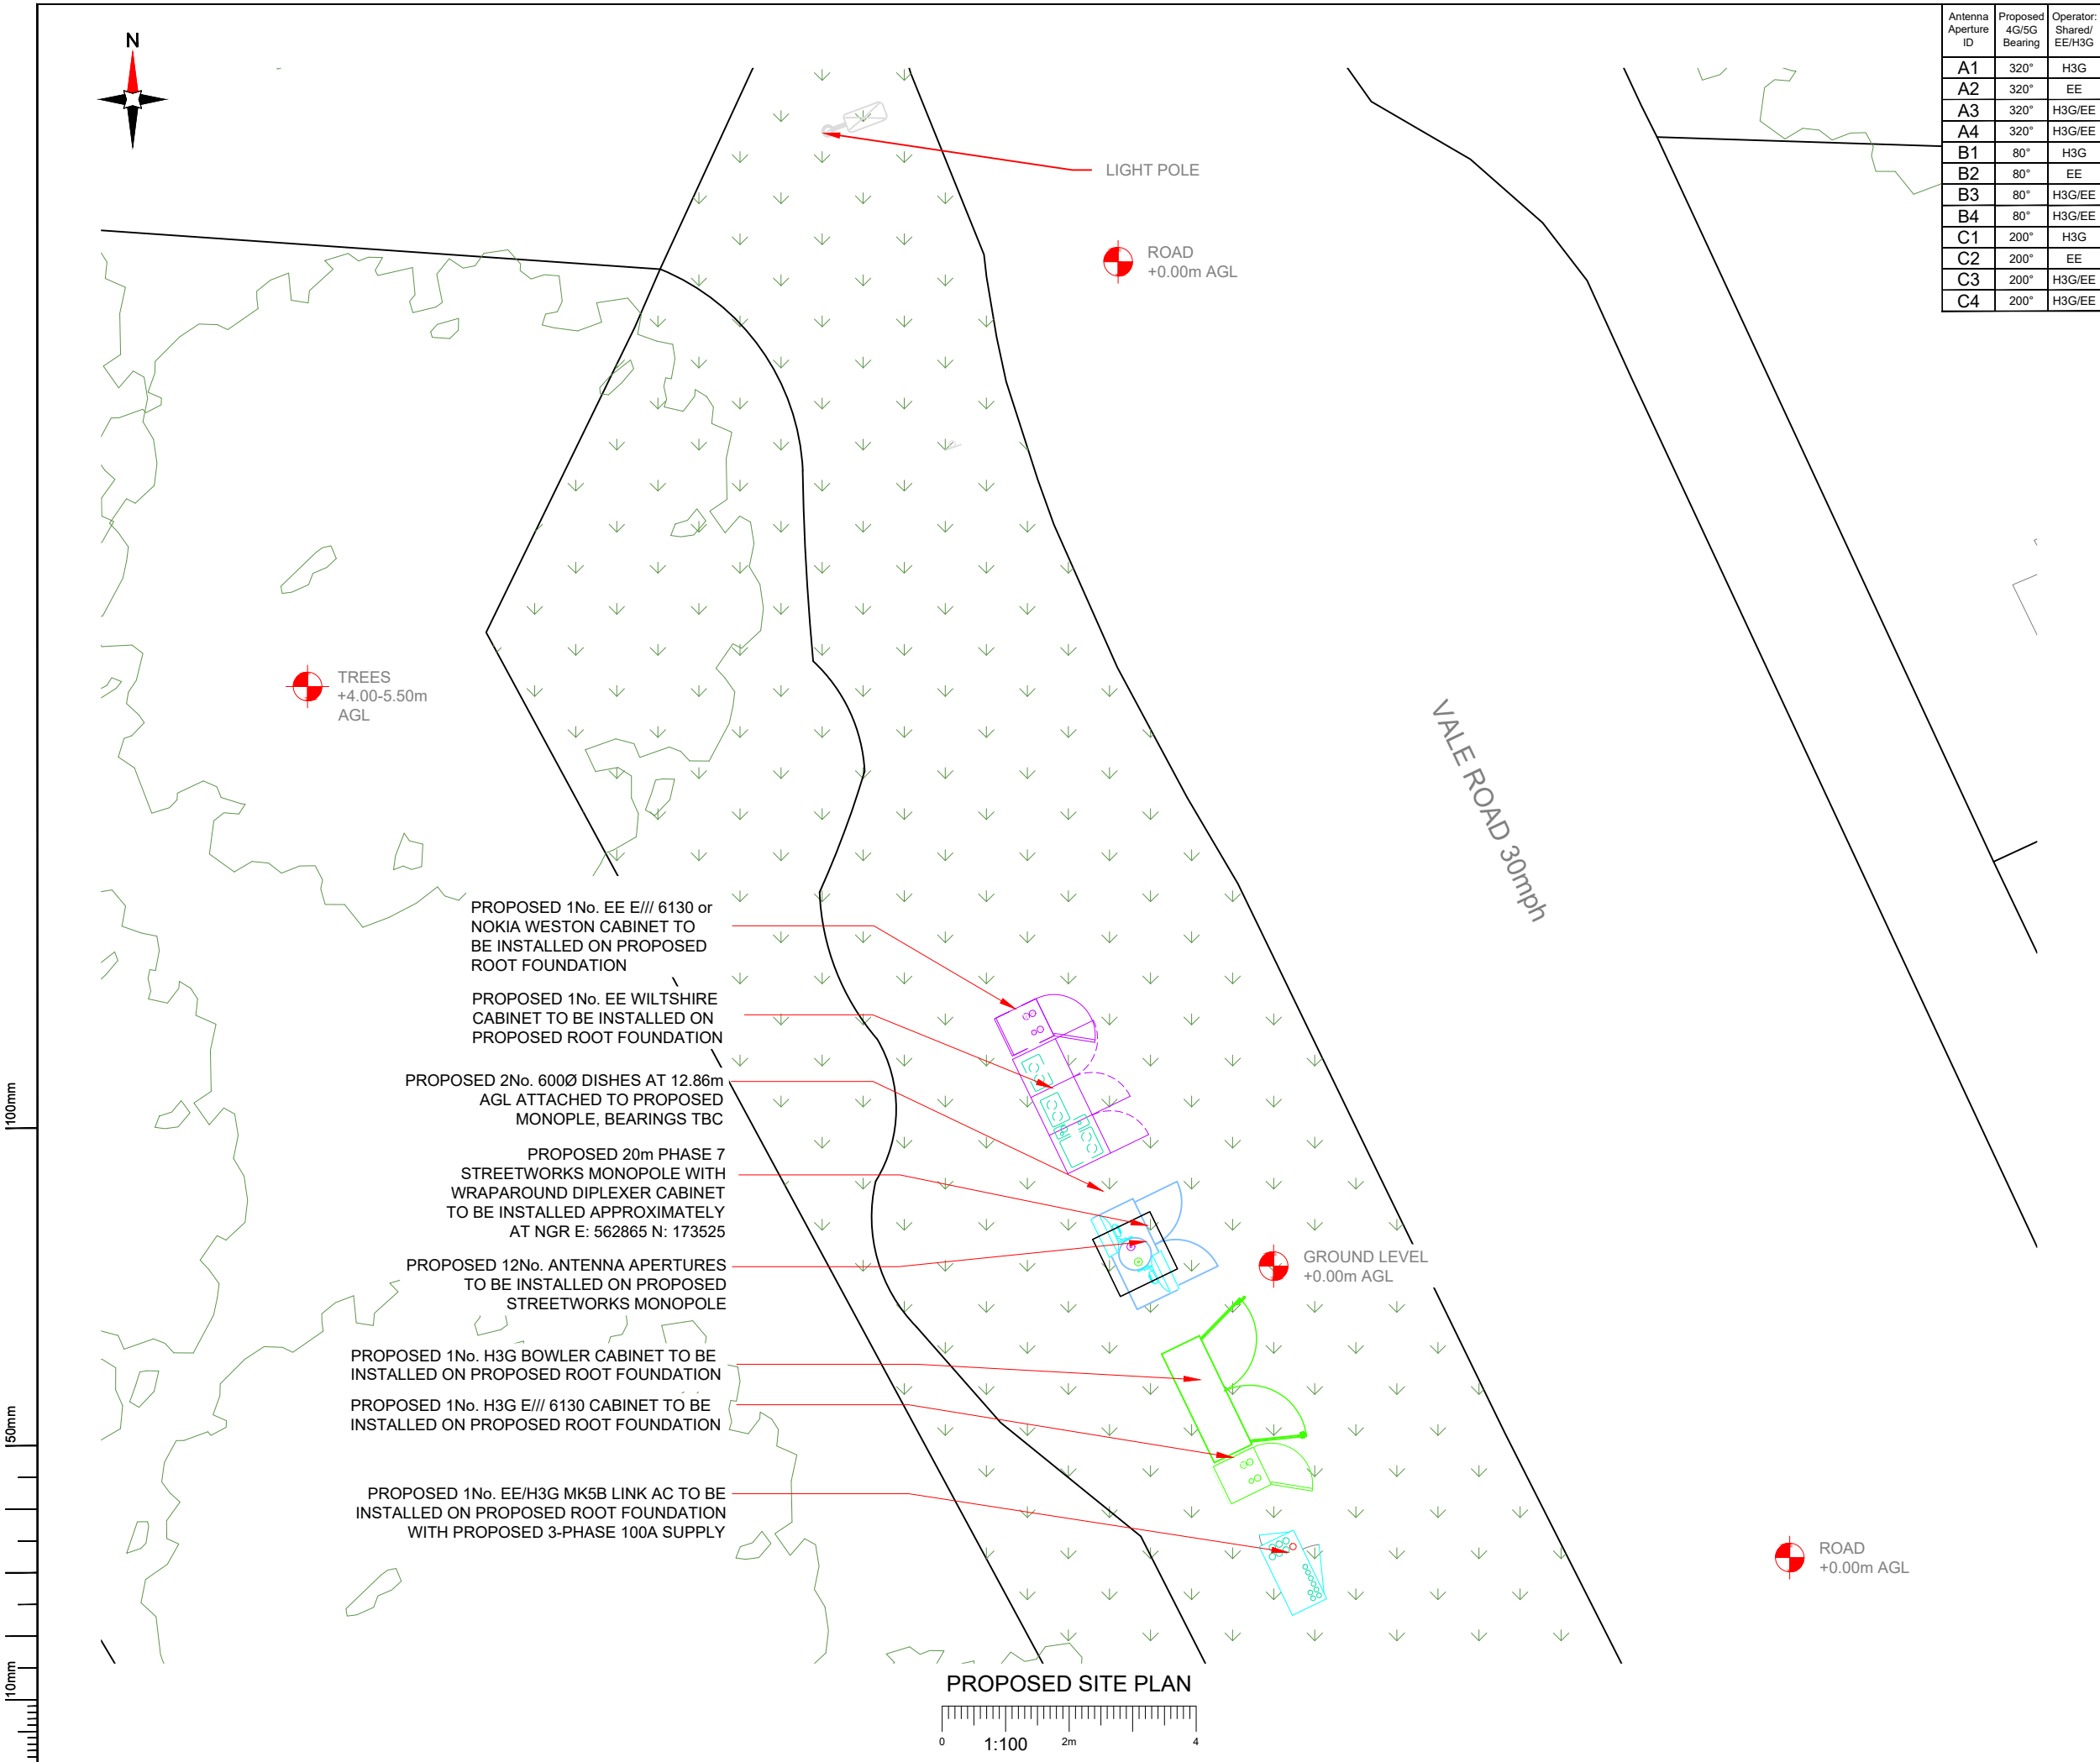

| Antenna Aperture ID | Proposed 4G/5G Bearing | Operator: Shared/ EE/H3G |
|---------------------|------------------------|--------------------------|
| A1                  | 320°                   | H3G                      |
| A2                  | 320°                   | EE                       |
| A3                  | 320°                   | H3G/EE                   |
| A4                  | 320°                   | H3G/EE                   |
| B1                  | 80°                    | H3G                      |
| B2                  | 80°                    | EE                       |
| B3                  | 80°                    | H3G/EE                   |
| B4                  | 80°                    | H3G/EE                   |
| C1                  | 200°                   | H3G                      |
| C2                  | 200°                   | EE                       |
| C3                  | 200°                   | H3G/EE                   |
| C4                  | 200°                   | H3G/EE                   |

- NOTES:
- ALL DIMENSIONS ARE IN MM UNLESS OTHERWISE STATED
  - DRAWING TO BE READ IN CONJUNCTION WITH ALL RELEVANT DRAWINGS AND SPECIFICATIONS
  - DO NOT SCALE DRAWINGS, ALL DIMENSION TO BE CHECKED ON SITE. ALL DIMENSIONS SHOWN ON EXISTING STRUCTURES ARE APPROXIMATE AND THE CONTRACTOR IS TO OBTAIN ALL EXACT SITE DIMENSIONS NECESSARY TO CARRY OUT PROPOSED WORKS
  - DUCT ROUTES ARE SHOWN INDICATIVELY, ACTUAL ROUTES TO BE DETERMINED ON SITE
  - ALL DISCREPANCIES TO BE REPORTED TO THE DESIGN ENGINEER

|           |                  |                                 |                   |        |
|-----------|------------------|---------------------------------|-------------------|--------|
| Master:   | MBNL / EE / H3G: | Project:                        | Purpose of Issue: | Issue: |
| M001      | MBNL             | NTQR                            | GA                | A      |
| Date:     | 01/08/2023       | Revision / Upgrade Description: |                   |        |
| Drawn:    | F. Borlina       | First Issue                     |                   |        |
| Checked:  | T. Clifford      |                                 |                   |        |
| Approved: | M. Venner        |                                 |                   |        |



Hutchison 3G UK Limited  
Green Park, 450 Longwater Avenue  
Reading, RG30 3UR  
Tel: 01628 765 500  
Fax: 01628 765 501



Hatfield Business Park  
Hatfield  
Hertfordshire  
AL10 9BW  
Tel: 01707 315000  
Fax: 01707 319001




Mobile Broadband Network Limited  
Sixth Floor, Thames Tower, Station Road, Reading, RG1 1LX



UNIT E3 PITTS CLEAVE INDUSTRIAL ESTATE, TAVISTOCK, DEVON, PL19 0PW  
sales@beaconcomms.co.uk  
Tel: +44 (0)1822 610610

|                    |                                            |               |        |
|--------------------|--------------------------------------------|---------------|--------|
| Site Name:         | VALE ROAD                                  |               |        |
| Site ID:           | 1707938                                    |               |        |
| Address:           | VALE ROAD<br>GRAVESHAM<br>KENT<br>DA11 9RE |               |        |
| Title:             | 215 PROPOSED SITE PLAN                     |               |        |
| Project:           | MBNL NTQR                                  |               |        |
| Purpose of Issue:  | GENERAL ARRANGEMENT                        |               |        |
| EE Cell ID:        | 30702                                      | MBNL Cell ID: | GVM091 |
| 3UK Cell ID:       | -                                          |               |        |
| Master Drawing No: | 1707938_GVM091_30702_M001                  |               |        |
| Issue:             | A                                          |               |        |

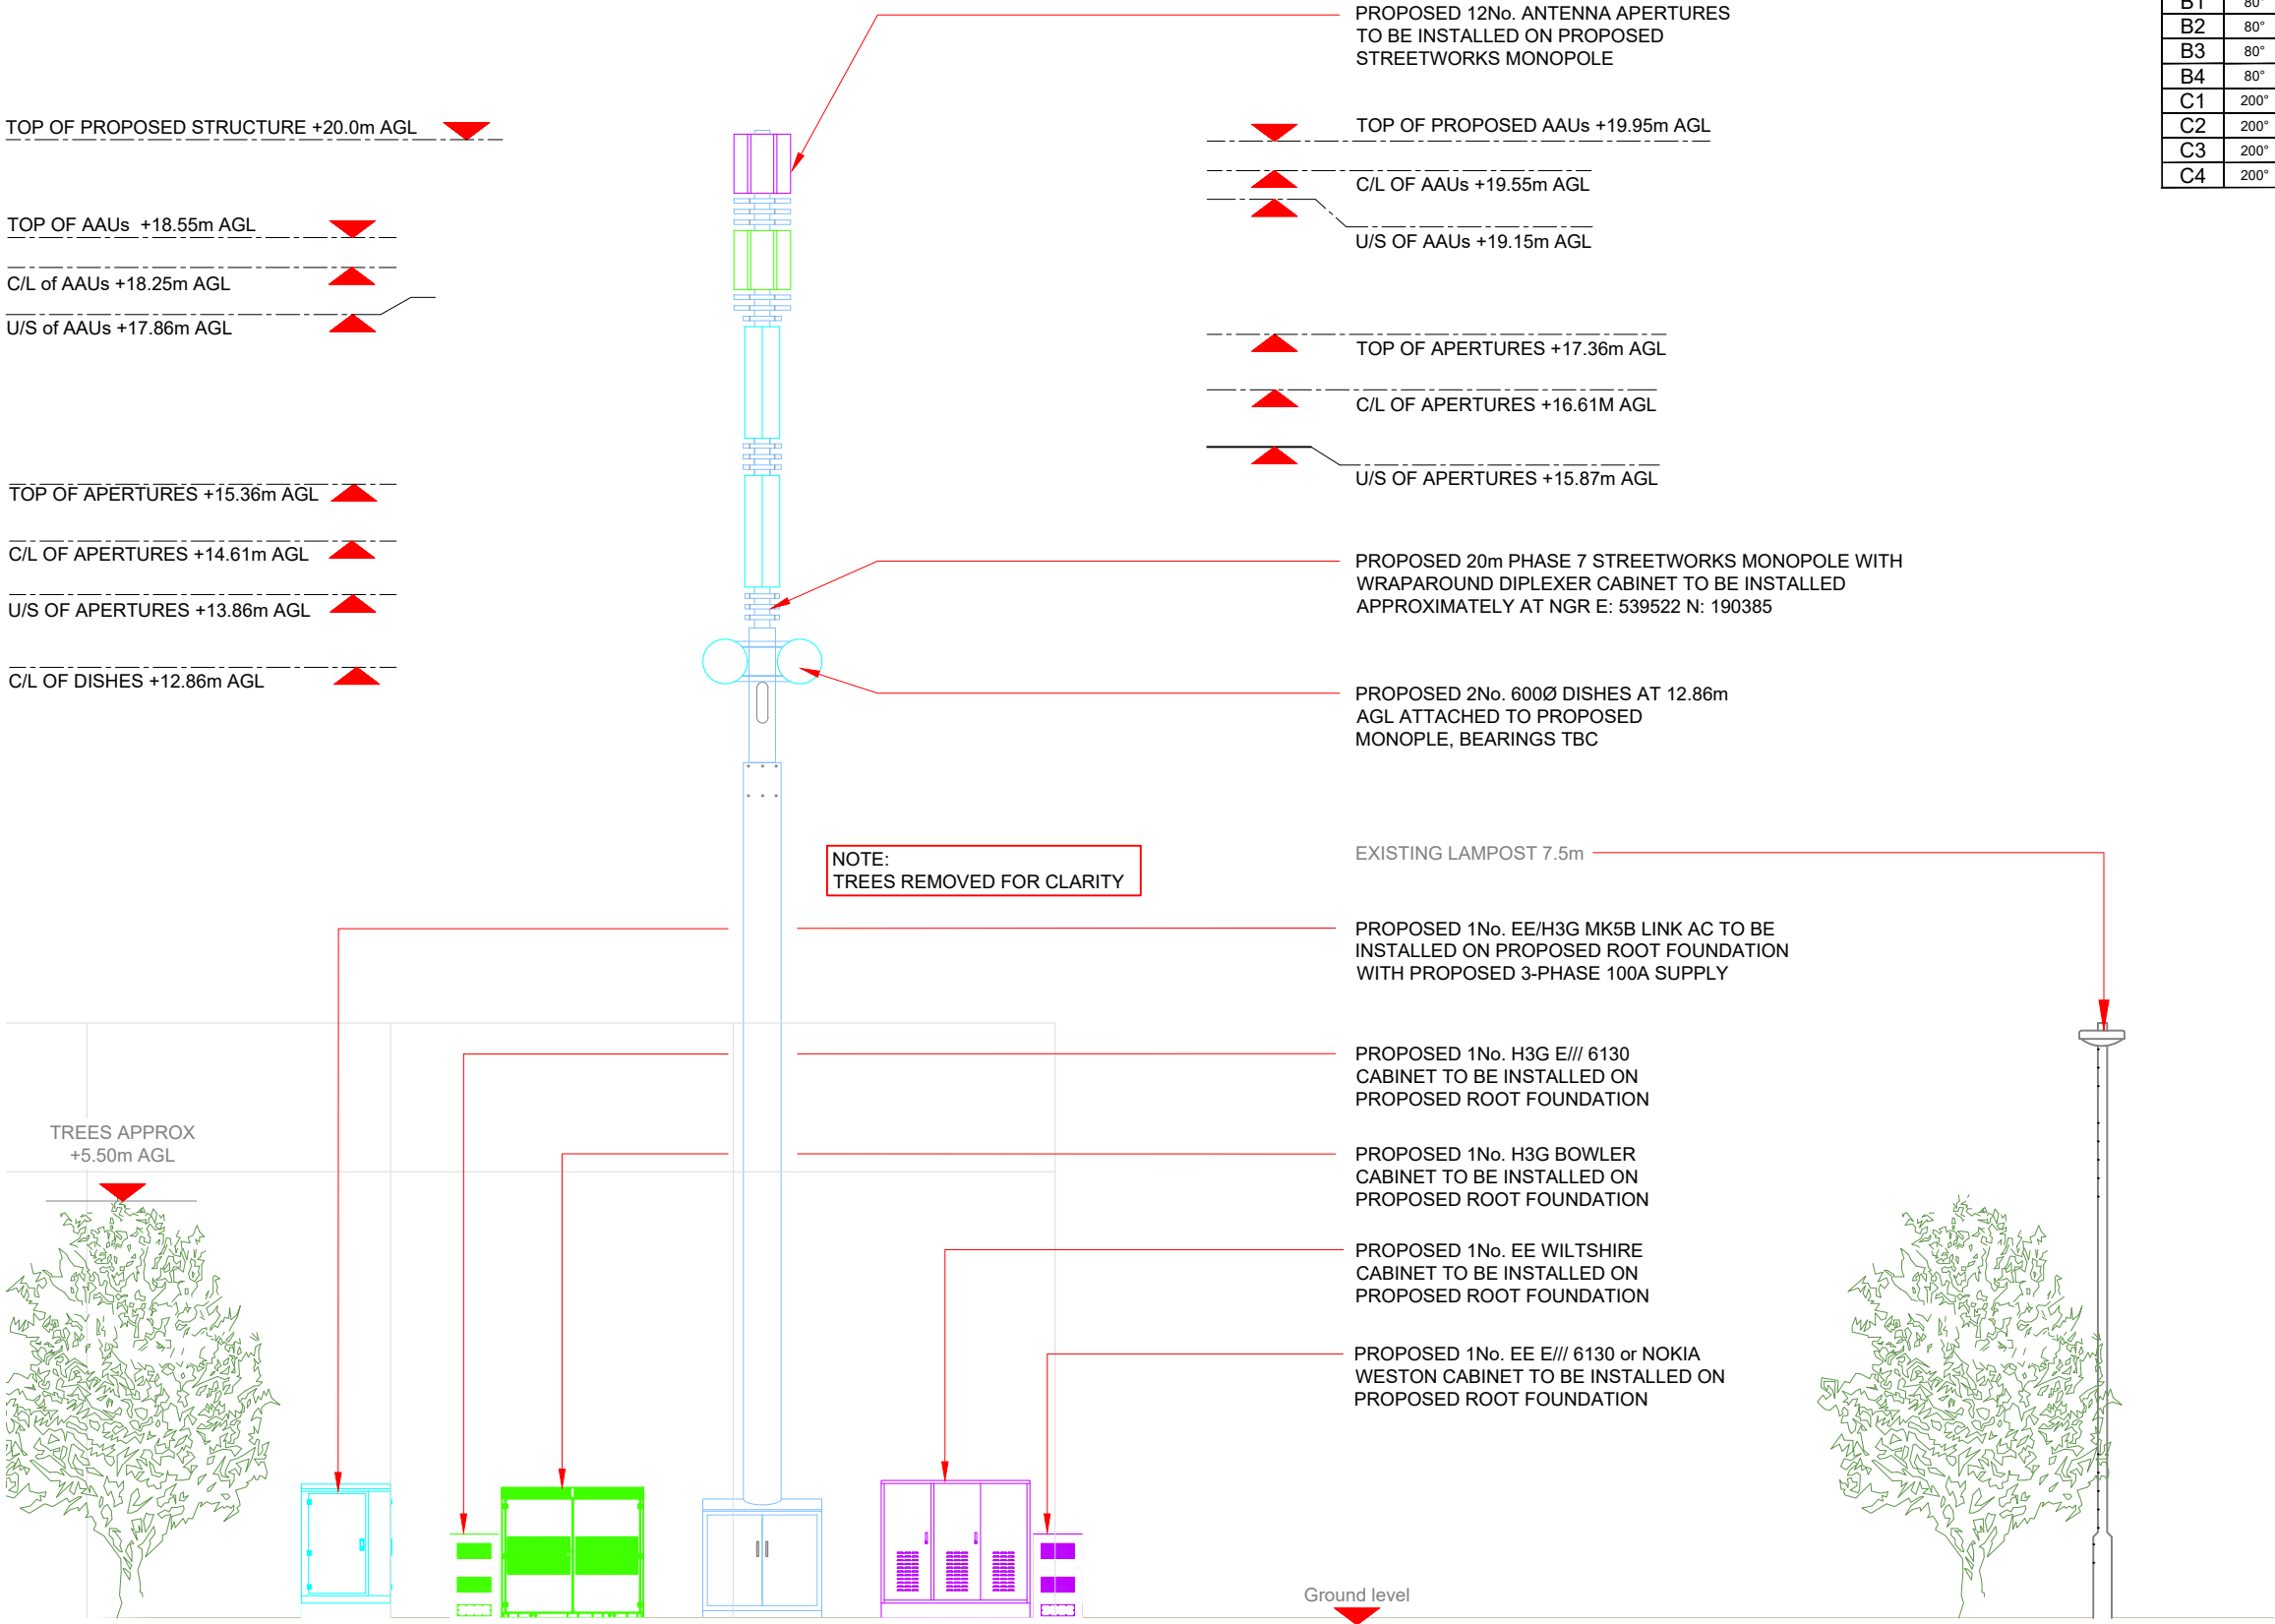

| Antenna Aperture ID | Proposed 4G/5G Bearing | Operator: Shared/ EE/H3G |
|---------------------|------------------------|--------------------------|
| A1                  | 320°                   | H3G                      |
| A2                  | 320°                   | EE                       |
| A3                  | 320°                   | H3G/EE                   |
| A4                  | 320°                   | H3G/EE                   |
| B1                  | 80°                    | H3G                      |
| B2                  | 80°                    | EE                       |
| B3                  | 80°                    | H3G/EE                   |
| B4                  | 80°                    | H3G/EE                   |
| C1                  | 200°                   | H3G                      |
| C2                  | 200°                   | EE                       |
| C3                  | 200°                   | H3G/EE                   |
| C4                  | 200°                   | H3G/EE                   |

- NOTES:
- ALL DIMENSIONS ARE IN MM UNLESS OTHERWISE STATED
  - DRAWING TO BE READ IN CONJUNCTION WITH ALL RELEVANT DRAWINGS AND SPECIFICATIONS
  - DO NOT SCALE DRAWINGS, ALL DIMENSION TO BE CHECKED ON SITE. ALL DIMENSIONS SHOWN ON EXISTING STRUCTURES ARE APPROXIMATE AND THE CONTRACTOR IS TO OBTAIN ALL EXACT SITE DIMENSIONS NECESSARY TO CARRY OUT PROPOSED WORKS
  - DUCT ROUTES ARE SHOWN INDICATIVELY, ACTUAL ROUTES TO BE DETERMINED ON SITE
  - ALL DISCREPANCIES TO BE REPORTED TO THE DESIGN ENGINEER

|                  |                       |                      |                      |                                             |
|------------------|-----------------------|----------------------|----------------------|---------------------------------------------|
| Master: M001     | MBNL / EE / H3G: MBNL | Project: NTQR        | Purpose of Issue: GA | Issue: A                                    |
| Date: 01/08/2023 | Drawn: F. Borlina     | Checked: T. Clifford | Approved: M. Venner  | Revision / Upgrade Description: First Issue |



Hutchison 3G UK Limited  
Green Park, 450 Longwater Avenue  
Reading, RG30 3UR  
Tel: 01628 765 000  
Fax: 01628 765 001



Hatfield Business Park  
Hatfield  
Hertfordshire  
AL10 9BW  
Tel: 01707 315000  
Fax: 01707 319001

**MBNL** Mobile Broadband Network Limited  
Sixth Floor, Thames Tower, Station Road, Reading, RG1 1LX

**BEACONCOMMS**  
UNIT E3 PITTS CLEAVE INDUSTRIAL ESTATE, TAVISTOCK, DEVON, PL19 0PW  
sales@beaconcomms.co.uk Tel: +44 (0)1822 610610

|                    |                                            |               |        |
|--------------------|--------------------------------------------|---------------|--------|
| Site Name:         | VALE ROAD                                  |               |        |
| Site ID:           | 1707938                                    |               |        |
| Address:           | VALE ROAD<br>GRAVESHAM<br>KENT<br>DA11 9RE |               |        |
| Title:             | 265 PROPOSED ELEVATION                     |               |        |
| Project:           | MBNL NTQR                                  |               |        |
| Purpose of Issue:  | GENERAL ARRANGEMENT                        |               |        |
| EE Cell ID:        | 30702                                      | MBNL Cell ID: | GVM091 |
| 3UK Cell ID:       | -                                          |               |        |
| Master Drawing No: | 1707938_GVM091_30702_M001                  |               | Issue: |
|                    |                                            |               | A      |

| Passive Infrastructure Equipment Capacity & Lead Operator |     |     |      |
|-----------------------------------------------------------|-----|-----|------|
| A                                                         | B   | C   | LEAD |
| SW1                                                       | SW1 | SW1 | H3G  |