



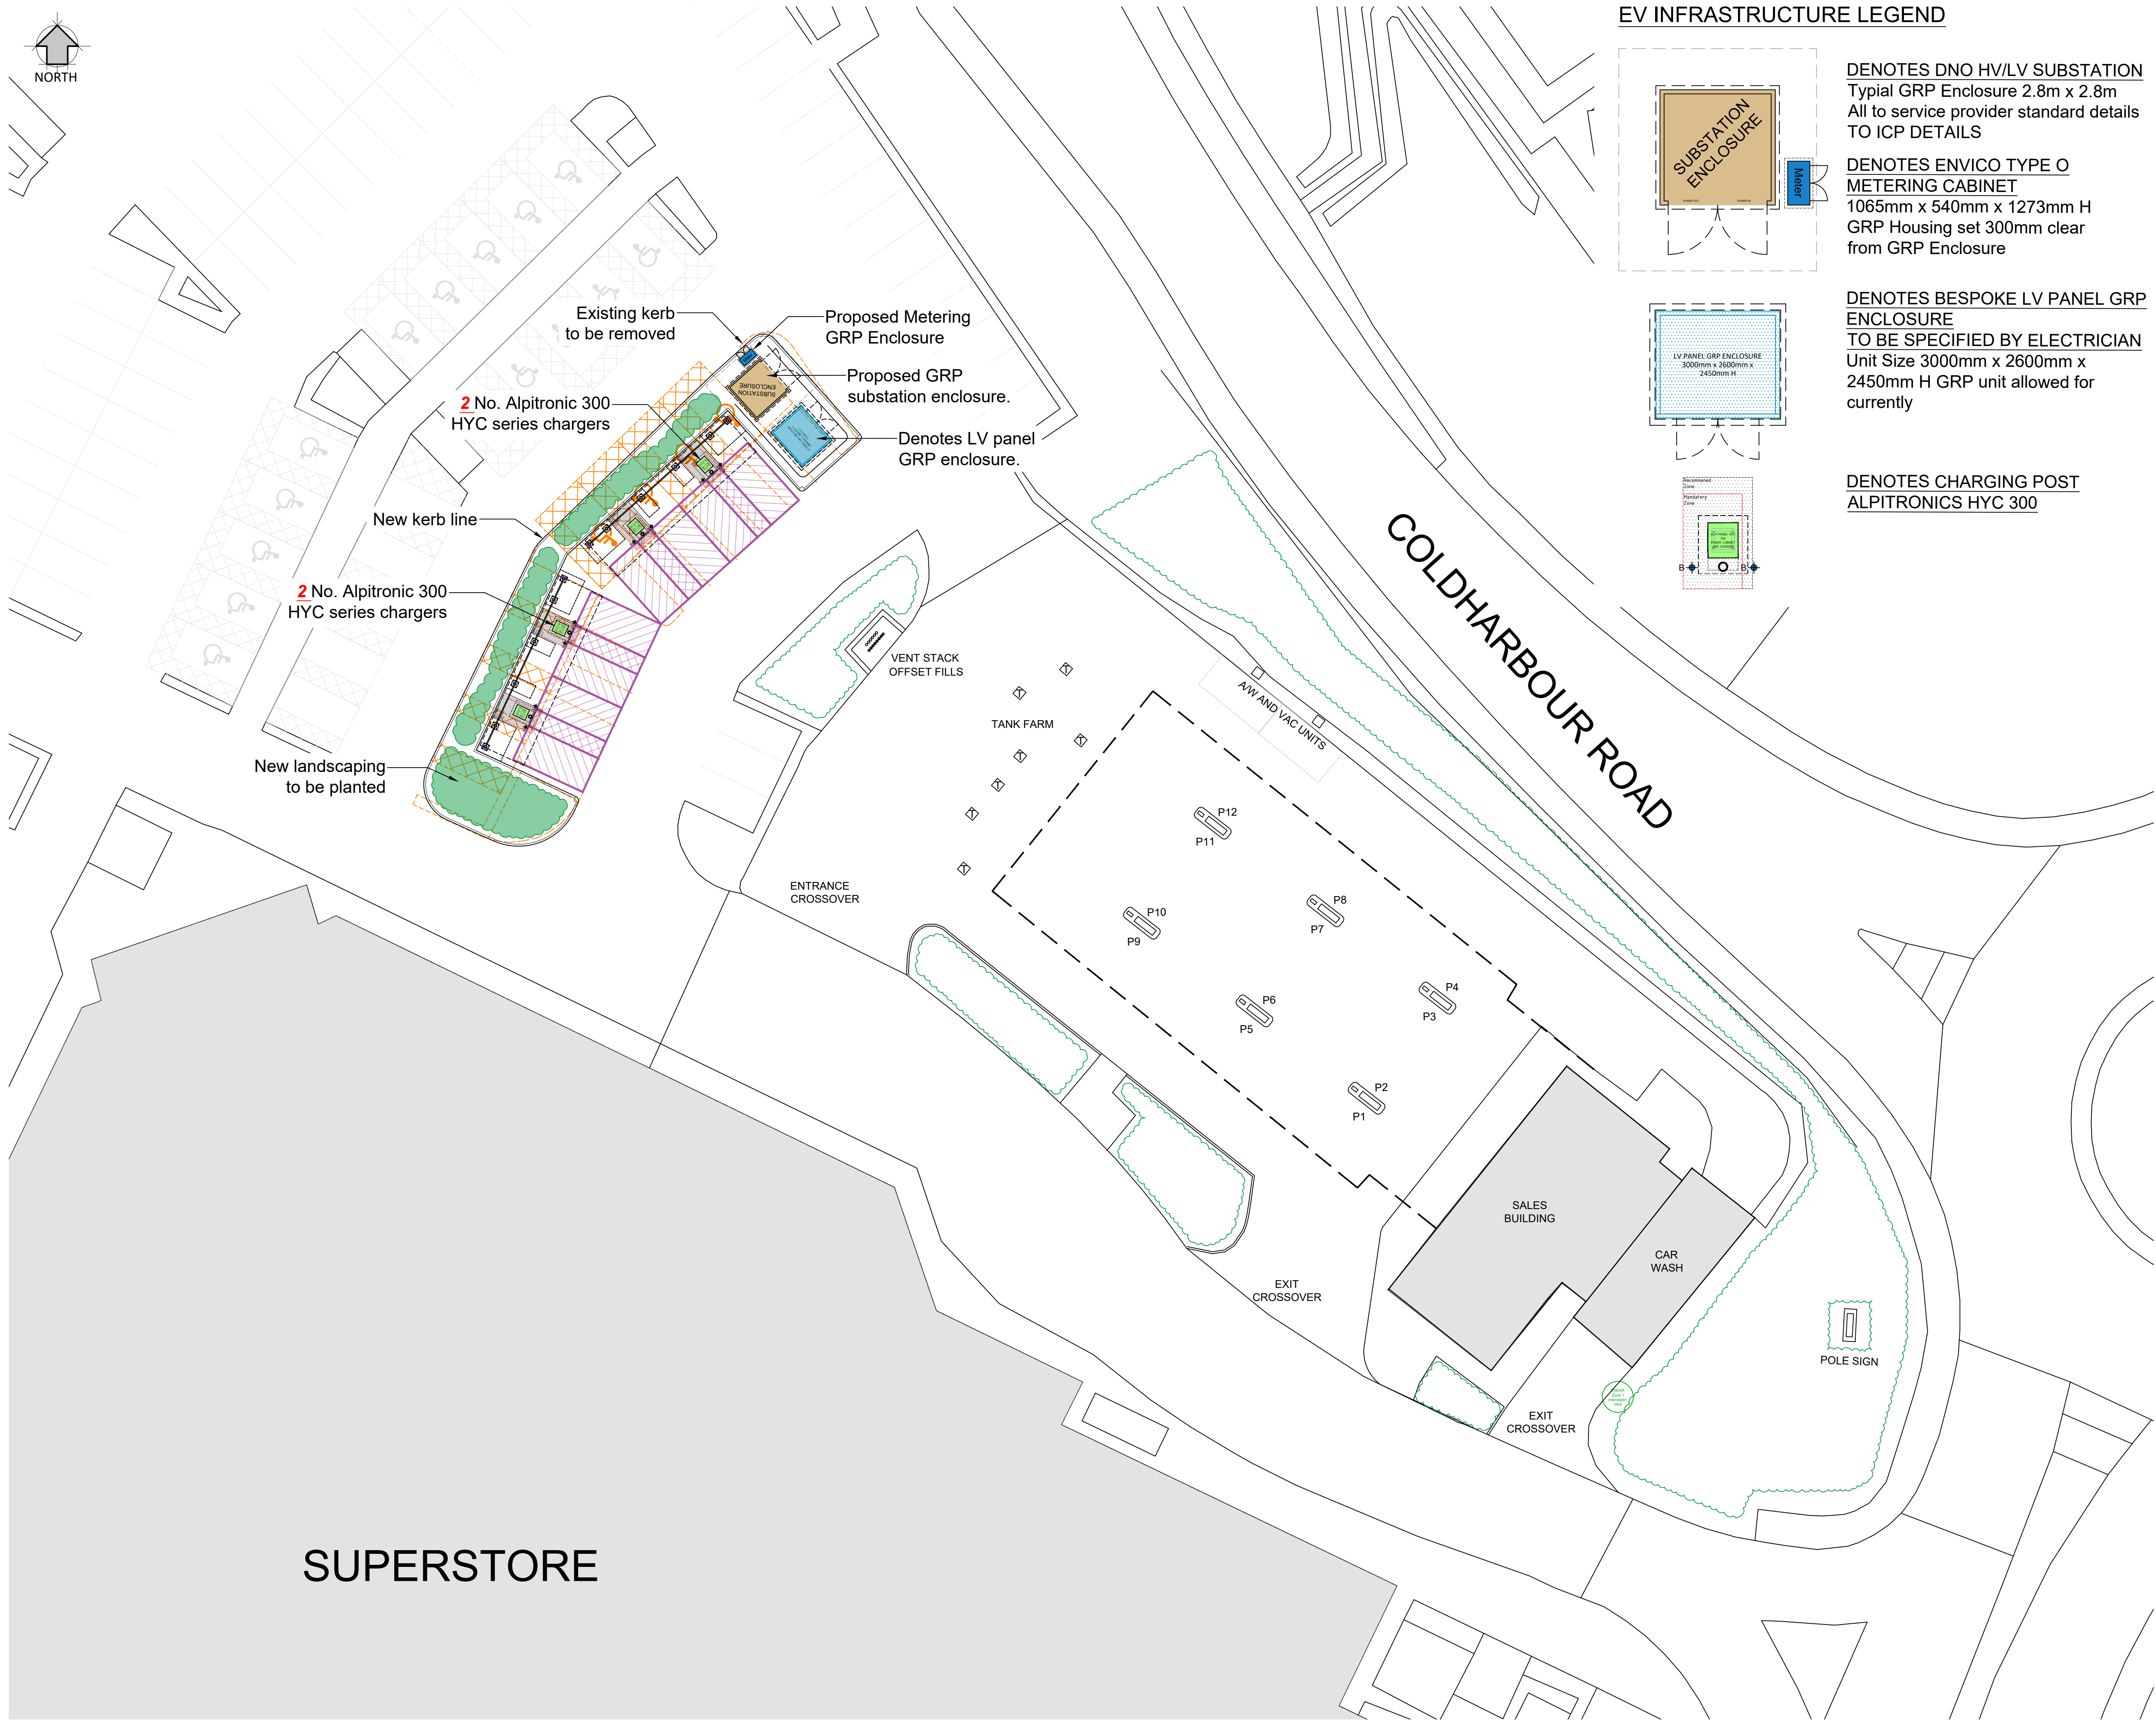


EV INFRASTRUCTURE LEGEND

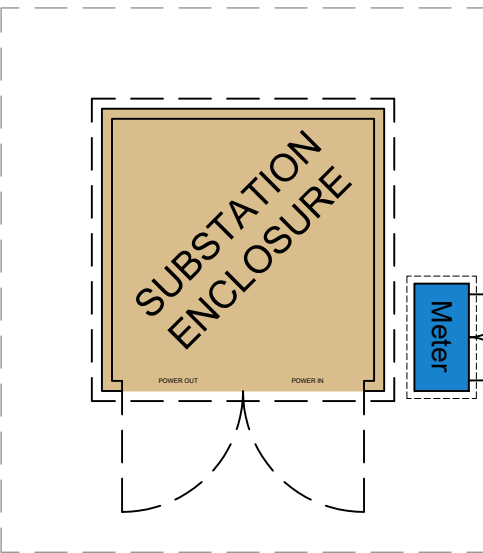


DENOTES DNO HV/LV SUBSTATION
Typical GRP Enclosure 2.8m x 2.8m
All to service provider standard details
TO ICP DETAILS

DENOTES ENVICO TYPE O METERING CABINET
1065mm x 540mm x 1273mm H
GRP Housing set 300mm clear
from GRP Enclosure

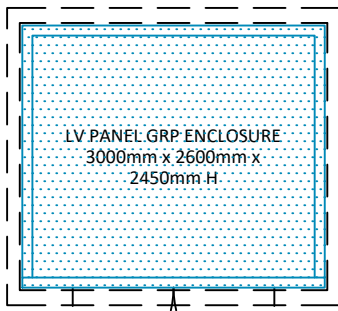

DENOTES BESPOKE LV PANEL GRP ENCLOSURE
TO BE SPECIFIED BY ELECTRICIAN
Unit Size 3000mm x 2600mm x
2450mm H GRP unit allowed for
currently

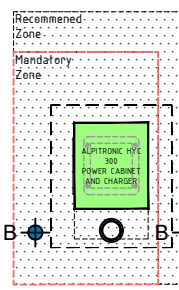

DENOTES CHARGING POST
ALPITRONICS HYC 300

DRAWING NOTES

COPYRIGHT ©
This drawing and the details herein are the copyright of MBH Design Studio Ltd. and must not be reproduced, altered or passed to any third party without prior written consent.

This drawing has been produced for the project listed below, is submitted in support of this application application to the Local Planning Authority and is not intended for use by any other person or for any other purpose.

Every effort has been made to ensure the accuracy of these drawings, however MBH Design Studio Ltd. accept no responsibility for any discrepancies arising from the reuse of survey information and preliminary drawings commissioned by the Applicant from others.


GENERAL NOTES

- This drawing has been prepared for the sole purpose of obtaining planning permission.
- This drawing is to be read in conjunction with drawings numbered:

14313-2298-209	Location Plan
14313-2298-209	Block Plan
14313-2298-209	Existing Site Plan
14313-2298-209	Proposed Site Plans
14313-2298-209	EV Canopy and Charger Details
14313-2298-209	Substation Enclosure Details
14313-2298-209	LV Enclosure Details
14313-2298-209	Meter Cabinet Details
- Any advertisements are indicative and are subject to a separate advertisement application
- Any neighbouring buildings shown on the elevations are diagrammatic and have been extrapolated from site photographs. They have not been measured.

DRAWING LEGEND

- EXISTING KERB
- PROPOSED KERB
- PROPOSED DROPPED KERB
- DEMOLISHED
- EXISTING LINE WORK
- PROPOSED LINE WORKS
- PROPOSED EV BOLLARD - RAL 5015
- EXISTING FLOOD LIGHT
- PROPOSED FLOOD LIGHT
- EXISTING FENCE LINE
- PROPOSED FENCE LINE

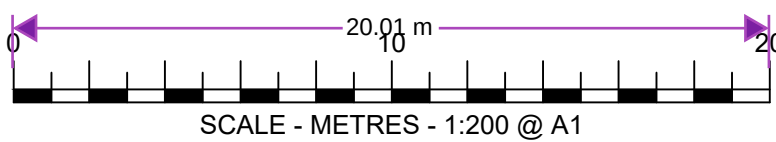

A	29.08.2024	PLANNING EDITS	KL/RRB
REV	DATE	DESCRIPTION	DRAWN/CHECKED
REVISION NOTES			

PLANNING



MBH Design Studio Ltd.
Rosemount House, Rosemount Avenue, West Byfleet, Surrey, KT14 6LB
www.mbhstd.com t: 01932 352 727 f: 01932 351 545

CLIENT



PROJECT

GRAVESEND SERVICE STATION
COLDHARBOUR ROAD, NORTHFLEET,
GRAVESEND,
DA11 7HU

DRAWING TITLE

PROPOSED SITE PLAN

DRAWN BY	DATE	SCALE	PAPER SIZE
HP	23.08.2024	1:200	A1
CHECKED BY	DRAWING NUMBER	REV.	
JN	14313-2298-201	A	