


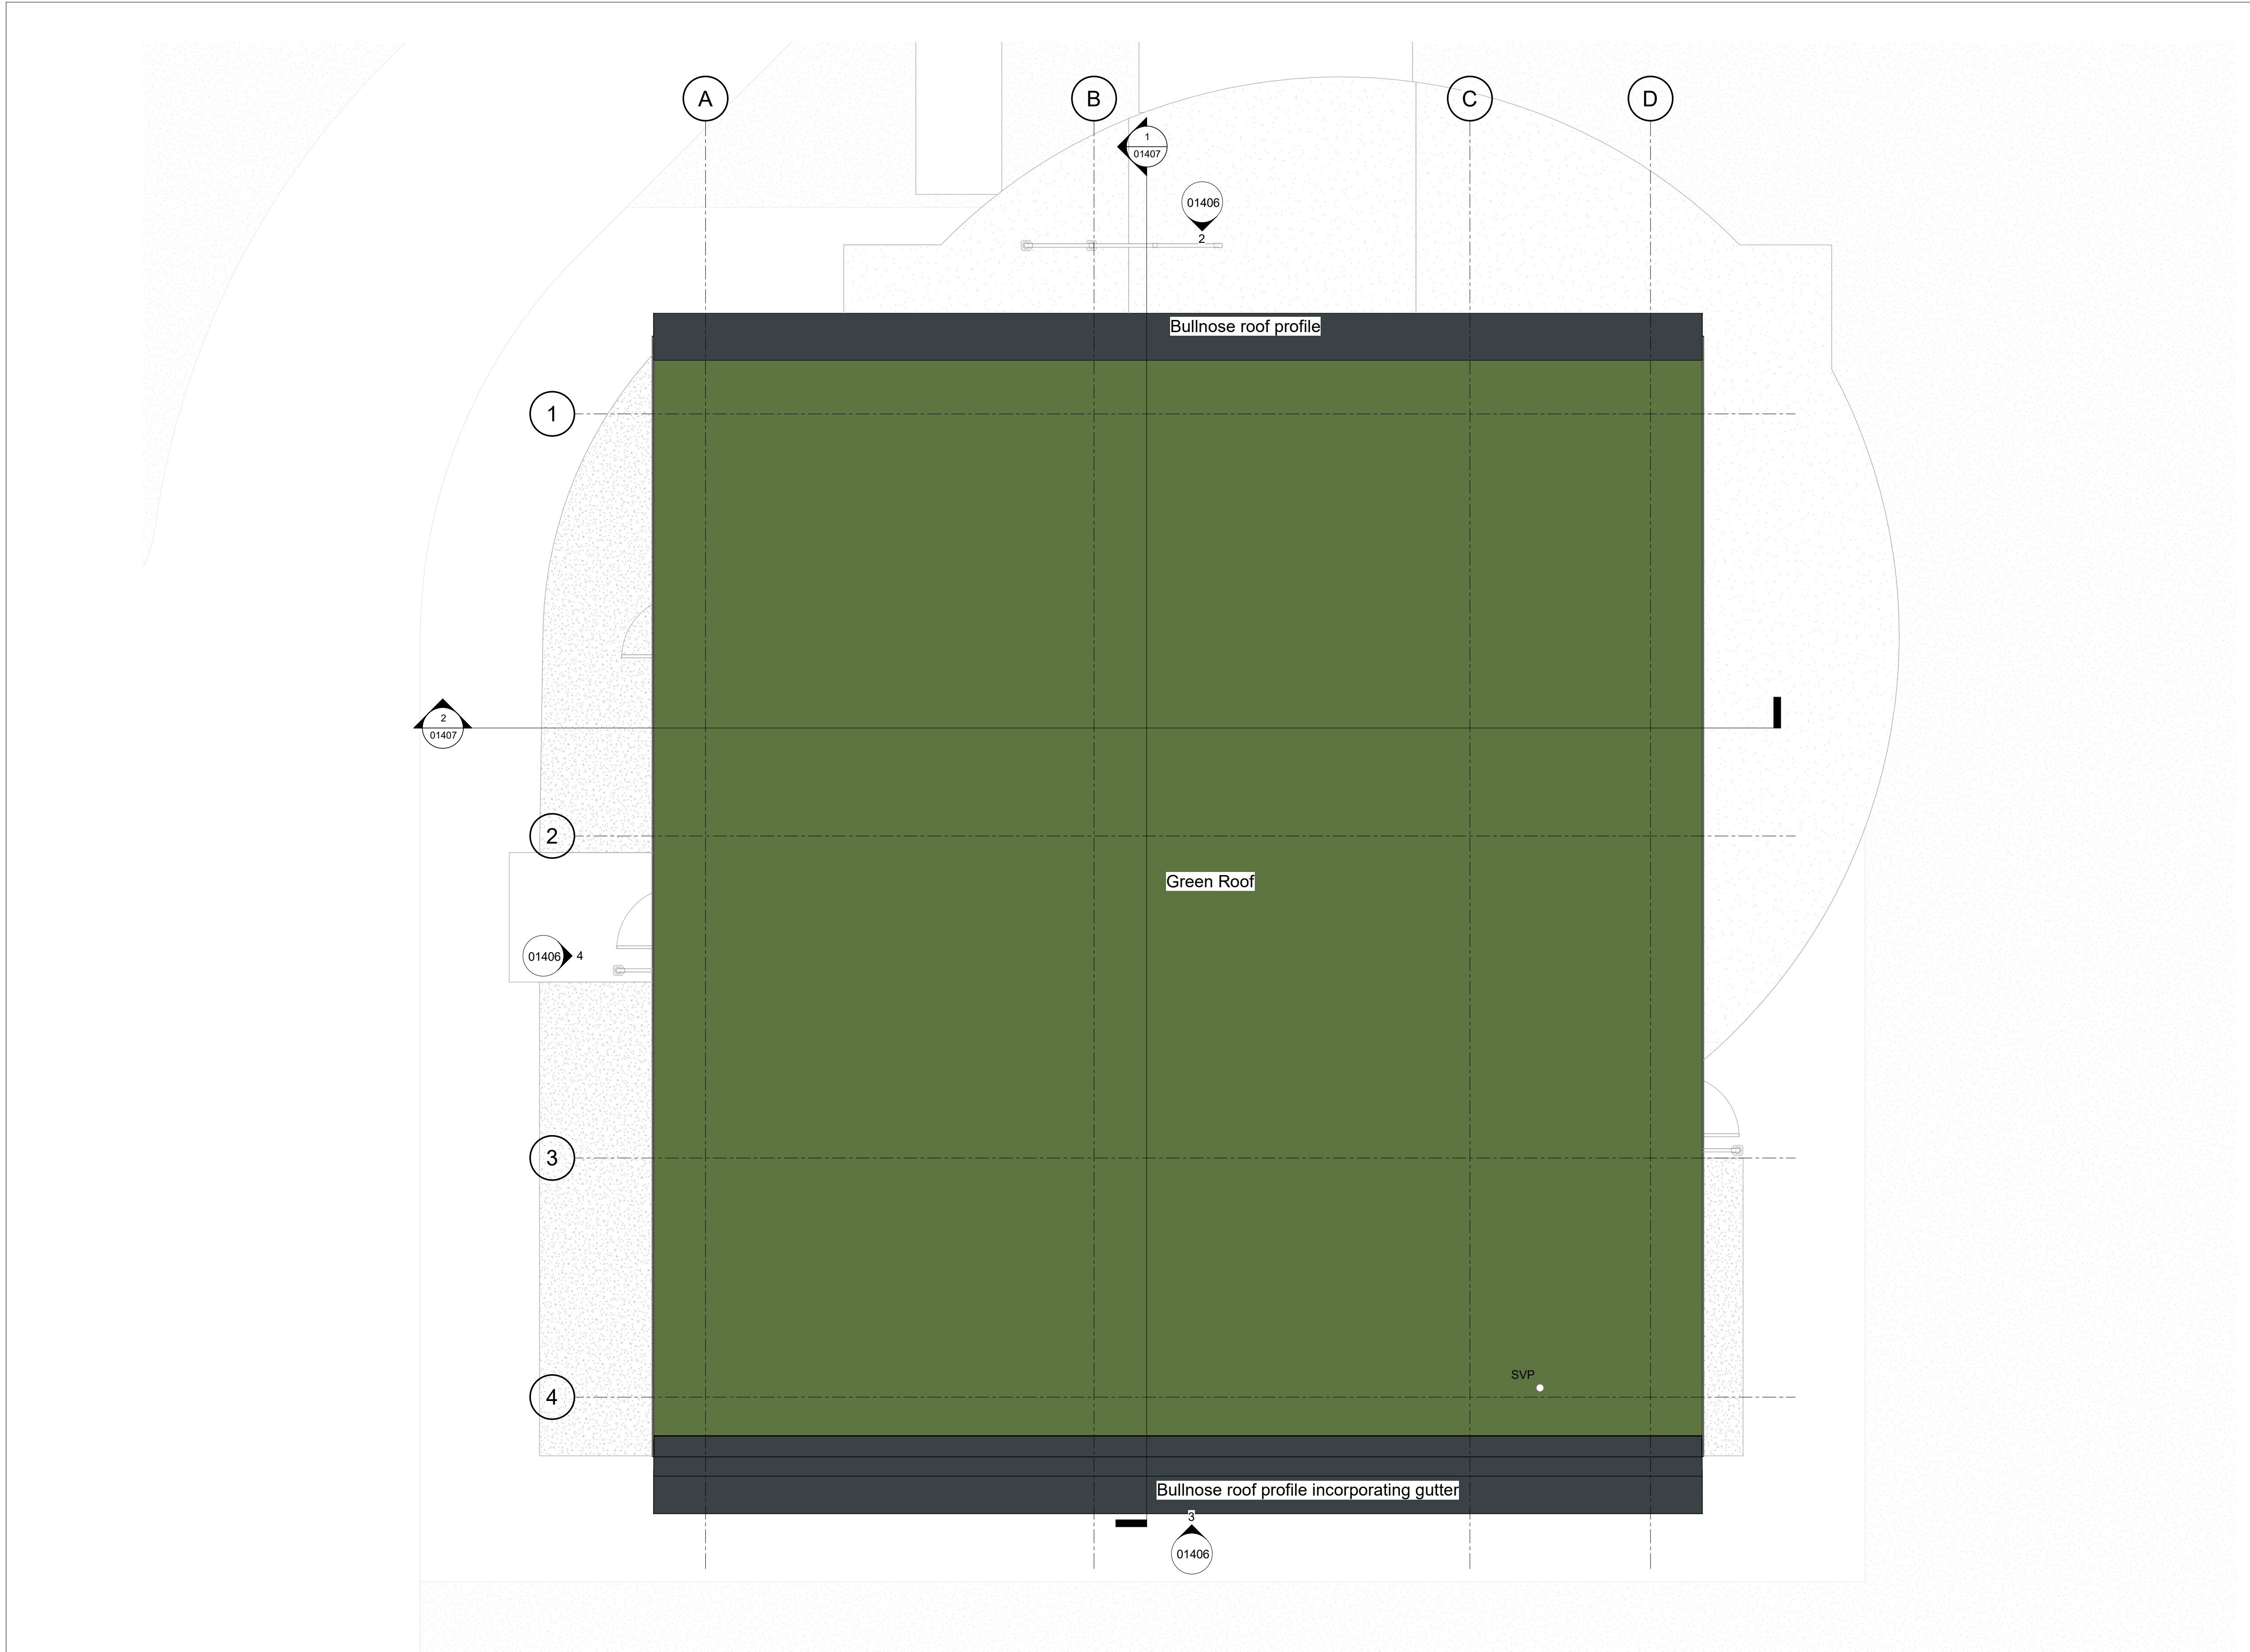

Roof Plan (Scale 1/50)

NOTES

1. ALL DIMENSIONS IN MILLIMETERS UNLESS OTHERWISE STATED
2. ALL LEVELS ARE IN METERS ABOVE ORDANANCE DATUM (mAOD)
3. FOR GRAVESEND SHAFT SEE PDD-100116-LAY-123
4. SHAFT CENTRE POINT AT, East = 567427.615, North = 174094.990
5. ROAD AND FOOTPATH ALIGNMENTS SHOWN ARE INDICATIVE ONLY
6. SVP - SOIL & VENT PIPE
RWP - RAINWATER PIPE
UPS - UNINTERRUPTED POWER SUPPLY


REFERENCE DRAWINGS

PDD-100116-LAY-106 - New Gravesend 400kV Cable Sealing End Compound HV Plant Plan Drawing

PDD-100116-LAY-102 - CSE Layout with cable termination arrangement (Gravesend site) (A784/A785)

PDD-100116-LAY-208 – GRAVESEND HEADHOUSE CONCEPT PROPOSAL

PDD-100116-LAY-123 – GRAVESEND SHAFT GENERAL ARRANGEMENT

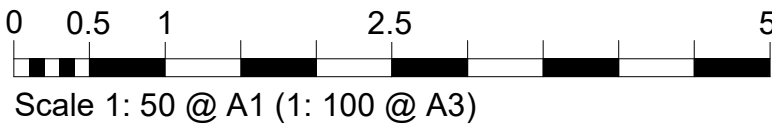

P03	Updated with structural and services information	RW	JK	NS	04/12/23
P02	Updated to comments received	RO	RW	JK	21/09/23
P01	Initial Issue	RO	RW	JK	07/09/23
Rev	Description	Cre'd	Chk'd	App'd	Date

nationalgrid

Master Scheme No:	Sub-Scheme No:	Site:
100116	-	NEW GRAVESEND CSEC

Scheme Name:
TKRE GRAIN-TILBURY AND KINGSNORTH-TILBURY 400kV UPRATING

Document Title:

Gravesend Headhouse - Planning - Proposed Roof Floor Plan

Created by: RO	Date: 07/09/23	Checked by: RW	Date: 07/09/23	Approved by: JK	Date: 07/09/23
Development Eng: BT	Document Type: Drawings	Scale: 1 : 50	Format: A1	Sheet(s): 1 of 1	Rev: P03

National Grid Document Number:
PDD-100116-LAY-056

FEED Document Number:
30003364-BHK-XX-XX-DR-A-01405