


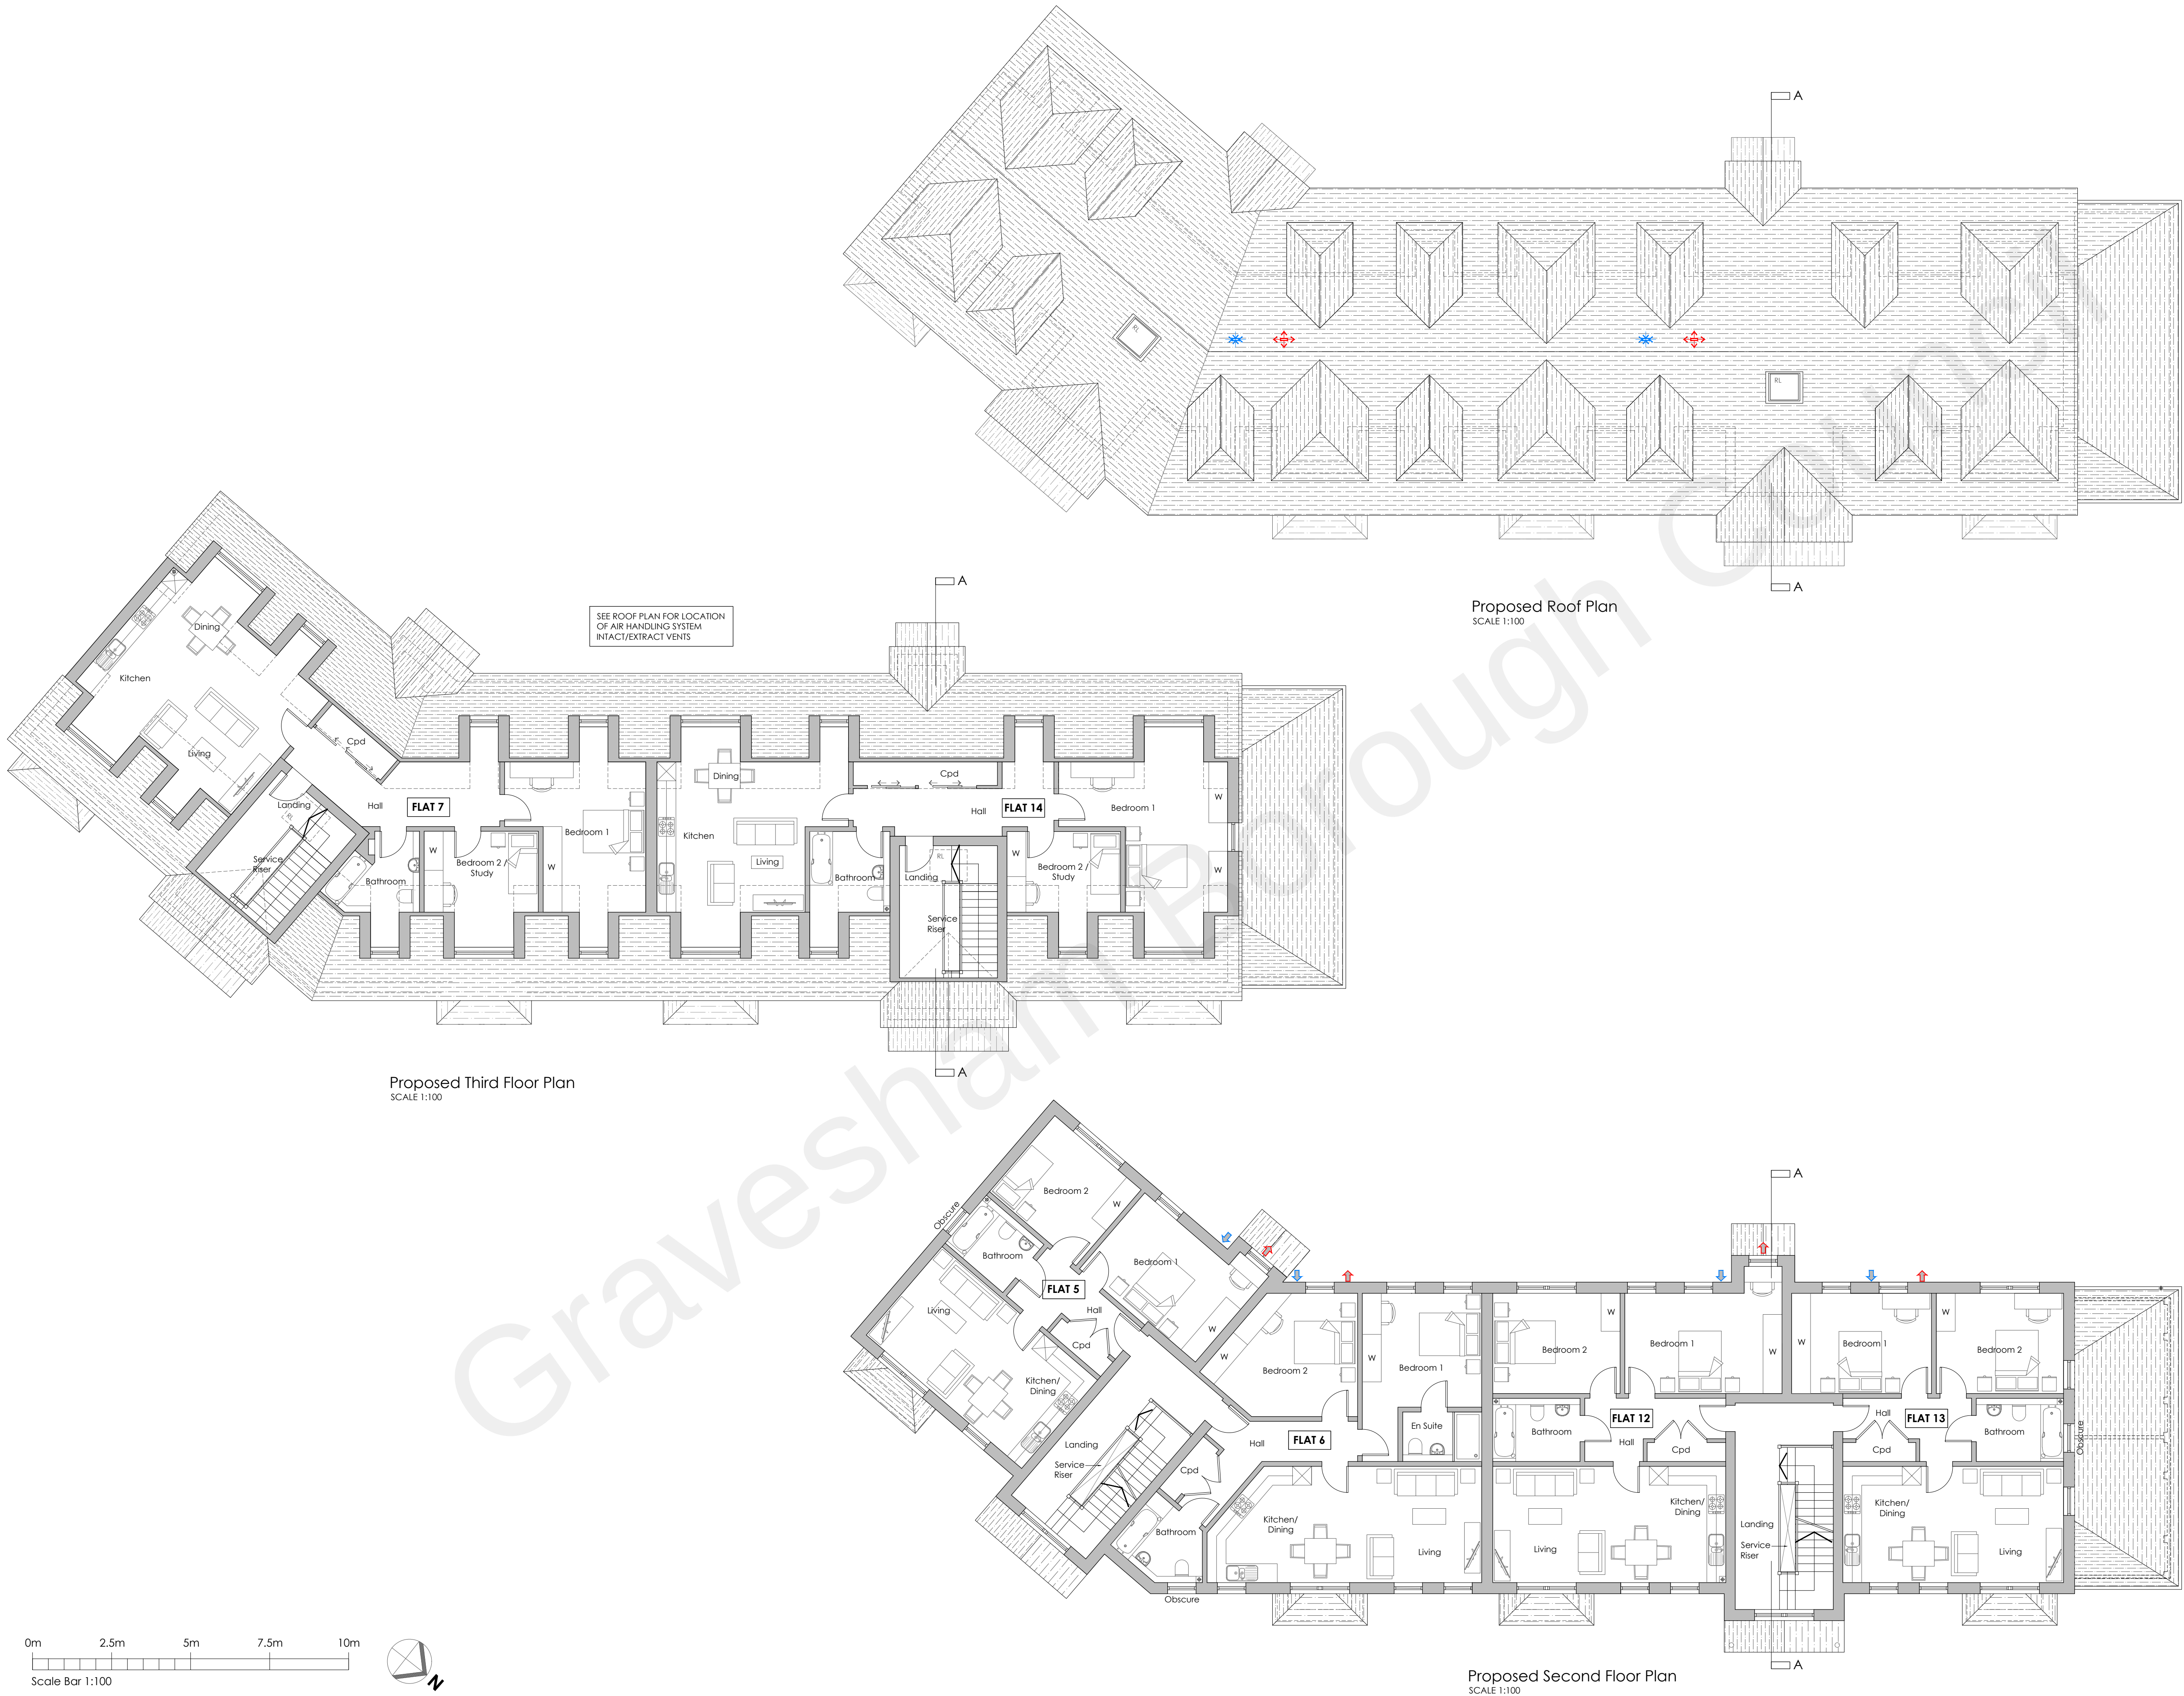

✱ ↓ AIR HANDLING SYSTEM FAN INTAKE GRILLE
↕ ↑ AIR HANDLING SYSTEM FAN EXTRACT GRILLE

READ IN CONJUNCTION WITH INDIVIDUAL APARTMENT PLANS BY ZEHNDER
SHOWING PROPOSED AIR HANDLING UNIT LOCATIONS AND DUCTWORK
ROUTING.

PROPOSED AIR HANDLING UNITS FOR UNITS 1, 2, 3, 4, 5, 6, 8, 9, 10, 11, 12 & 13
= CEILING MOUNTED **CA155CM-G8 (RH) MVHR**

PROPOSED AIR HANDLING UNITS FOR UNITS 7 & 14
= WALL MOUNTED **CA155WM-G8 MVHR**

ALL UNITS HAVE **CA125600 ATTENUATORS** FITTED TO SUPPLY
AND EXTRACT DUCTS.

Rev	Date	Comments
-----	------	----------

PLANNING

Client
BRT Properties Kent Ltd

Project

2 Vale Road,
Northfleet,
Gravesend,
Kent,
DA11 8BZ

Title

Proposed 2nd & 3rd Floor Plans
and Roof Plan

Project No.

7985

Date

DEC 2021

Drawing No.

7985-PD-03

Revision

Scale

AS SHOWN @A1

Drawn

MN

Check

RR

Nepiclar House, London Road
Wrotham Heath, TN15 7RS
phone: 01732 753333
fax: 01732 753334
info@offsetarchitects.co.uk
www.offsetarchitects.co.uk

