
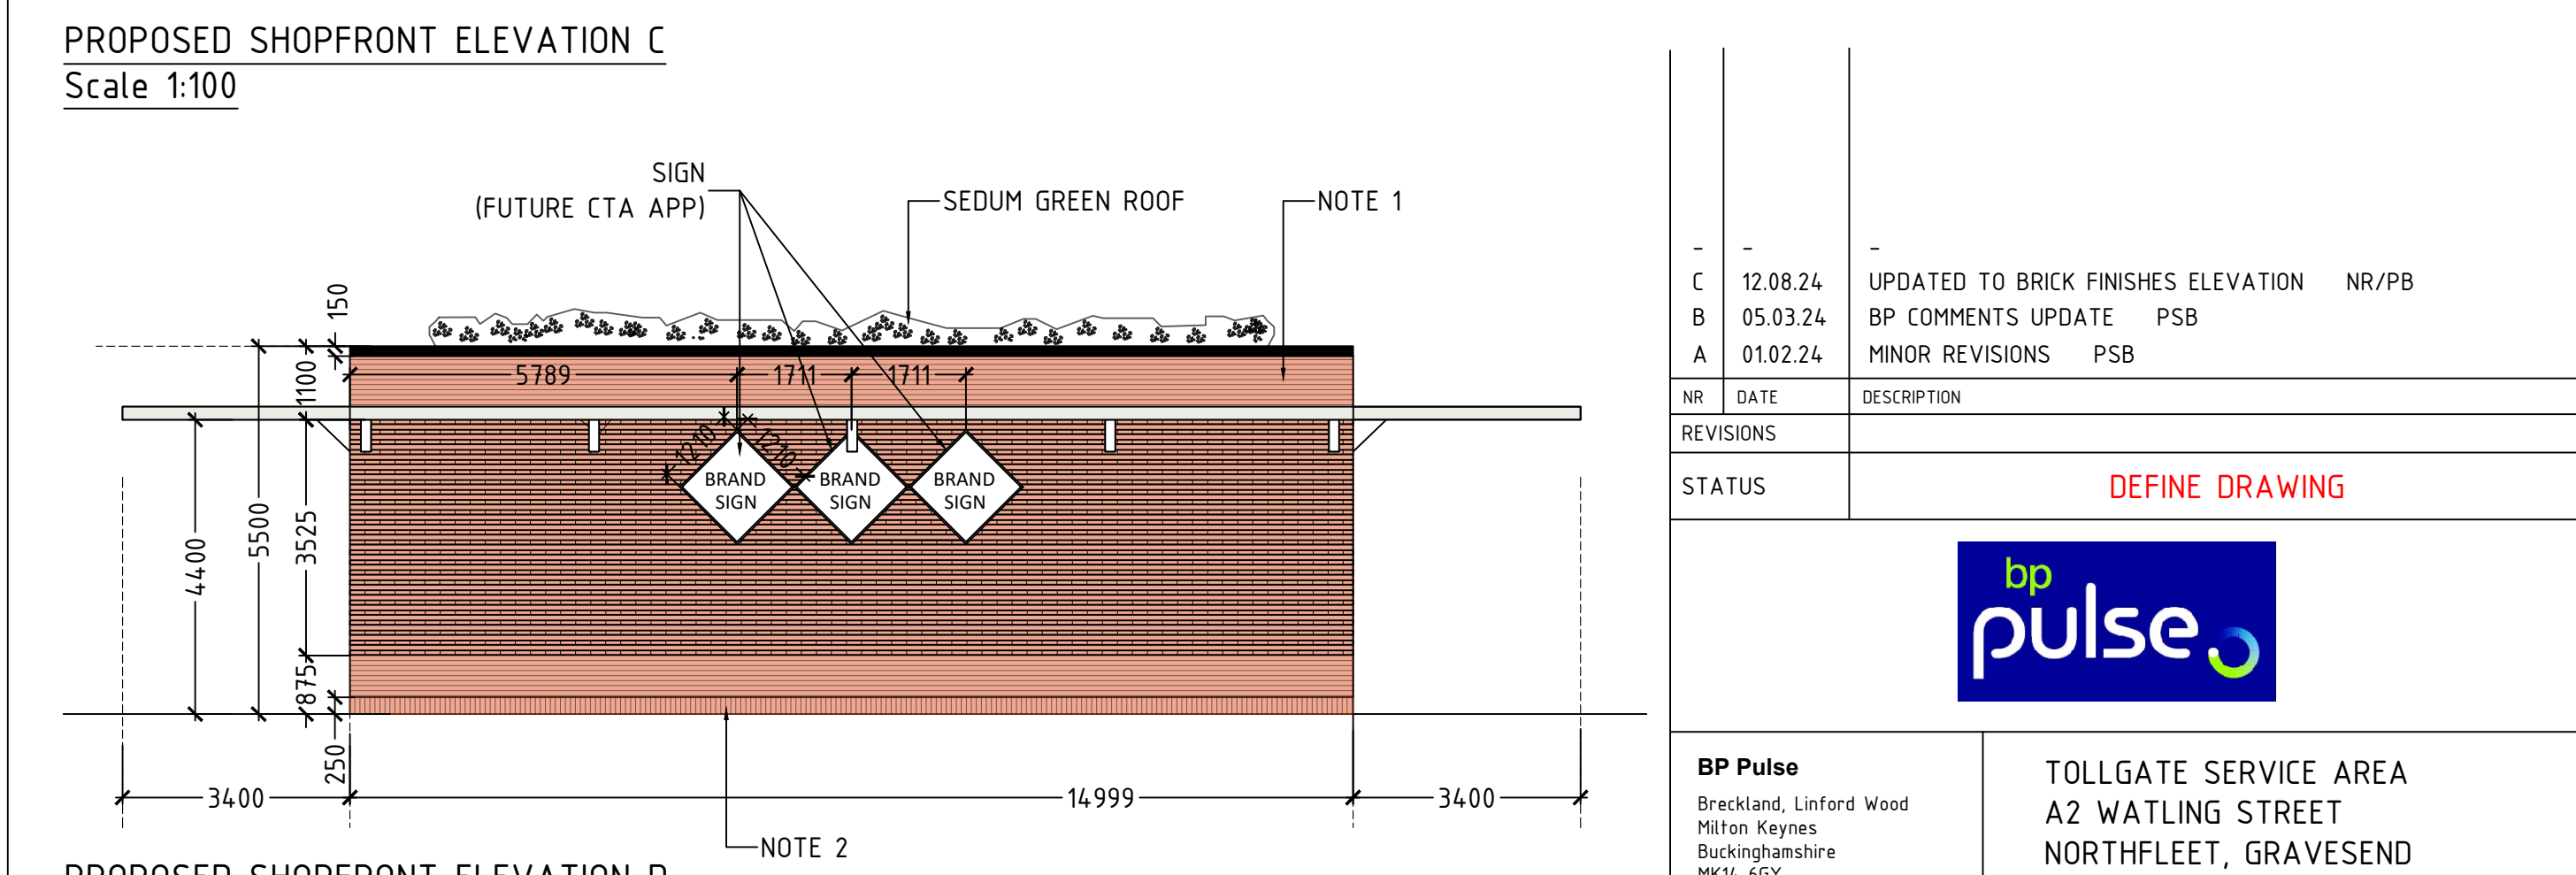
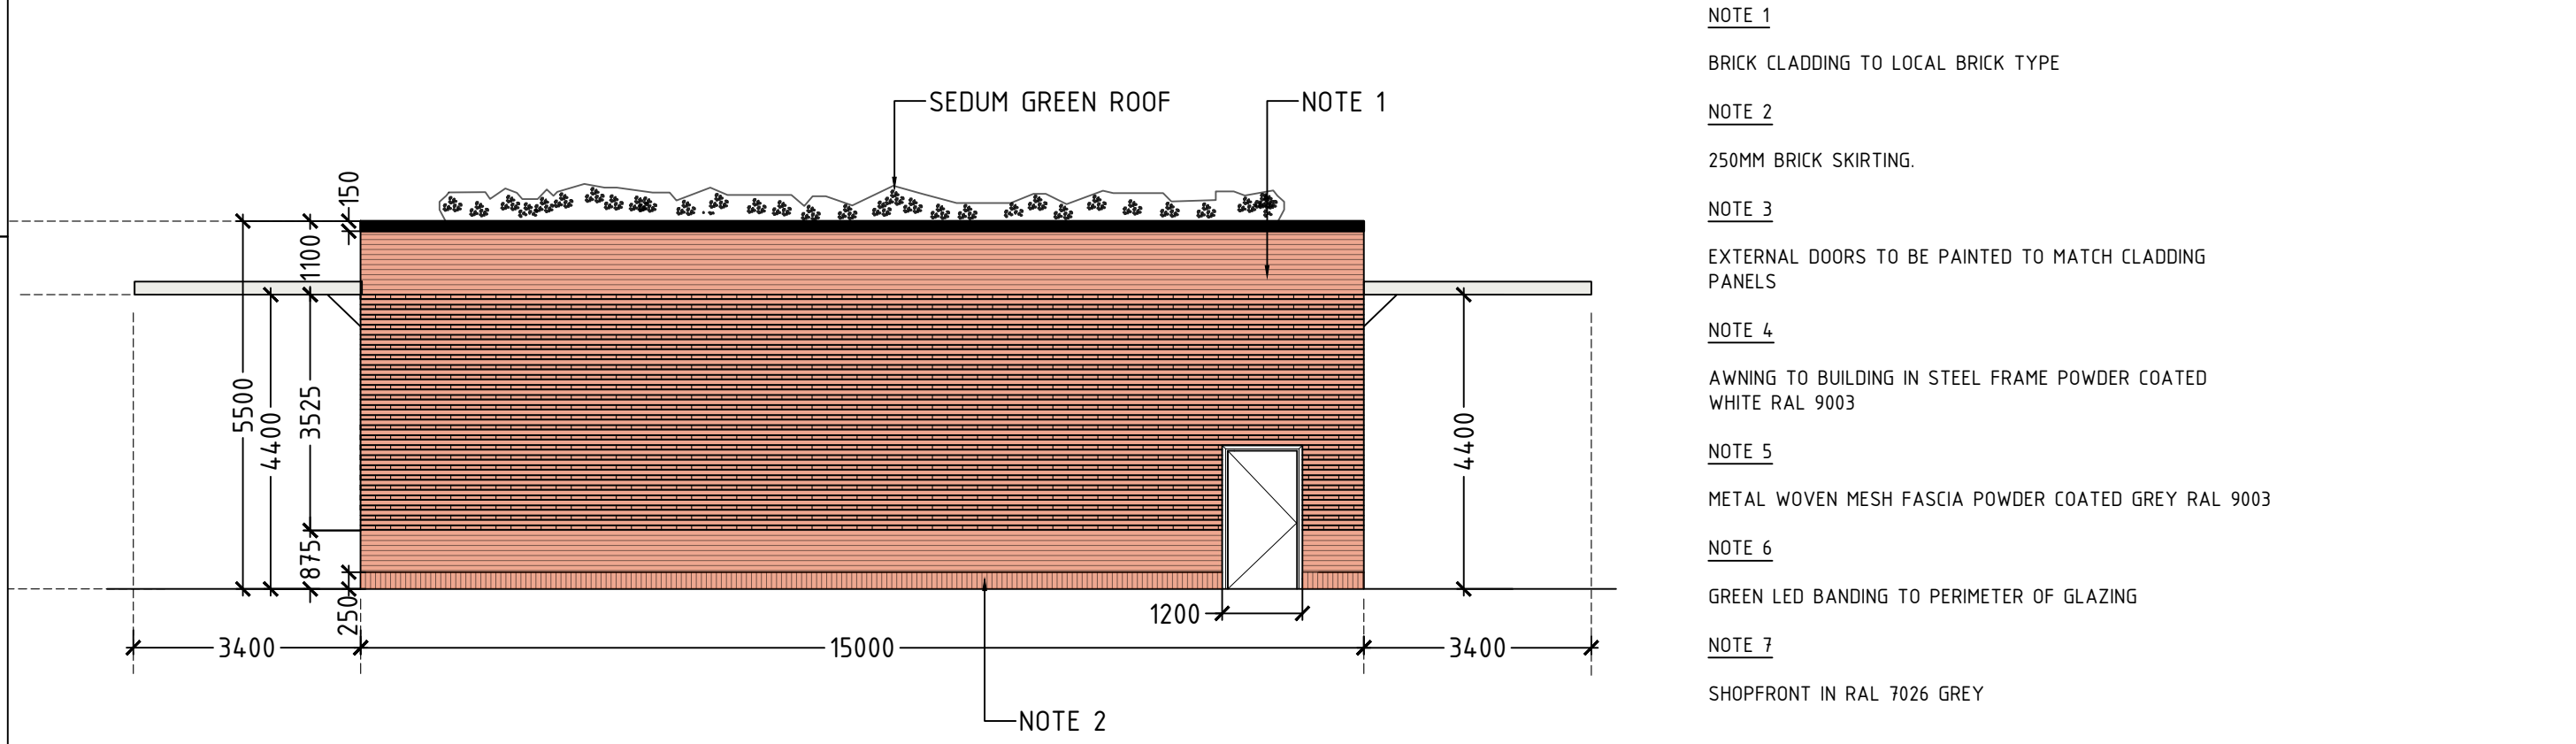
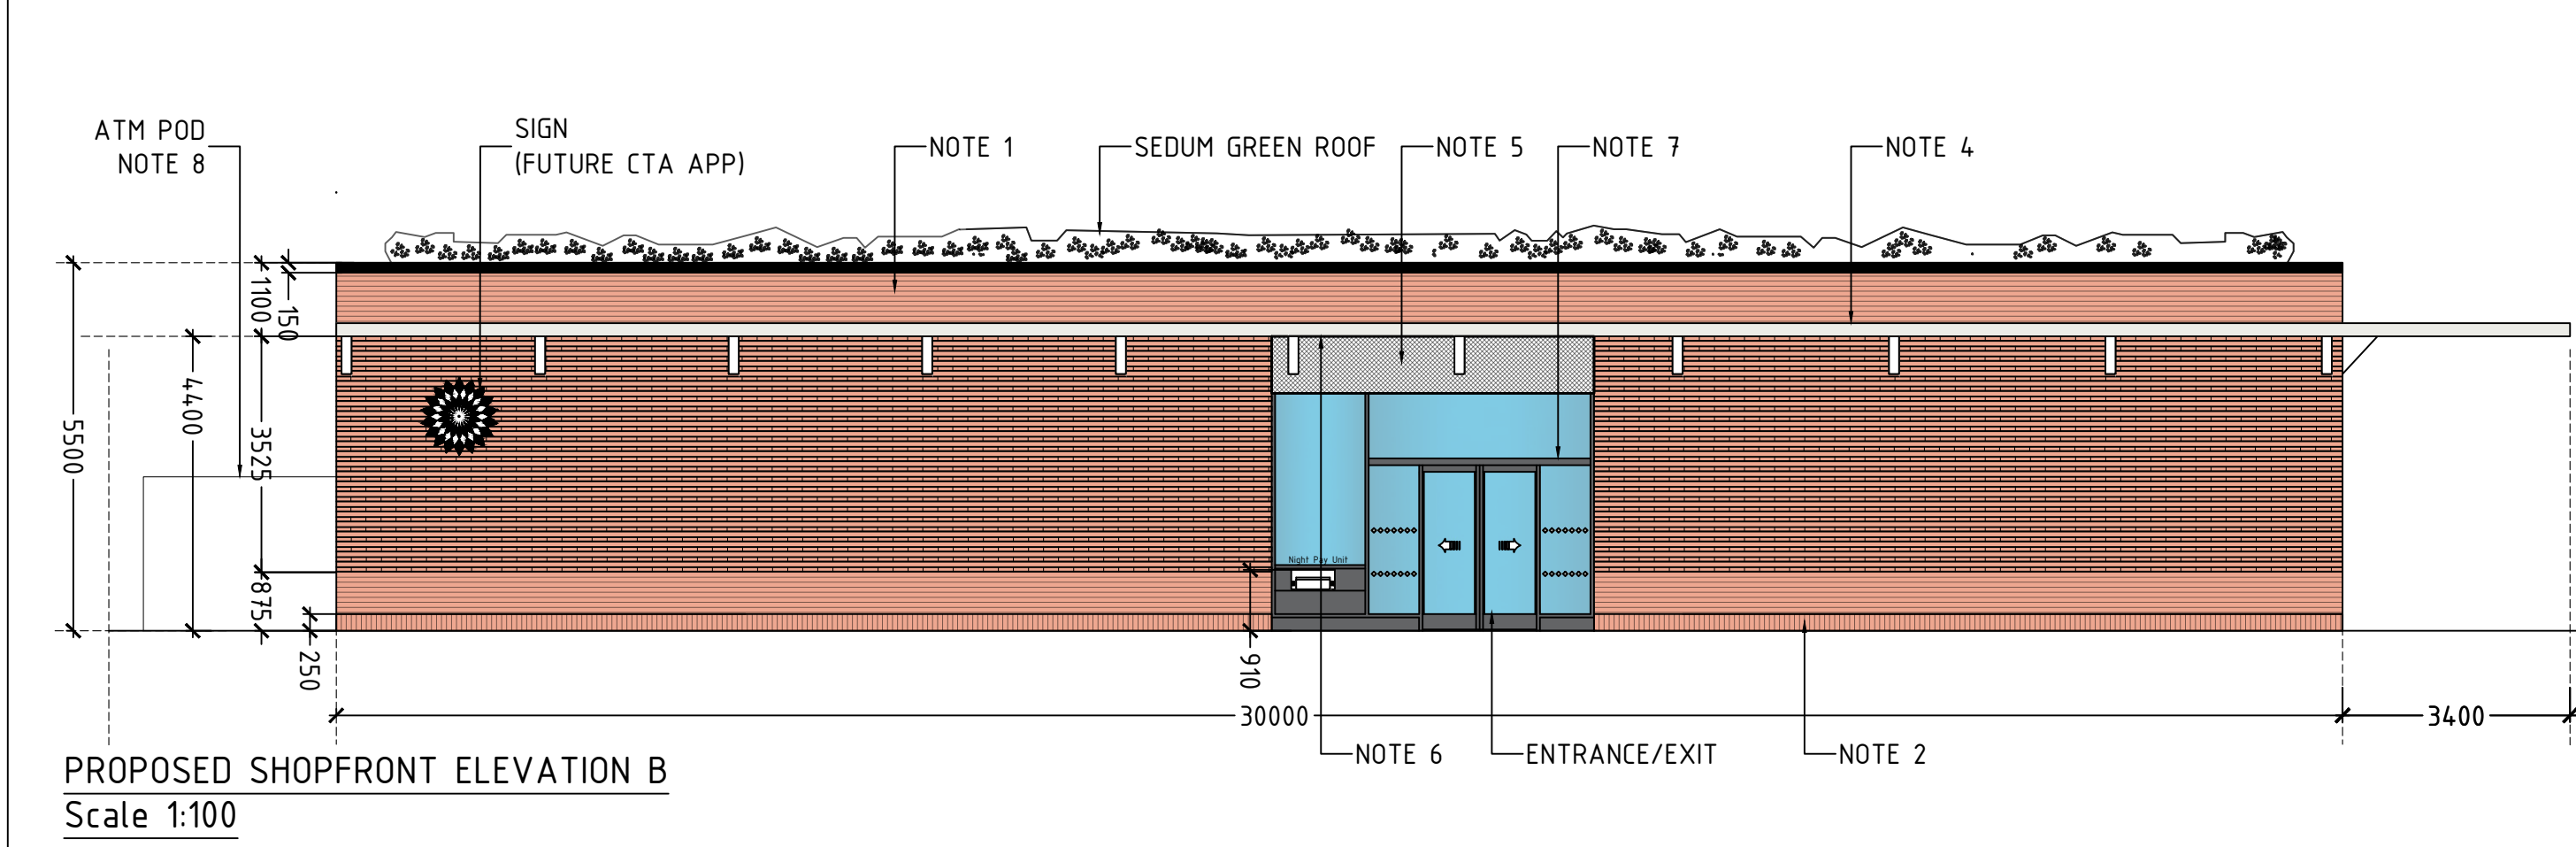
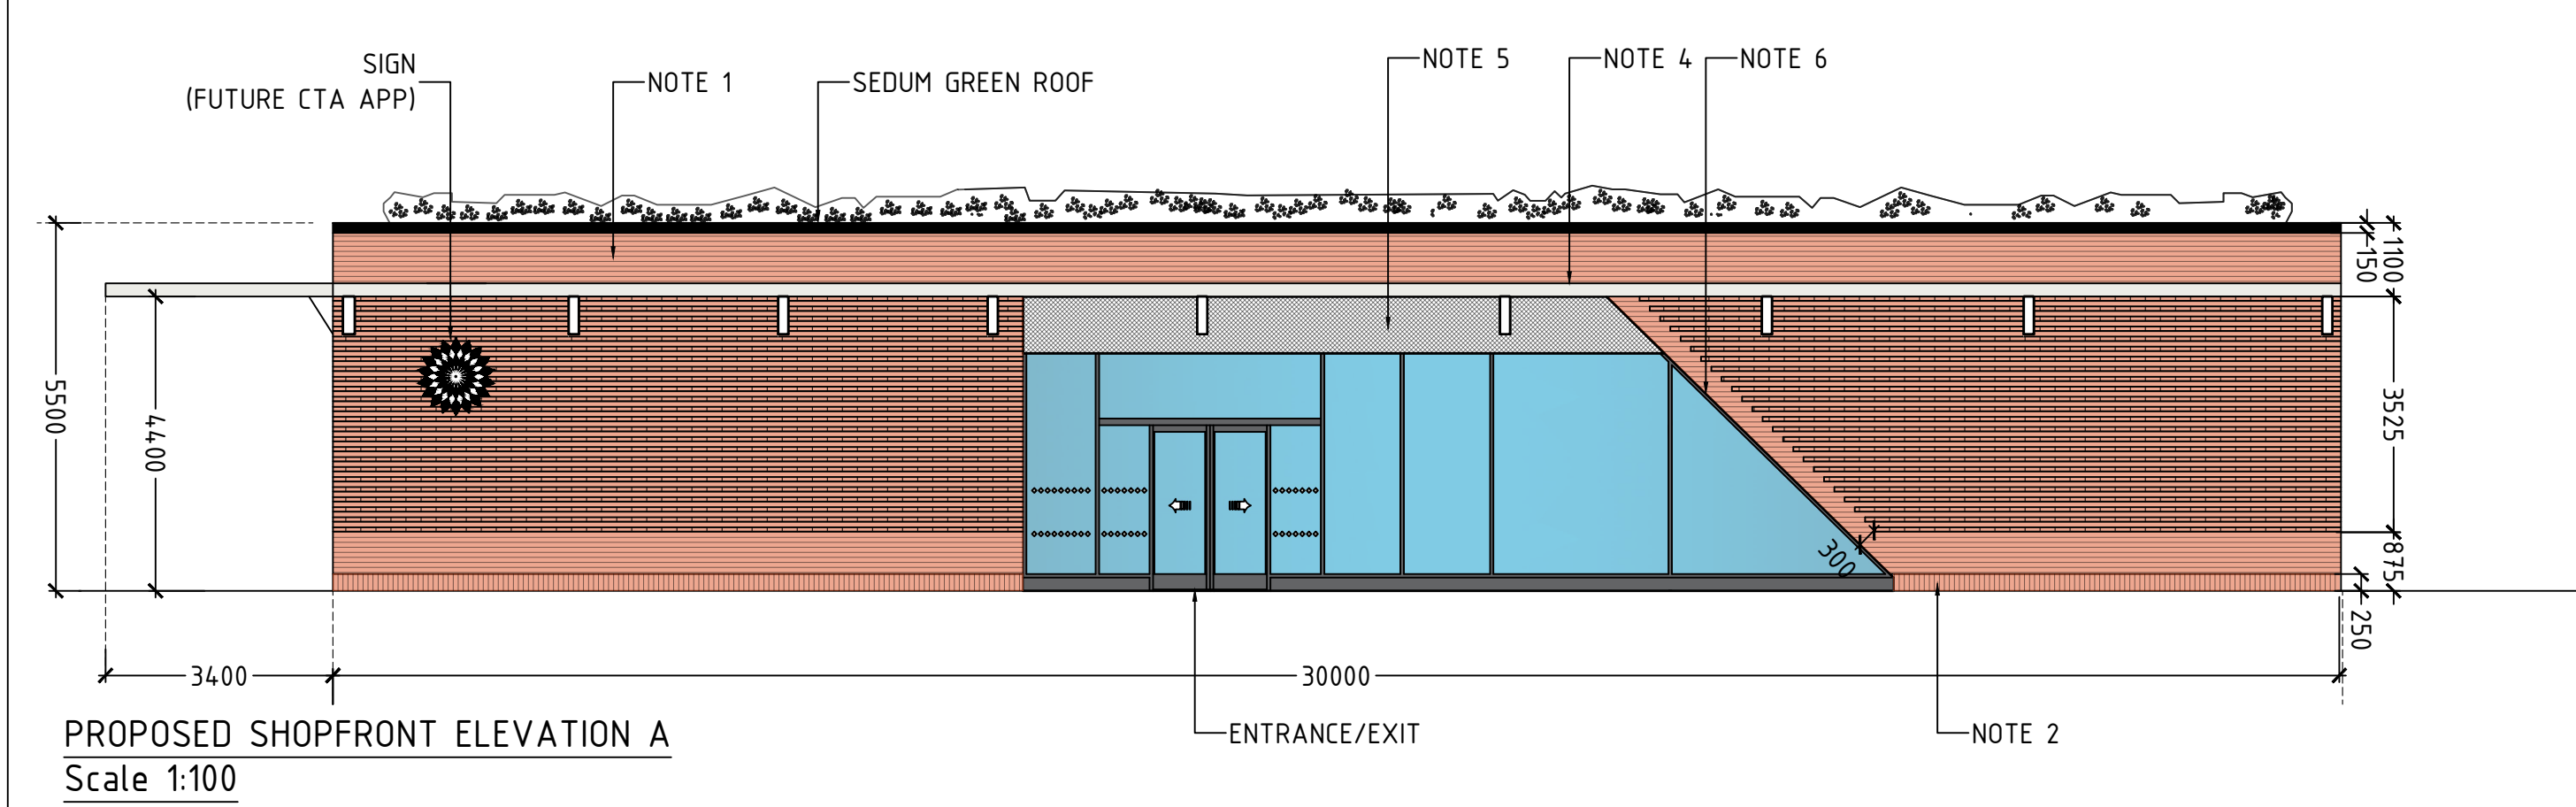
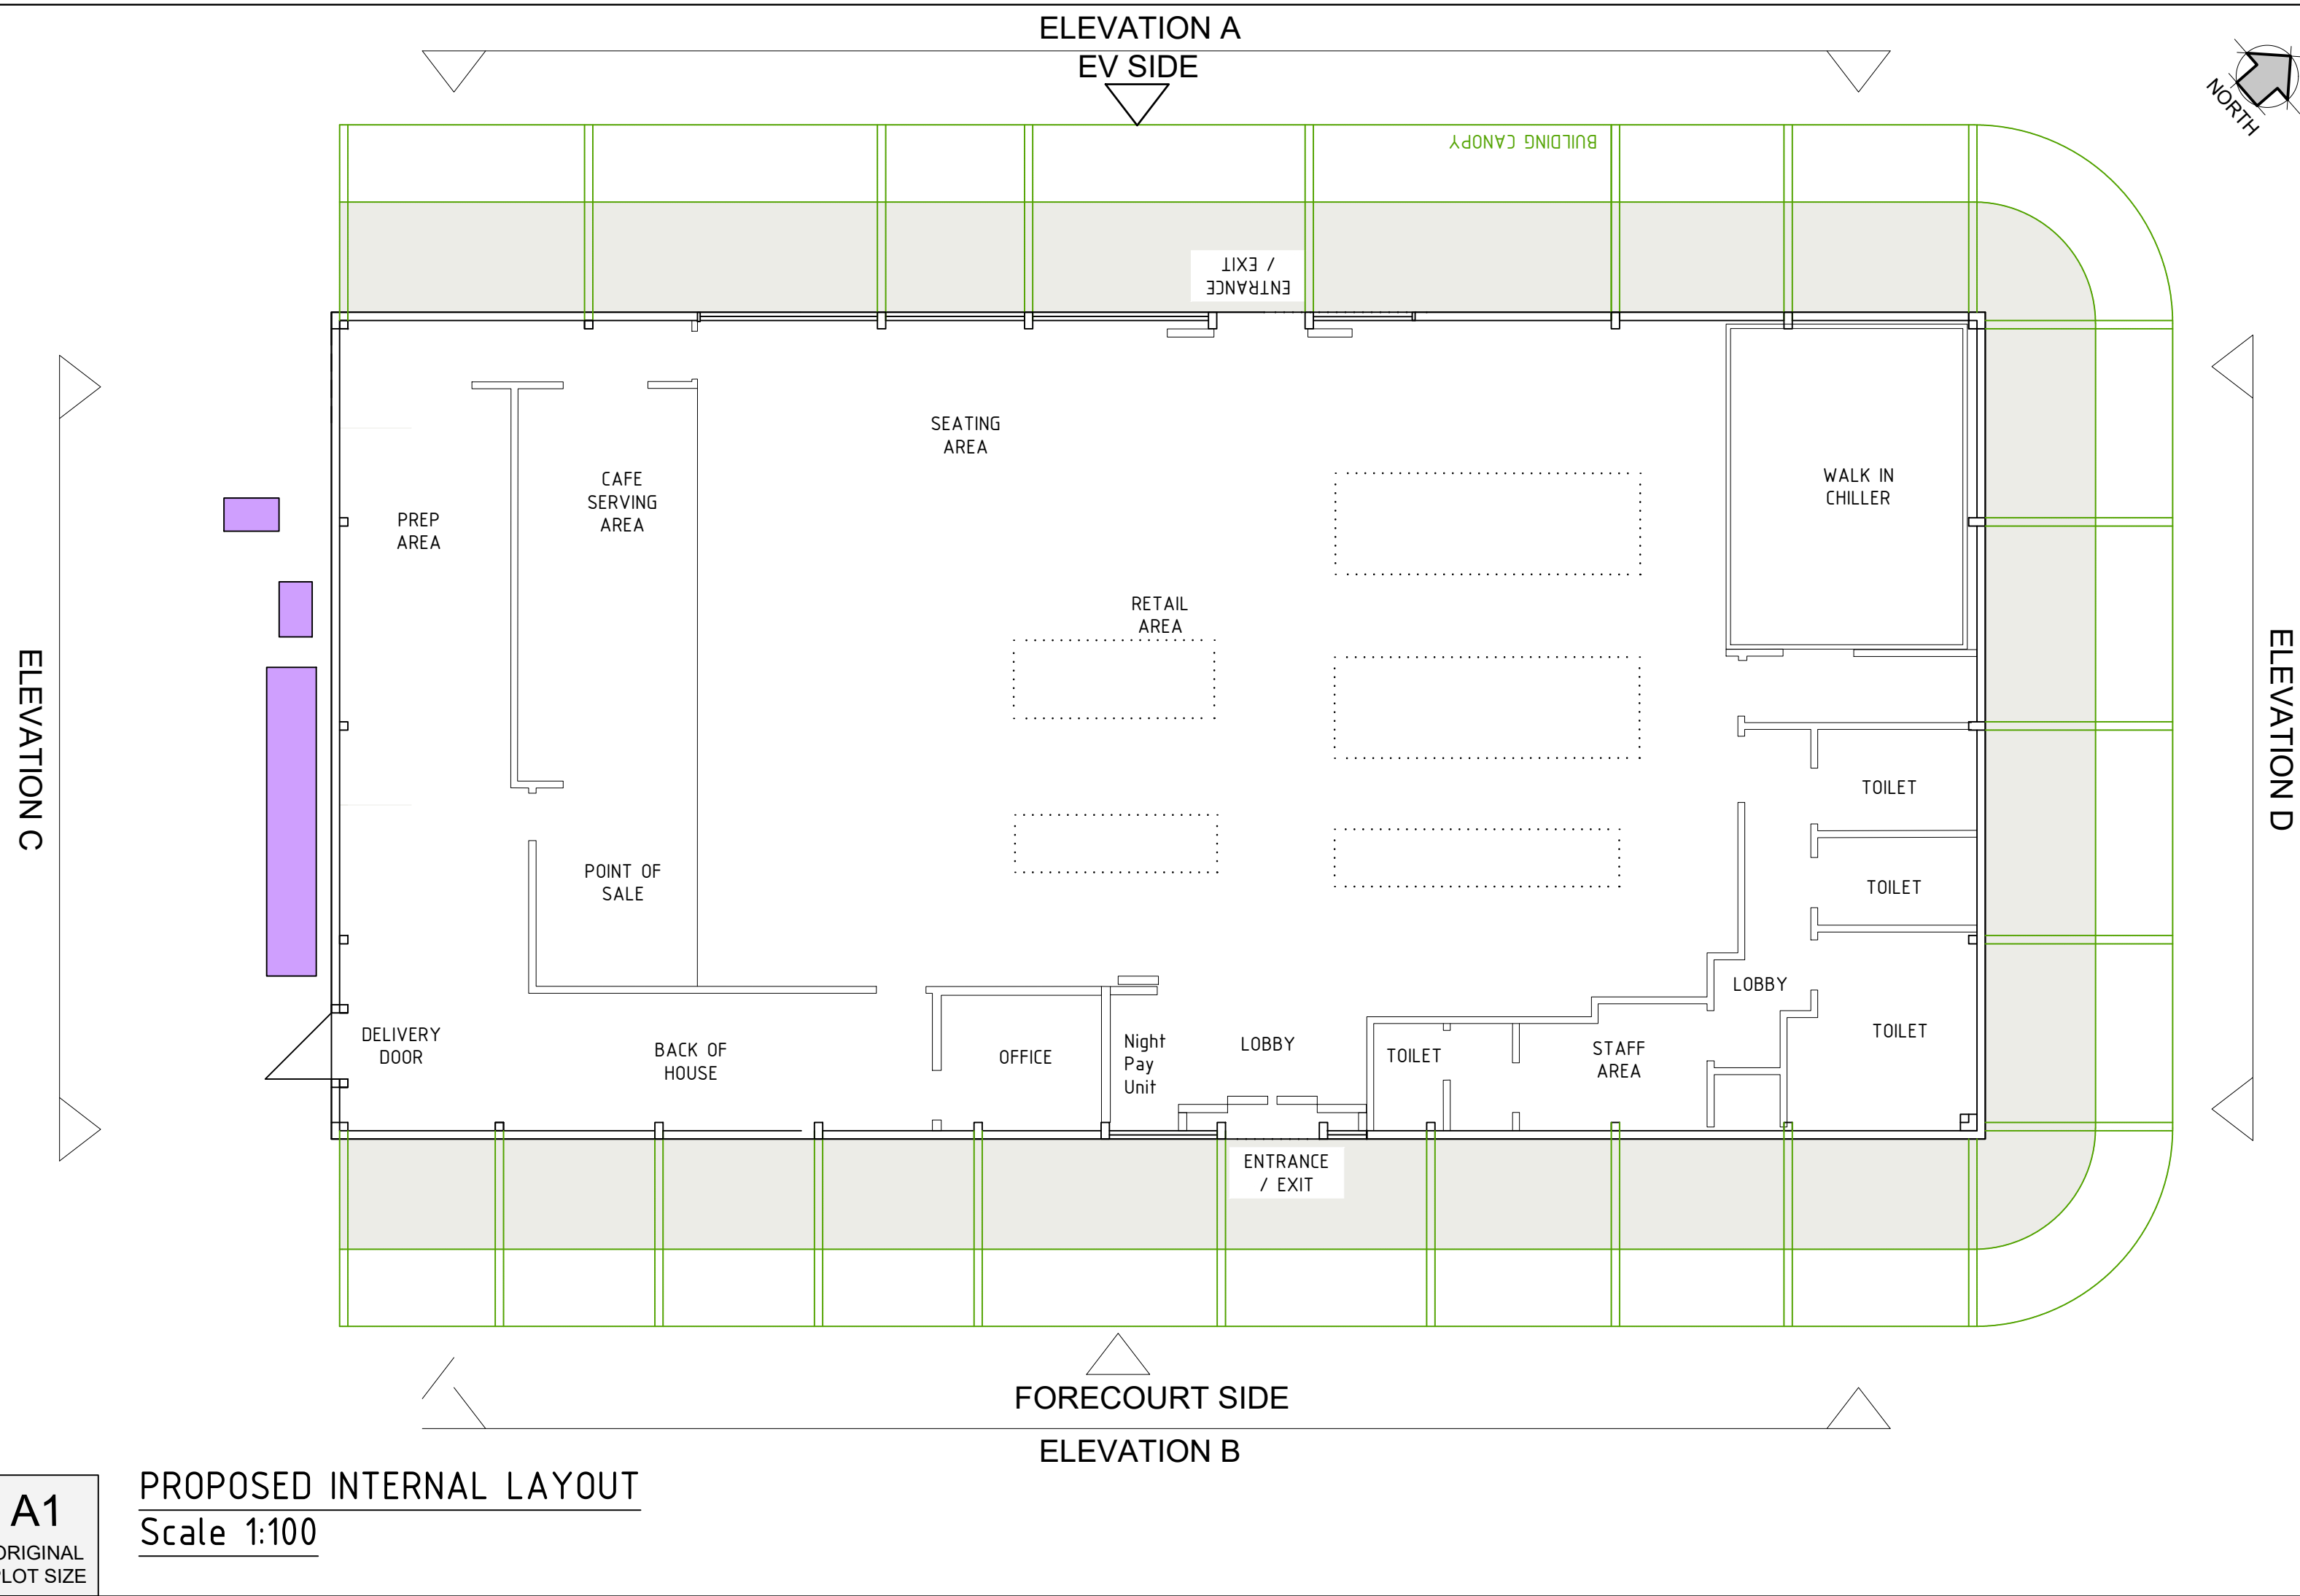


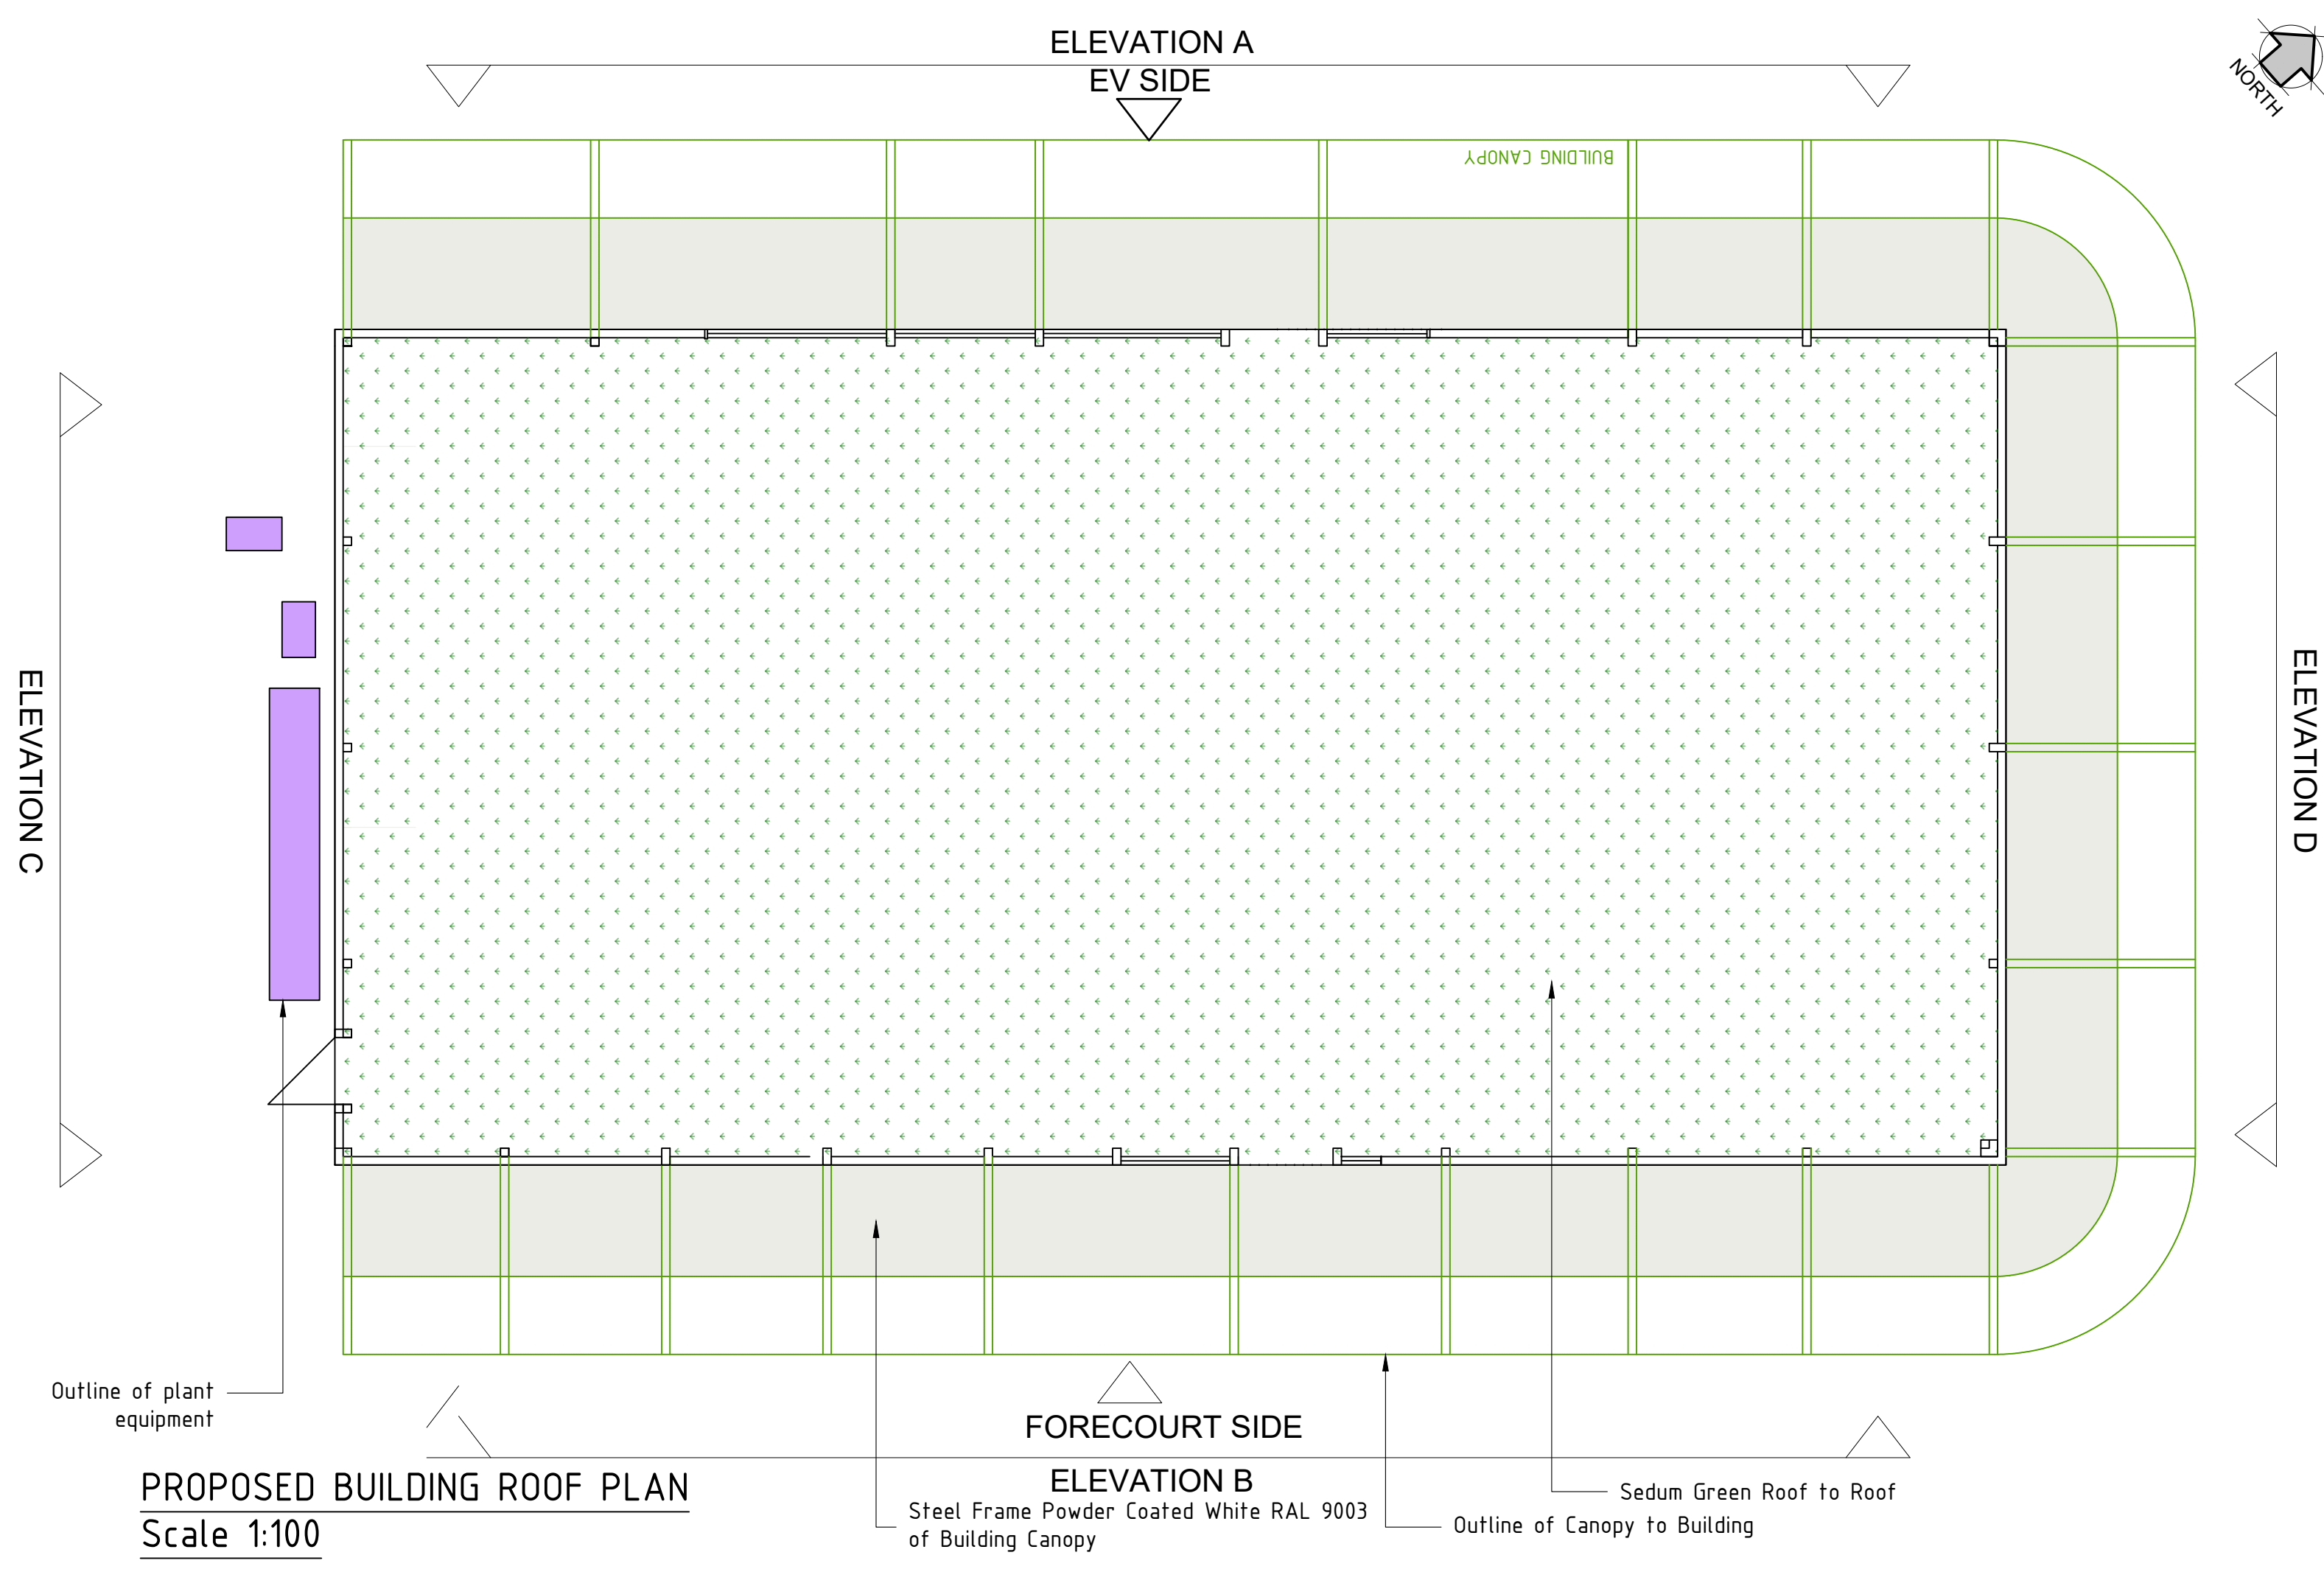

PROPOSED SHOPFRONT ELEVATION D
Scale 1:100

GENERAL NOTES

This drawing has been prepared for the sole purpose of obtaining planning permission for a Electric Vehicle Charging Installation & Petrol Filling Station

This drawing is to be read in conjunction with drawings

EV005-PS-LAY-000-GB00015044-0001-001 Site Location Plan
EV005-PS-LAY-000-GB00015044-0003-001 Existing Site Layout
EV005-PS-LAY-000-GB00015044-0003-002 Existing Site Layout 1-500 Scale Plan
EV005-PS-LAY-000-GB00015044-0005-001 Proposed Site Layout
EV005-PS-LAY-000-GB00015044-0005-002 Proposed Site Layout 1-500 Scale Plan
EV005-PS-LAY-000-GB00015044-0007-001 Surfacing Site Layout
EV005-PS-LAY-000-GB00015044-0004-001 Proposed Site Elevations
EV005-PS-GAS-000-GB00015044-0001-001 Proposed Building Details
EV005-PS-GAS-000-GB00015044-0002-001 Equipment Details Sheet
EV005-PS-LAY-000-GB00015044-0009-001 Vehicle Tracking NGV
EV005-PS-LAY-000-GB00015044-0010-001 Vehicle Tracking Cars

Any advertisements are indicative and are subject to a separate advertisement application.

BP Pulse
Breckland, Linford Wood
Milton Keynes
Buckinghamshire
MK14 6GY

TOLLGATE SERVICE AREA
A2 WATLING STREET
NORTHFLEET, GRAVESEND
KENT DA11 7NP

PROPOSED BUILDING DETAILS

DRAWN:	PB	
DATE:	JAN 24	
DESIGN CHECKED:	-	
DATE:	-	
APPROVED:	-	
DATE:	-	
DATE:	-	
SCALE:	1:200@A1	

SCALED DIMENSIONS SHOULD NOT BE TAKEN FROM THIS DRAWING (APPROPRIATE FOR A1 ONLY)

ARCHITECT: MBH

BP DRAWING NUMBER: EV005-PS-GAS-000-GB00015044-0001-001
REV: B01

MBH DRAWING NUMBER: 14170-24
REV: C

This drawing has been produced in accordance with BP Chargemaster design standards & current legal requirements. Copyright of BP Chargemaster. Illegal use is prohibited. Reproduction only with permission of BP Chargemaster