


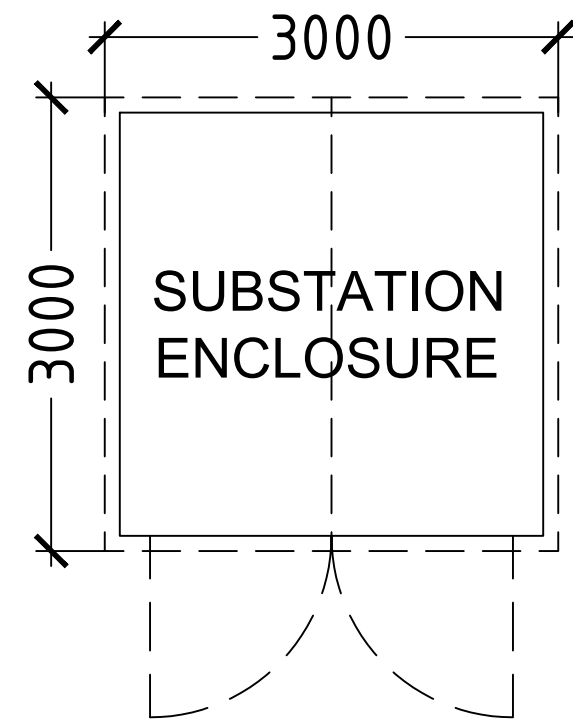
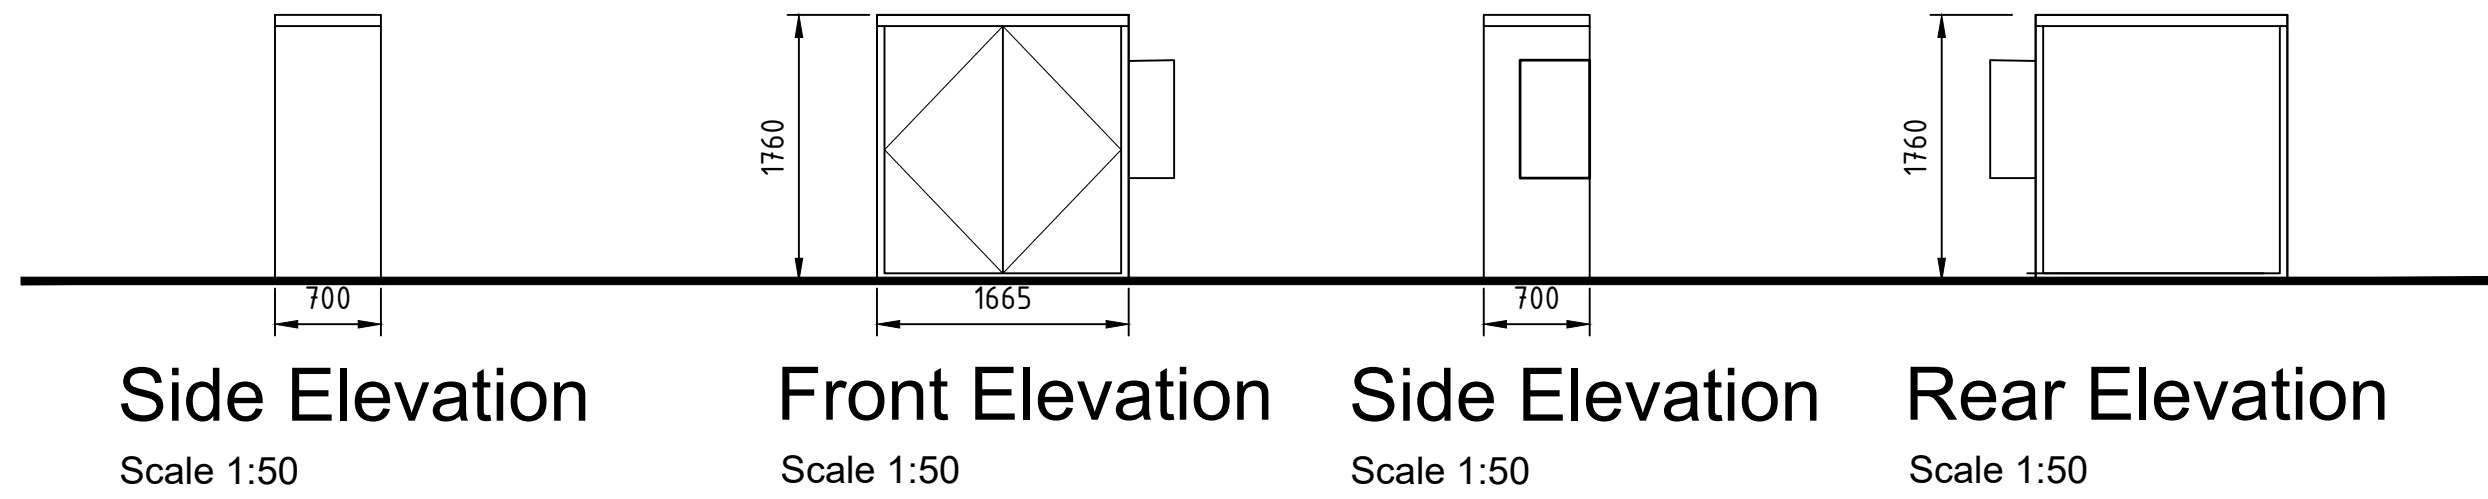
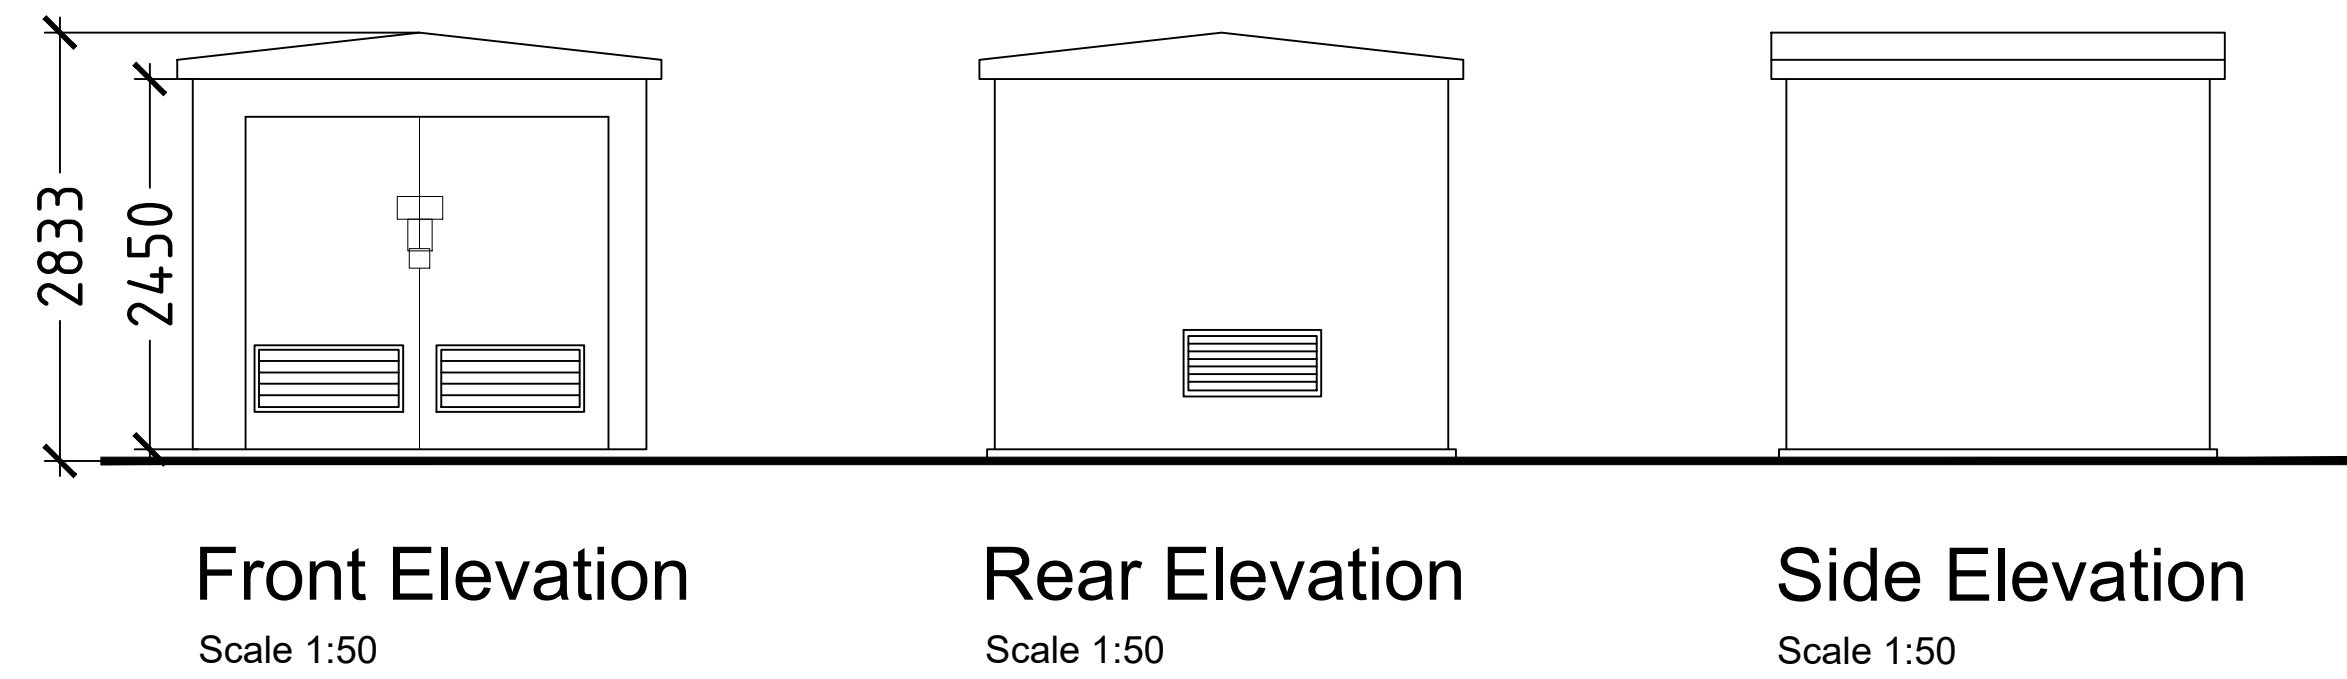
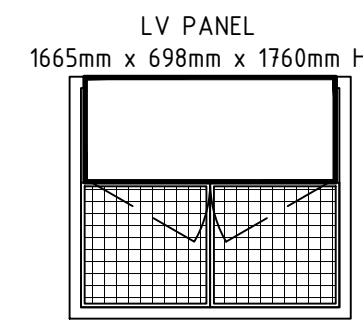


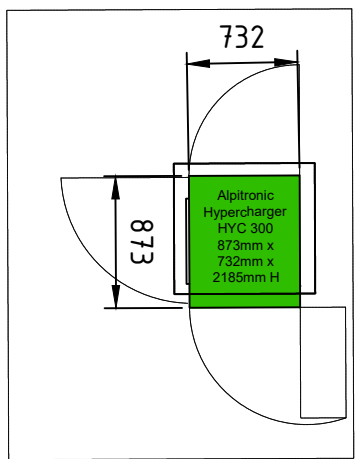


GRP Substation Floor Plan
Scale 1:50

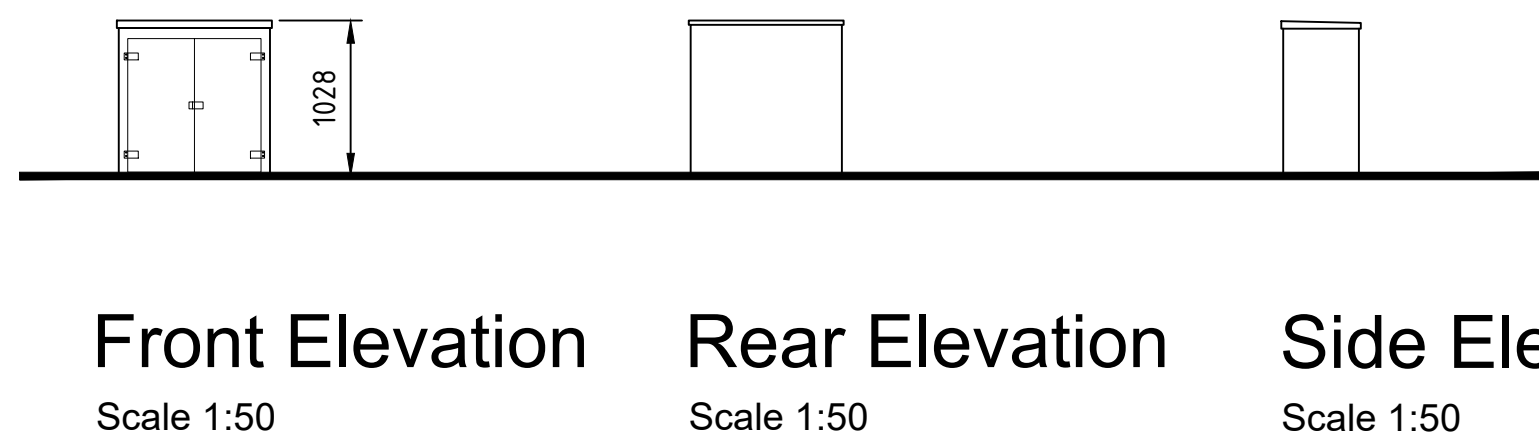


Low Voltage Schneider
Panel
Floor Plan
Scale 1:50

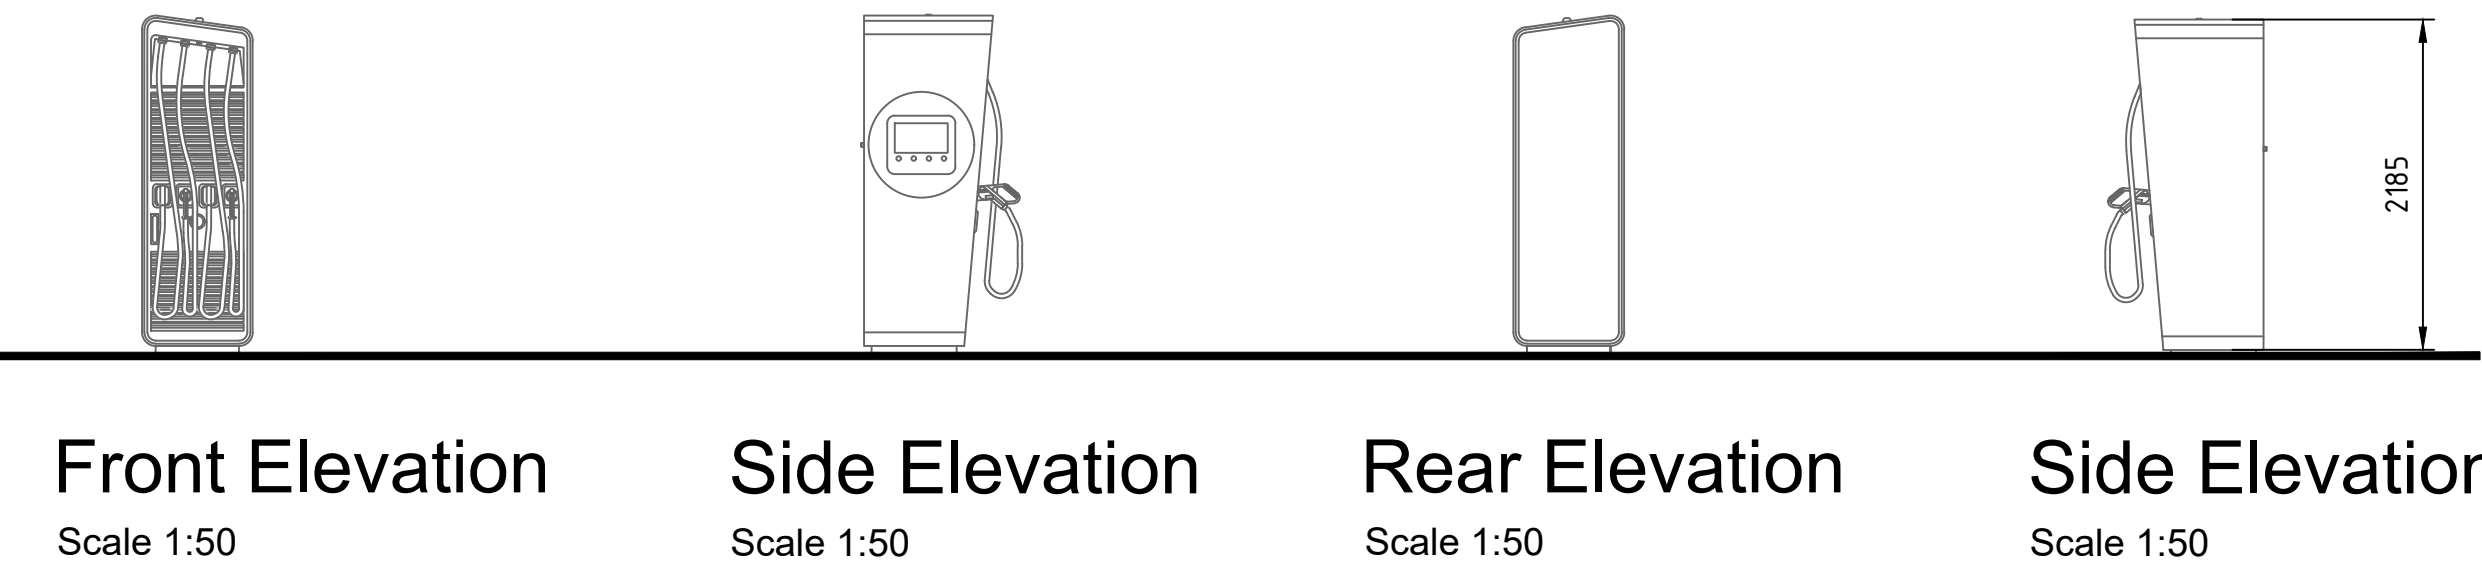


Alpitronic HYC 400 POWER CABINET &
CHARGER Floor Plan
Scale 1:50

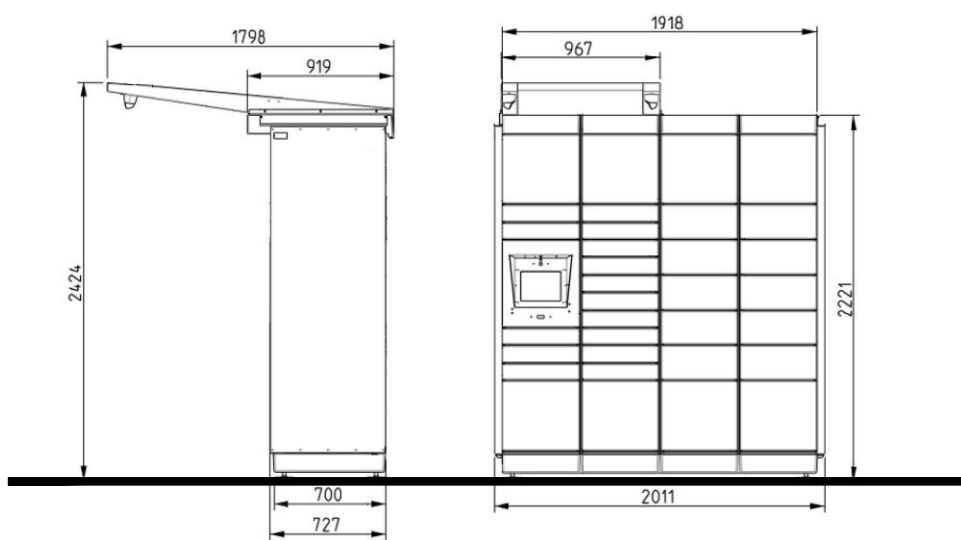


Side Elevation Front Elevation
Scale 1:50 Scale 1:50

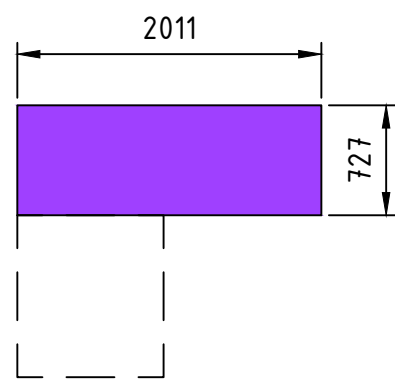


Parcel Collection Locker
Floor Plan
Scale 1:50

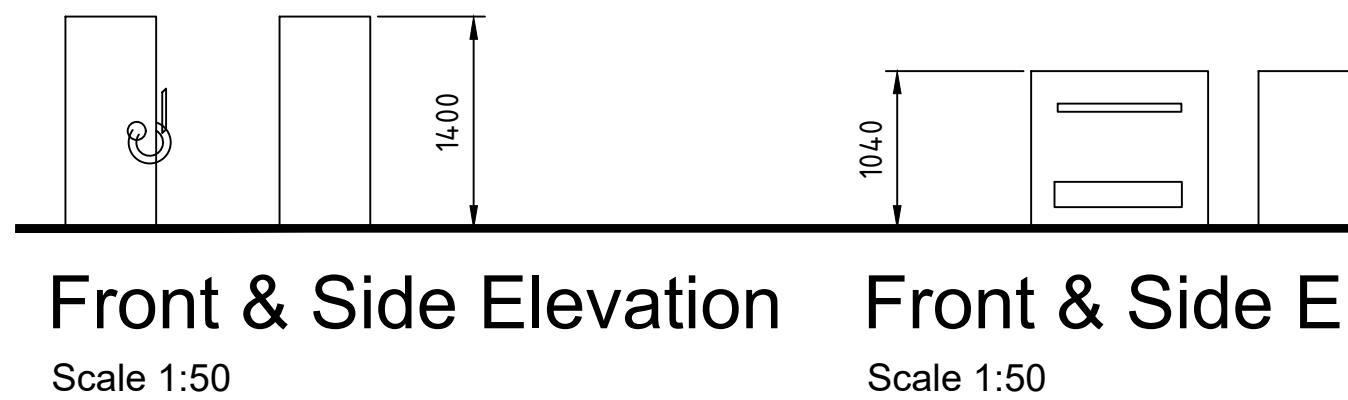


Front & Side Elevation
Scale 1:50

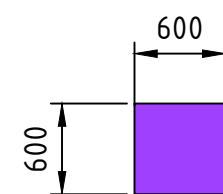


VAC Machine
Floor Plan
Scale 1:50

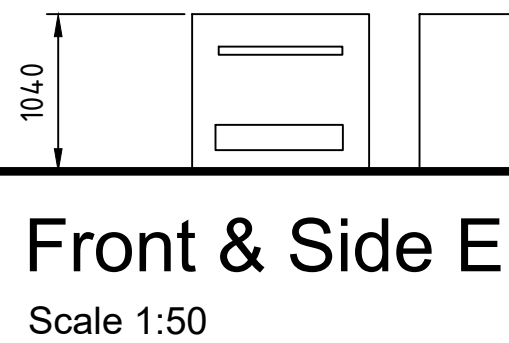


Front & Side Elevation
Scale 1:50

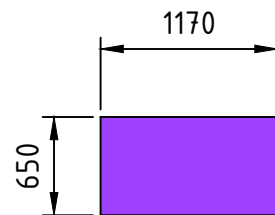


Mat Cleaner
Machine
Scale 1:50

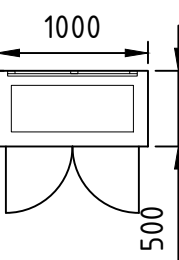


Electric Meter Cabinet
Floor Plan
Scale 1:50

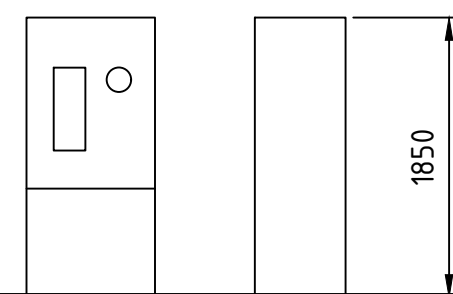


Front & Side Elevation
Scale 1:50

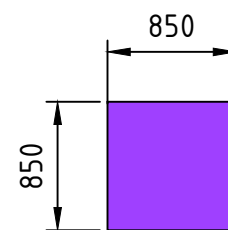


Deposit Return
Machine (DRS)
Scale 1:50

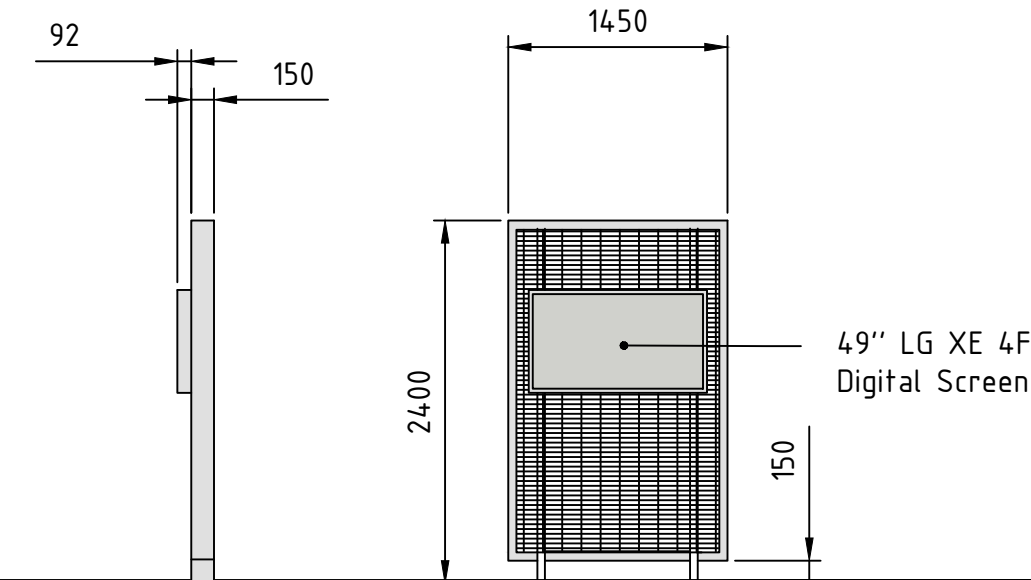

Front & Side Elevation
Scale 1:50

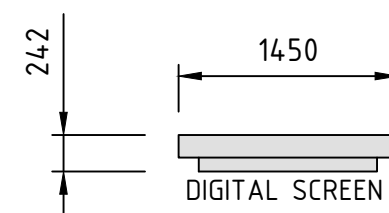

Digital Screen
Scale 1:50

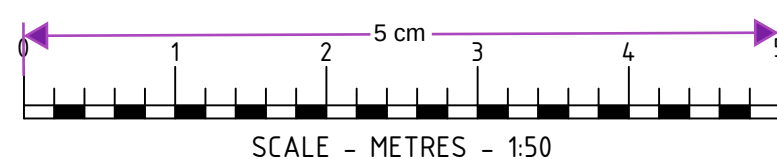

GENERAL NOTES

This drawing has been prepared for the sole purpose of obtaining planning permission for a Electric Vehicle Charging Installation & Petrol Filling Station

This drawing is to be read in conjunction with drawings

EV005-PS-LAY-000-GB00015044-0001-001 Site Location Plan
EV005-PS-LAY-000-GB00015044-0003-001 Existing Site Layout
EV005-PS-LAY-000-GB00015044-0003-002 Existing Site Layout 1-500 Scale Plan
EV005-PS-LAY-000-GB00015044-0005-001 Proposed Site Layout
EV005-PS-LAY-000-GB00015044-0005-002 Proposed Site Layout 1-500 Scale Plan
EV005-PS-LAY-000-GB00015044-0007-001 Surfacing Site Layout
EV005-PS-LAY-000-GB00015044-0004-001 Proposed Site Elevations
EV005-PS-GAS-000-GB00015044-0001-001 Proposed Building Details
EV005-PS-GAS-000-GB00015044-0002-001 Equipment Details Sheet
EV005-PS-LAY-000-GB00015044-0009-001 Vehicle Tracking HGV
EV005-PS-LAY-000-GB00015044-0010-001 Vehicle Tracking Cars

Any advertisements are indicative and are subject to a separate advertisement application.

NR	DATE	DESCRIPTION
A	05.03.24	BP COMMENTS ADDED PSB
REVISIONS		
STATUS		
DEFINE DRAWING		
bp pulse		
BP Pulse Breckland, Linford Wood Milton Keynes Buckinghamshire MK14 6GY		
TOLLGATE SERVICE AREA A2 WATLING STREET NORTHFLEET, GRAVESEND KENT DA11 7NP		
EQUIPMENT DETAILS SHEET		
BP DRAWING NUMBER		
REV		
EV005-PS-GAS-000-GB00015044-0002-001		
B01		
MBH DRAWING NUMBER		
REV		
14170-25		
A		
ARCHITECT: MBH		
This drawing has been produced in accordance with BP Chargemaster design standards & current legal requirements. Copyright of BP Chargemaster. Illegal use is prohibited. Reproduction only with permission of BP Chargemaster		