



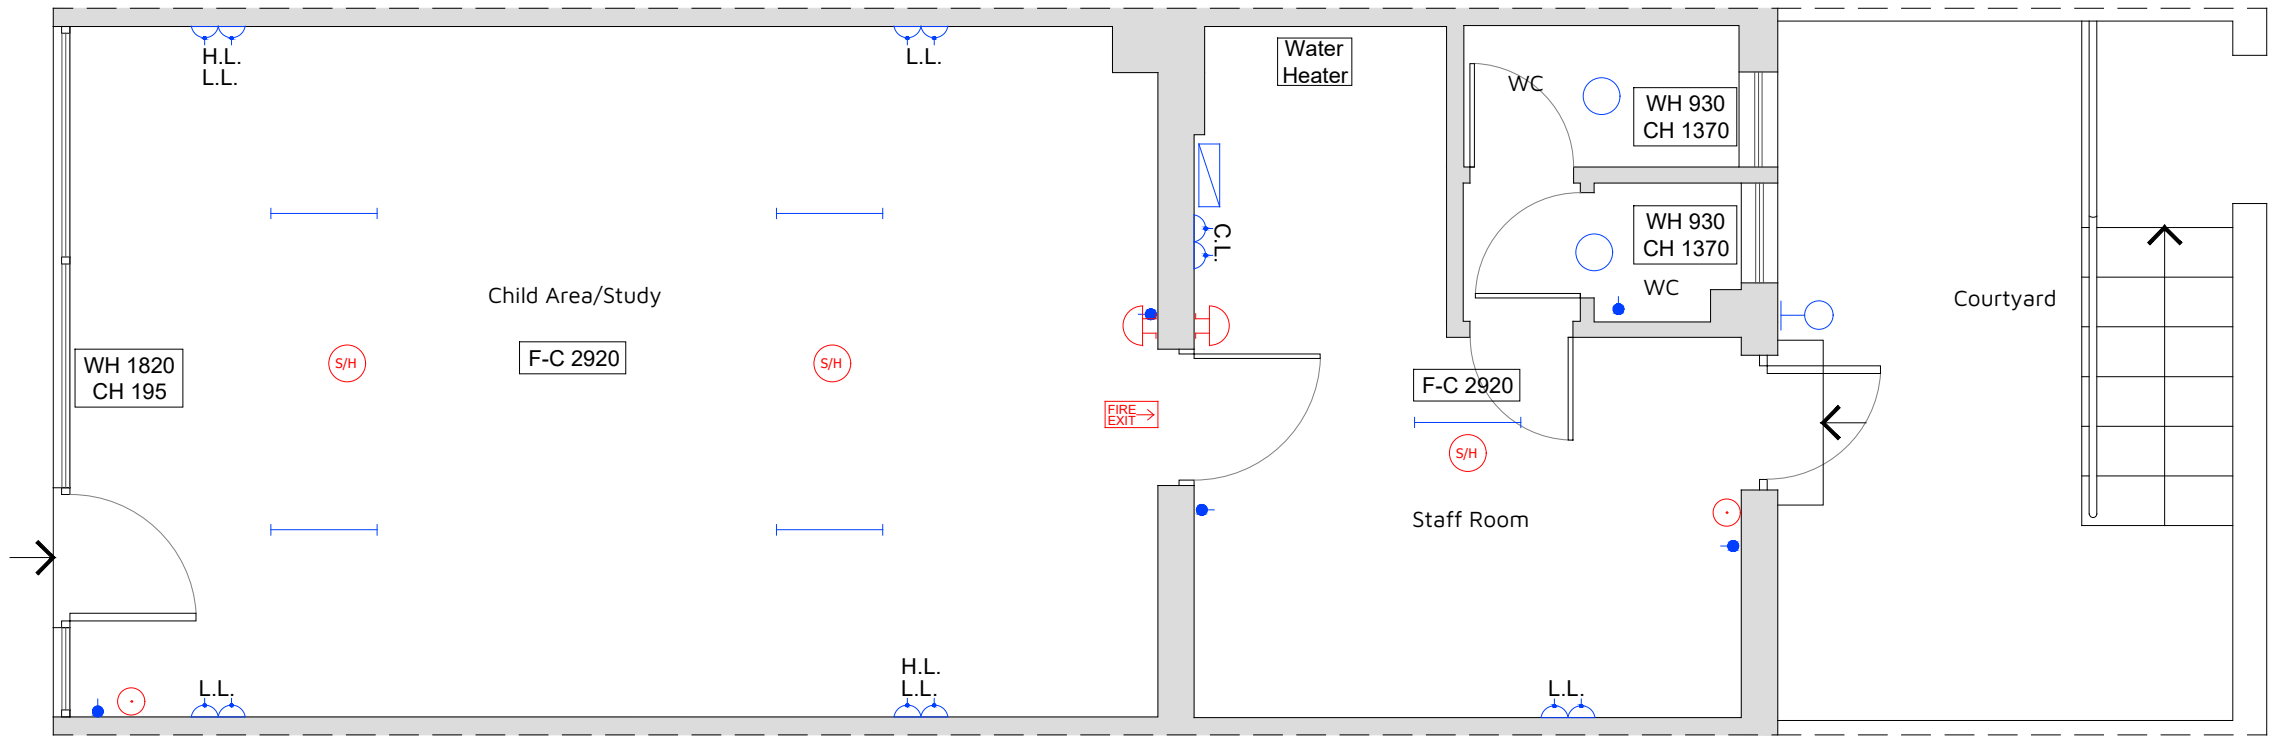

ELECTRICAL LEGEND		
	Bulkhead ceiling fitting	
	Double plug socket	C.L. = Counter Level H.H. = Half Height H.L. = High Level
	Single plug socket	
	L.L. = Low Level	
	Distribution Board	
	Single or double switch	
	Fluorescent Tube	
	Wall Light	

FIRE PRECAUTIONS LEGEND	
	Non-maintained Fire Exit sign
	Heat or smoke detector
	Fire alarm push button
	Fire alarm sounder

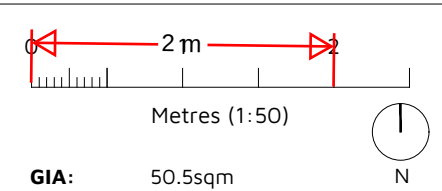

GIA: 50.5sqm

Rev: Reason: Date:

Client:
KENT COUNTY COUNCIL
Project:
13 HIVE LANE, NORTHFLEET, GRAVESEND,
KENT,DA11 9DE
Title:
EXISTING FLOOR PLAN

Drawing No: DHA/37273/03 Rev: 1:50 Scale: DEC 2025 Date:



Eclipse House, Eclipse Park. Sittingbourne Road
Maidstone, Kent. ME14 3EN

t: 01622 776226 f: 01622 776227
e: info@dhaplanning.co.uk w: www.dhaplanning.co.uk

No reproduction by any method of any part of this document
is permitted without the consent of the copyright holders.
Produced for Town and Country planning purposes only.

© Crown Copyright 2025. All rights reserved. Licence Number: 100031961

CAD Reference: DHA_37323_13 HIVE_MC01