
 


SITE LOCATION

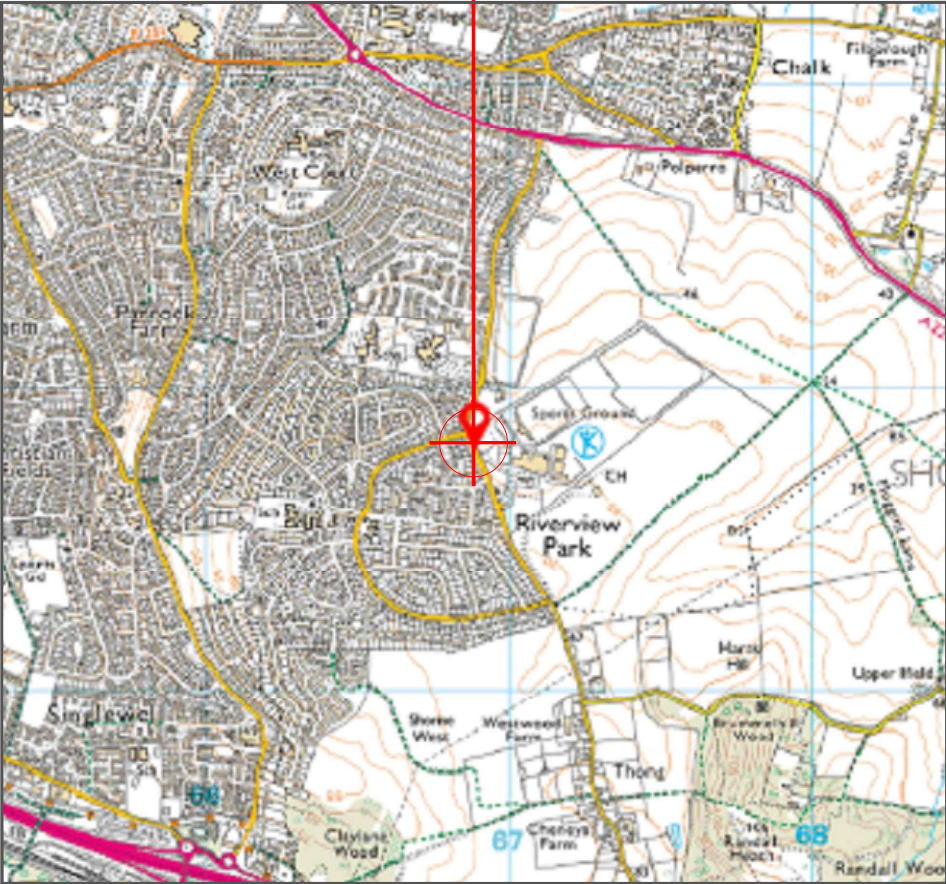


Reproduced by permission of Ordnance Survey on behalf of the Controller of His Majesty's Stationery Office
All rights reserved. © Crown Copyright licence no. 100022432

SITE AREA PLAN



SITE PHOTOGRAPH

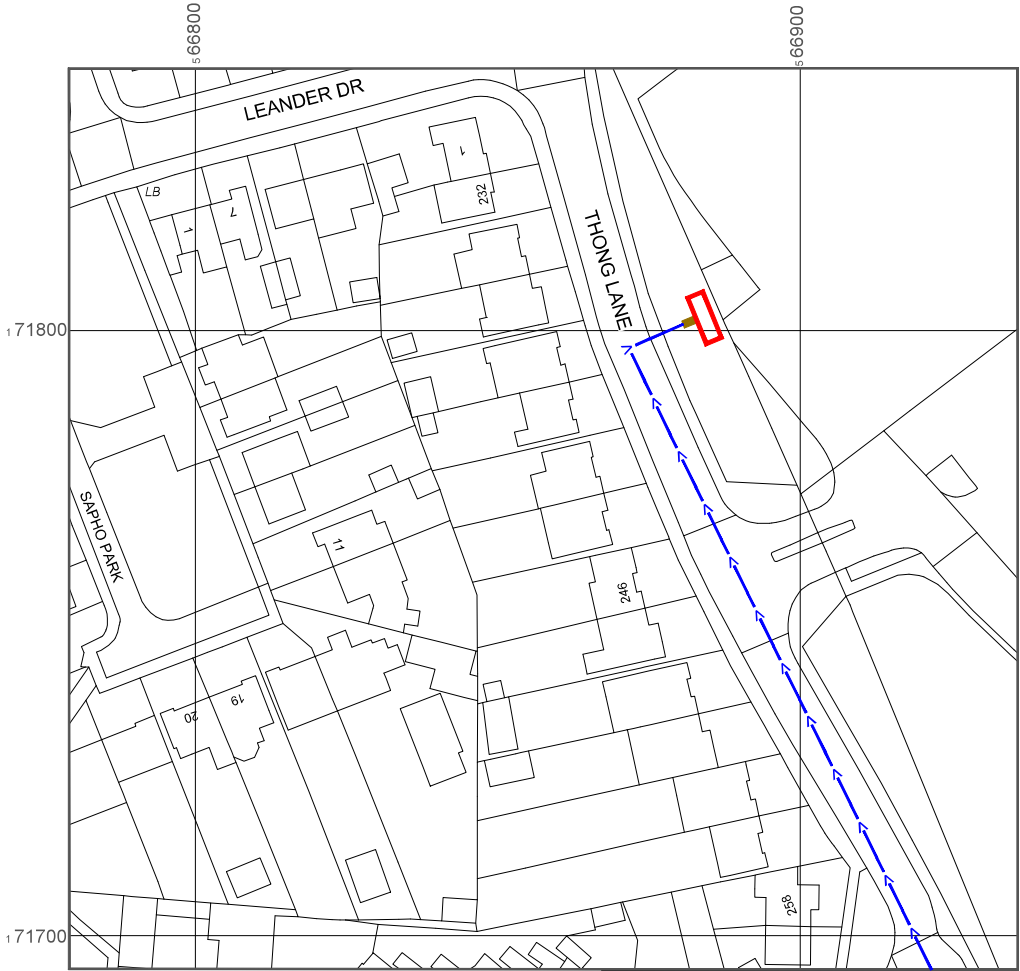


Reproduced by permission of Ordnance Survey on behalf of the Controller of His Majesty's Stationery Office
All rights reserved. © Crown Copyright licence no. 100022432

NGR E: 566889 N: 171799

W3W: keen.chose.areas

 SITE LOCATION PLAN



NOTES:

1. ALL DIMENSIONS IN MM UNLESS OTHERWISE NOTED.

Demise:



Access Route To Site:



Access Route:



JVCO ID - HS3023000R

Master:	Project:	Purpose of Issue:	Issue:
M001	Churchill	Detailed Design	A1
Date:	22/10/2025	Revision / Upgrade Description:	
Drawn:	RR	Detailed Design Issue	
Checked:	RAJ		
Approved:	DVH		



Hutchison 3G UK Limited
Green Park, 450 Longwater Avenue
Reading, RG30 3UR
Tel: 01628 765 000
Fax: 01628 765 001

H3G Base Station Information line:
0845 6043000
Available 8am-8pm Monday to Friday

Design Consultant:



WHP Telecoms
401 Faraday Street, Birchwood,
Park, Warrington, Cheshire,
WA3 6GA

Tel: 01925424100
e-mail: info@whptelecoms.com

Site Name:
LEGEND SC S/W 208674

Site ID:
1102380

Address:
LEGEND SC SW
THONG LANE GRAVESEND
GRAVESEND KENT
DA12 4LG


Title:
002 SITE LOCATION PLAN

Project:
CHURCHILL

Purpose of Issue:
DETAILED DESIGN

EE Cell ID:	MBNL Cell ID:	H3G Cell ID:
21830	GVM024	DA0103

File name:
GVM024_21830_DA0103_CWP_DD_A1

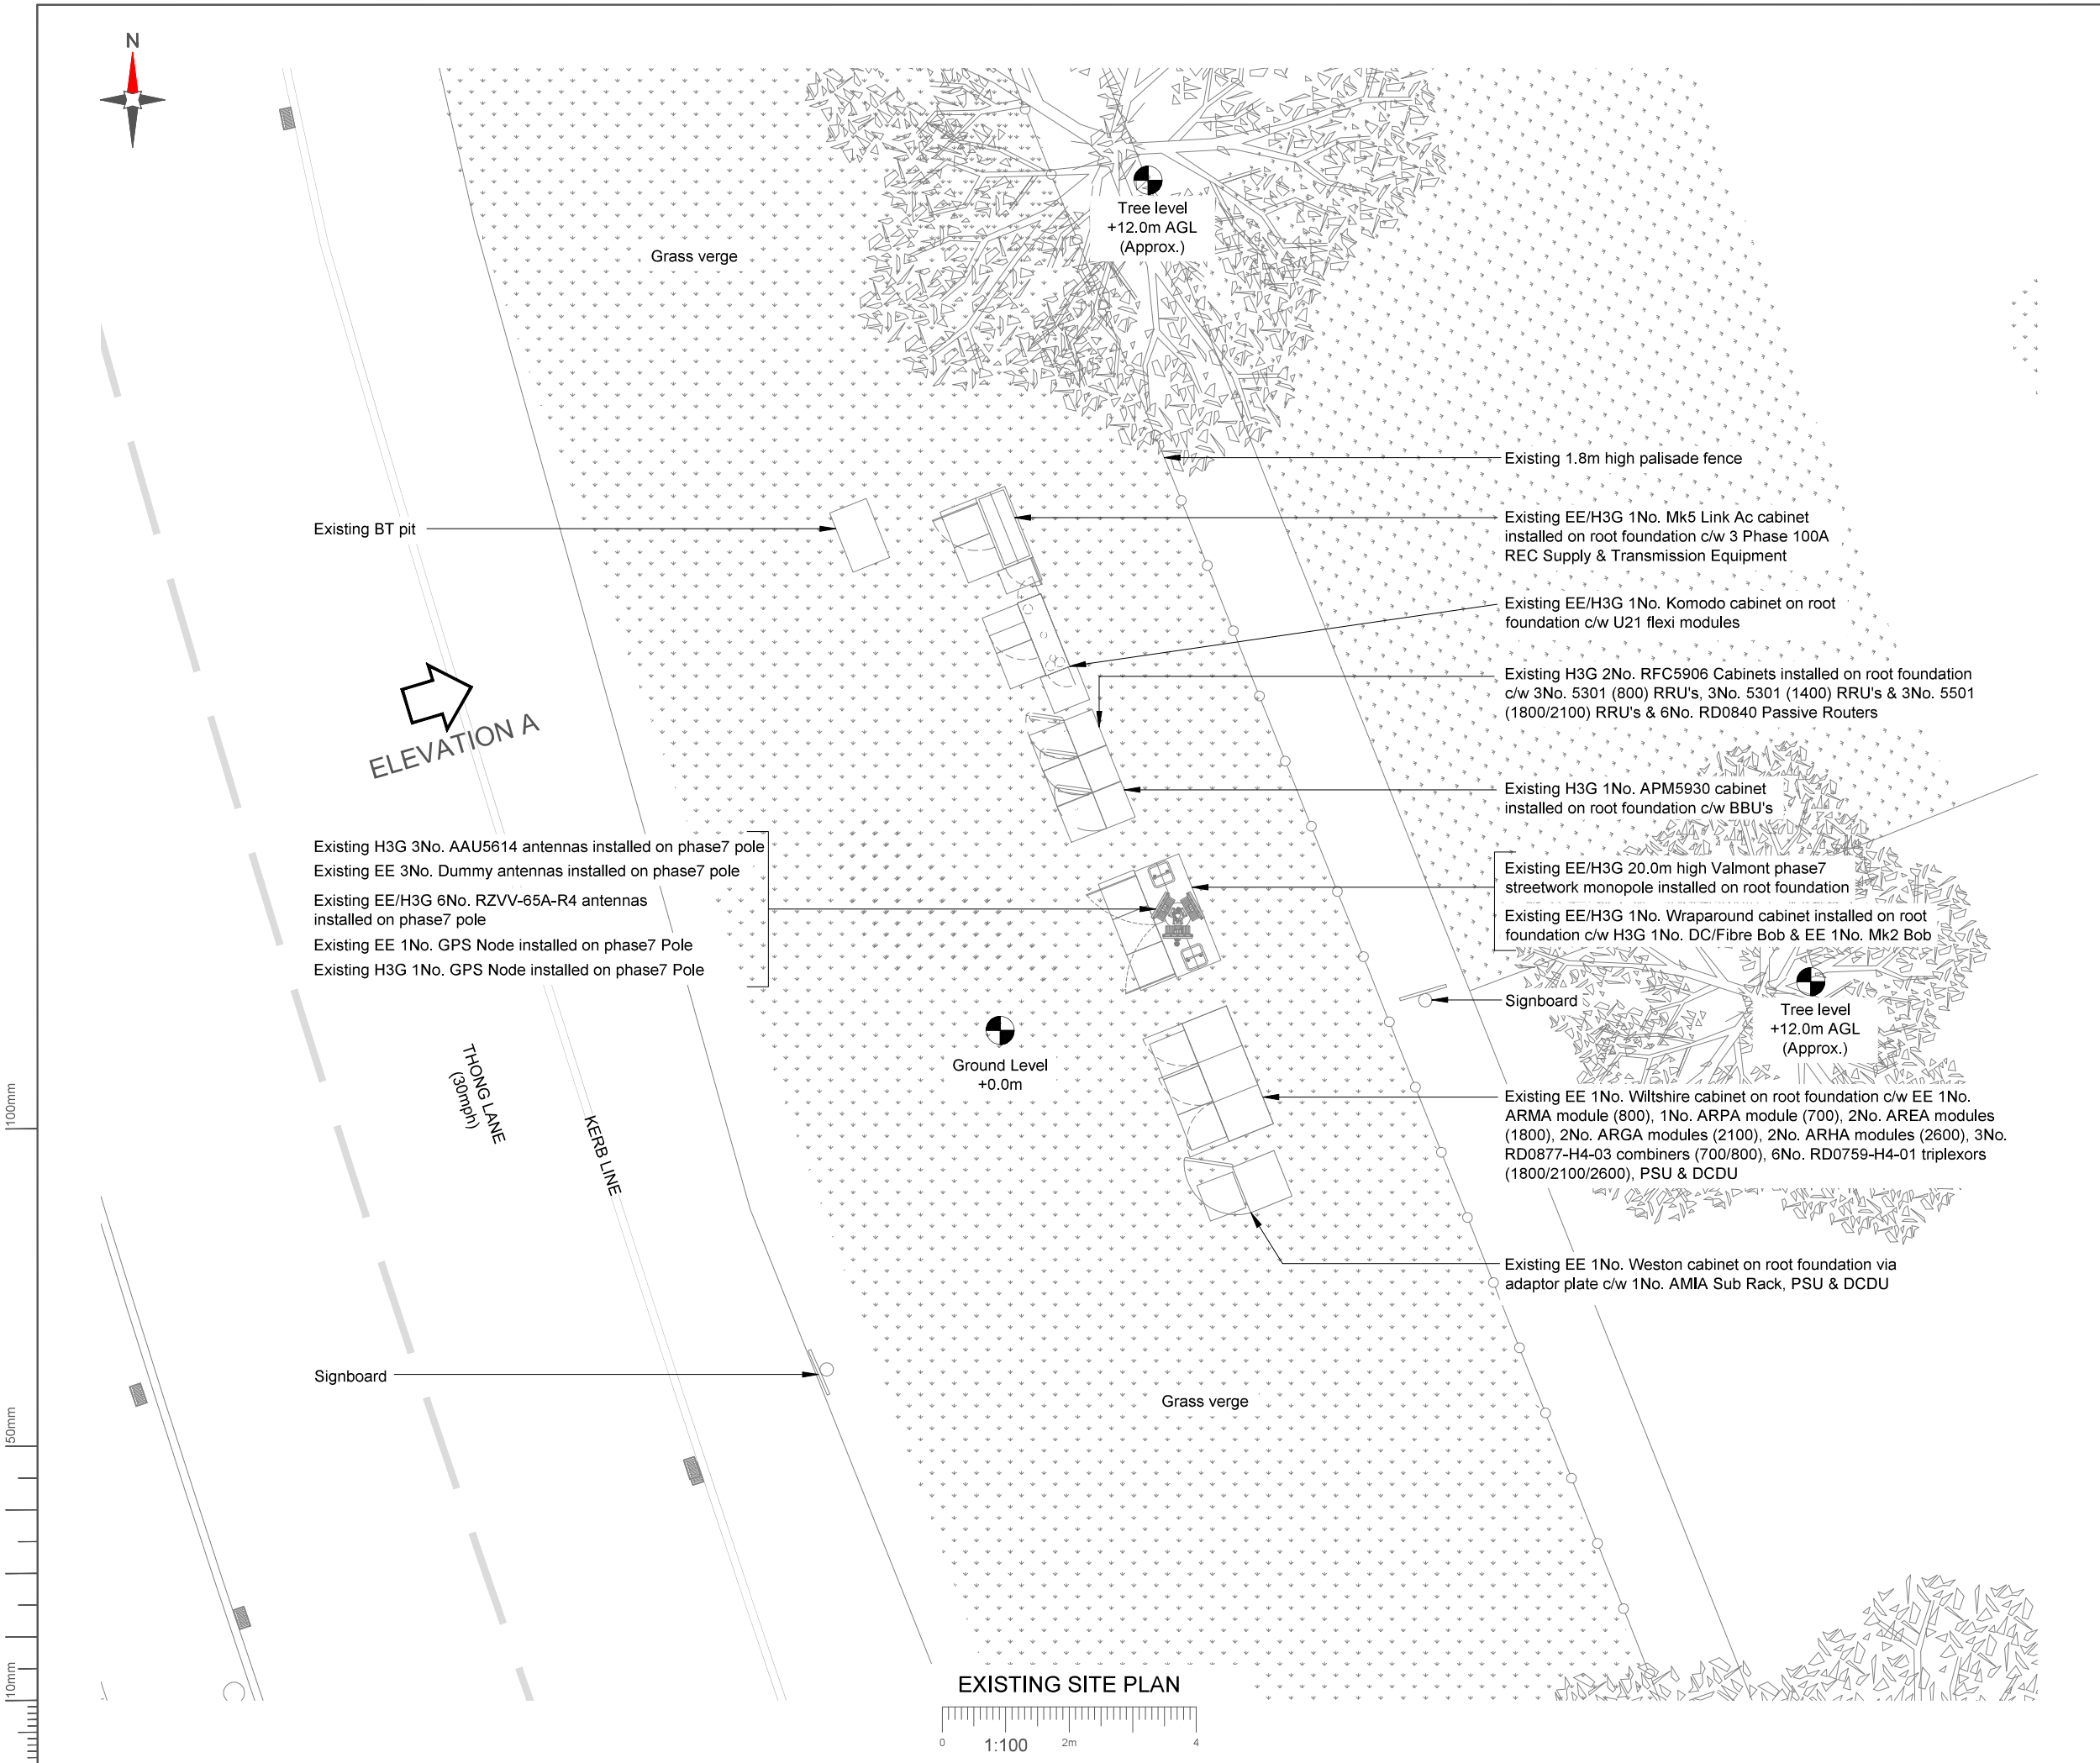

NOTES:
1. ALL DIMENSIONS IN MM UNLESS OTHERWISE NOTED.

JVCO ID - HS3023000R

Master:	Project:	Purpose of Issue:	Issue:
M001	Churchill	Detailed Design	A1
Date:	22/10/2025	Revision / Upgrade Description:	
Drawn:	RR	Detailed Design Issue	
Checked:	RAJ		
Approved:	DVH		

Hutchison 3G UK Limited
Green Park, 450 Longwater Avenue
Reading, RG30 3UR
Tel: 01628 765 000
Fax: 01628 765 001

H3G Base Station Information line:
0845 6043000
Available 8am-8pm Monday to Friday

Design Consultant:

WHP Telecoms
401 Faraday Street, Birchwood,
Park, Warrington, Cheshire,
WA3 6GA

Tel: 01925424100
e-mail: info@whptelecoms.com

Site Name:

LEGEND SC S/W 208674

Site ID:

1102380

Address:

LEGEND SC SW
THONG LANE GRAVESEND
GRAVESEND KENT
DA12 4LG

Title:

100 EXISTING SITE PLAN

Project:

CHURCHILL

Purpose of Issue:

DETAILED DESIGN

EE Cell ID:	MBNL Cell ID:	H3G Cell ID:
21830	GVM024	DA0103

File name:

GVM024_21830_DA0103_CWP_DD_A1



THONG LANE
(30mph)

Grass verge

Tree level
+12.0m AGL
(Approx.)

— Existing 1.8m high palisade fence

→ Existing EE/H3G 1No. Mk5 Link Ac cabinet installed on root foundation c/w 3 Phase 100A REC Supply & Transmission Equipment

- Existing EE/H3G 1No. Komodo cabinet on root foundation c/w U21 flexi modules to be removed

→ Existing H3G 2No. RFC5906 Cabinets installed on root foundation
c/w 3No. 5301 (800) RRU's, 3No. 5301 (1400) RRU's & 3No. 5501
(1800/2100) RRU's & 6No. RD0840 Passive Routers to be removed

Existing H3G 1No. APM5930 cabinet installed on root foundation c/w BBU's to be removed

Existing EE/H3G 20.0m high Valmont phase7
streetwork monopole installed on root foundation

Existing EE/H3G 1No. Wraparound cabinet installed on root foundation c/w H3G 1No. DC/Fibre Bob & EE 1No. Mk2 Bob

— Signboard 5

Tree level
+12.0m AG
(Approx.)

— Existing EE 1No. Wiltshire cabinet on roof foundation c/w EE 1No.
ARMA module (800), 1No. ARPA module (700), 2No. AREA modules
(1800), 2No. ARGA modules (2100), 2No. ARHA modules (2600), 3No.
RD0877-H4-03 combiners (700/800), 6No. RD0759-H4-01 triplexors
(1800/2100/2600), PSU & DCDU

Existing EE 1No. Weston cabinet on root foundation via adaptor plate c/w 1No. AMIA Sub Rack, PSU & DCDU

Grass verge

PROPOSED SITE PLAN

NOTES:

1. ALL DIMENSIONS IN MM UNLESS OTHERWISE NOTED.

JVCO ID - HS3023000R

Master: M001	Project: Churchill	Purpose of Issue: Detailed Design	Issue: A1
Date: 22/10/2025	Revision / Upgrade Description: Detailed Design Issue		
Drawn: RR			
Checked: RAJ			
Approved: DVH			



Hutchison 3G UK Limited
Green Park, 450 Longwater Avenue
Reading, RG30 3UR
Tel: 01628 765 000
Fax: 01628 765 001

H3G Base Station Information line:
0845 6043000
Available 8am-8pm Monday to Friday

Design Consultant:



WHP Telecoms
401 Faraday Street, Birchwood,
Park, Warrington, Cheshire,
WA3 6GA

Tel: 01925424100
e-mail: info@whptelecoms.com

Site Name:

LEGEND SC S/W 208674

Site ID:

1102380

Address:

LEGEND SC SW
THONG LANE GRAVESEND
GRAVESEND KENT
DA12 4LG

Title:

150 PROPOSED SITE PLAN

Project:

CHURCHILL


Purpose of Issue:

DETAILED DESIGN

EE Cell ID: 21830	MBNL Cell ID: GVM024	H3G Cell ID: DA0103
-----------------------------	--------------------------------	-------------------------------

File name:

GVM024 21830 DA0103 CWP DD A1

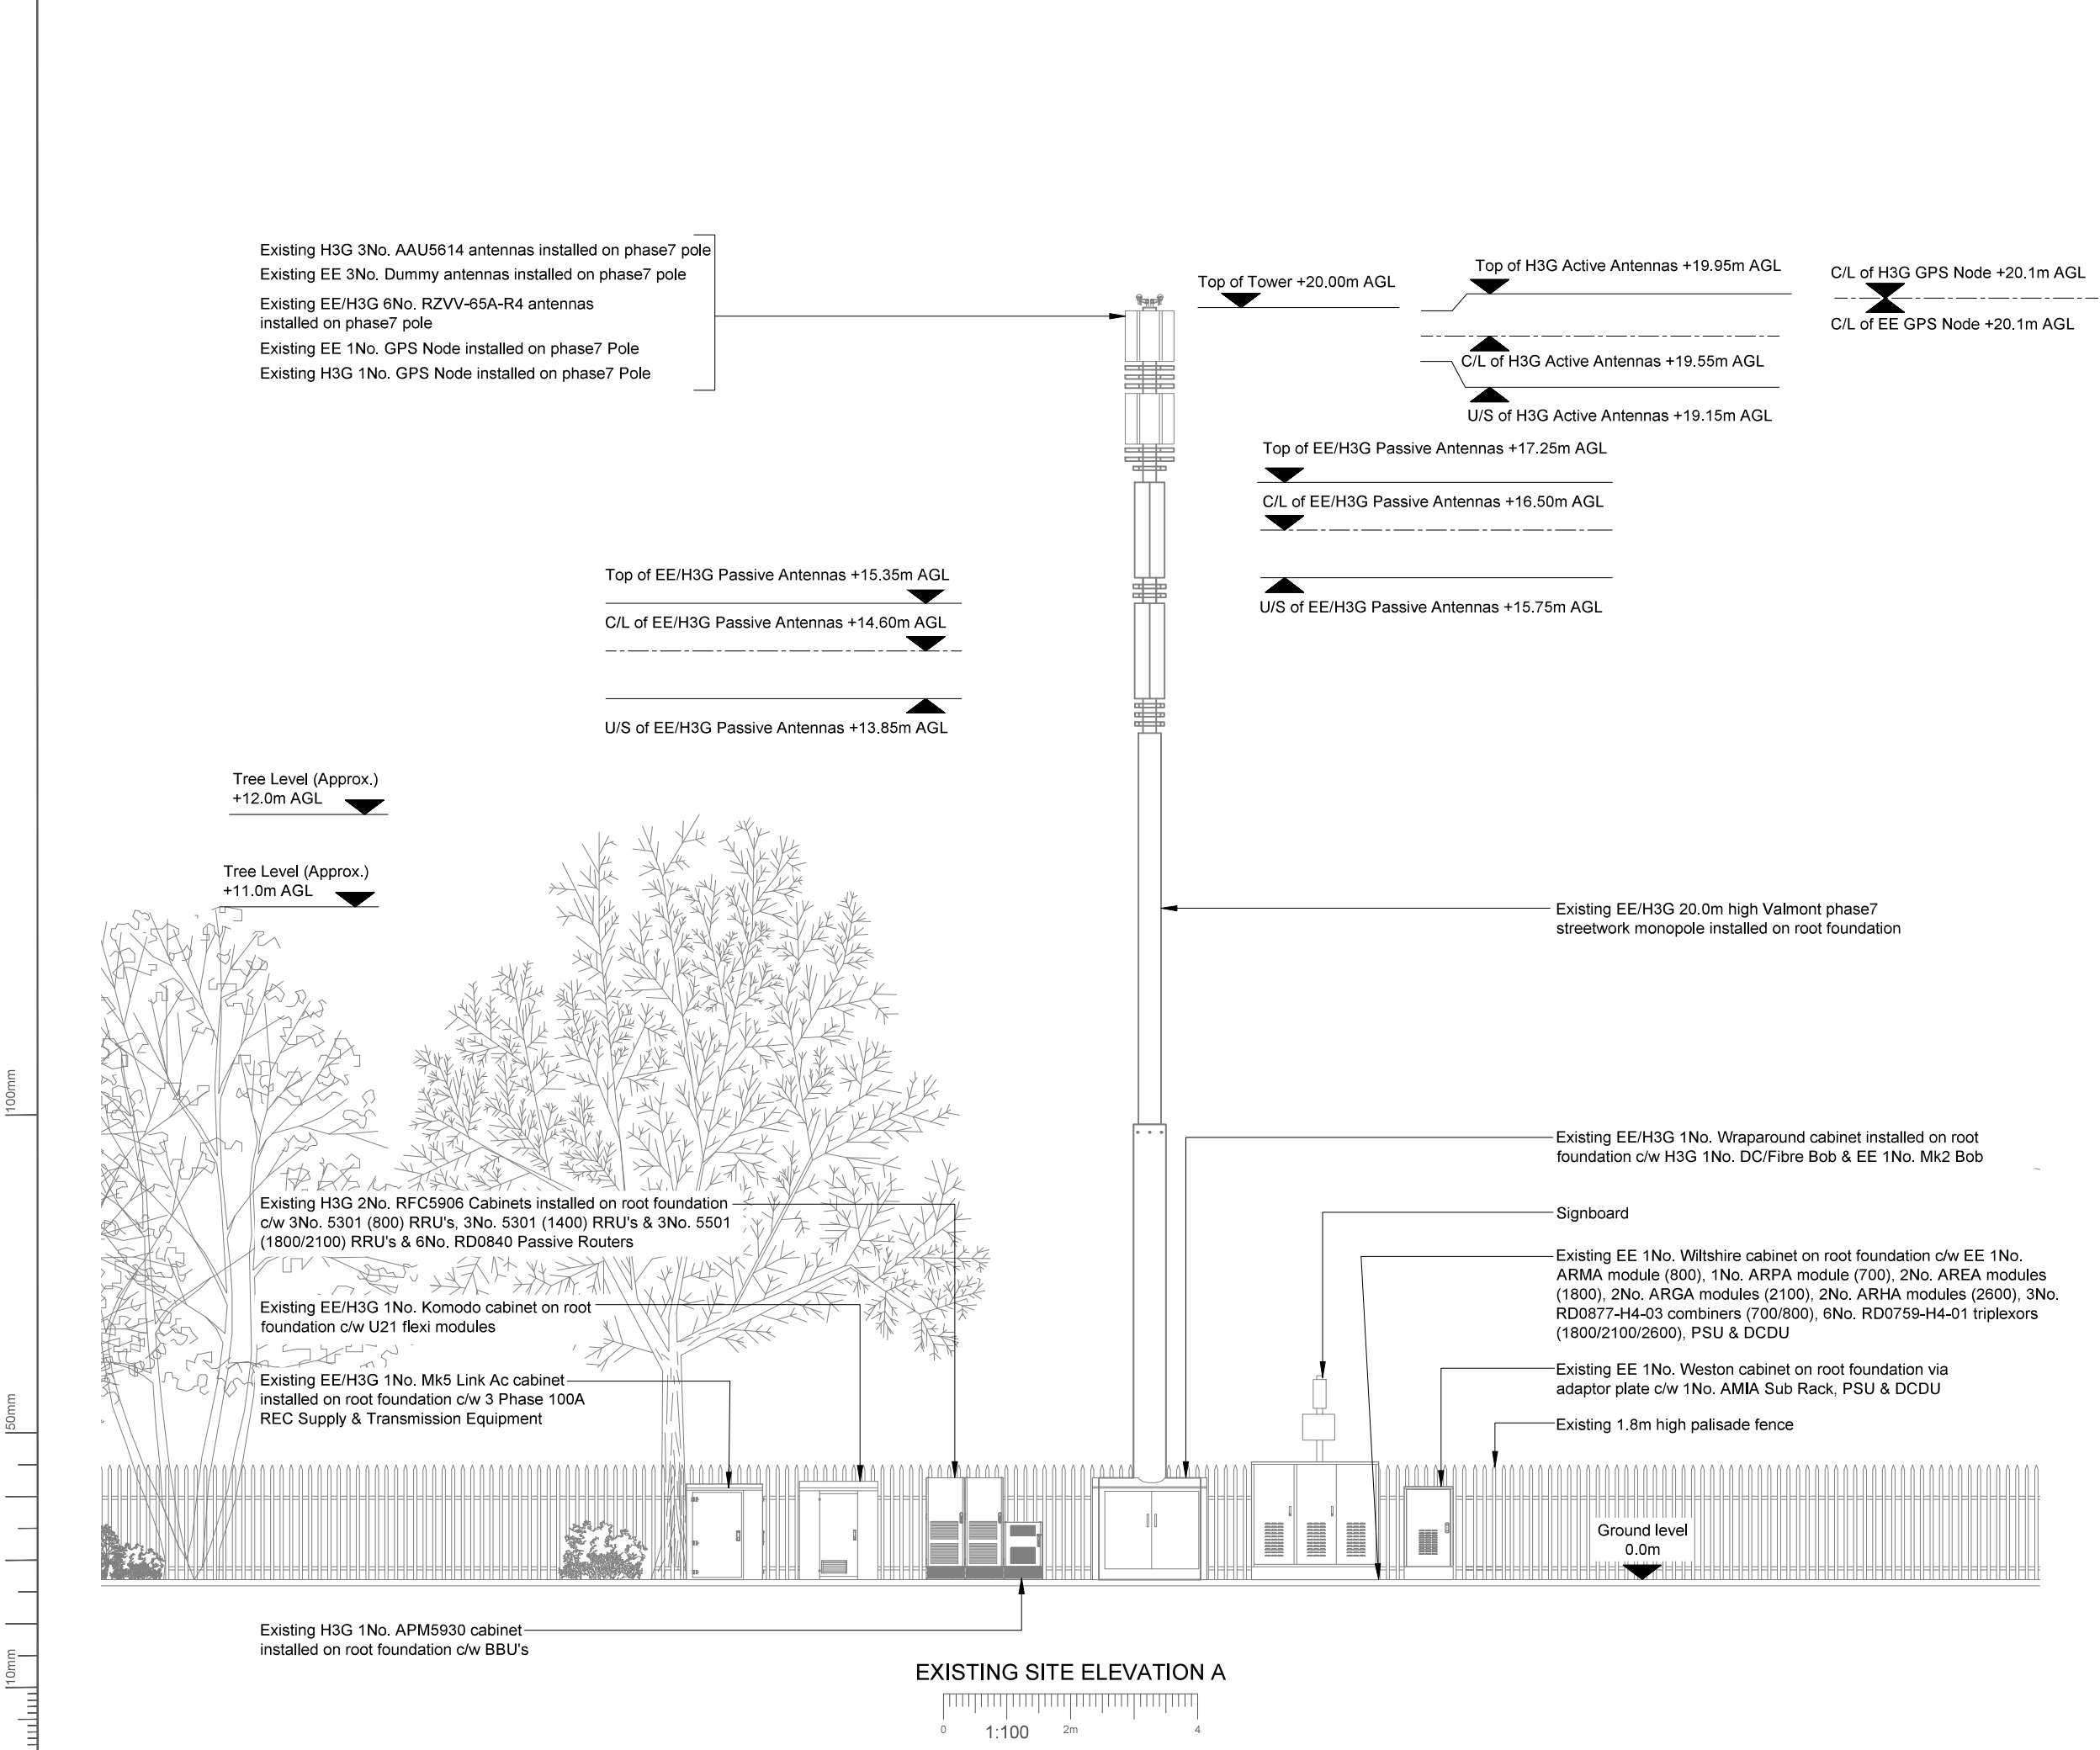

NOTES:
1. ALL DIMENSIONS IN MM UNLESS OTHERWISE NOTED.

JVCO ID - HS3023000R

Master:	Project:		Purpose of Issue:	Issue:
M001	Churchill		Detailed Design	A1
Date:	22/10/2025	Revision / Upgrade Description:		
Drawn:	RR	Detailed Design Issue		
Checked:	RAJ			
Approved:	DVH			



Hutchison 3G UK Limited
Green Park, 450 Longwater Avenue
Reading, RG30 3UR
Tel: 01628 765 000
Fax: 01628 765 001

H3G Base Station Information line:
0845 6043000
Available 8am-8pm Monday to Friday

Design Consultant:


WHP Telecoms
401 Faraday Street, Birchwood,
Park, Warrington, Cheshire,
WA3 6GA

Tel: 01925424100
e-mail: info@whptelecoms.com

Site Name:
LEGEND SC S/W 208674

Site ID:
1102380

Address:
LEGEND SC SW
THONG LANE GRAVESEND
GRAVESEND KENT
DA12 4LG


Title:
200 EXISTING SITE ELEVATION

Project:
CHURCHILL

Purpose of Issue:
DETAILED DESIGN

EE Cell ID:	MBNL Cell ID:	H3G Cell ID:
21830	GVM024	DA0103

File name:
GVM024_21830_DA0103_CWP_DD_A1

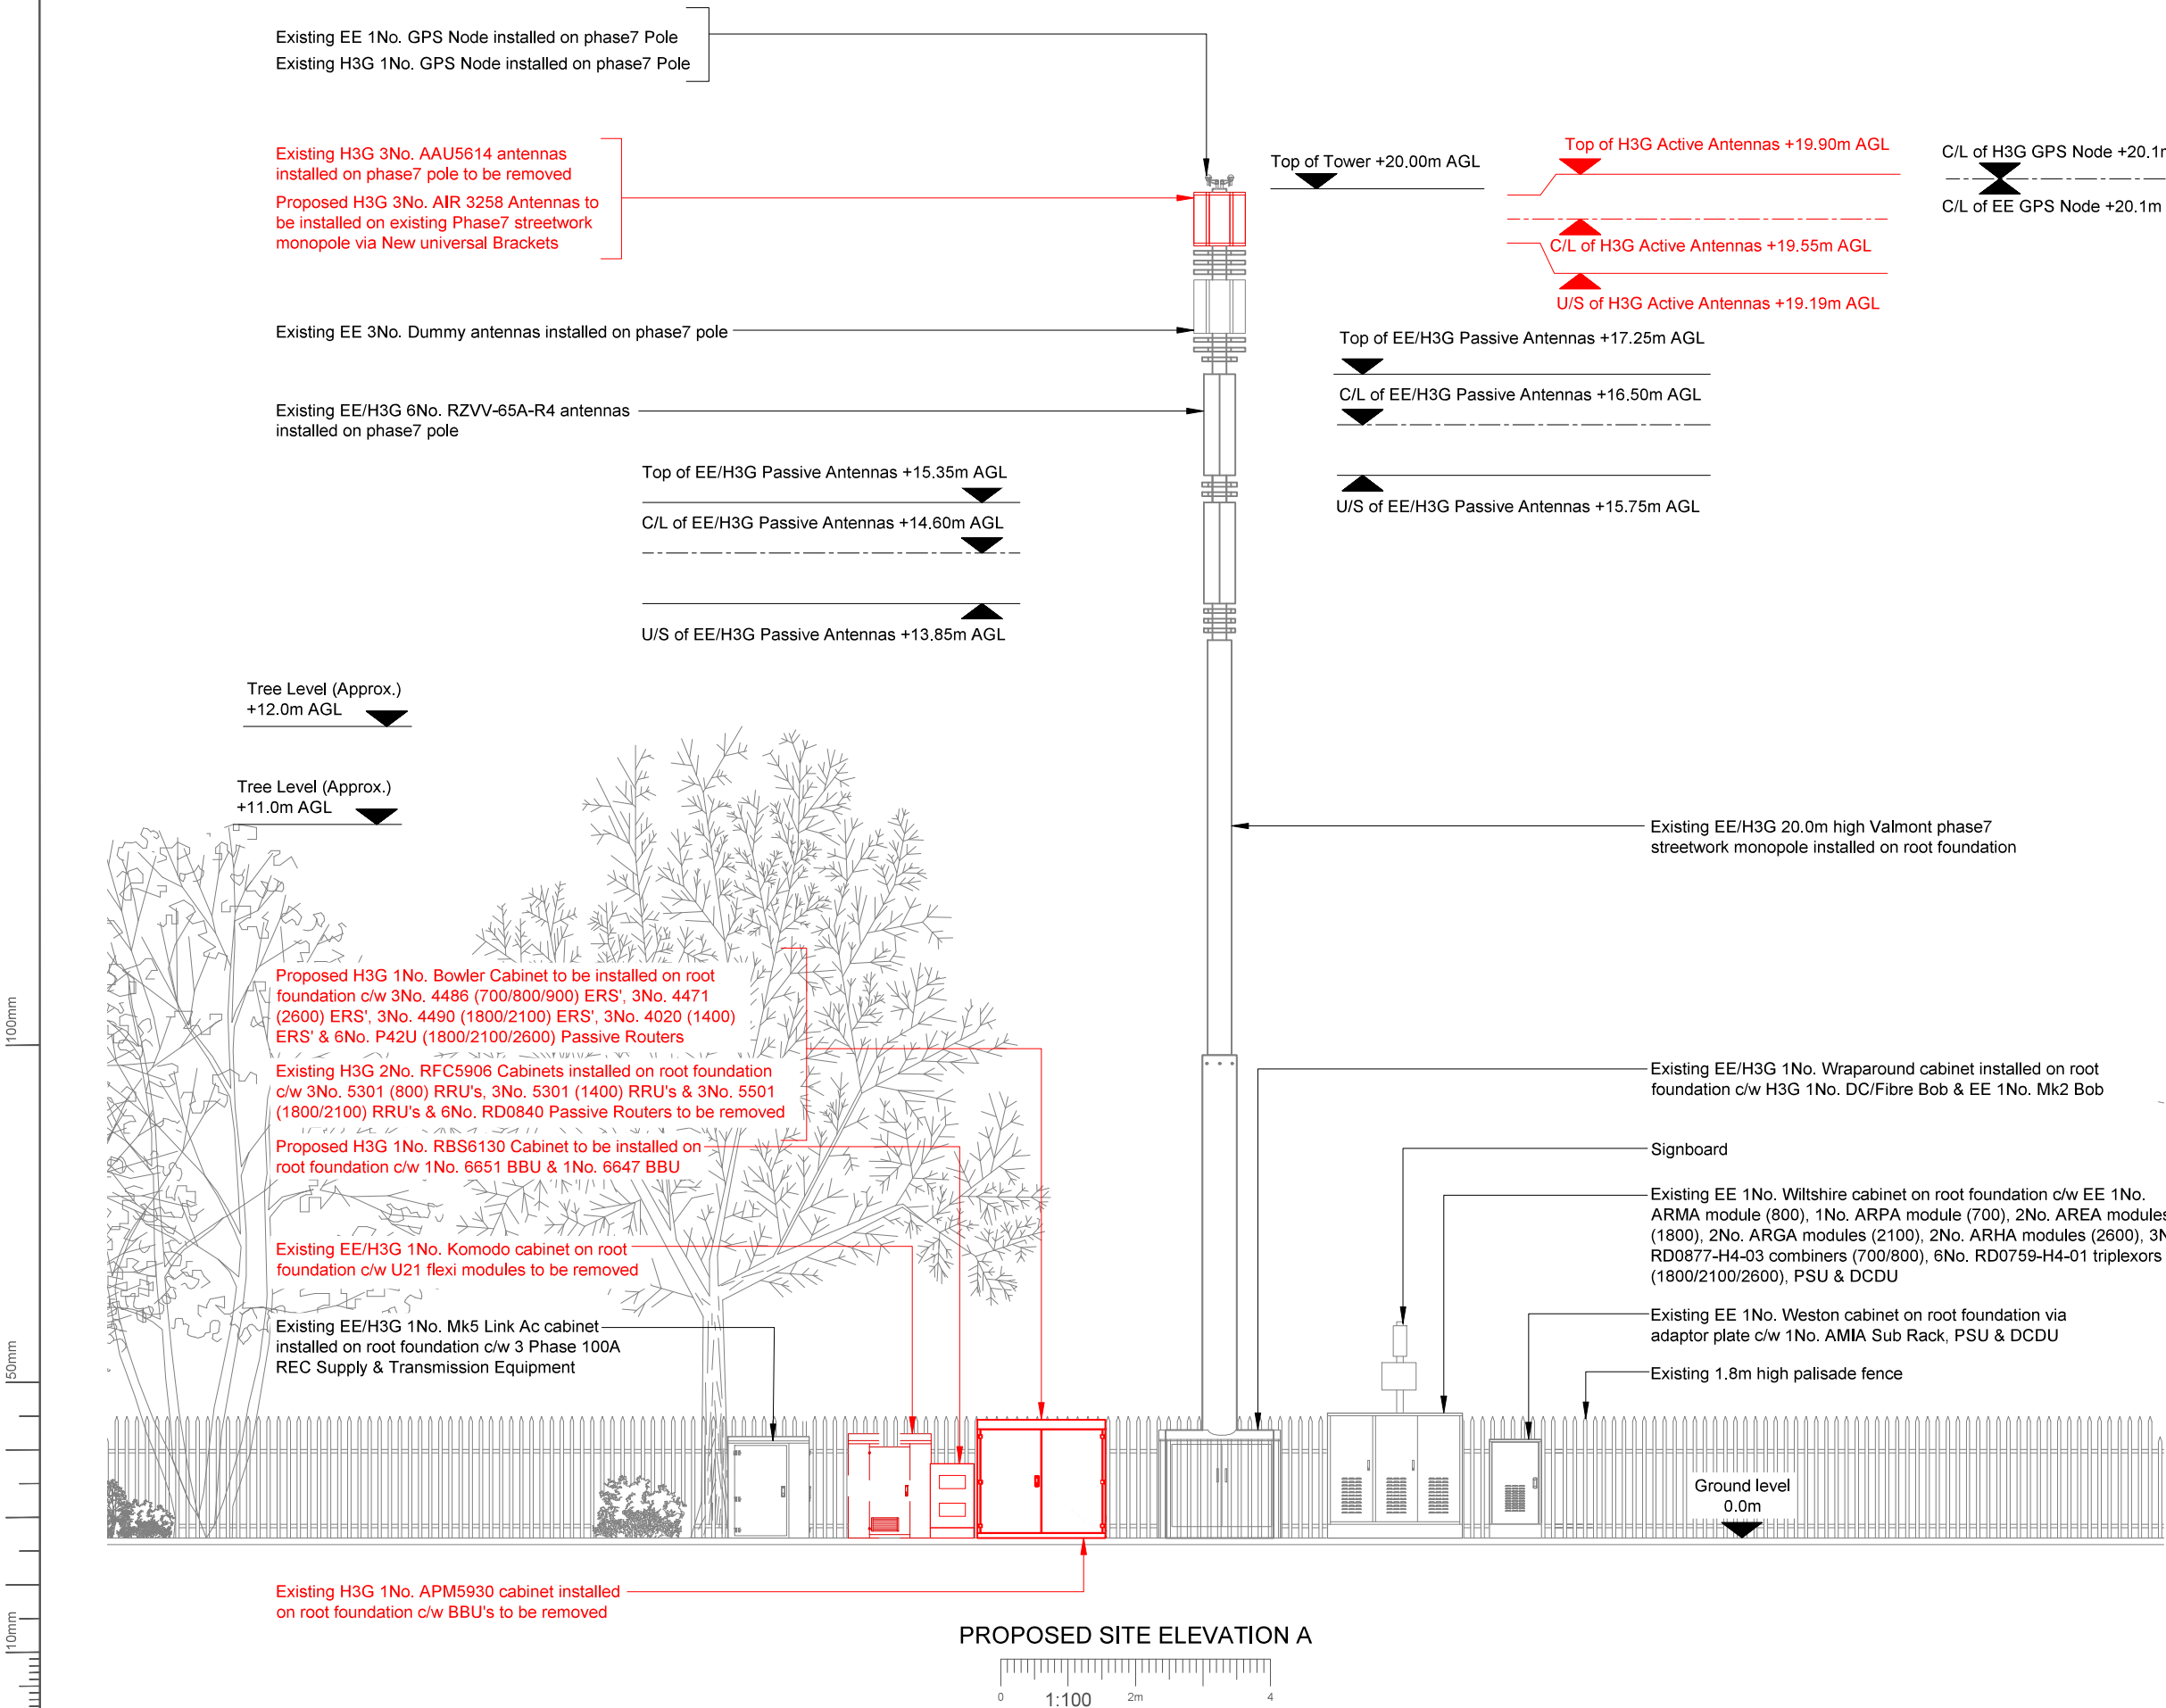

NOTES:

1. ALL DIMENSIONS IN MM UNLESS OTHERWISE NOTED.

JVCO ID - HS3023000R

Master:	Project:	Purpose of Issue:	Issue:
M001	Churchill	Detailed Design	A1
Date:	22/10/2025	Revision / Upgrade Description:	
Drawn:	RR	Detailed Design Issue	
Checked:	RAJ		
Approved:	DVH		



Hutchison 3G UK Limited
Green Park, 450 Longwater Avenue
Reading, RG30 3UR
Tel: 01628 765 000
Fax: 01628 765 001

H3G Base Station Information line:
0845 6043000
Available 8am-8pm Monday to Friday

Design Consultant:



WHP Telecoms
401 Faraday Street, Birchwood,
Park, Warrington, Cheshire,
WA3 6GA

Tel: 01925424100
e-mail: info@whptelecoms.com

Site Name:
LEGEND SC S/W 208674

Site ID:
1102380

Address:
**LEGEND SC SW
THONG LANE GRAVESEND
GRAVESEND KENT
DA12 4LG**

Title:
250 PROPOSED SITE ELEVATION

Project:
CHURCHILL

Purpose of Issue:
DETAILED DESIGN

EE Cell ID:	MBNL Cell ID:	H3G Cell ID:
21830	GVM024	DA0103

File name:
GVM024_21830_DA0103_CWP_DD_A1