

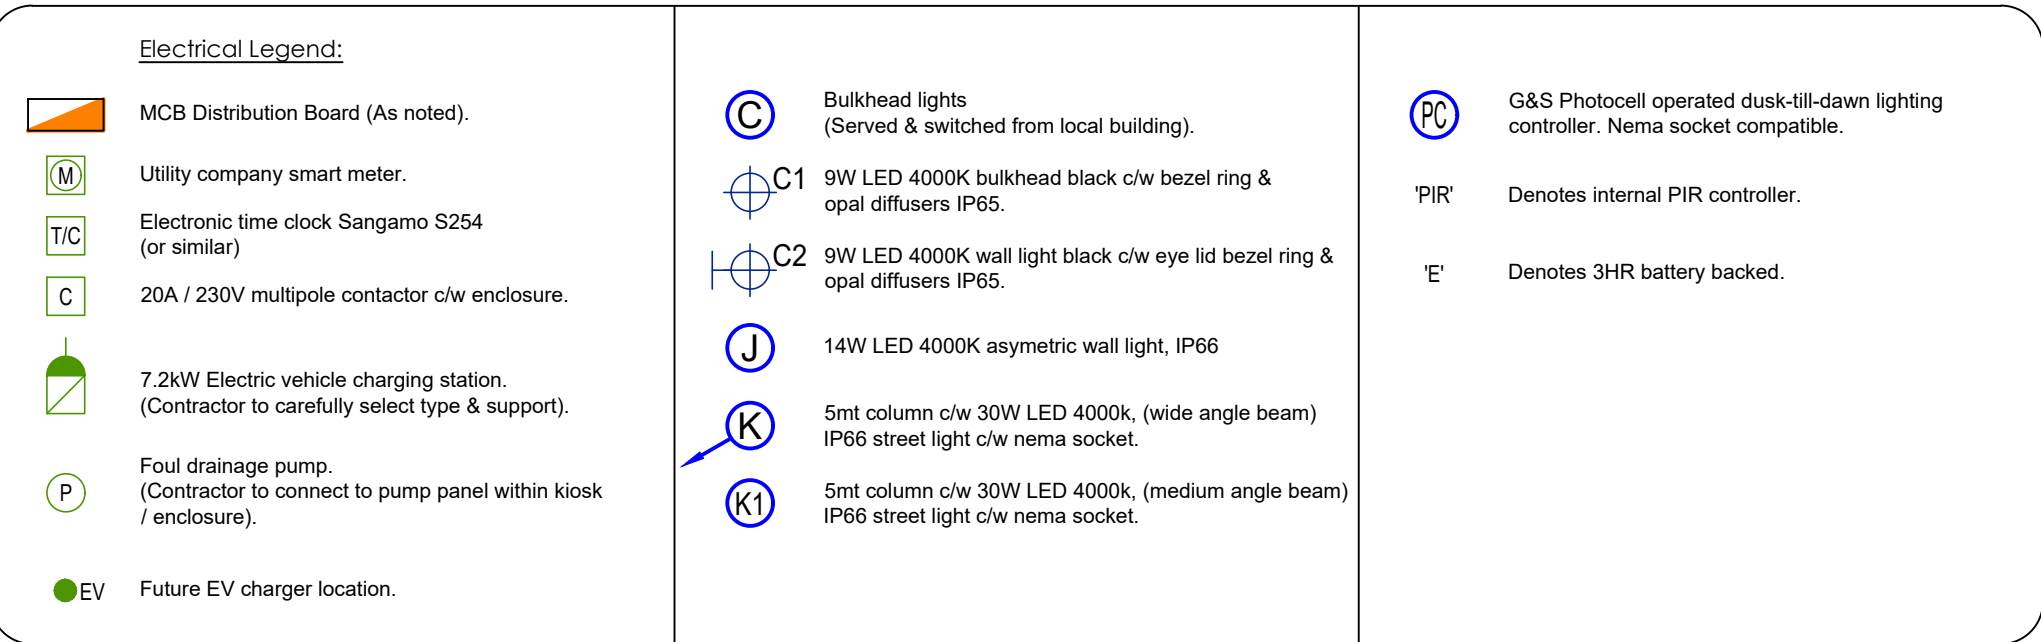


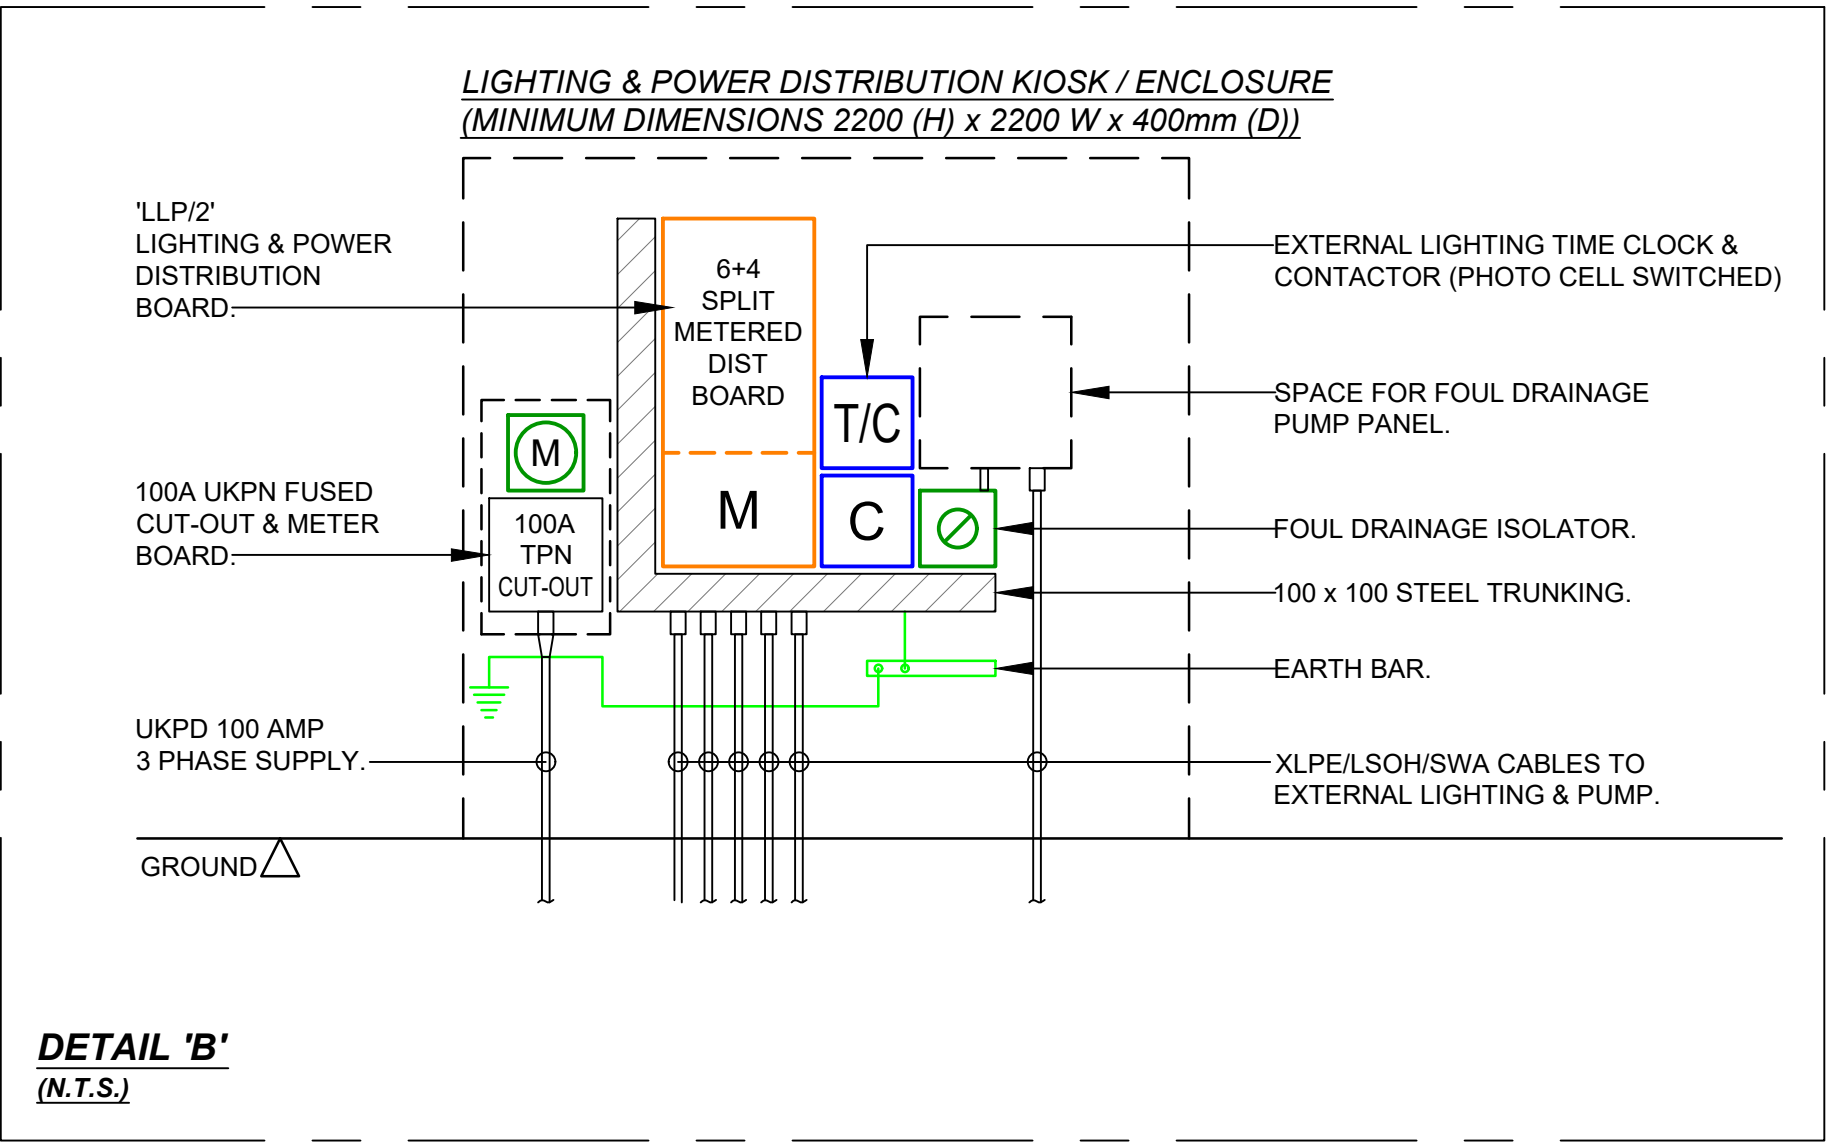

2. REFER TO DISTRIBUTION BOARD SCHEDULE FOR CIRCUIT REFERENCES.
3. LIGHTING SHALL BE CO-ORDINATED WITH ALL OTHER ELECTRICAL & MECHANICAL SERVICES INSTALLATIONS.
4. FINAL SETTING OUT OF EQUIPMENT SHALL BE TO THE ARCHITECT'S ROOM LAYOUT & REFLECTIVE CEILING PLANS.
5. LOCATIONS DENOTED  EV ARE FUTURE EV CHARGING POINTS TO BE CABLED FOR FUTURE CONNECTION.

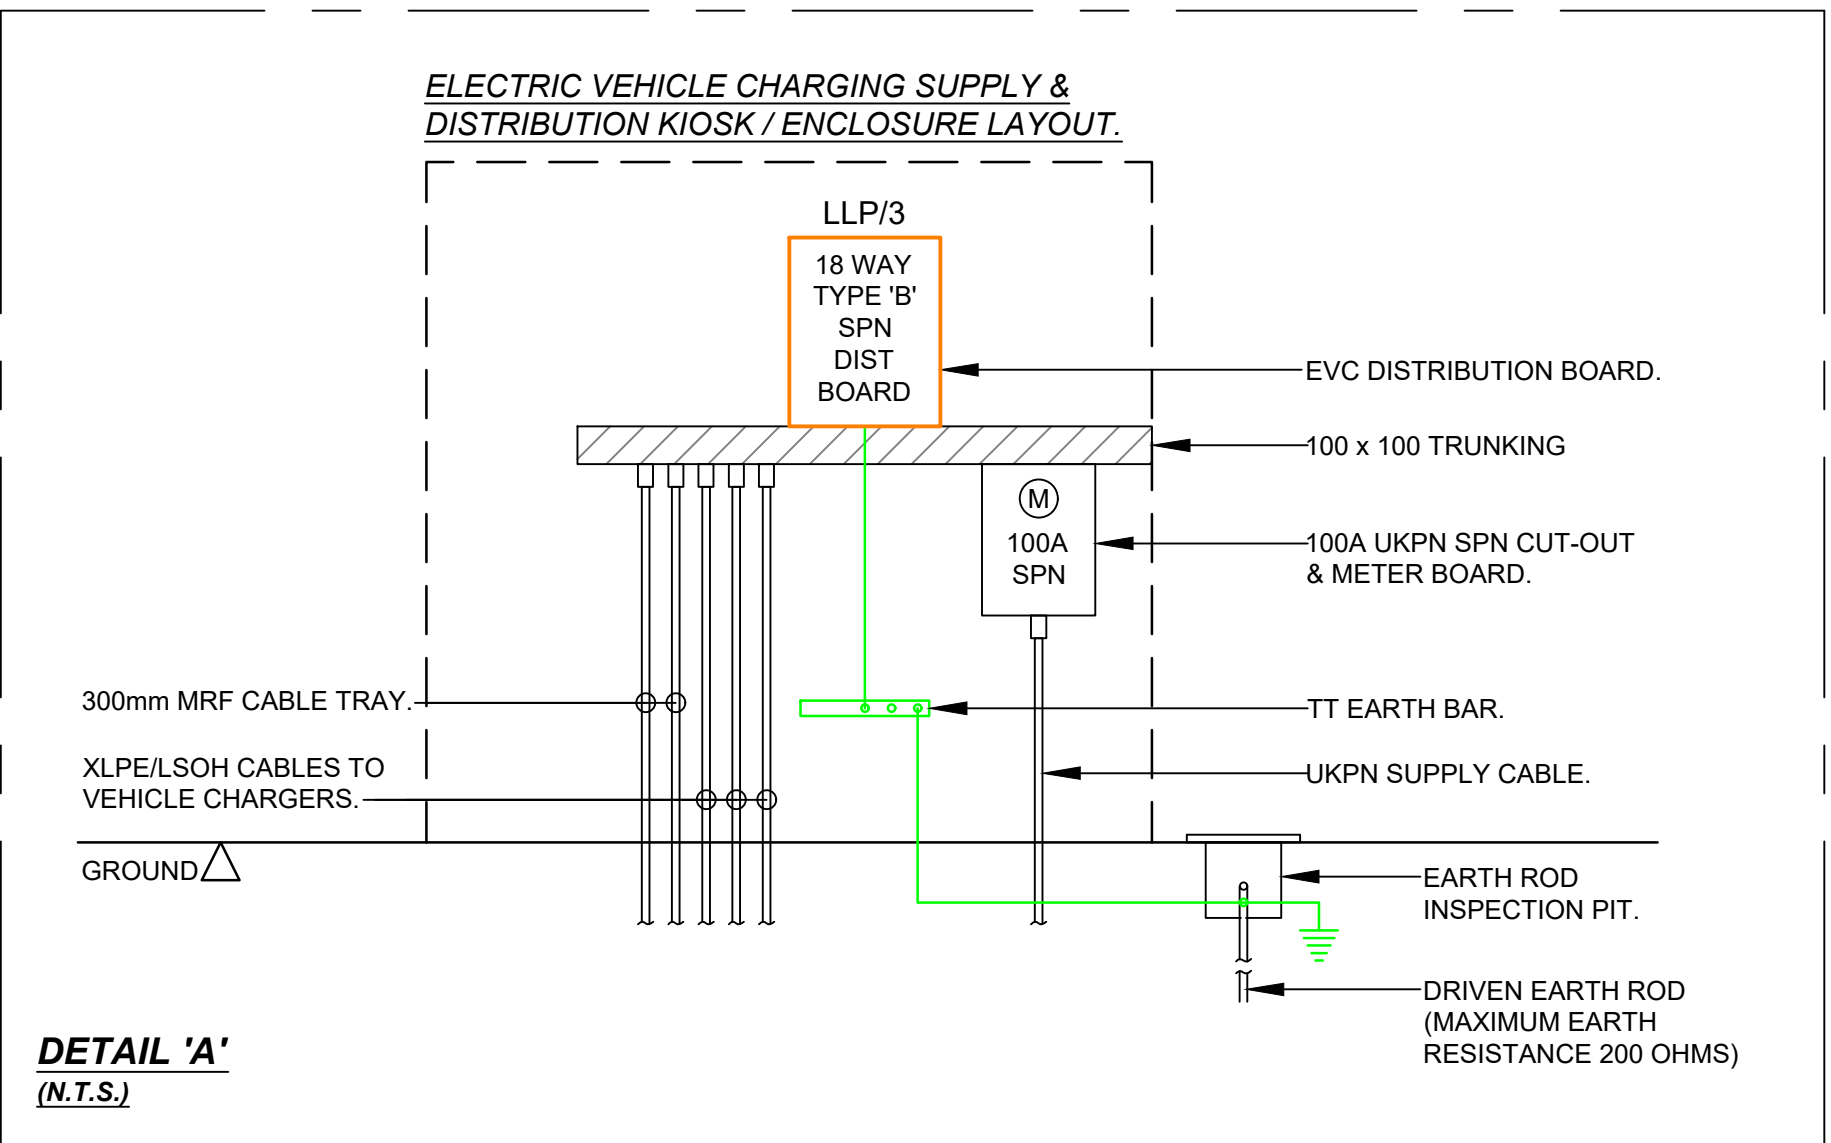

C1	GAZEBO LIGHTING & POWER ADDED. PUMP CHAMBER POWER LOCATION CHANGED. 'J' TYPE LIGHTING CHANGED TO ASYMMETRIC TYPE& FUTURE EV CHARGER POINTS ADDED.	31/07/20
P1	ISSUED FOR APPROVAL.	26/04/20
REF	REVISION	DATE

FOR APPROVAL



Client

Project

Custom House
The Terrace
Gravesend, DA12 2BW

Title:

EXTERNAL LIGHTING, POWER & ANCILLARY SERVICES

Date:

March 2025

Cad R

•

Project No.

Scale:

Eng.:

Drawn

E241

1:200 @

100

Drawing No.: EXT/XX/DR/E/61/016

C1