


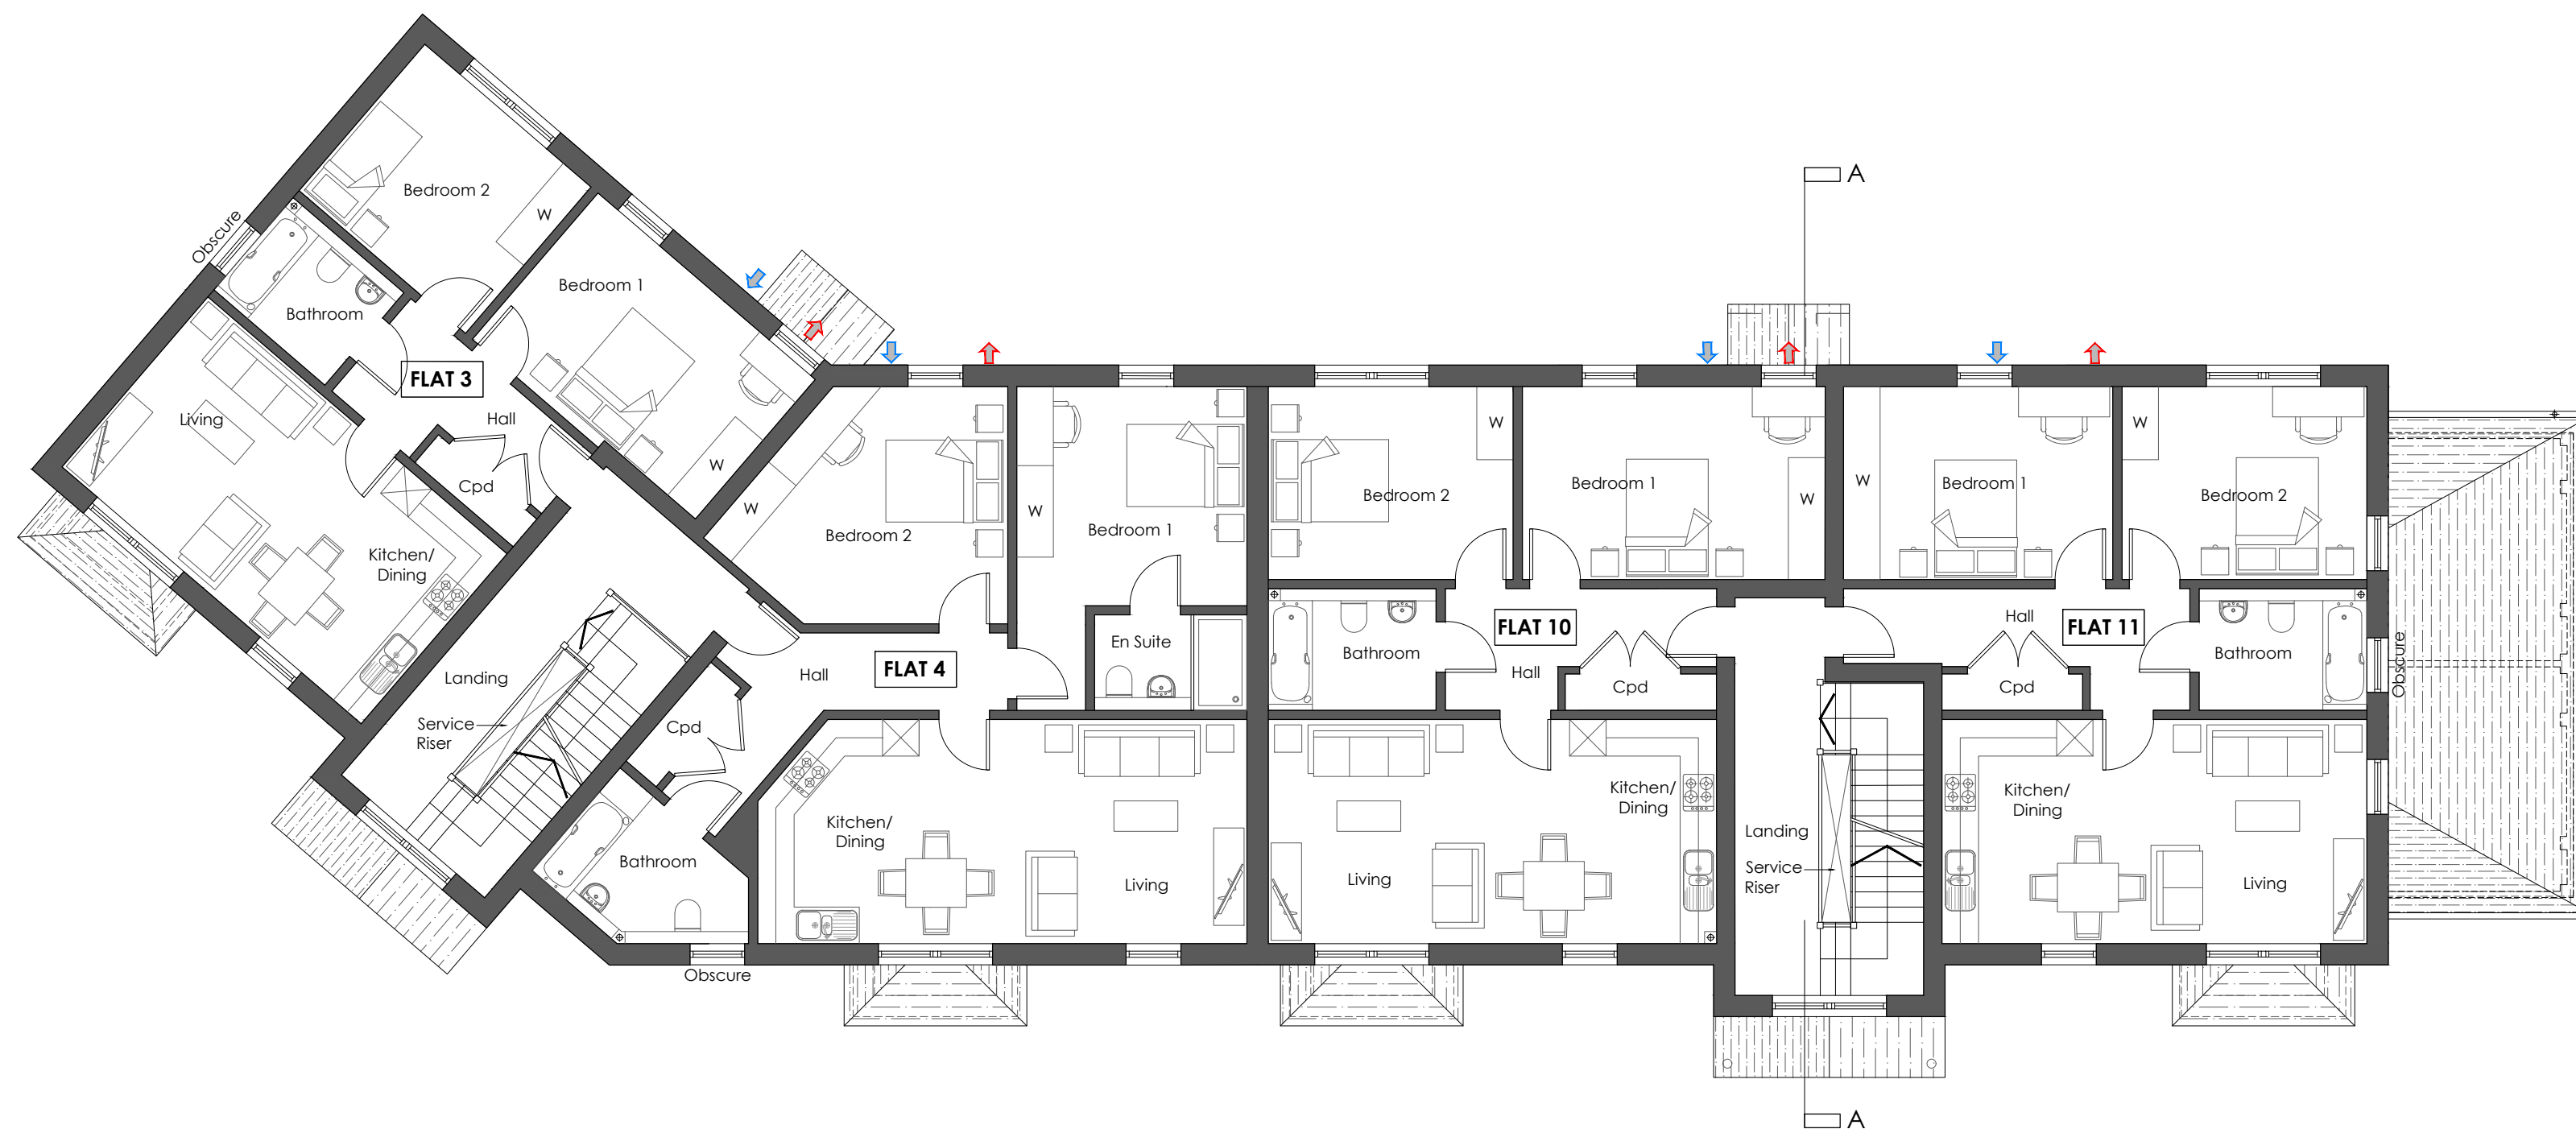

Proposed First Floor Plan
SCALE 1:100


- AIR HANDLING SYSTEM FAN INTAKE GRILLE
 AIR HANDLING SYSTEM FAN EXTRACT GRILLE

READ IN CONJUNCTION WITH INDIVIDUAL APARTMENT PLANS BY ZEHNDER
SHOWING PROPOSED AIR HANDLING UNIT LOCATIONS AND DUCTWORK
ROUTING.

PROPOSED AIR HANDLING UNITS FOR UNITS 1, 2, 3, 4, 5, 6, 8, 9, 10, 11, 12 & 13
= CEILING MOUNTED **CA15SCM-G8 (RH) MVHR**

PROPOSED AIR HANDLING UNITS FOR UNITS 7 & 14
= WALL MOUNTED **CA155WM-G8 MVHR**

ALL UNITS HAVE **CA125400 ATTENUATORS** FITTED TO SUPPLY
AND EXTRACT DUCTS.

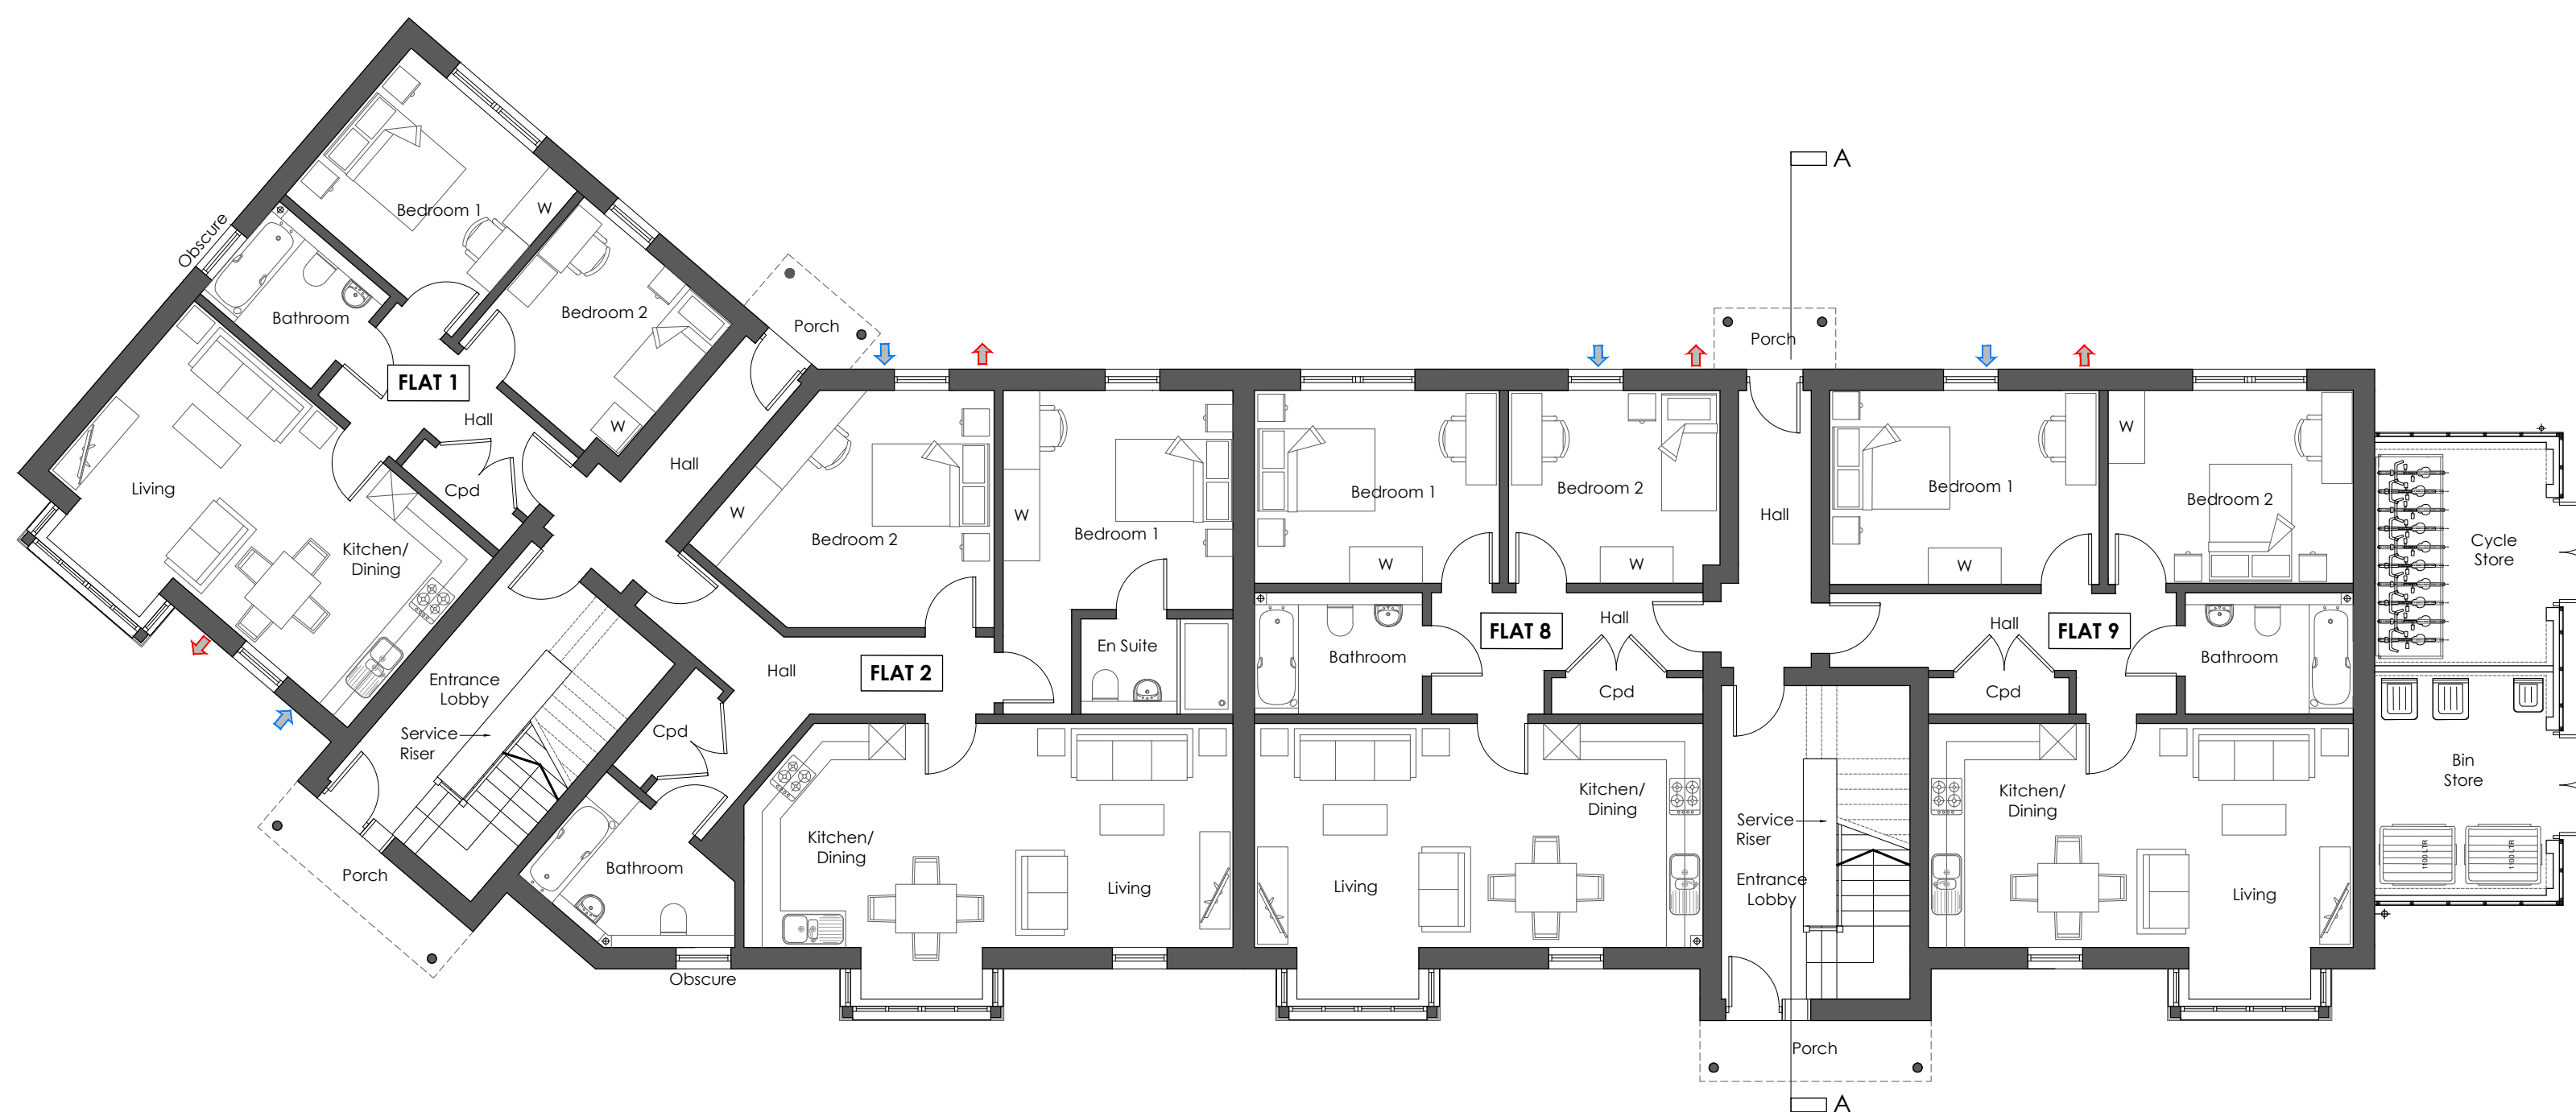

Proposed Ground Floor Plan
SCALE 1:100

0m 2.5m 5m 7.5m 10m
Scale Bar 1:100



Rev	Date	Comments
-----	------	----------

PLANNING

Client
BRT Properties Kent Ltd

Project
2 Vale Road,
Northfleet,
Gravesend,
Kent,
DA11 8BZ

Title
Proposed Ground & First Floor Plans

Project No.	Date
7985	MAR 25
Drawing No.	Revision
7985-PD-20	
Scale	Drawn
AS SHOWN @A1	NF
	Check
	RR

Nepical House, London Road
Wrotham Heath, TN15 7ES
phone: 01732 753333
fax: 01732 753334
info@offsetarchitects.co.uk
www.offsetarchitects.co.uk

