




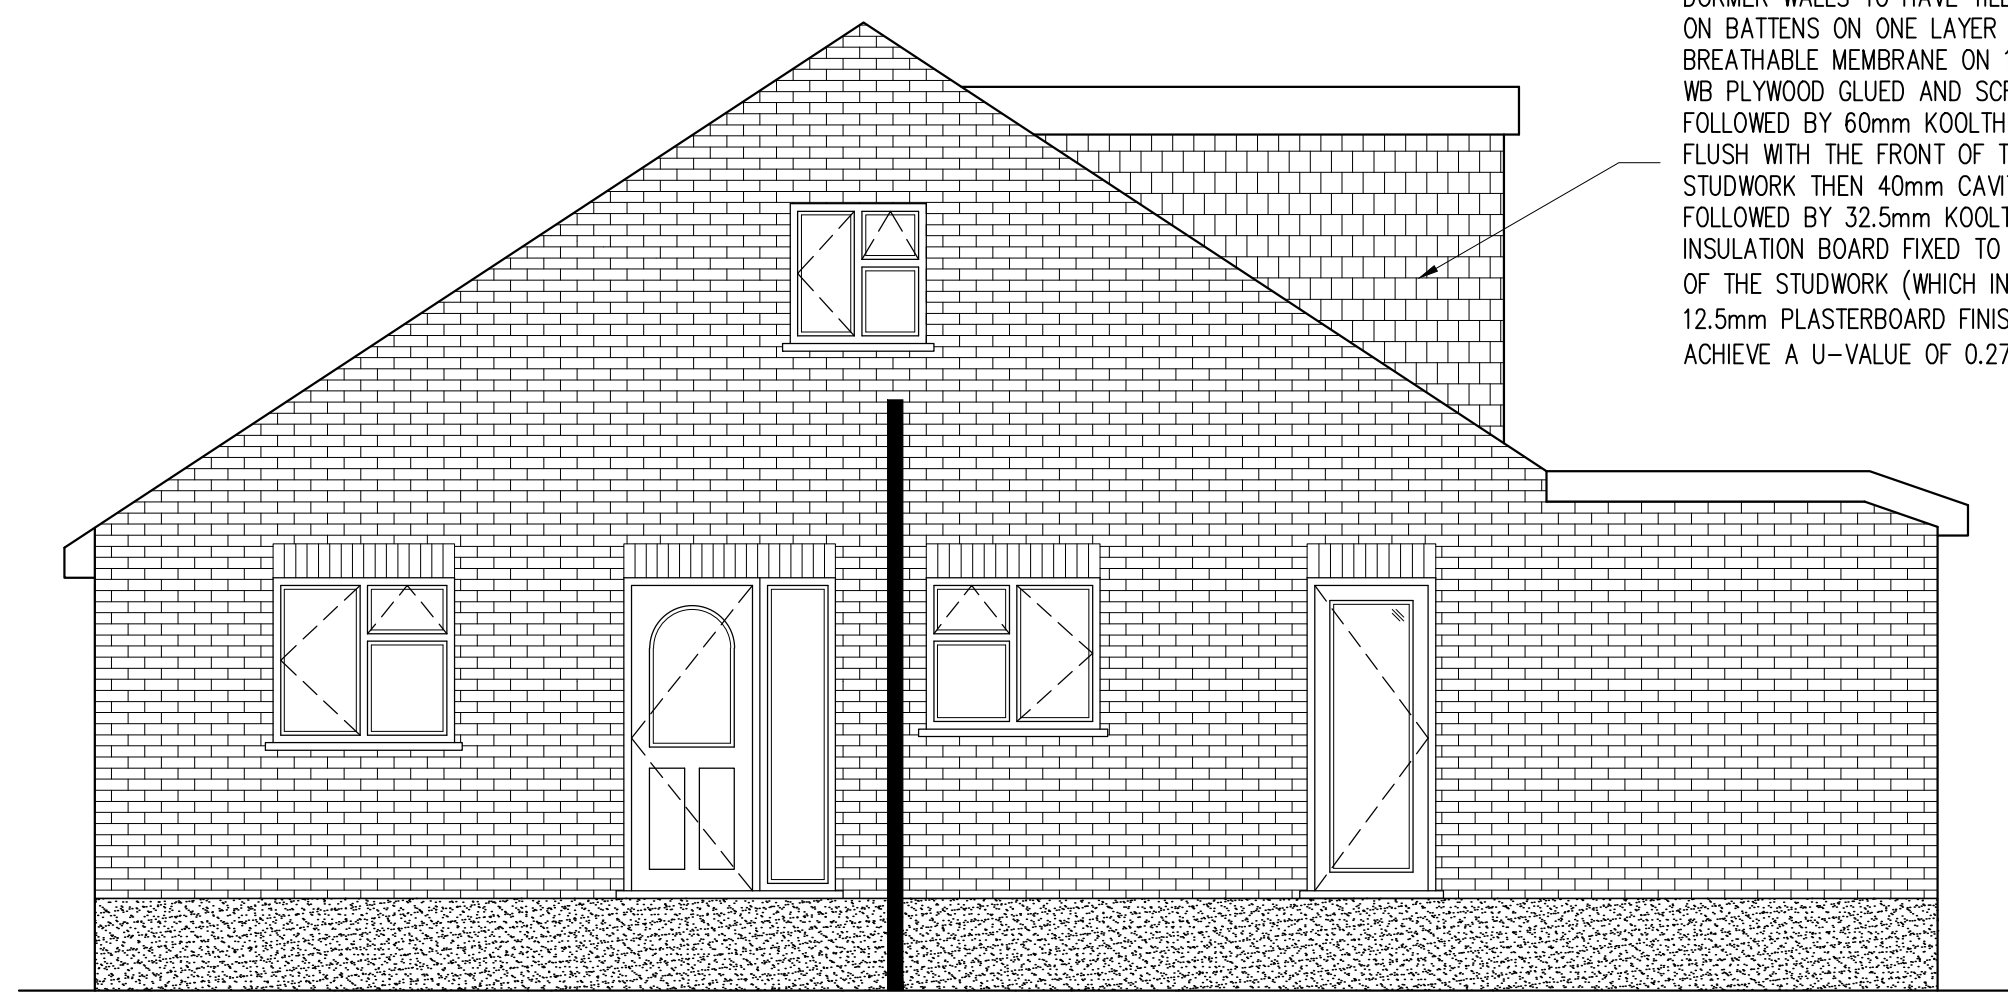


PROPOSED SIDE ELEVATION
SCALE 1:50

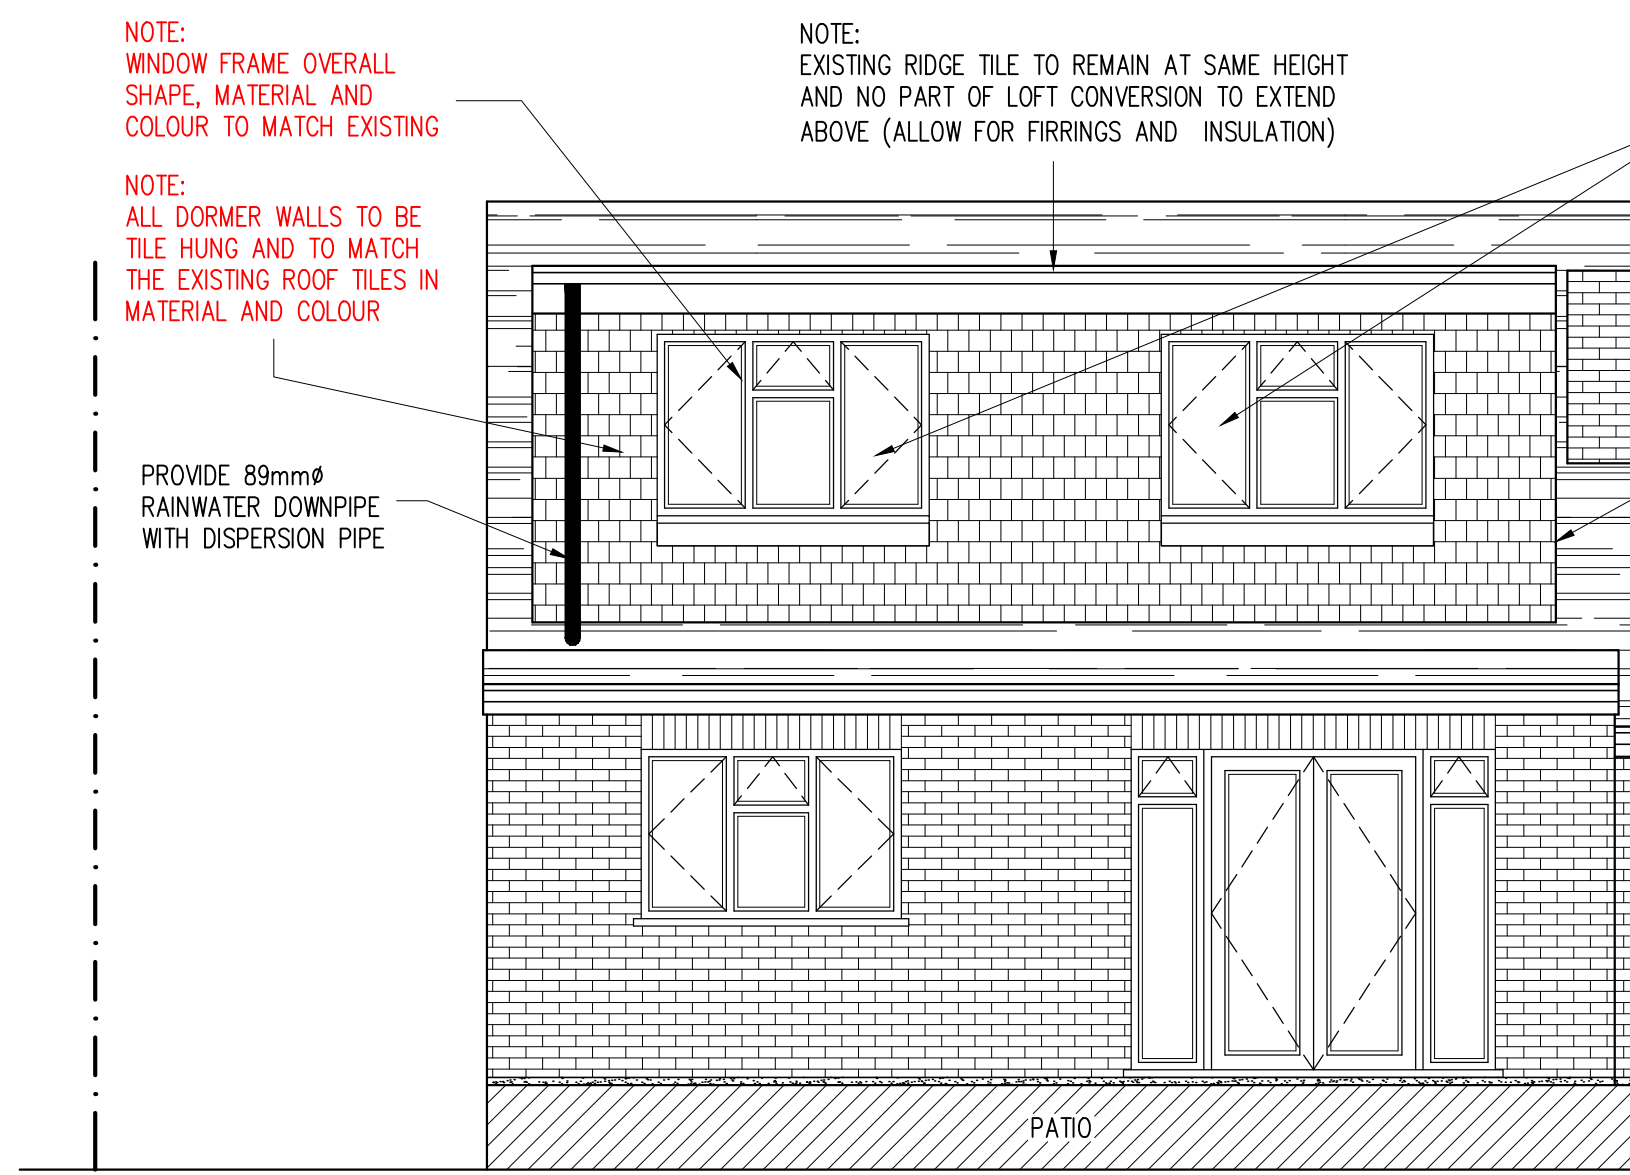

PROPOSED REAR ELEVATION
SCALE 1:50

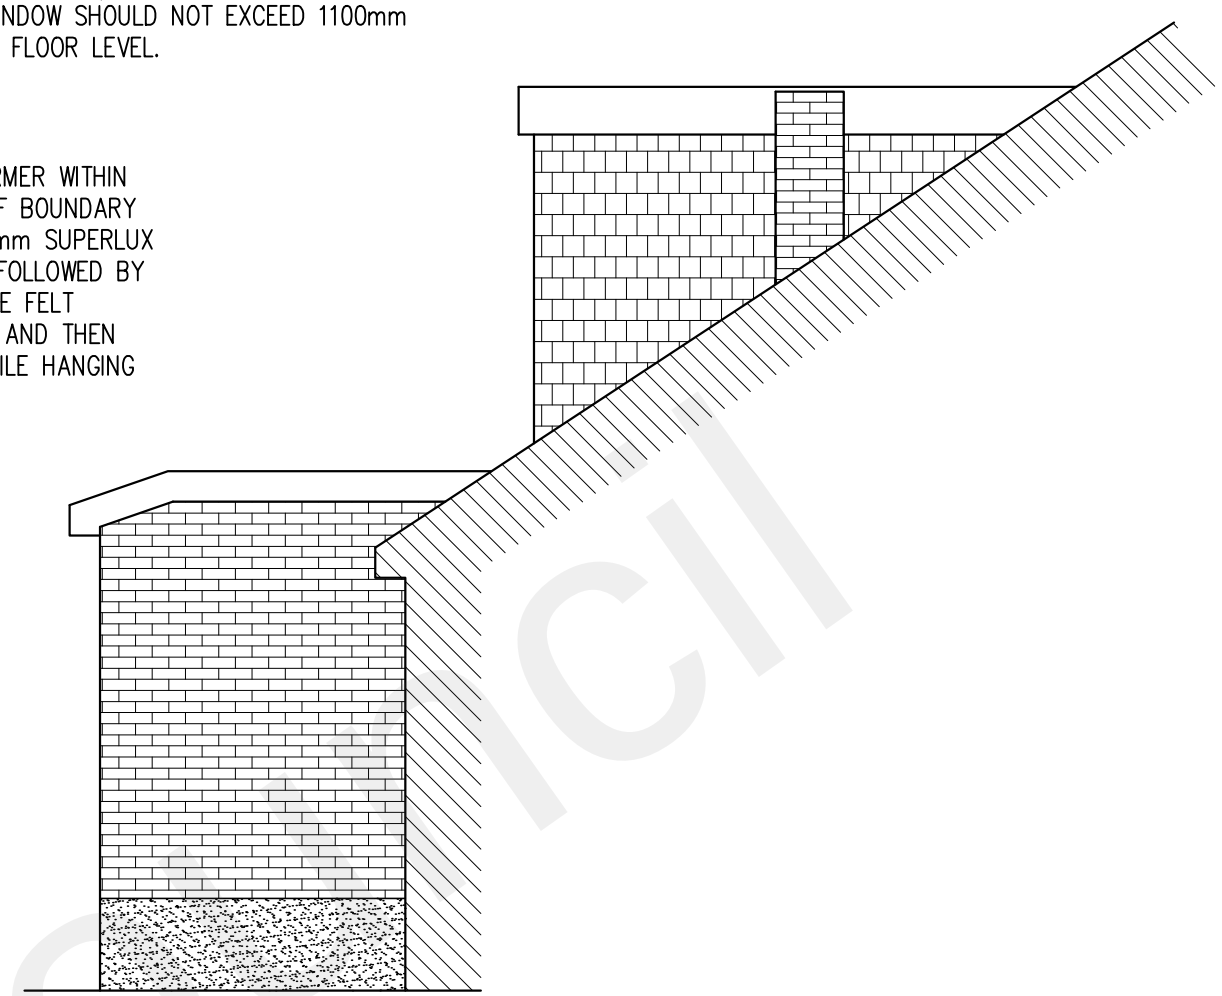

PROPOSED SIDE ELEVATION A
SCALE 1:50

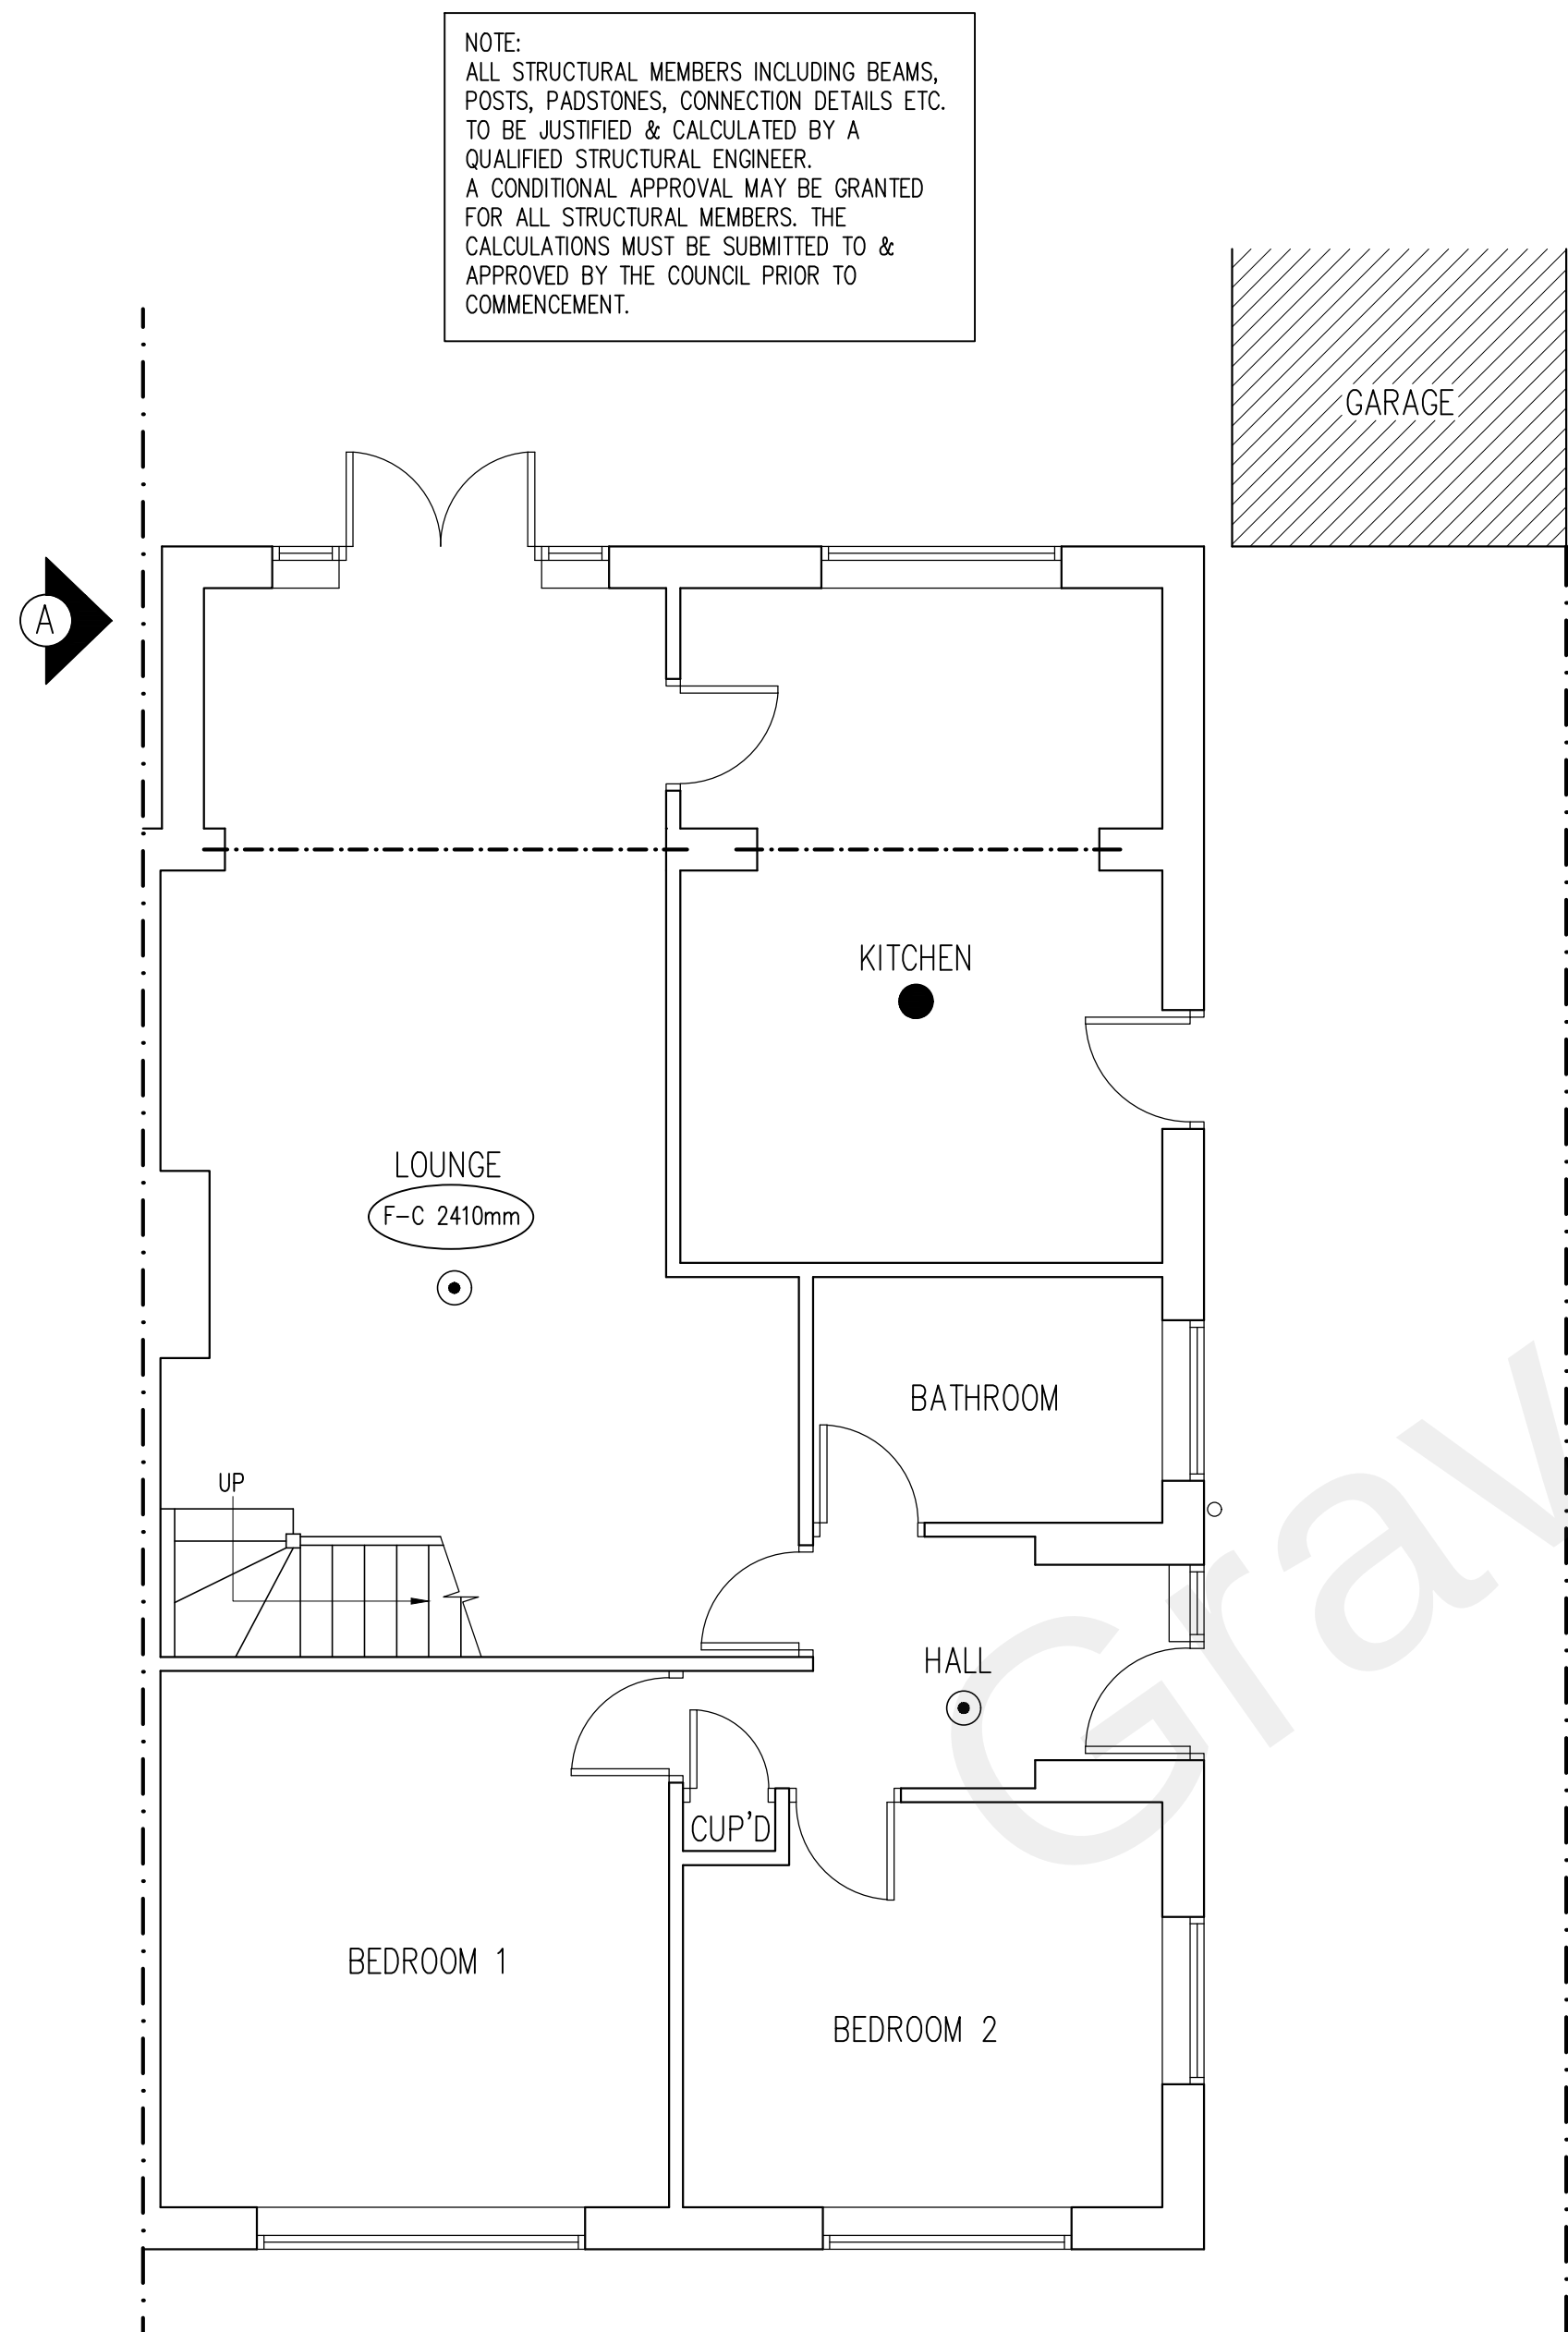

PROPOSED GROUND FLOOR PLAN
SCALE 1:50

A HEAT DETECTOR IS TO BE PROVIDED TO THE KITCHEN IN ACCORDANCE WITH B.S. 5839 PART 1 & 6

SMOKE DETECTORS ARE TO BE INSTALLED AT GROUND AND LOFT FLOOR LEVEL IN THE VICINITY OF THE STAIRCASE CONNECTED TO THE MAINS ELECTRICAL SUPPLY WITH BATTERY BACK UP INTERCONNECTED WITH THE HEAT DETECTOR.


AN INSTALLATION AND COMMISSIONING CERTIFICATE IS REQUIRED IN RESPECT OF THE FIRE ALARM

THE OCCUPIERS SHOULD BE PROVIDED WITH DOCUMENTATION ALLOWING THEM TO USE AND MAINTAIN THE FIRE ALARM


LEGEND

● DENOTES MAINS WIRE LINKED SMOKE ALARMS WITH BATTERY BACK UP AND A SEPARATE FUSE ON THE DISTRIBUTION BOARD


● DENOTES MAINS WIRE LINKED HEAT DETECTOR WITH BATTERY BACK UP AND A SEPARATE FUSE ON THE DISTRIBUTION BOARD

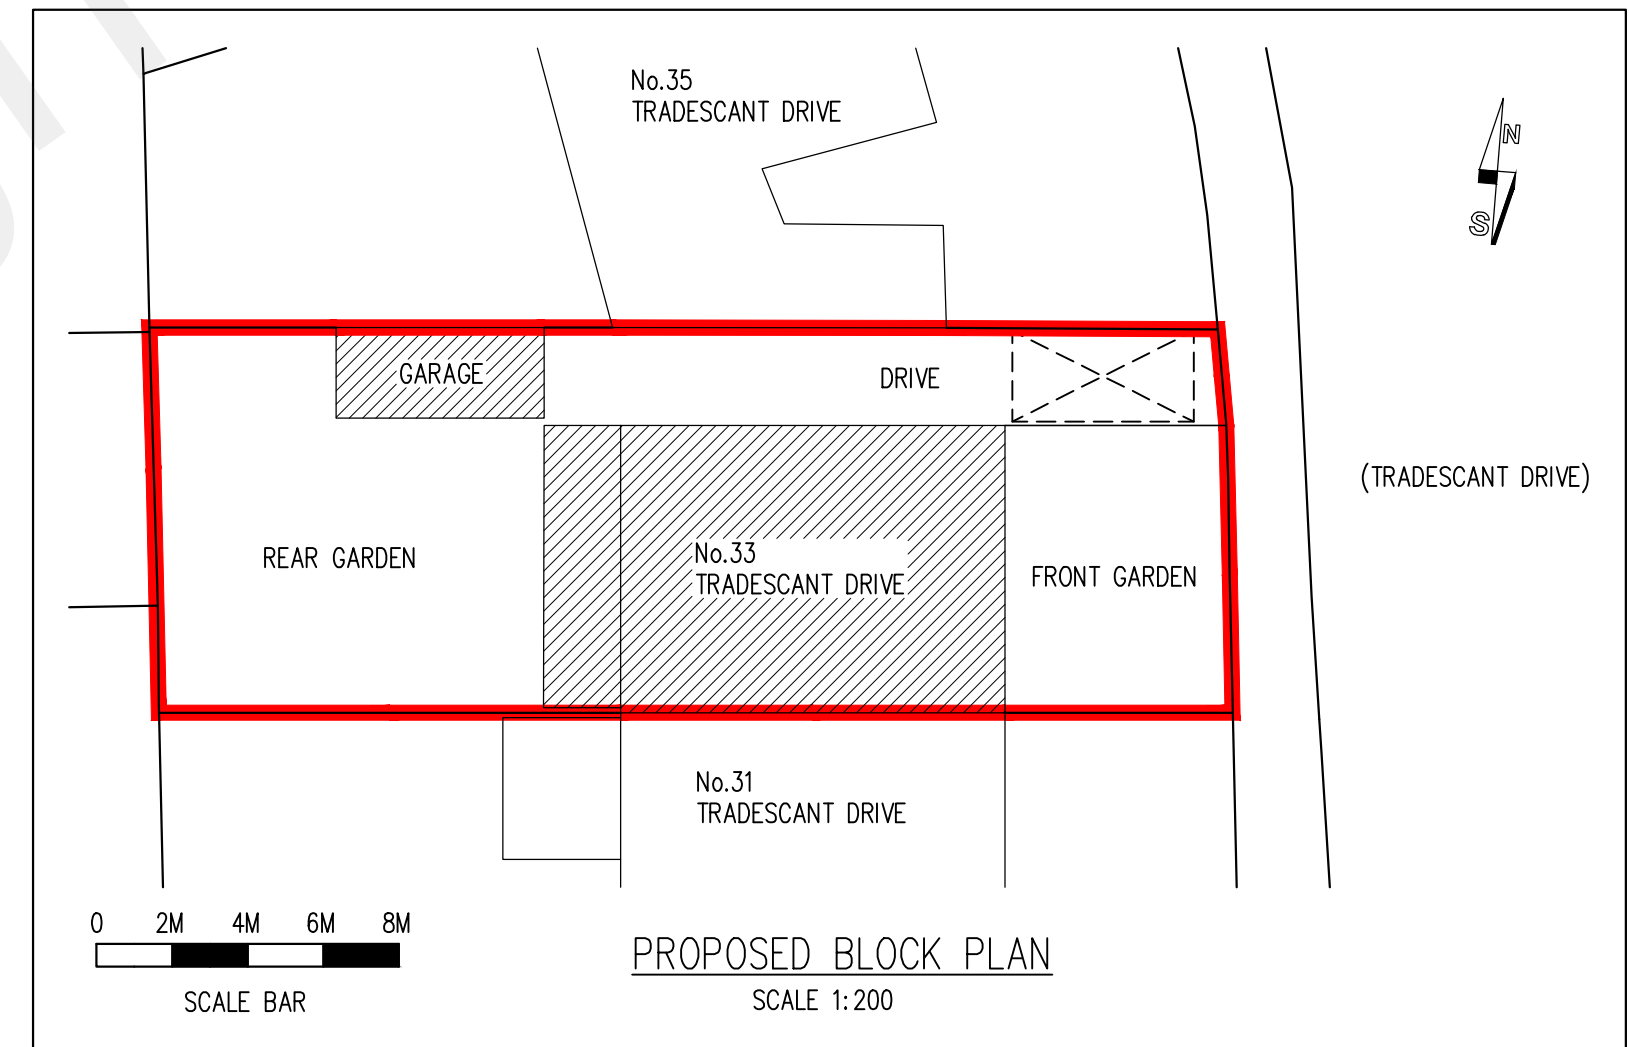


PROPOSED BLOCK PLAN
SCALE 1:200

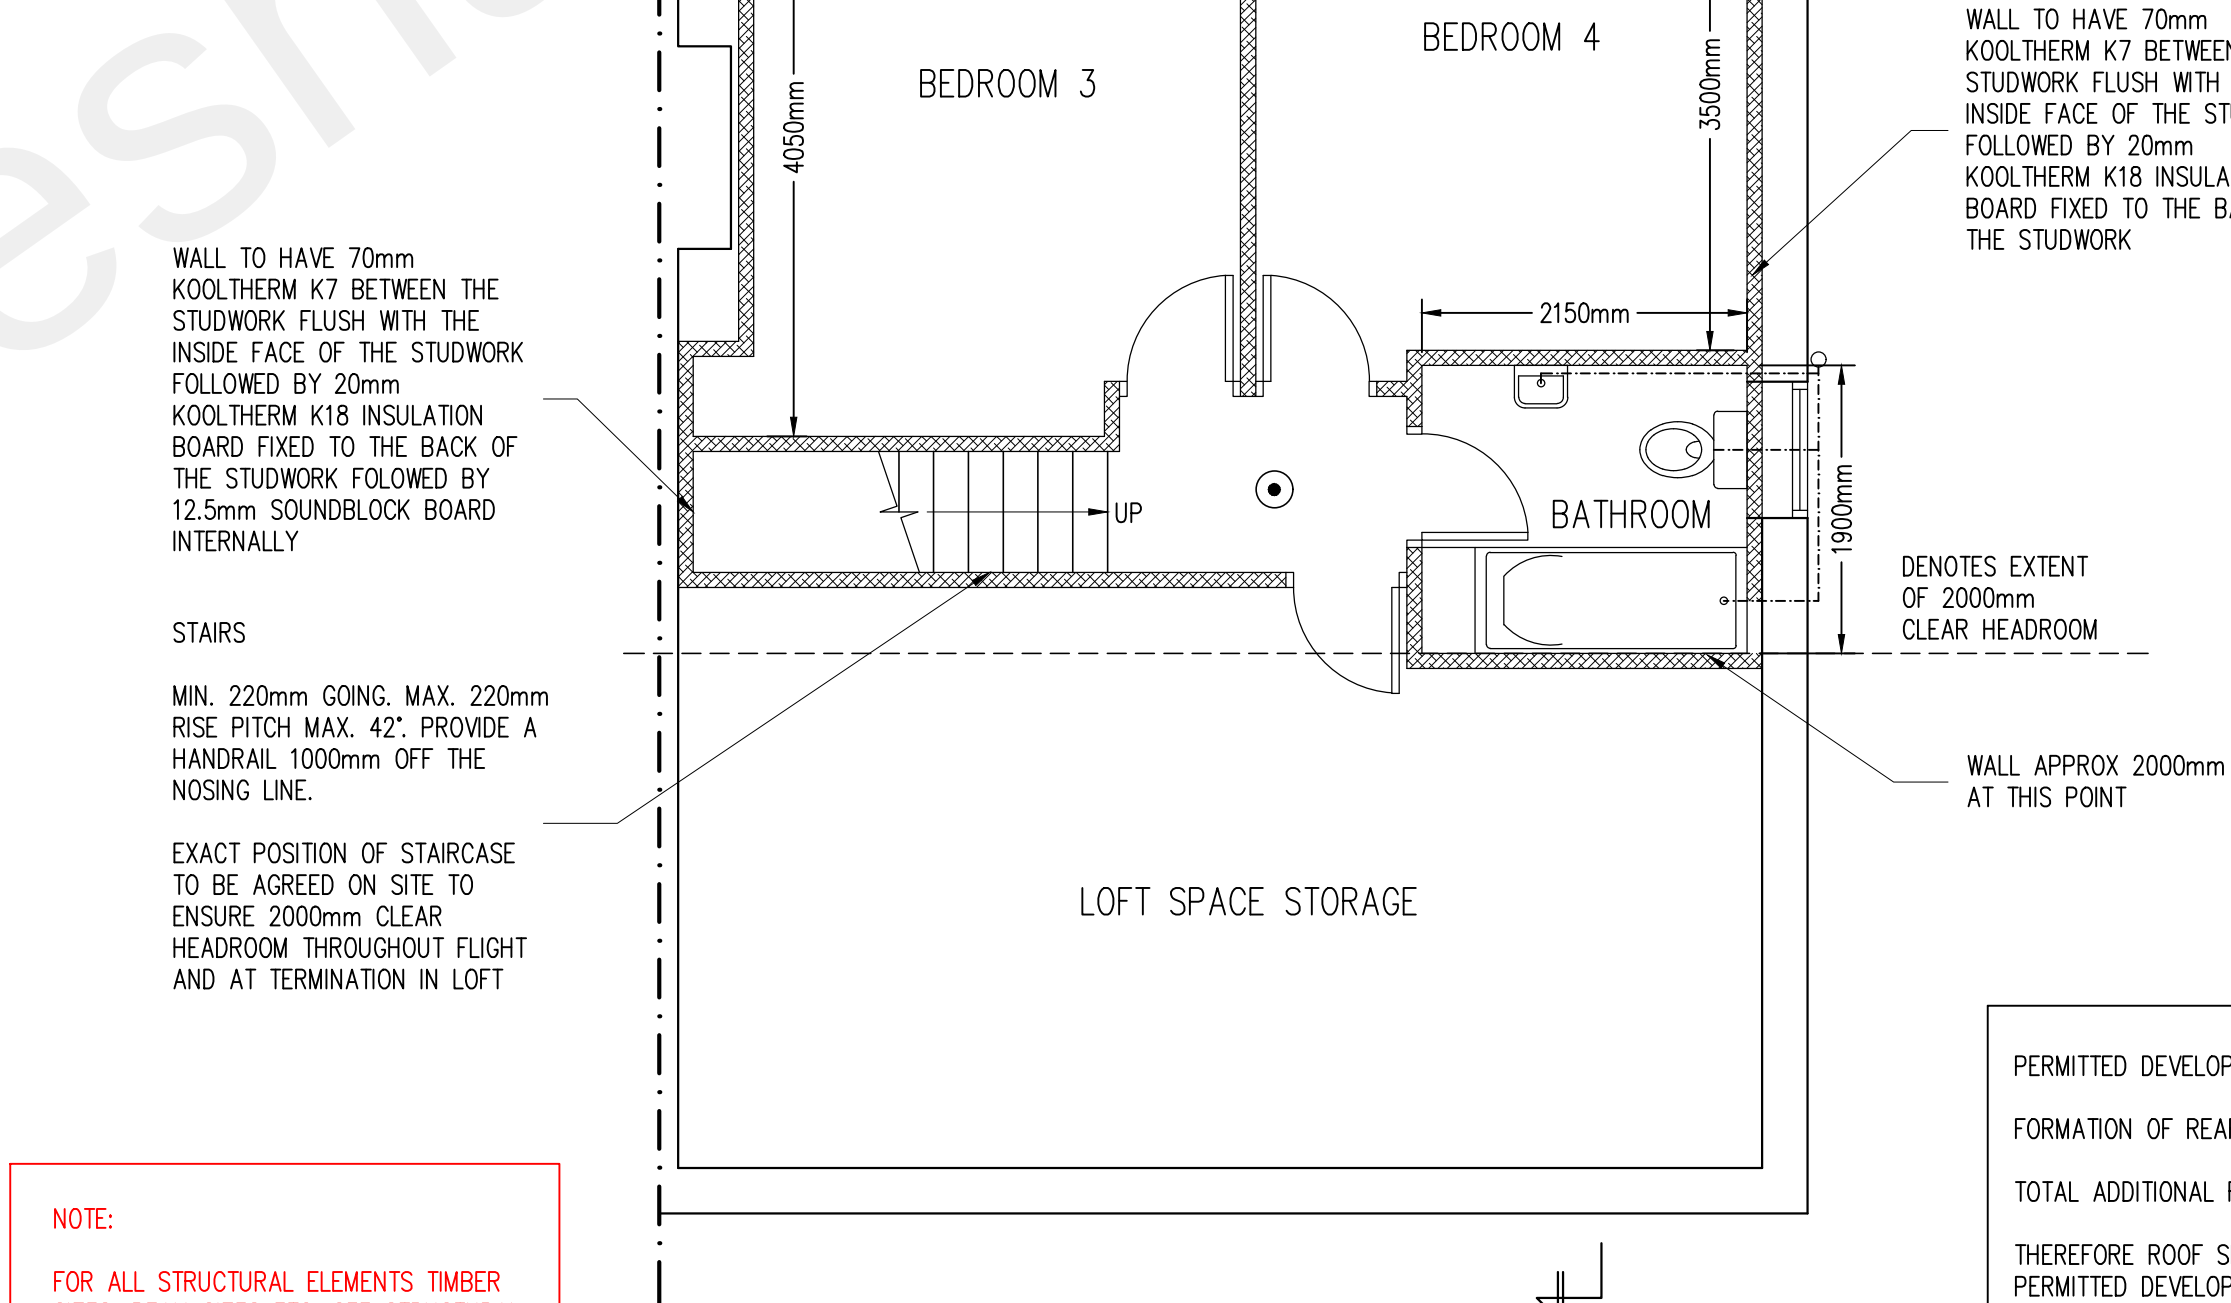

PROPOSED LOFT FLOOR PLAN
SCALE 1:50

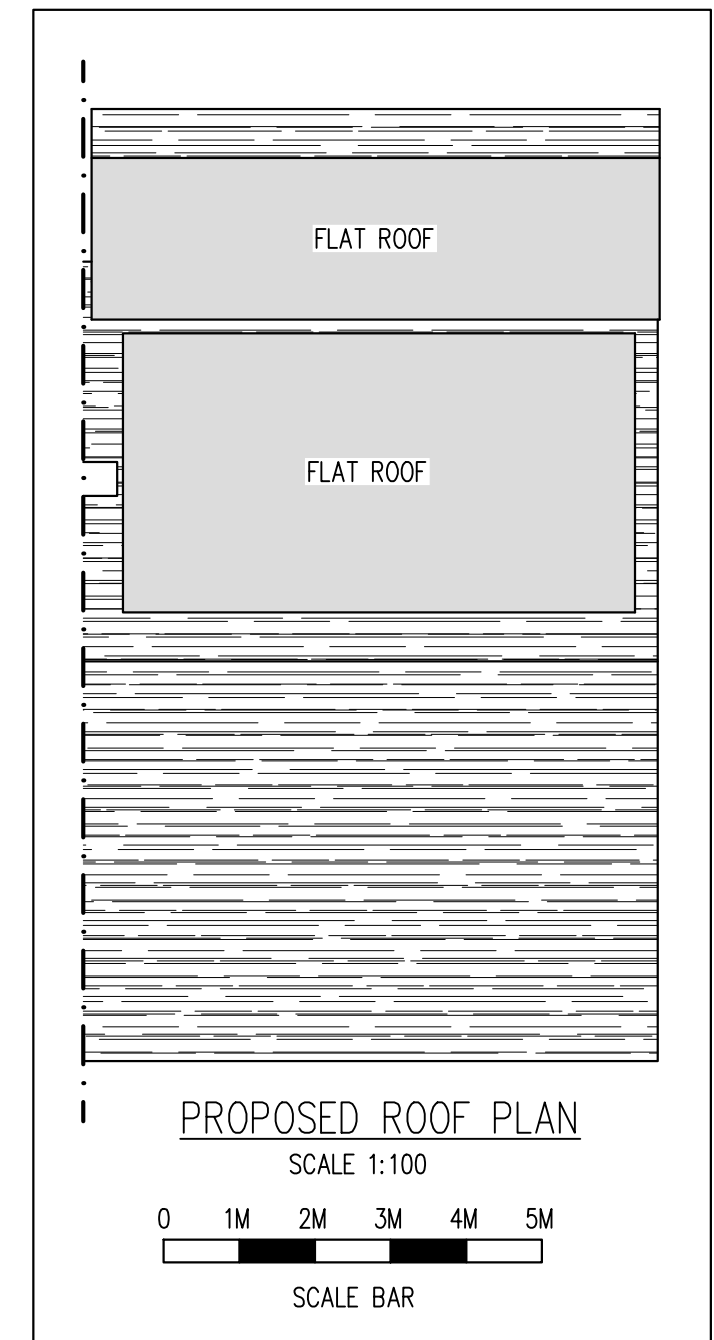

PROPOSED ROOF PLAN
SCALE 1:100

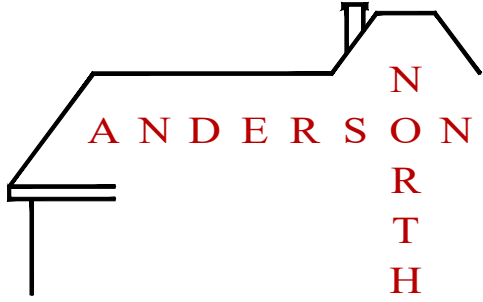C	29/03/22				PLANNING AMENDMENTS
B	17/03/22				PLANNING AMENDMENTS
Rev	Date	By	Chd	Revisions	
Client					
MRS ANNE ANGUS					
Job Title					
PROPOSED LOFT CONVERSION AT 33 TRADESCANT DRIVE MEOPHAM GRAVESEND KENT DA13 0EL					
ARCHITECTURAL CONSULTANTS					
					
ANDERSON NORTH LIMITED					
Glen Lodge Priory Close, East Farleigh Kent ME15 0EY Tel: 01732 522 455 Mob: 07957 627 440					
Scale		Date			
AS SHOWN @ A1		16/12/21			
Drawing Title					
PROPOSED FLOOR PLAN AND ELEVATIONS					
Drawing No.					Rev.
33- TRADESCANT-DRIVE-02					C