



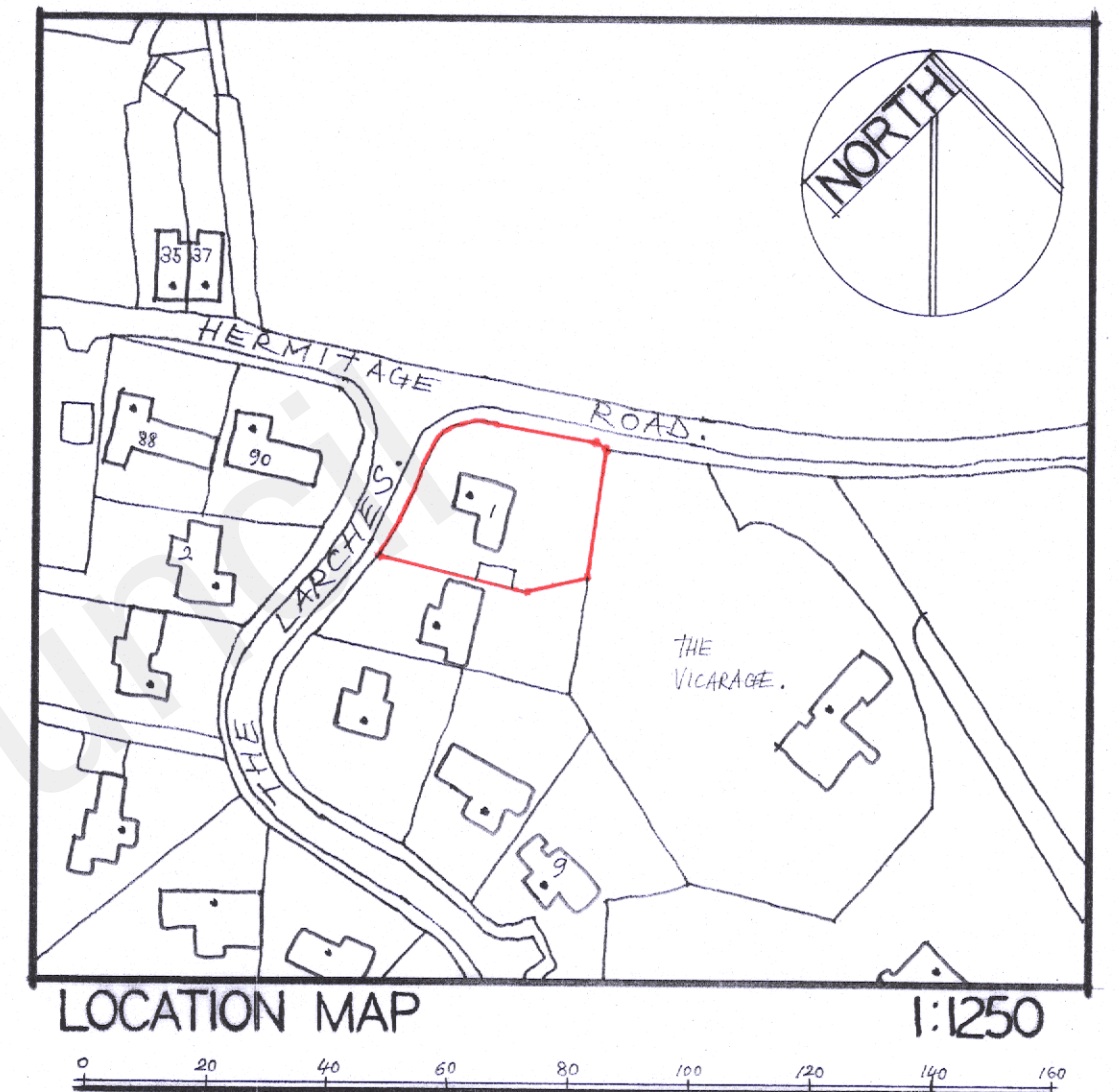


EXISTING GROUND FLOOR PLAN.

SCALE 1:50

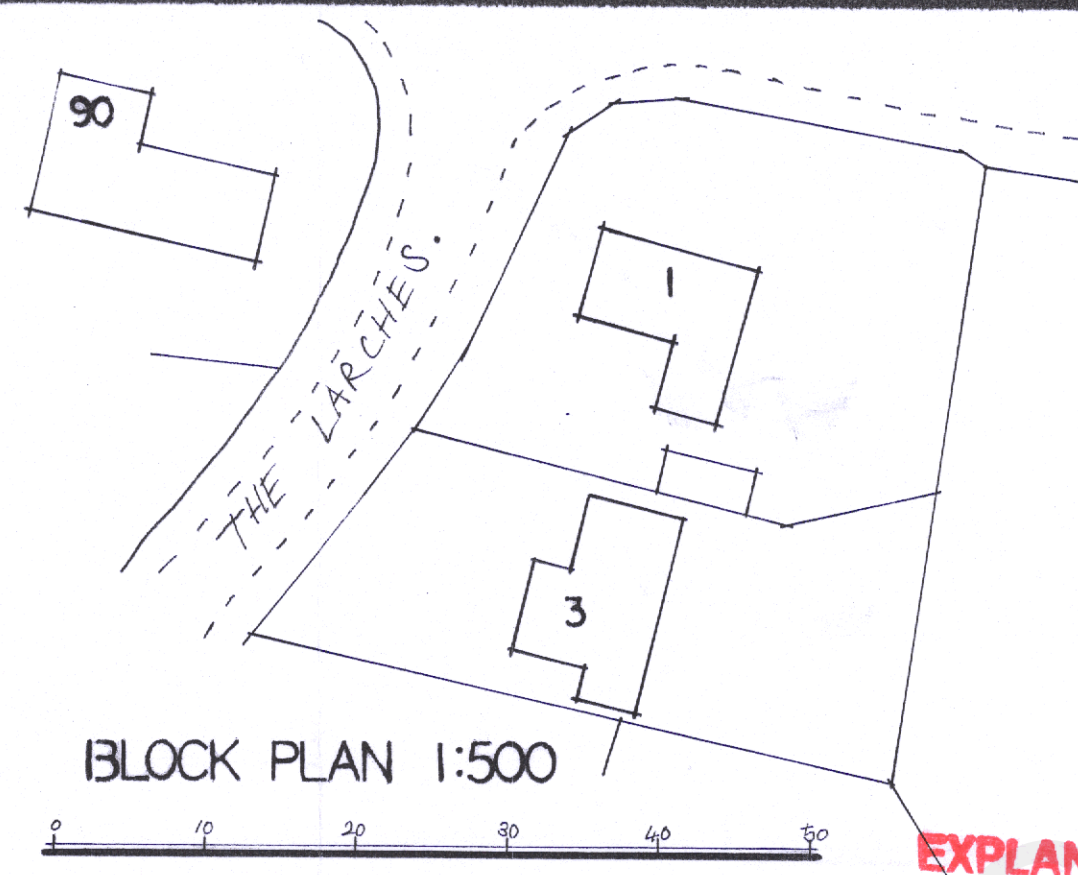

RDP RAINWATER DOWN PIPE.
CB CUPBOARD.
H HEATING DUCT.
GM GAS METER.
CU CONSUMER UNIT.
SVP SOIL VENT PIPE.

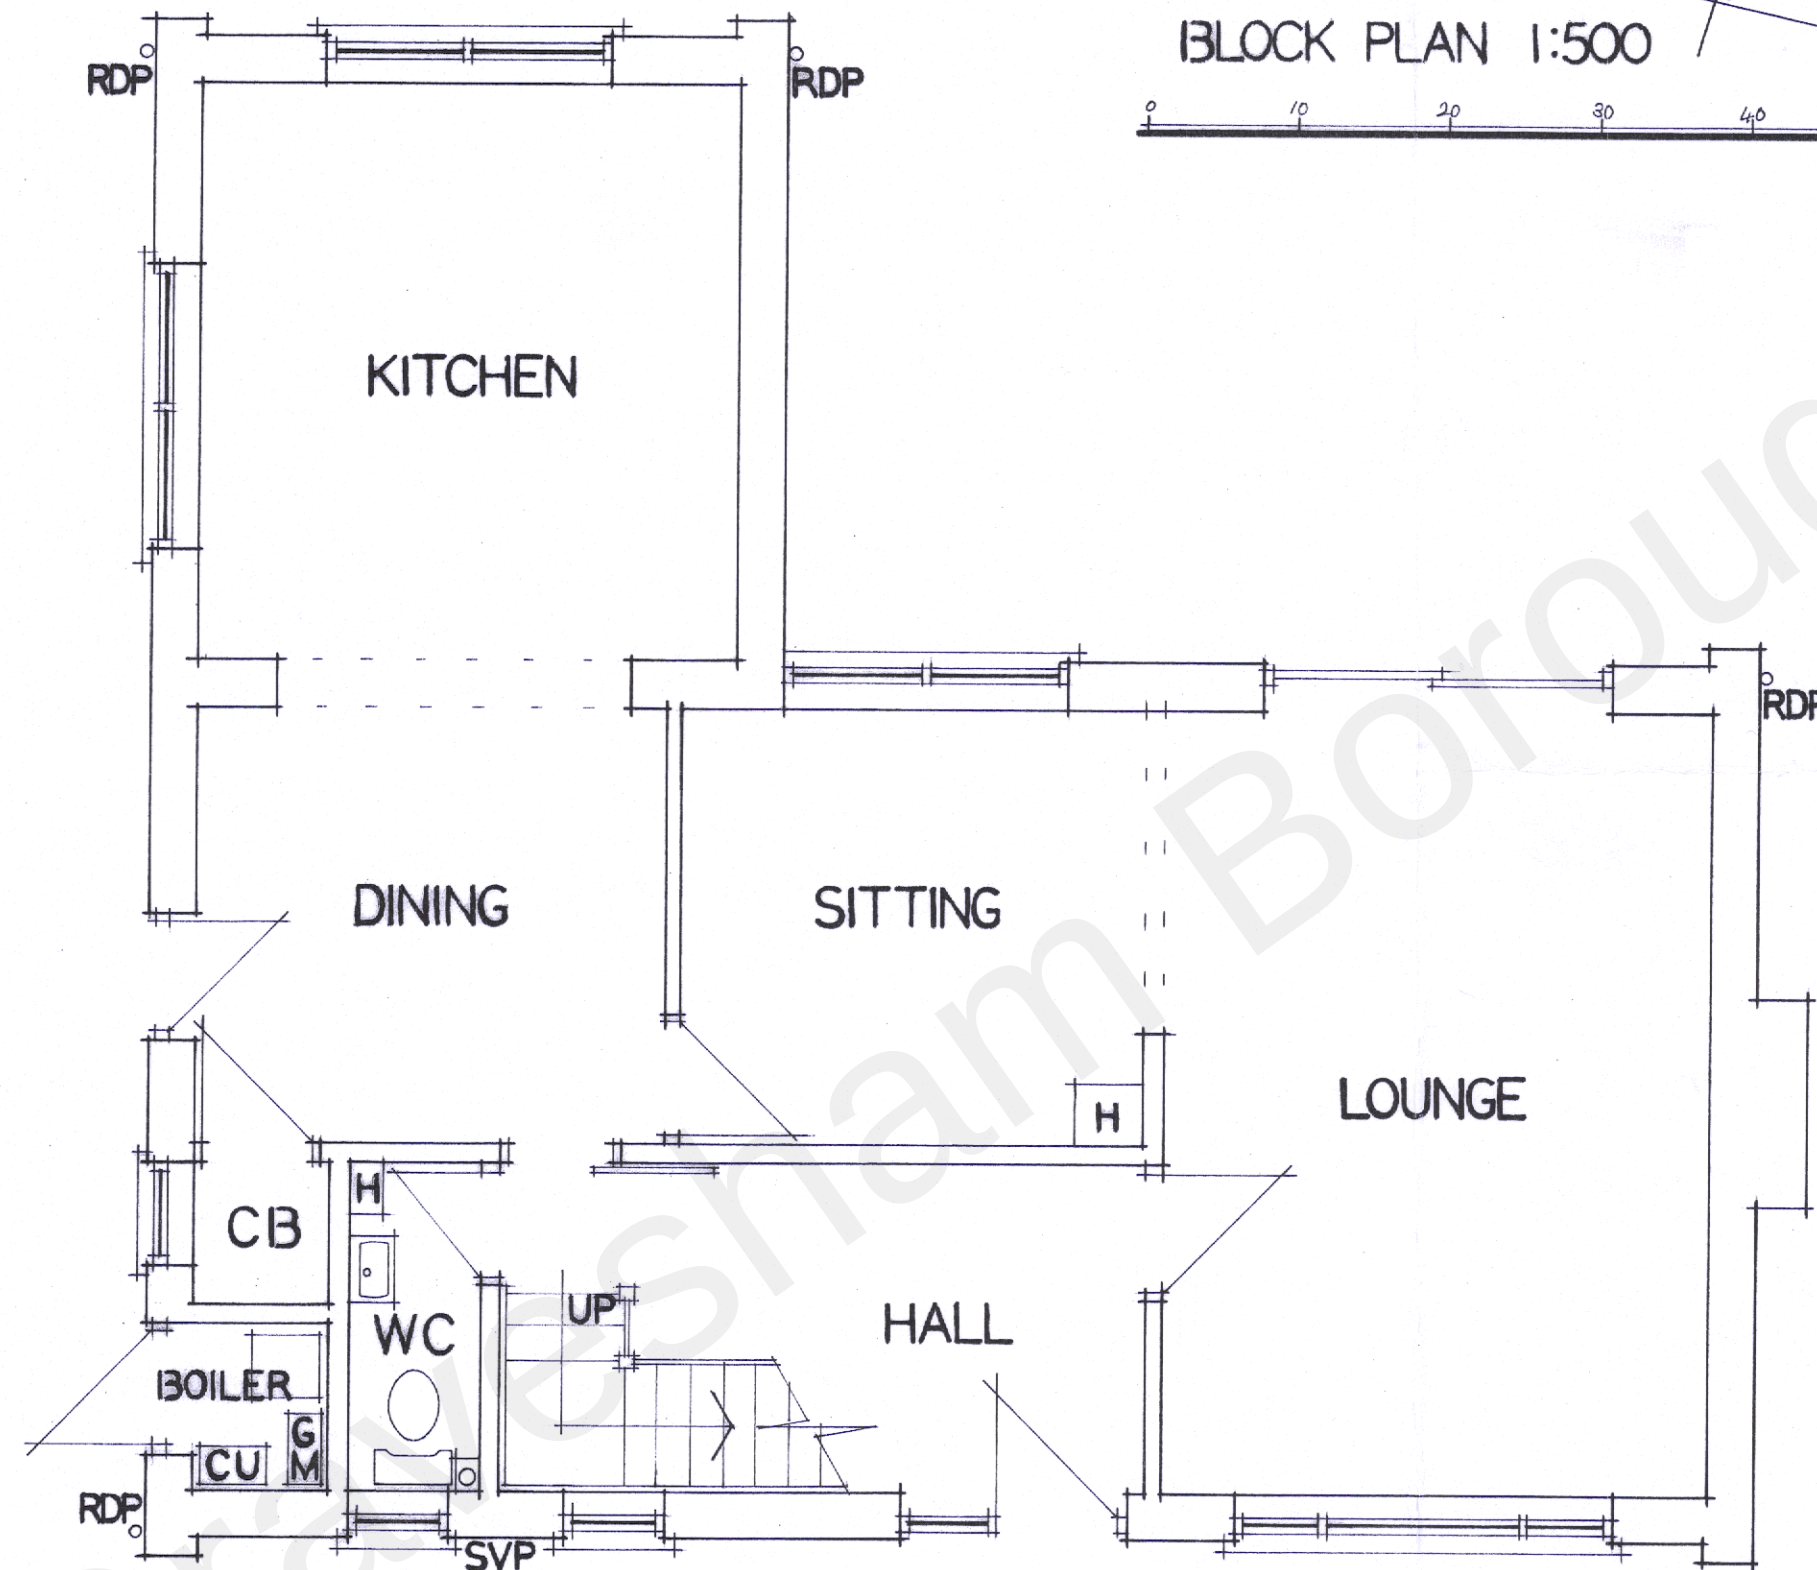

20211098

RECEIVED

-2 SEP 2021

PROJECT.

1 THE LARCHES
HIGHAM
ROCHESTER
KENT
ME3 7NQ.

CLIENT.

MR & MRS D. CORCORAN.

PROPOSED TITLE.

GROUND FLOOR EXTENSION
TO REAR ELEVATION. MONO
PITCH ROOF IN DESIGN.

SCALE. 1:50.

AI

DRAWN BY. D. CHAMBERLAN.

01795 876 412

07711 848 334

DATE. AUGUST 2021.

DRAWING N°. DC/744.

E: DAVEDEVADESIGN @ GMAIL.COM