

- KEY
- HP

FIRE HYDRANT POINT (DOUBLE)

HP

FIRE HYDRANT POINT (SINGLE)

HP

HYDRANT POINT (Mains Network)

HP


HYDRANT POINT (Removed)

MAIN ISOLATING VALVES (2)

FIRE MAIN

FIRE MAIN (Mains Network)

2g

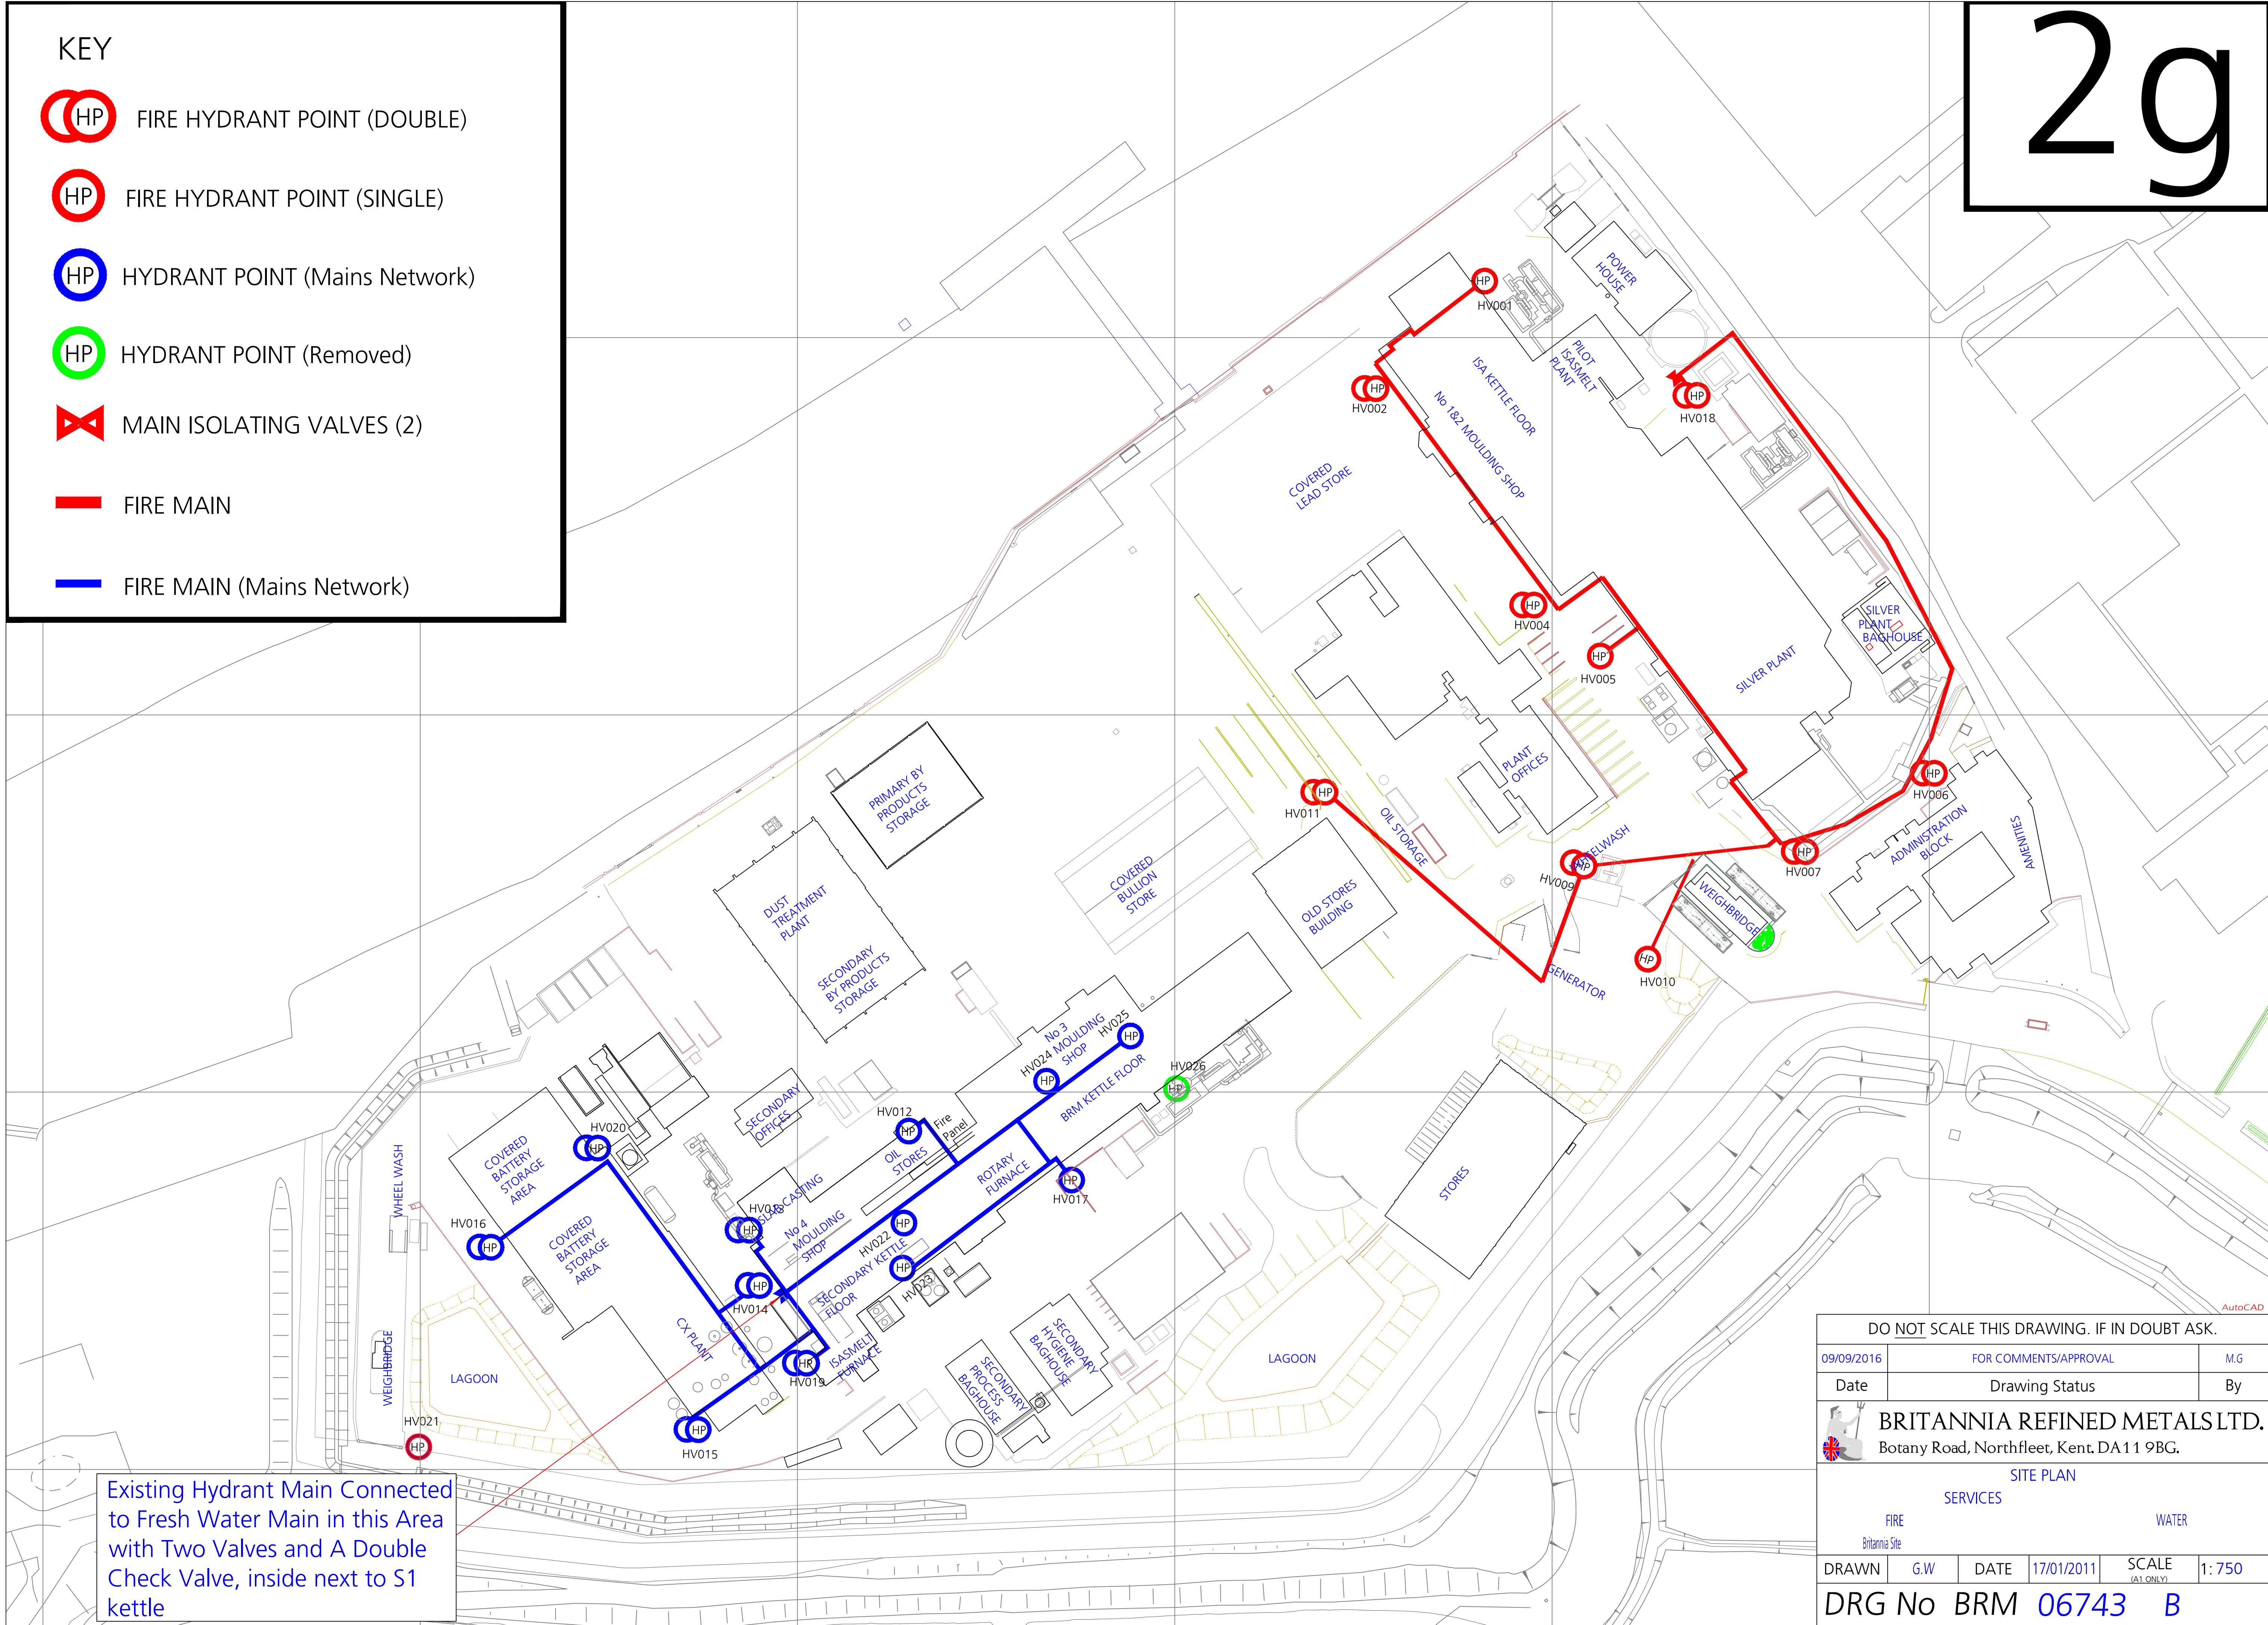

Existing Hydrant Main Connected to Fresh Water Main in this Area with Two Valves and A Double Check Valve, inside next to S1 kettle

DO NOT SCALE THIS DRAWING. IF IN DOUBT ASK.			
09/09/2016	FOR COMMENTS/APPROVAL		M.G
Date	Drawing Status		By
 BRITANNIA REFINED METALS LTD. Botany Road, Northfleet, Kent. DA11 9BG.			
SITE PLAN			
SERVICES		WATER	
FIRE			
Britannia Site			
DRAWN	G.W	DATE	17/01/2011
		SCALE	1: 750
		(A1 ONLY)	
DRG No BRM 06743 B			