

 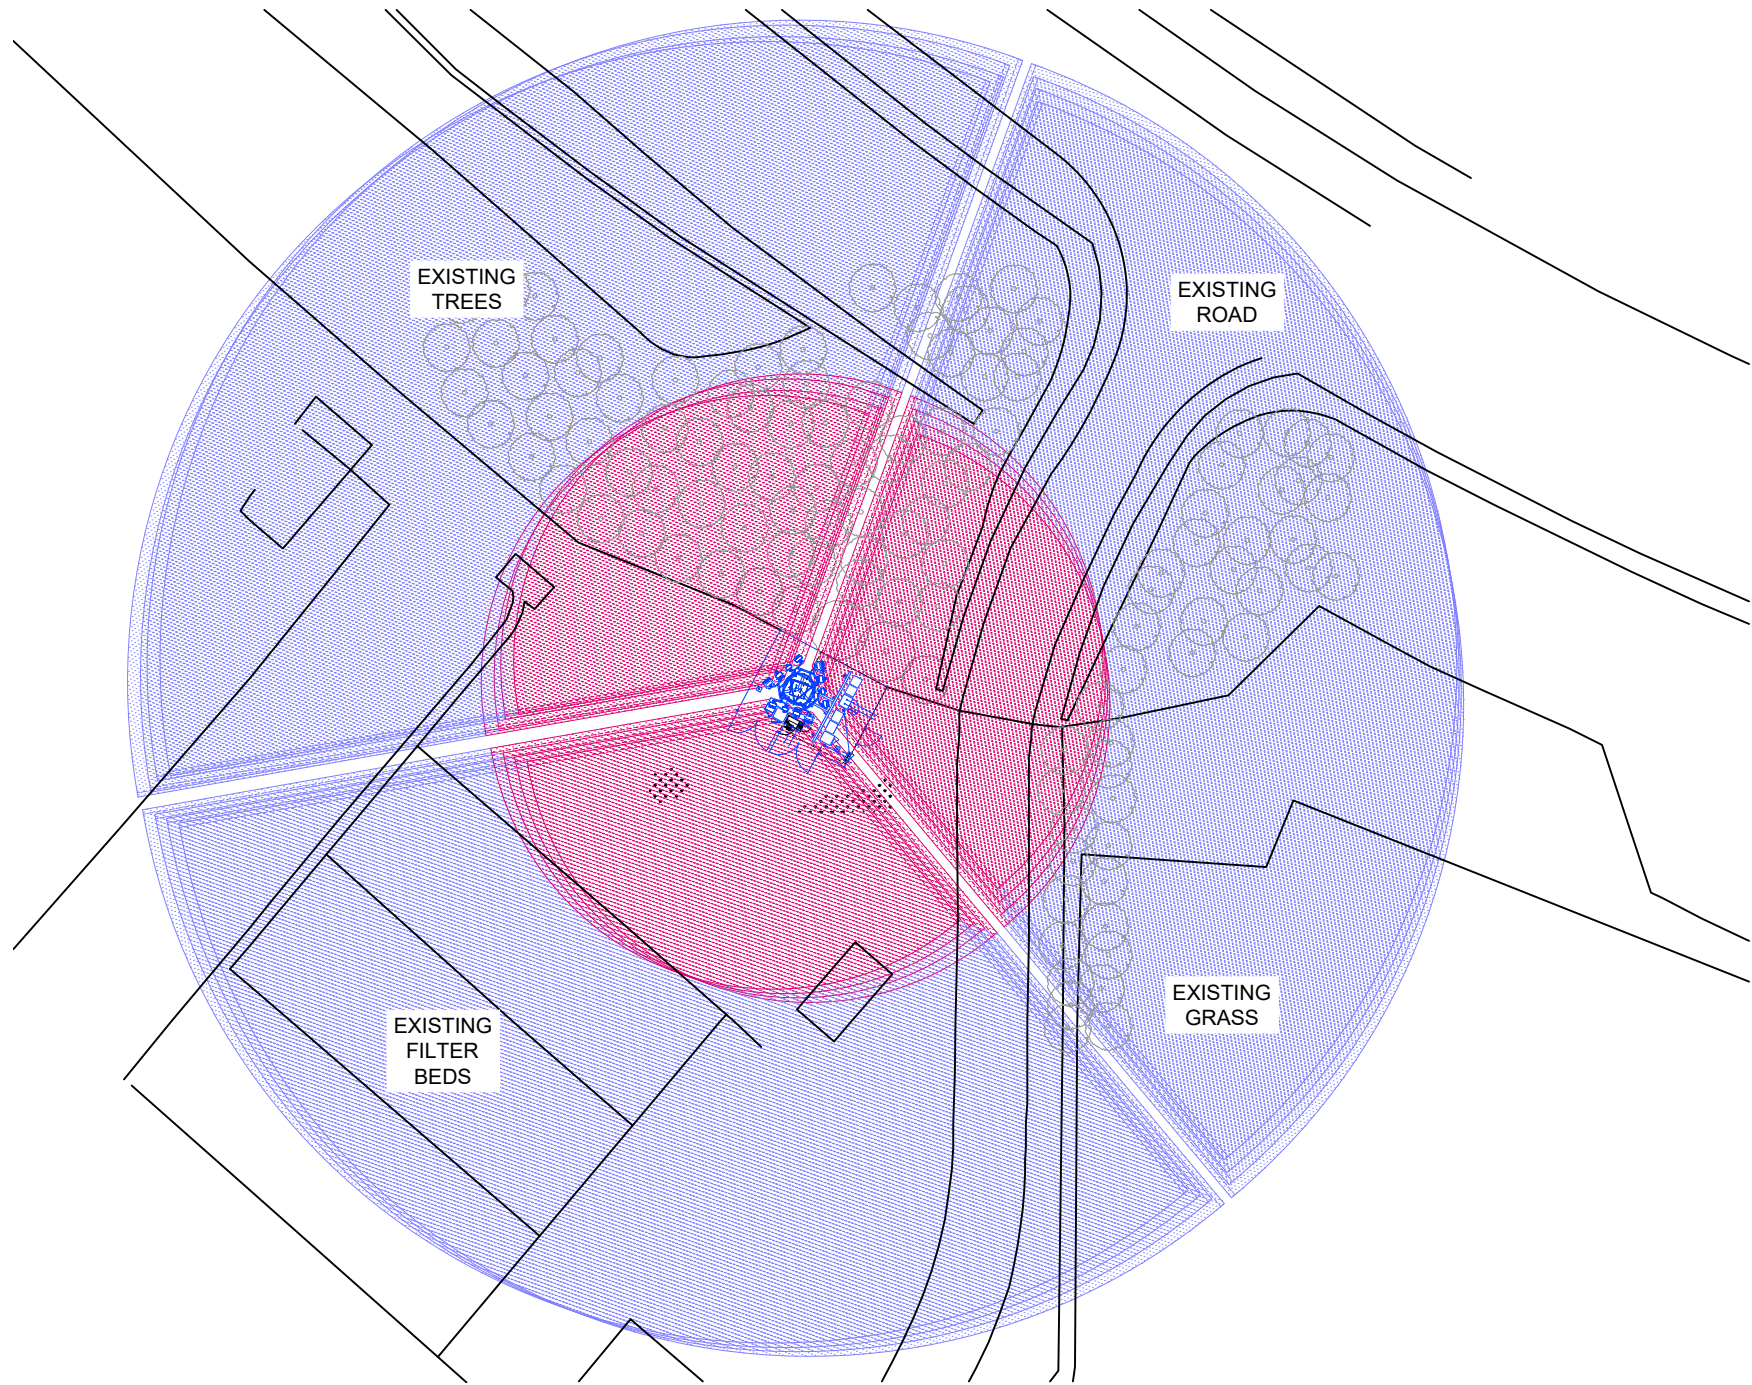


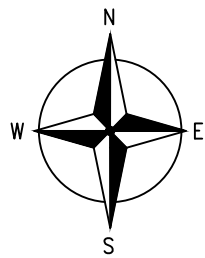

NOTE: ALL EVALUATION & RESULTING MODELING HAS BEEN UNDERTAKEN UTILISING ALL TECHNOLOGIES CAPABLE OF BEING OPERATED THROUGH THE CHOSEN ANTENNA SOLUTION ON THE DATE OF PRODUCTION & CALCULATED TO ACHIEVE MAXIMUM POWER OUTPUT FOR EACH TECHNOLOGY WITHIN WIG OPERATIONAL GUIDELINES

ICNIRP SITE PLAN



ALL DIMENSIONS ARE IN mm UNLESS NOTED OTHERWISE

N.G.R	E 562040	N 173520
-------	----------	----------

NOMINATION REFERENCE: N/A

CONCESSION/FIXIT REQUIRED?	☒ YES	☐ NO
----------------------------	---	-----------------------------

REASON FOR CONCESSION/FIXIT:

-

ICNIRP DETAILS

IN ACCORDANCE WITH OPERATOR SPECIFIC ICNIRP GUIDELINES

SITE DESIGN CATEGORY	PUBLIC ACCESS
----------------------	---------------

ICNIRP CONTROL MEASURE (IF REQUIRED):

NO CONTROL MEASURES REQUIRED

DEPENDENCIES FOR DETAILED DESIGN/BUILD

ASBESTOS SURVEY	☒	NO
CHERRY PICKER SURVEY	☒	NO
COMMS SERVICE ALTERATION	☒	NO
GDC/STRUCTURAL CALCULATIONS	YES	☒
GEOTECH AND/OR TRIAL DIG	YES	☒
ICNIRP CONTROL MEASURES	☒	NO
INTRUSIVE SURVEY	☒	NO
MEWP/SCAFFOLD REQUIREMENTS	☒	NO
REC SERVICE ALTERATION	YES	☒
STAT SEARCHES	YES	☒
GPRS REQUIREMENT	☒	NO
TENSILE PROOF TESTS	☒	NO
TOWER CLIMB	☒	NO

COLOUR CHART

BLACK	TEXT, EXISTING BUILDINGS, TOWERS, STRUCTURES, TREES, ETC.
BLUE	PROPOSED INSTALLATION

F	AMENDED TO SUIT DAF 23/07/24	DP	MC	09.08.2024
E	ERS DETAILS CORRECTED	DP	MC	15.07.2024
D	AMENDED TO SUIT DAF 04/03/24	DP	MC	23.04.2024
C	MINOR AMENDS	DM	DP	15.02.2024
B	MINOR AMENDS	NM	RL	24.07.2023
REV	DESCRIPTION OF REVISION	BY	CH	DATE

DESIGN CONSULTANT	WIG PROJECT NUMBER
TELENT	CTIL-C-SWS0063-3-UPGRADE



TEF	CTIL	VF
067713	13776925	37177_16

SITE NAME AND ADDRESS

NORTHFLEET WTW
SPRINGFIELD GROVE
THAMES WAY
GRAVESEND - KENT
DA11 8HN

DRAWING TITLE:

ICNIRP PLAN

PURPOSE OF ISSUE:

CONSTRUCTION

DRAWING NUMBER:

200

SCALE:	DRAWN:	DATE:	REV:
AS SHOWN @ A3	RN	03.12.2020	F
CHECKED:	DATE:	APPROVED:	DATE:
DP	03.12.2020	DP	03.12.2020