


TYPE D - TYPICAL INSPECTION CHAMBER DETAIL
FIGURE B 18 SEWERAGE SECTOR GUIDANCE APPENDIX C - 'THE CODE'
DEPTH FROM COVER LEVEL TO SOFFIT OF PIPE UP TO 3m
FLEXIBLE MATERIAL CONSTRUCTION FOR USE IN AREAS SUBJECT TO VEHICLE LOADING


PLASTIC CHAMBERS AND RINGS SHALL COMPLY WITH CLAUSE E2.31

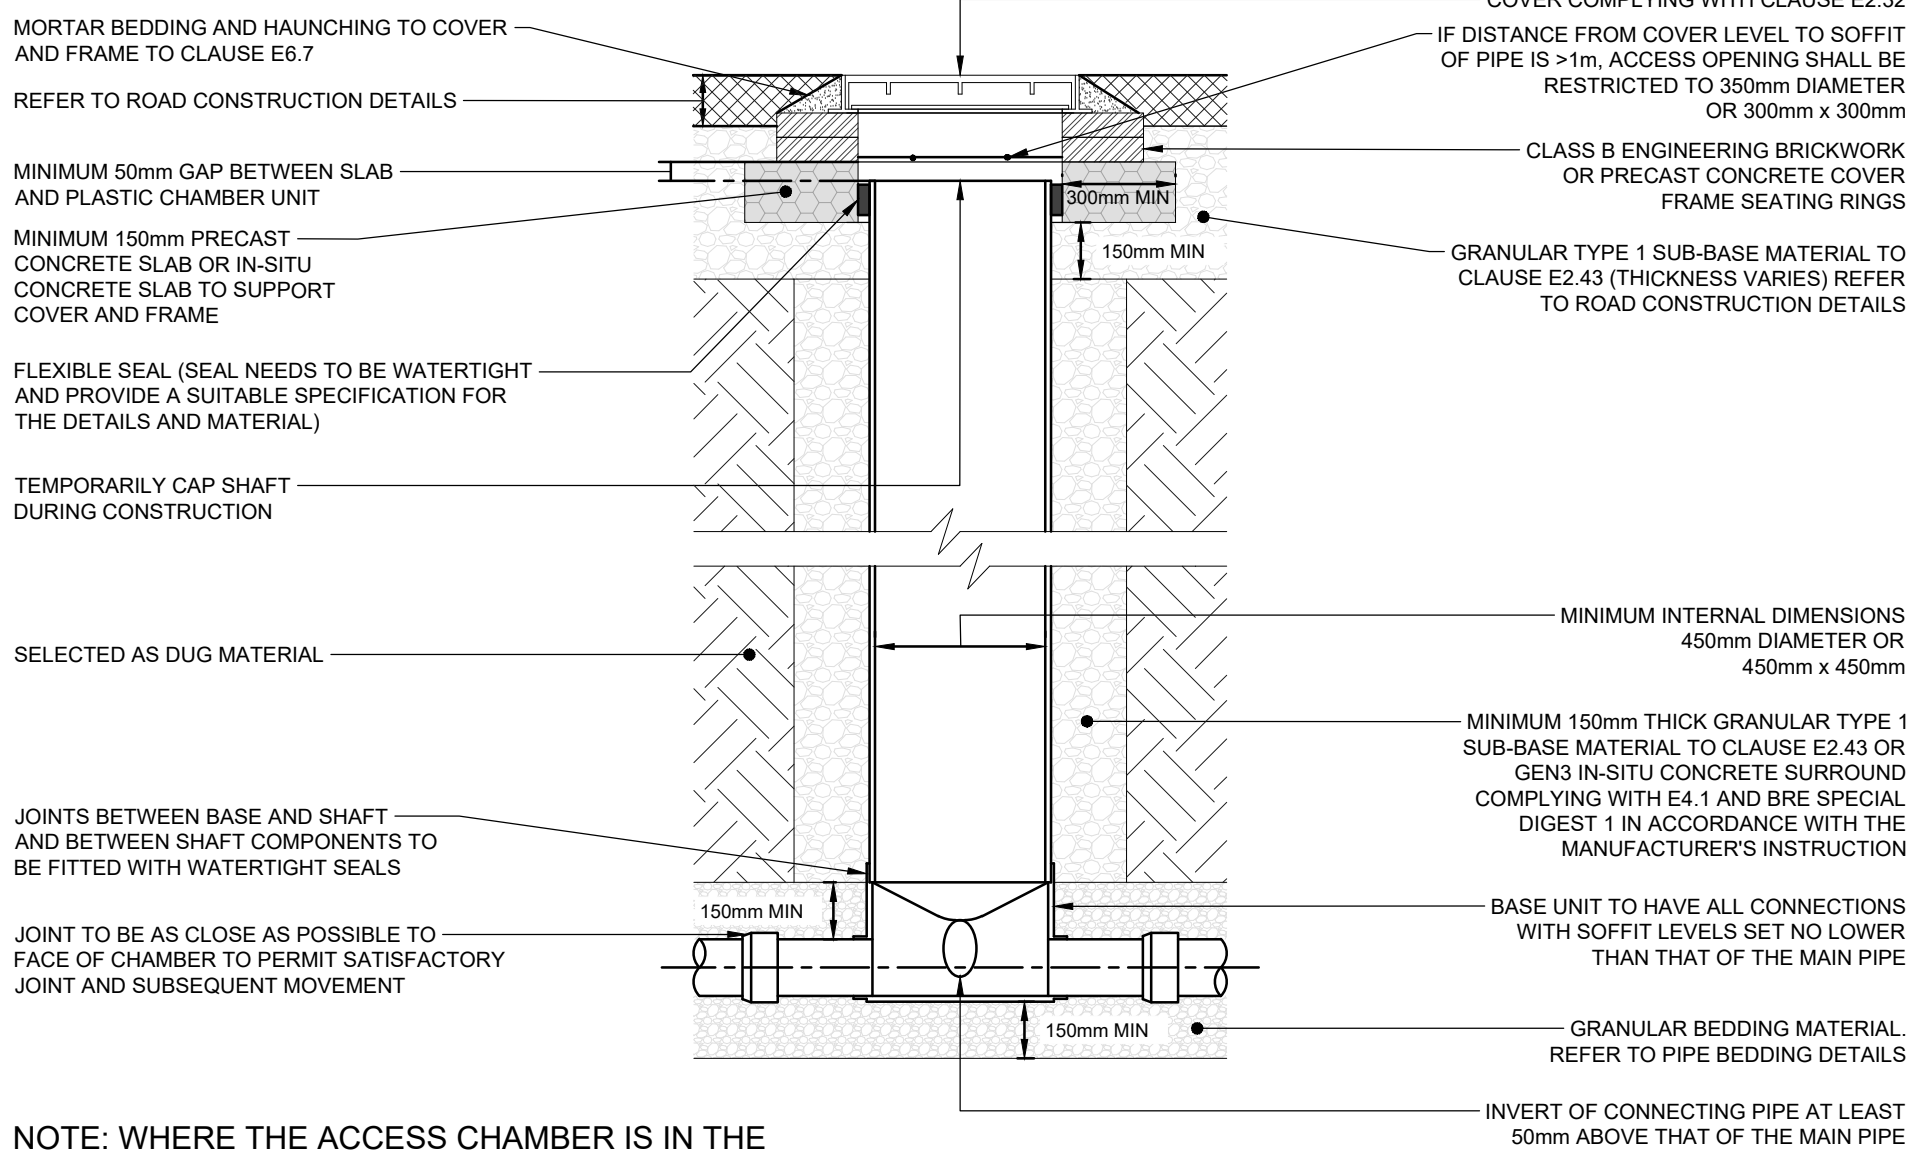


NOTE: WHERE THE ACCESS CHAMBER IS IN THE HIGHWAY (INCLUDING ANY FOOTWAY), THE HIGHWAY AUTHORITY CAN HAVE SPECIFIC REQUIREMENTS.

TYPE D - TYPICAL INSPECTION CHAMBER DETAIL
FIGURE B 19 SEWERAGE SECTOR GUIDANCE APPENDIX C - 'THE CODE'
FLEXIBLE MATERIAL CONSTRUCTION ALTERNATIVE TOP DETAILS FOR USE IN AREAS OF LIGHT VEHICLE LOADING OR LANDSCAPED AREAS

PLASTIC CHAMBERS AND RINGS SHALL COMPLY WITH CLAUSE E2.31



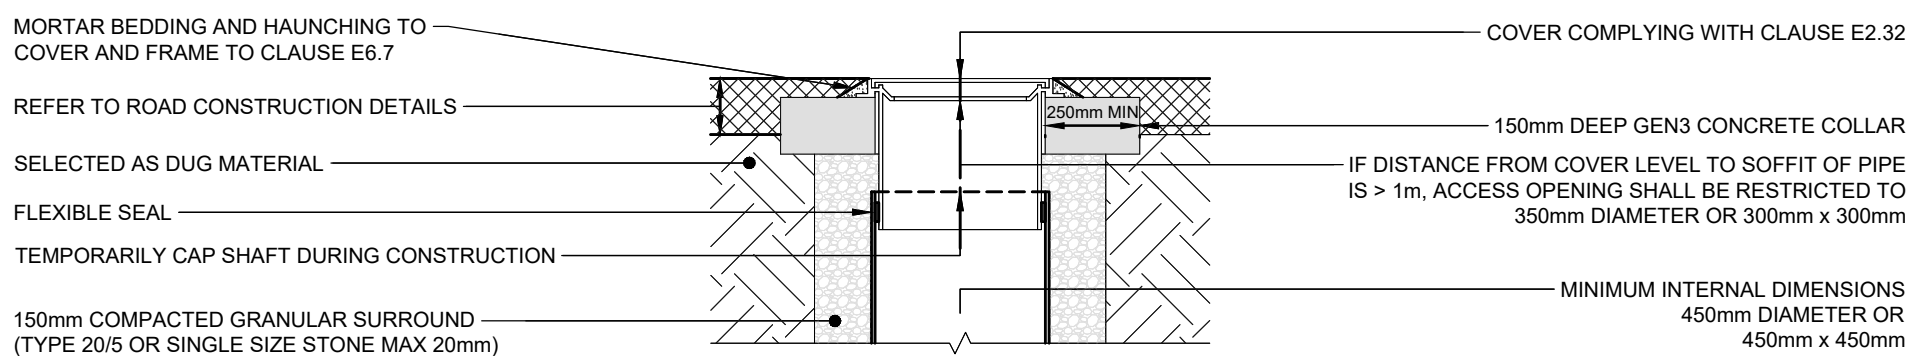


SITED IN DOMESTIC DRIVEWAYS/FOOTWAYS

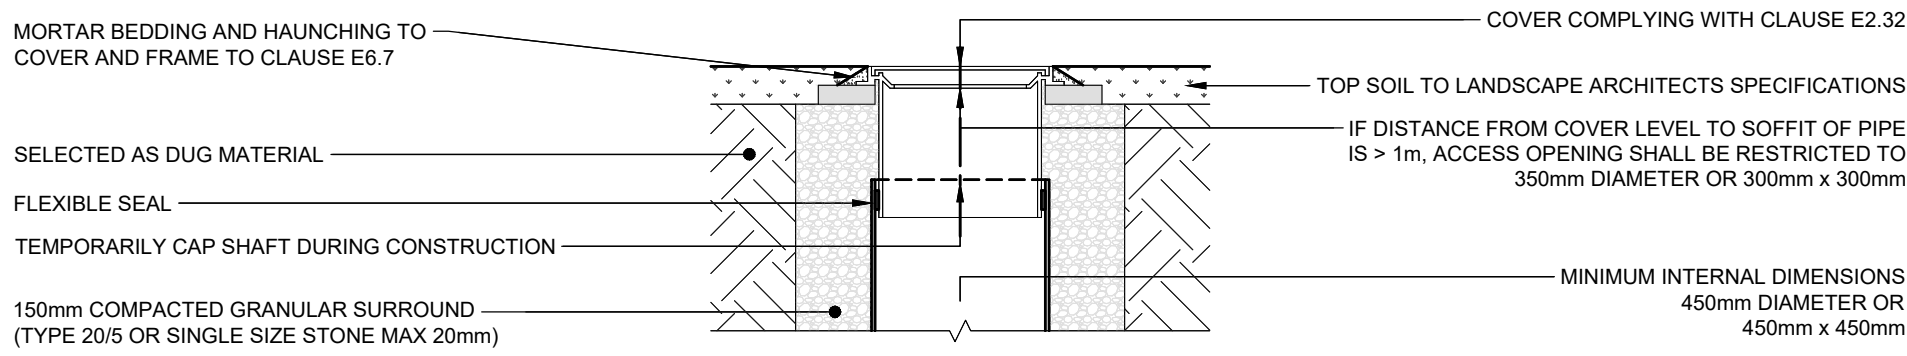


SITED IN DOMESTIC GARDENS


NOTE: WHERE THE ACCESS CHAMBER IS IN THE HIGHWAY (INCLUDING ANY FOOTWAY), THE HIGHWAY AUTHORITY CAN HAVE SPECIFIC REQUIREMENTS.

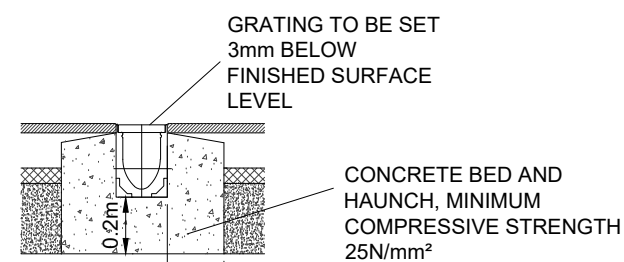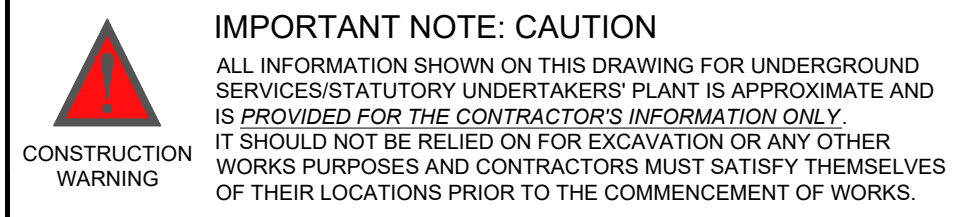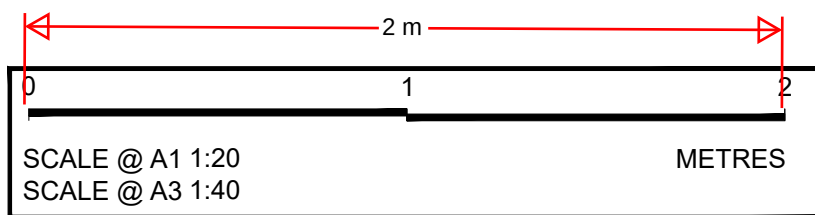

ACO
MULTIDRAIN
150Ø D400
(1:20)

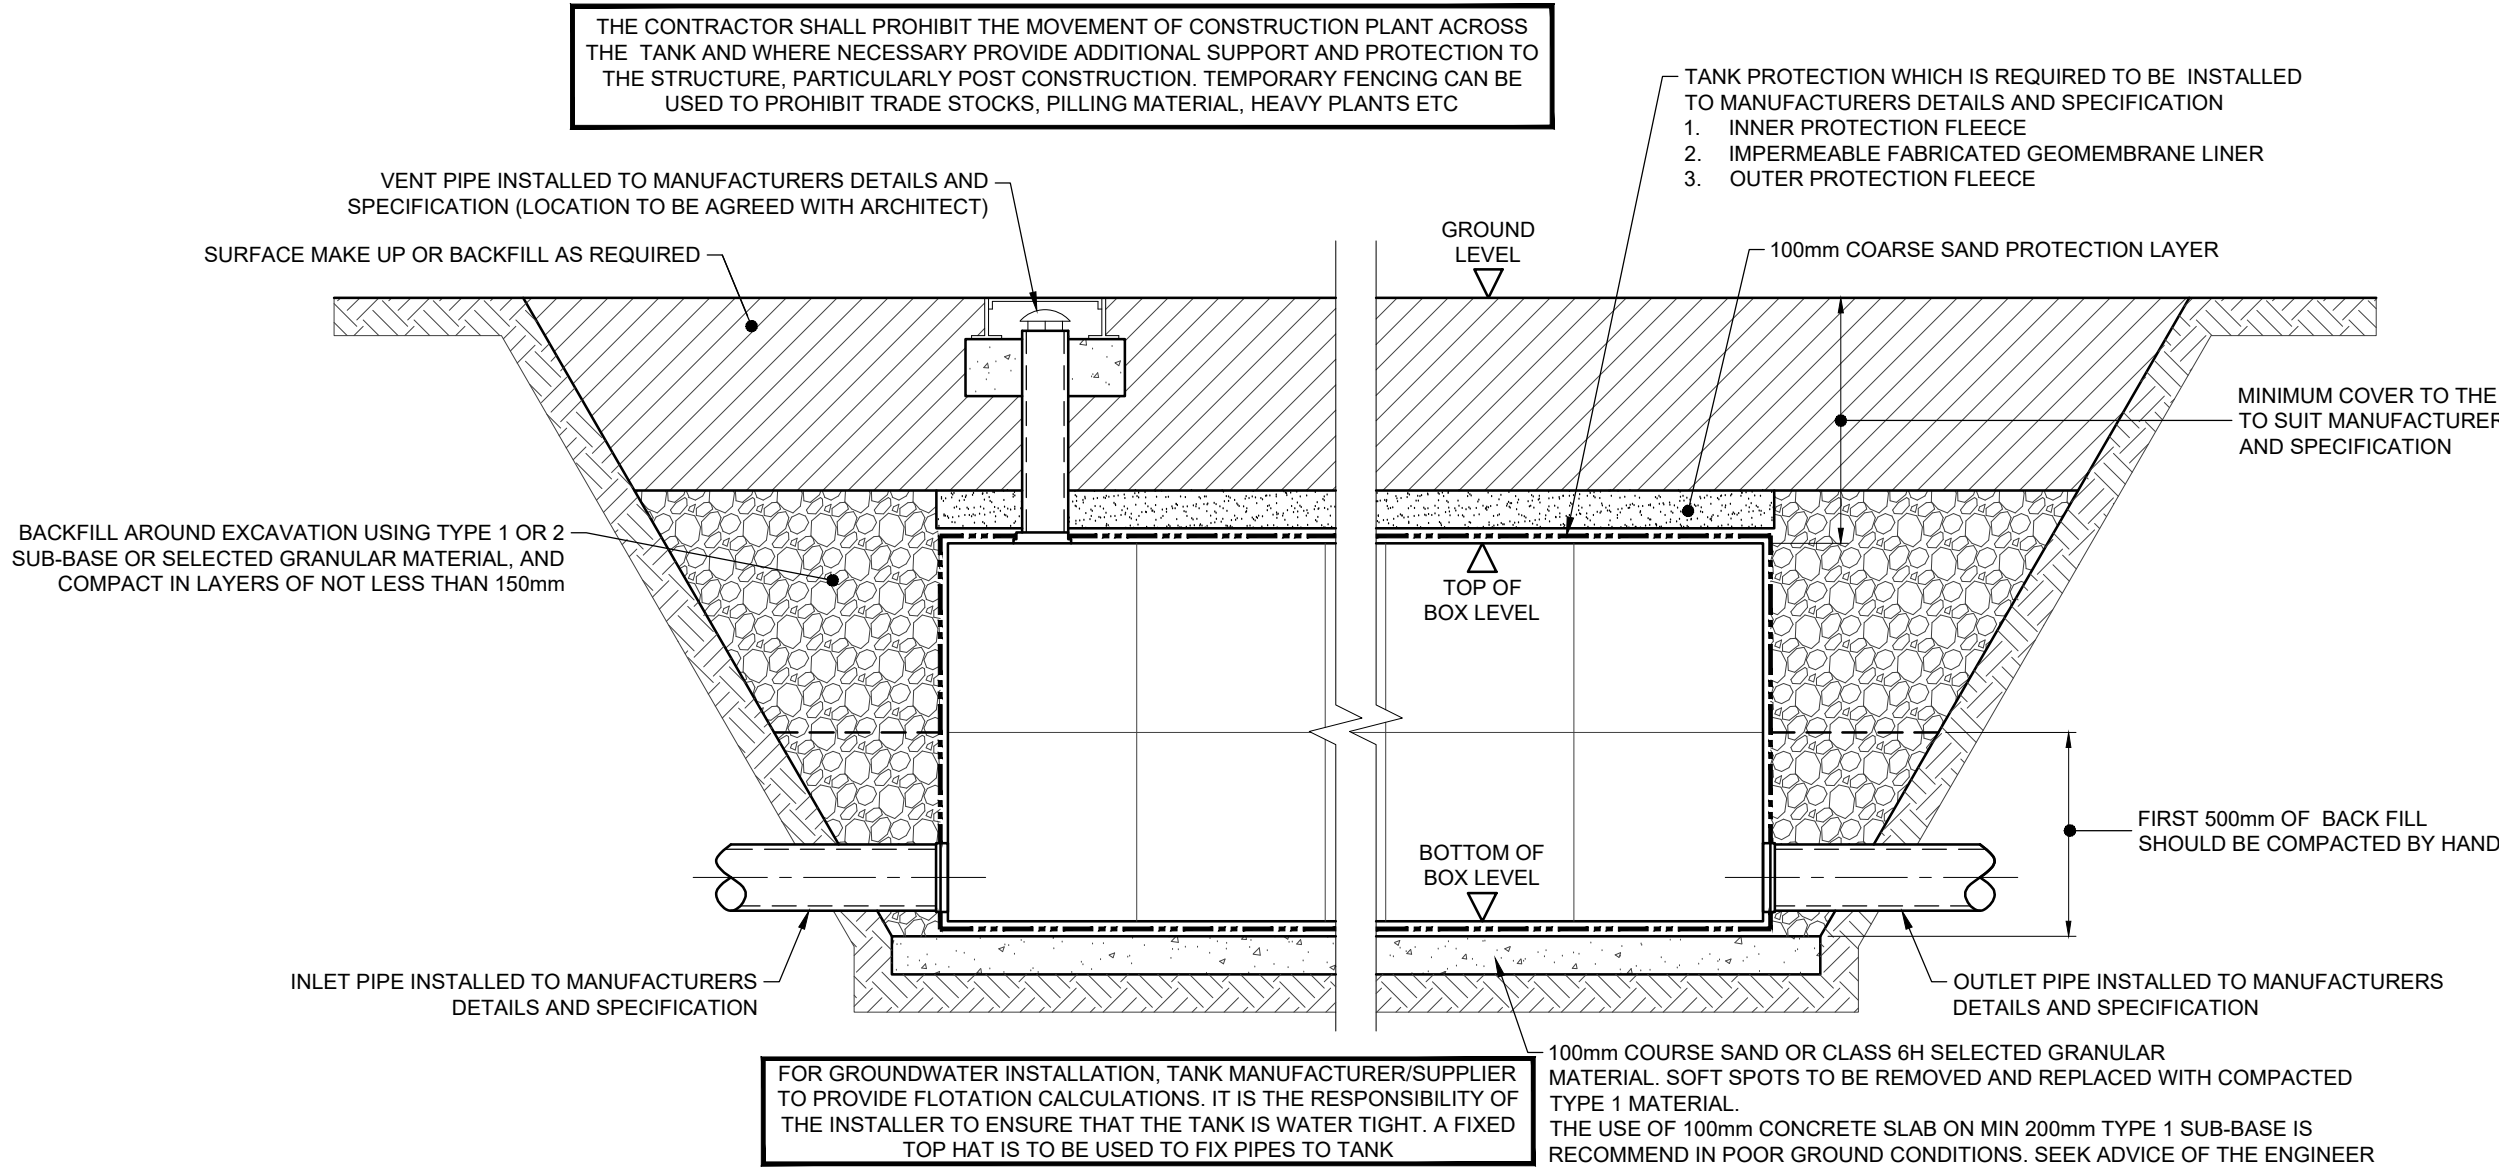


TYPICAL DETAIL FOR ATTENUATION TANK

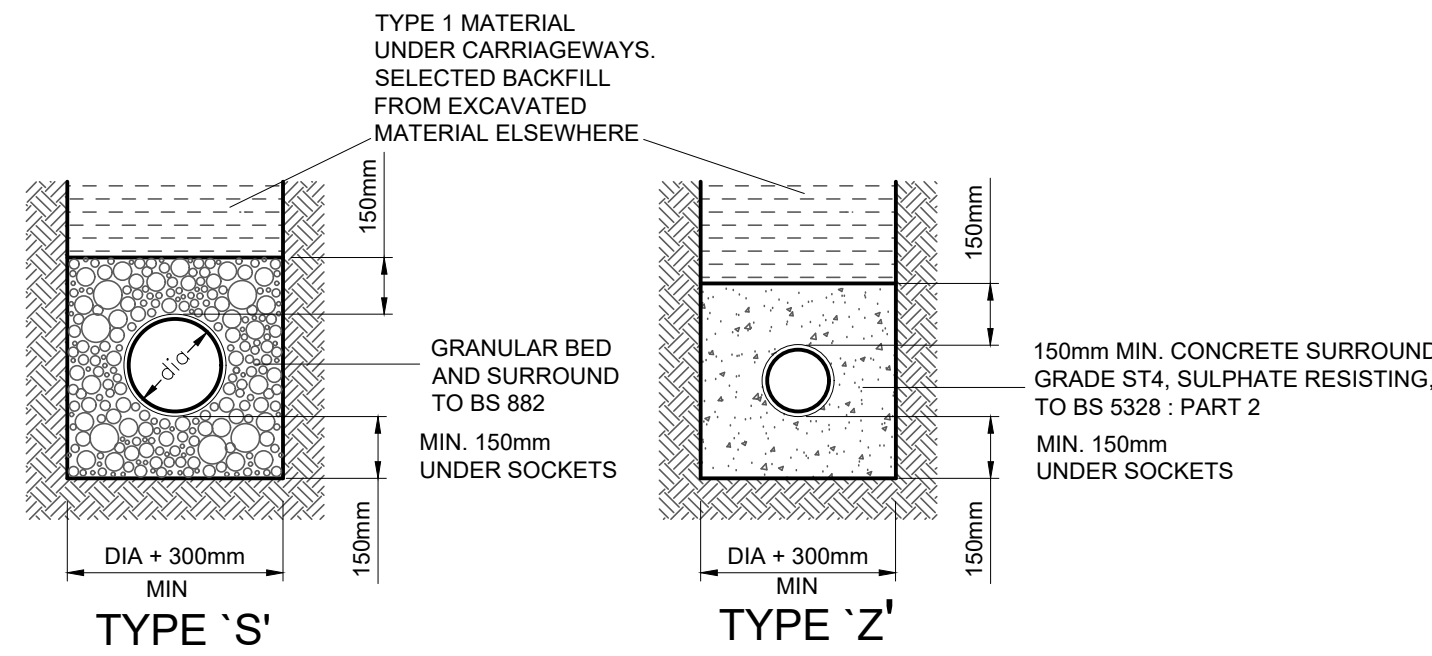


PIPE BEDDING DETAILS IN PRIVATE AREAS

DRAINAGE WITH MORE THAN 600mm COVER - LANDSCAPED
900mm COVER - ROADS
(UNLESS BEDDING TYPE IS STATED ON THE DRAINAGE PLANS OR SPECIFICATION)


DRAINAGE WITH LESS THAN 600mm COVER - LANDSCAPED
900mm COVER - ROADS
(UNLESS BEDDING TYPE IS STATED ON THE DRAINAGE PLANS OR SPECIFICATION)

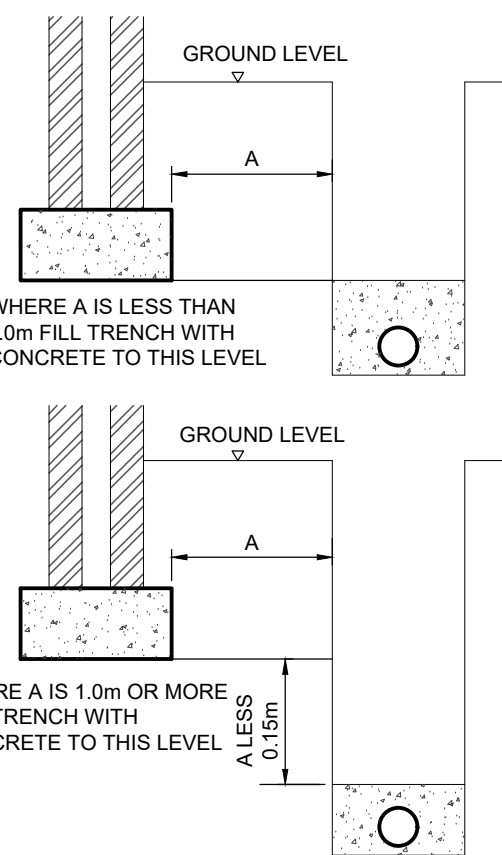

DRAINAGE NEAR BUILDINGS

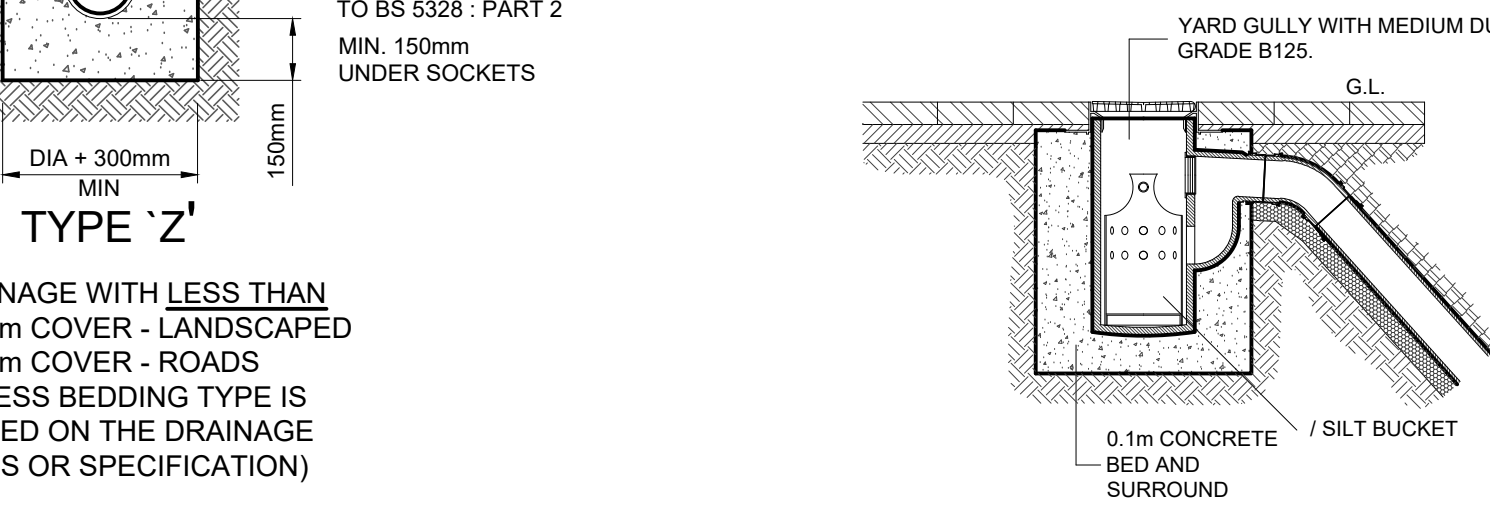


YARD GULLY

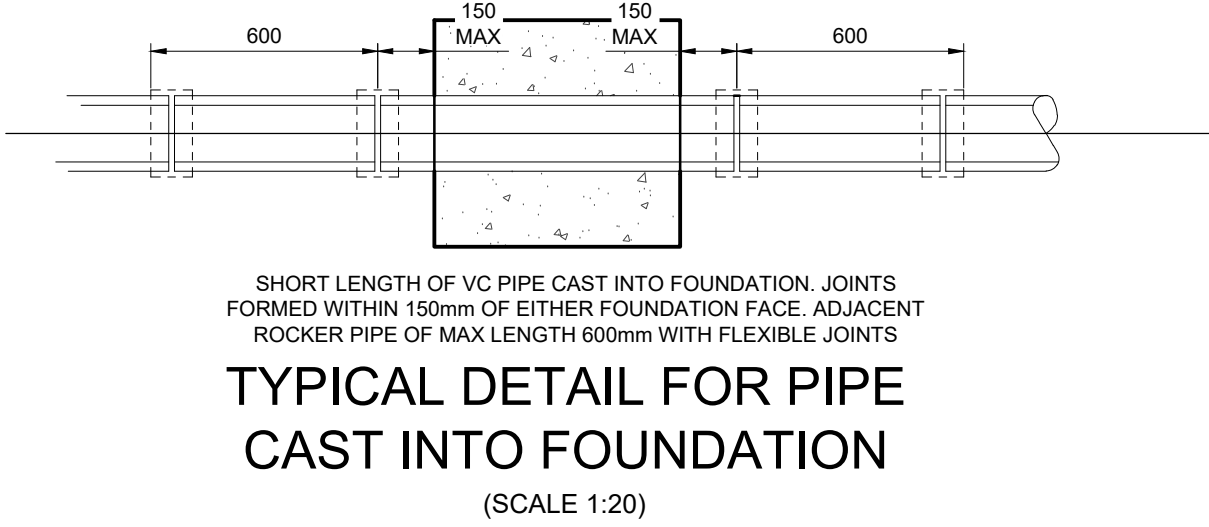


TYPICAL DETAIL FOR PIPE CAST INTO FOUNDATION

(SCALE 1:20)

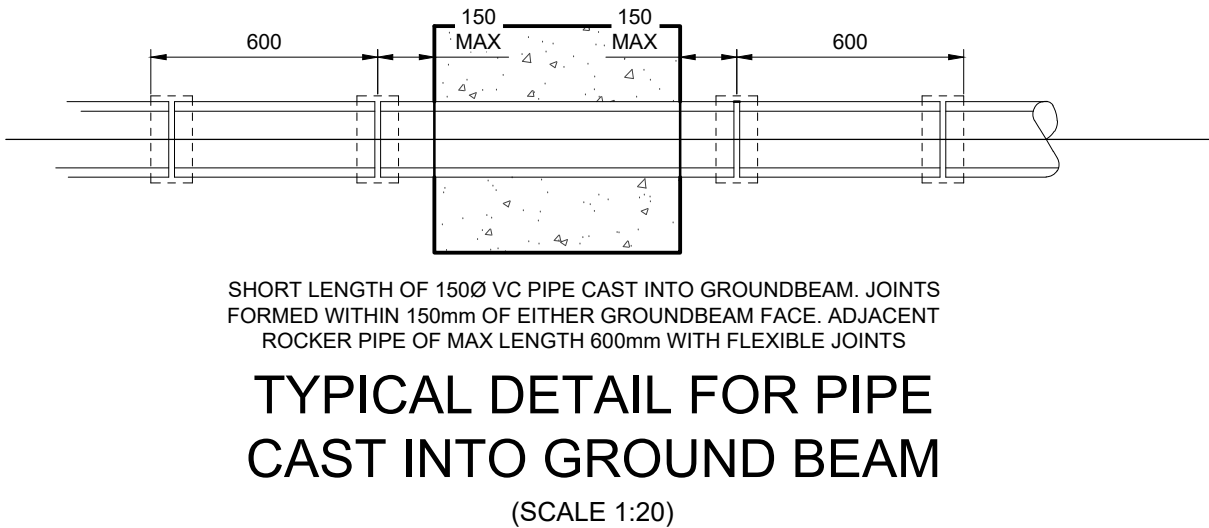


TYPICAL DETAIL FOR PIPE CAST INTO GROUND BEAM


(SCALE 1:20)

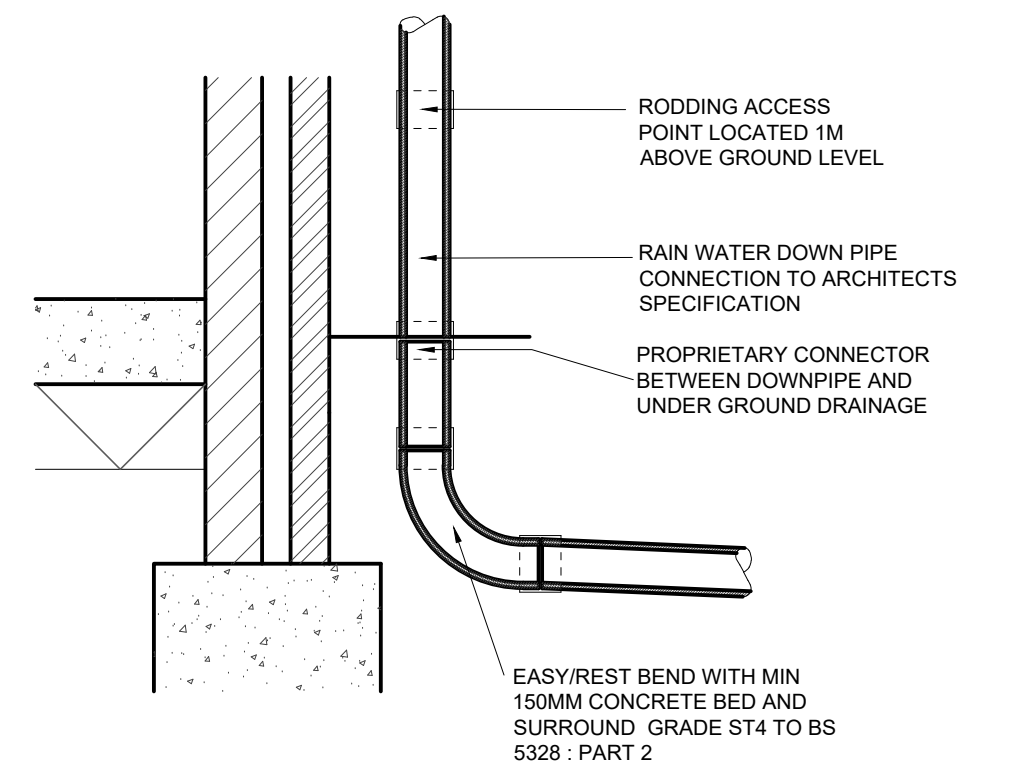


SEALED RAIN WATER DOWNPIPE

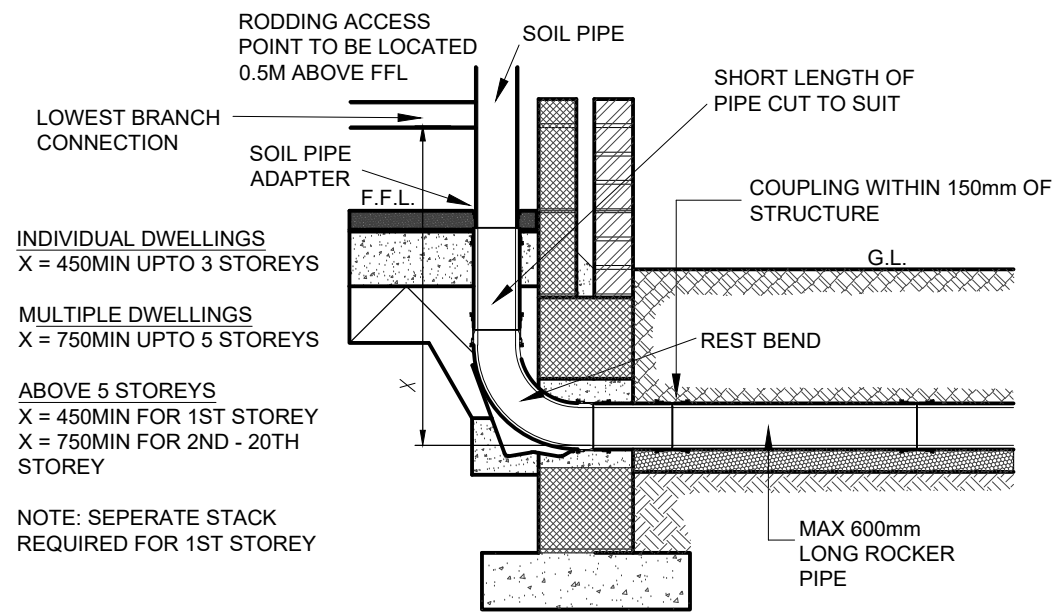


SOIL & VENT PIPE/STUB STACK/DURGO CONNECTION DETAIL

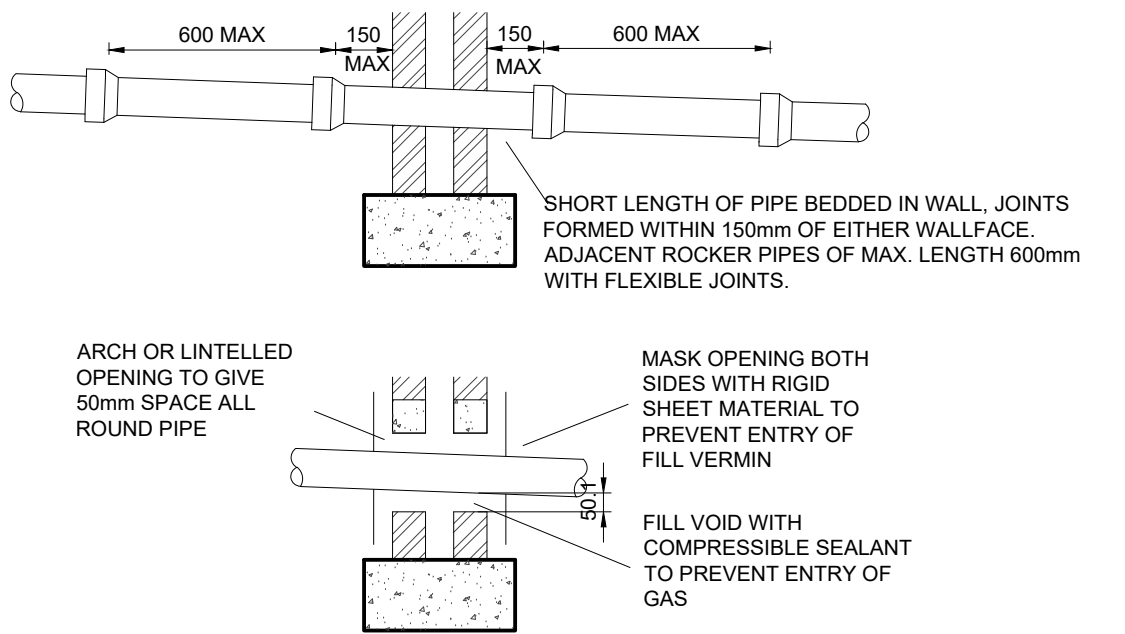

PIPES PENETRATING WALLS

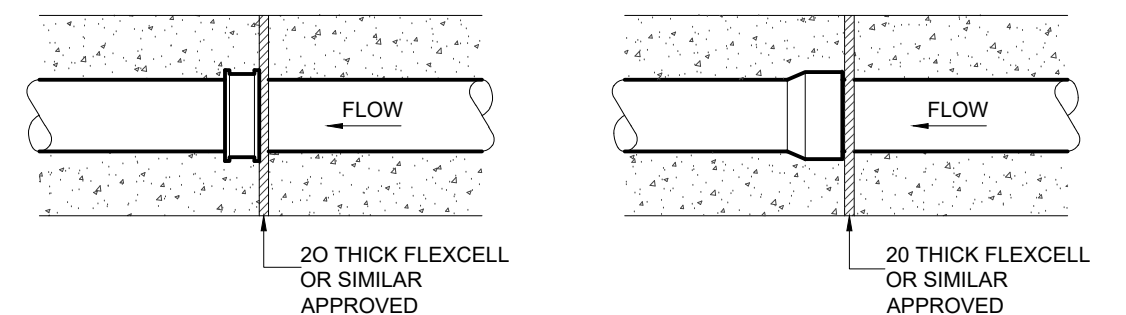

FLEXIBLE JOINT
DETAIL
FOR SLEEVED PIPES
(SCALE 1:20)

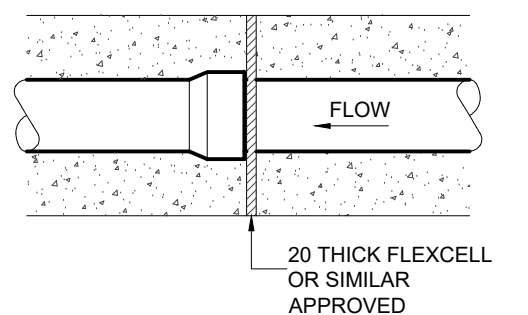

FLEXIBLE JOINT
DETAIL FOR
SOCKETED PIPES
(SCALE 1:20)

- NOTES:
- THIS DRAWING TO BE READ IN CONJUNCTION WITH ALL RELEVANT ARCHITECTS AND ENGINEERS DRAWINGS AND SPECIFICATIONS.
 - FOR SETTING OUT REFER TO ARCHITECT'S DRAWINGS.
 - ALL DIMENSIONS ARE IN MILLIMETRES (mm) UNLESS NOTED OTHERWISE.
 - DO NOT SCALE FROM THE DRAWING OR THE COMPUTER DIGITAL DATA. ONLY FIGURED DIMENSIONS TO BE USED.

Rev	Date	Description	By
P03	03/04/24	SCALE BAR ADDED	JLM
P02	12/01/24	UPDATED TO SUIT COMMENTS	JLM
P01	20/12/23	PRELIMINARY ISSUE	SPB

Job
LAND TO REAR OF
24 STONE STREET, GRAVESEND,
KENT DA11 0NP

Drawing Status

PRELIMINARY

Title
DRAINAGE DETAILS

Scale @ A1
1:20

Date
DEC_2023

By
SPB

Checked
MB

Drawing Number
7691-MBP-XX-XX-DR-C-0502

Revision
P03

MBP Consulting Engineers

1 Lancaster Place
London WC2E 7ED
T 020 7240 1191
E london@mbp-uk.com
W mbp-uk.com