


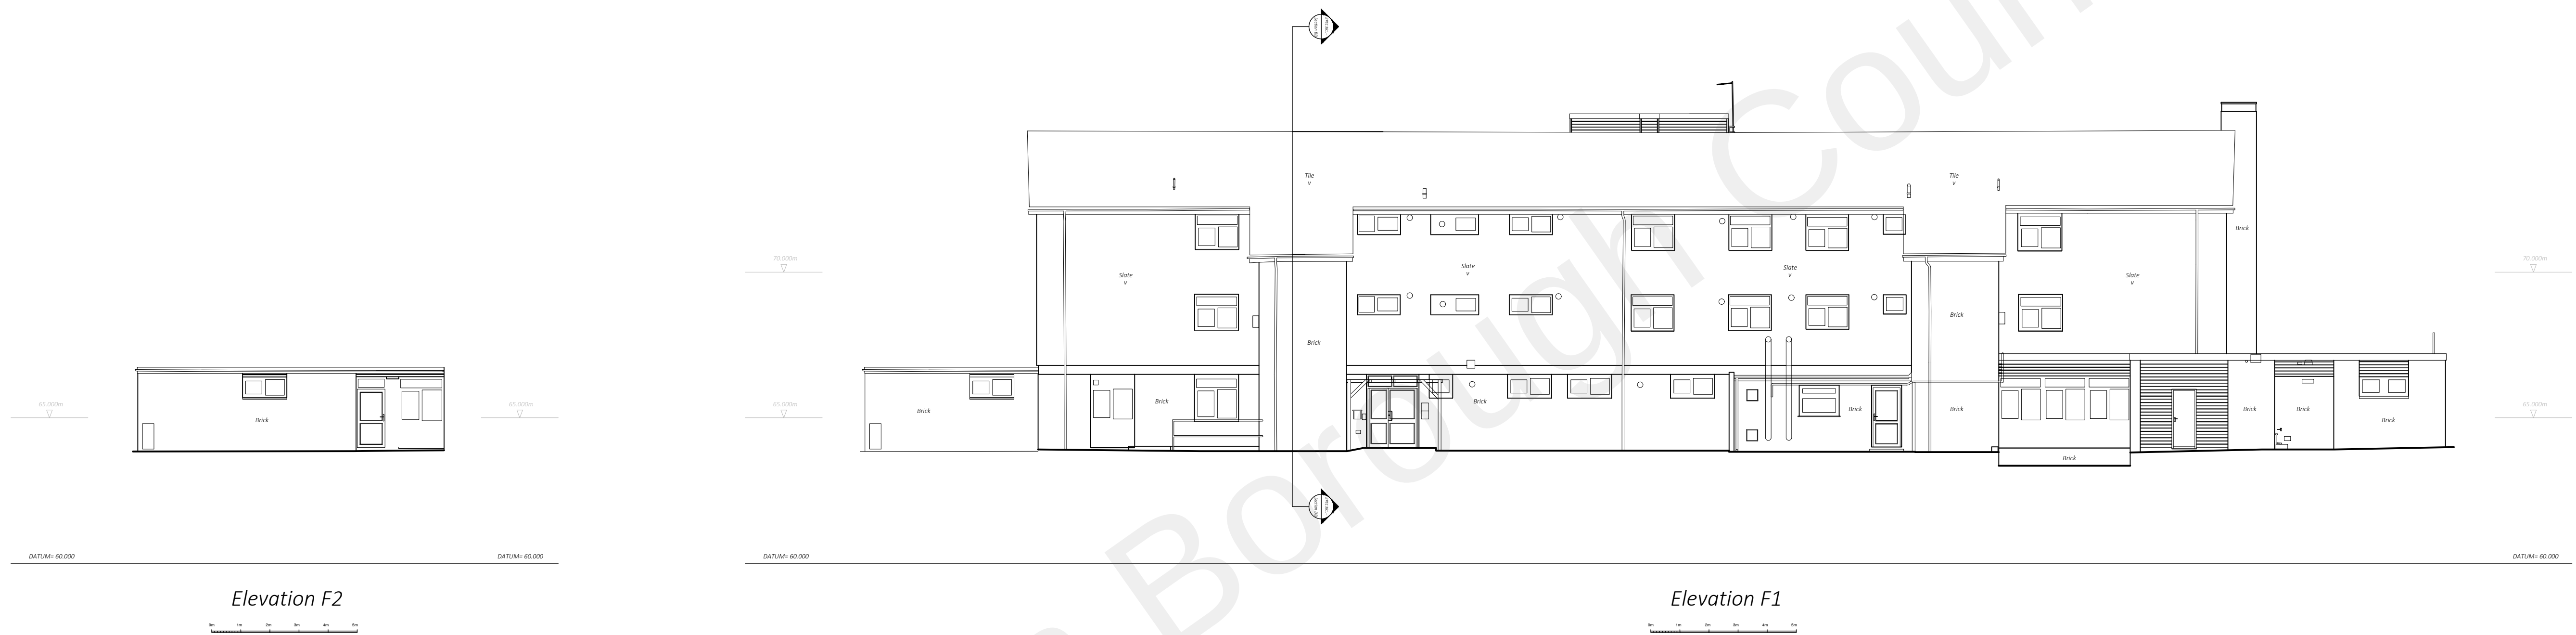

Site Legend:			Building Legend:			Levels:			Project: Hevercourt. Goodwood Crescent. Gravesend. DA12 5EY			Blueprint Surveys Ltd						
AB	Air Brick	GV	Gas Valve	SYL	Single Yellow Line	CA	Centre of Arch	RWP	Rain Water Pipe	Level data has been obtained with Kinematic GPS corrections via the Ordnance Survey's network, OS Net. http://www.ordnancesurvey.co.uk/oswebsite/gps/commercialservices/faq.html			TOPOGRAPHIC SURVEYS FLOOR PLANS ELEVATIONS and SECTIONS 3D SCANNING BPS			Land and Measured Building Surveys		
ACU	Air Conditioning Unit	IC	Inspection Cover	TCB	Telephone Call Box	CH	Ceiling Height	SA	Spring of Arch									
ASP	Artificial Stone Paving	IL	Invert level	TP	Telegraph Pole	CWT	Cold Water Tank	SCH	Suspended Ceiling Height									
BT	British Telecom	LP	Lamp Post	TW	Top of Wall	DH	Door Head	SD	Sliding Door									
CL	Cover Level	MKR	Marker (Service)	TF	Top of Fence	ESP	Electricity Switch Panel	SP	Soil Pipe	Drawing: Elevations			Scale: 1:125 @ A1			Tel: 020 8339 6125		
DYL	Double Yellow Line	MP	Metal Post	UTL	Unable To Lift	F	Frame Height	SVP	Soil and Vent Pipe									
EL	Electricity	OH	Overhead	VP	Vent Pipe	GDH	Glazed Door Height	USB	Underside of Beam									
FAI	Fresh Air Inlet	OST	Oil Storage Tank	WV	Water Valve	GRL	Glazed Roof Light	WP	Waste Pipe									
FB	Flower Bed	PB	Post Box	CP	Concrete Post	HWT	Hot Water Tank	WST	Water Storage Tank	Date: November 2015			Drawing No: BPS1361.05 of 08			E Mail: admin@blueprintsurveys.co.uk		
FH	Fire Hydrant	PL	Pavement Light	WP	Wooden Post	RSD	Roller Shutter Door											
G	Gully	RE	Rodding Eye	/CB	Close Boarded Fence													
		RS	Road Sign	/IW	Interwoven Panel													
		SNP	Street Name Plate	/VB	Vertical Board													