


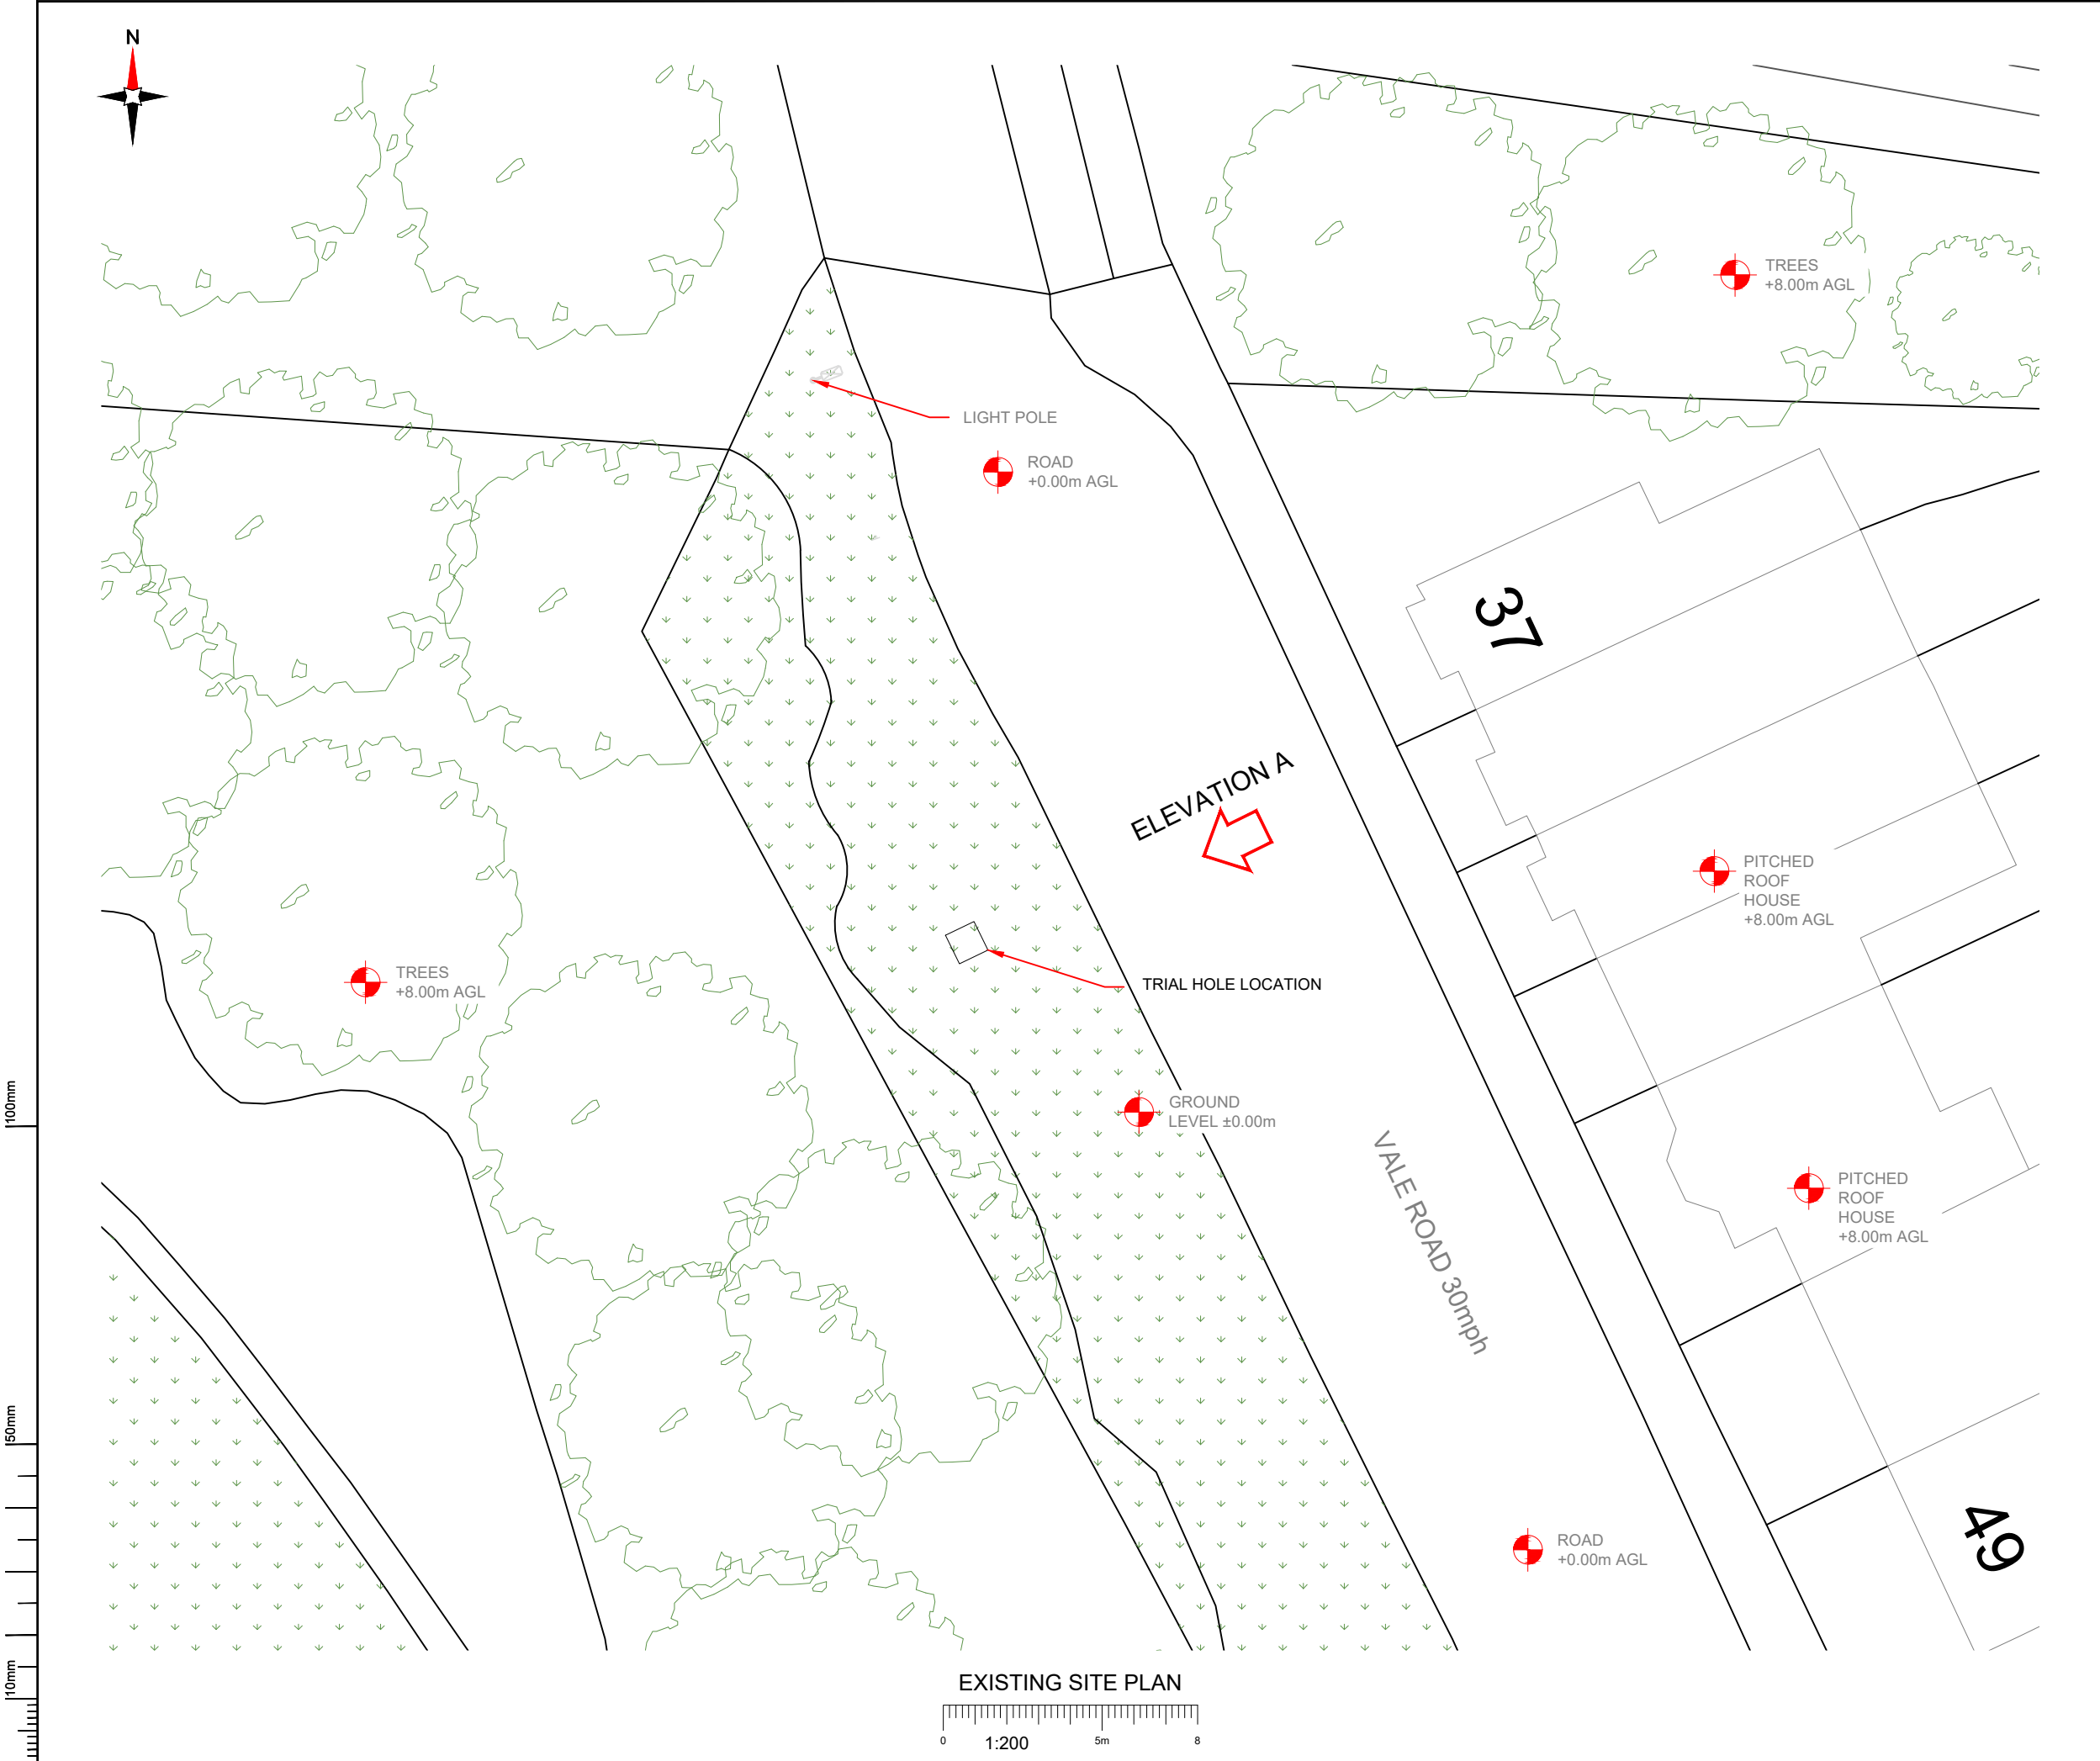

- NOTES:
- ALL DIMENSIONS ARE IN MM UNLESS OTHERWISE STATED
 - DRAWING TO BE READ IN CONJUNCTION WITH ALL RELEVANT DRAWINGS AND SPECIFICATIONS
 - DO NOT SCALE DRAWINGS. ALL DIMENSION TO BE CHECKED ON SITE. ALL DIMENSIONS SHOWN ON EXISTING STRUCTURES ARE APPROXIMATE AND THE CONTRACTOR IS TO OBTAIN ALL EXACT SITE DIMENSIONS NECESSARY TO CARRY OUT PROPOSED WORKS
 - DUCT ROUTES ARE SHOWN INDICATIVELY. ACTUAL ROUTES TO BE DETERMINED ON SITE
 - ALL DISCREPANCIES TO BE REPORTED TO THE DESIGN ENGINEER

Master:	MBNL / EE / H3G:	Project:	Purpose of Issue:	Issue:
M007	MBNL	NTQR	Planning	D
Date:	14/06/2024	Revision / Upgrade Description:		
Drawn:	J.Halloran	Planning - Resubmitted with proposed monopole at 18.0m instead of 20.0m. Monopole and Cabinets coloured Green (6002)		
Checked:	T. Clifford			
Approved:	M. Venner			
Master:	MBNL / EE / H3G:	Project:	Purpose of Issue:	Issue:
M006	MBNL	NTQR	Detailed Design	C3
Date:	19/03/2024	Revision / Upgrade Description:		
Drawn:	J.Halloran	Detailed Design - Amended as per CP & TX rejections.		
Checked:	T. Clifford			
Approved:	M. Venner			
Master:	MBNL / EE / H3G:	Project:	Purpose of Issue:	Issue:
M005	MBNL	NTQR	Detailed Design	C2
Date:	30/01/2024	Revision / Upgrade Description:		
Drawn:	J.Halloran	Detailed Design - Amended as per T&T, MBNL & CP rejections - TX approved		
Checked:	T. Clifford			
Approved:	M. Venner			
Master:	MBNL / EE / H3G:	Project:	Purpose of Issue:	Issue:
M004	MBNL	NTQR	Detailed Design	C1
Date:	05/01/2024	Revision / Upgrade Description:		
Drawn:	K. Soper	Detailed Design - First Issue		
Checked:	T. Clifford			
Approved:	M. Venner			
Master:	MBNL / EE / H3G:	Project:	Purpose of Issue:	Issue:
M003	MBNL	NTQR	Planning	C
Date:	11/10/2023	Revision / Upgrade Description:		
Drawn:	W. Dean	Amended as per TX Rejection comments		
Checked:	T. Clifford			
Approved:	M. Venner			



Hutchison 3G UK Limited
Green Park, 450 Longwater Avenue
Reading, RG30 3UR
Tel: 01628 765 000
Fax: 01628 765 001

H3G Base Station Information line:
0845 6043000
Available 8am-8pm Monday to Friday



Hatfield Business Park
Hatfield
Hertfordshire
AL10 9BW

Tel: 01707 315000
Fax: 01707 319001



Mobile Broadband Network Limited
Sixth Floor, Thames Tower, Station Road, Reading, RG1 1LX



UNIT E3 PITTS CLEAVE INDUSTRIAL ESTATE, TAVISTOCK, DEVON, PL19 0PW
sales@beaconcomms.co.uk

Tel: +44 (0)1822 610610

Site Name:	VALE ROAD		
Site ID:	1707938		
Address:	VALE ROAD GRAVESHAM KENT DA11 9RE		
Title:	100 EXISTING SITE PLAN		
Project:	MBNL NTQR		
Purpose of Issue:	PLANNING DRAWING		
EE Cell ID:	30702	MBNL Cell ID:	GVM091
3UK Cell ID:	DA1149		
Master Drawing No:	1707938_GVM091_30702_DA1149_M007		
Issue:	D		

 
100mm

150mm

10mm



EXISTING ELEVATION A



- NOTES:
1. ALL DIMENSIONS ARE IN MM UNLESS OTHERWISE STATED
 2. DRAWING TO BE READ IN CONJUNCTION WITH ALL RELEVANT DRAWINGS AND SPECIFICATIONS
 3. DO NOT SCALE DRAWINGS, ALL DIMENSIONS TO BE CHECKED ON SITE. ALL DIMENSIONS SHOWN ON EXISTING STRUCTURES ARE APPROXIMATE AND THE CONTRACTOR IS TO OBTAIN ALL EXACT SITE DIMENSIONS NECESSARY TO CARRY OUT PROPOSED WORKS
 4. DUCT ROUTES ARE SHOWN INDICATIVELY, ACTUAL ROUTES TO BE DETERMINED ON SITE
 5. ALL DISCREPANCIES TO BE REPORTED TO THE DESIGN ENGINEER

Master:	MBNL / EE / H3G:	Project:	Purpose of Issue:	Issue:
M007	MBNL	NTQR	Planning	D
Date:	14/06/2024	Revision / Upgrade Description:		
Drawn:	J.Halloran	Planning - Resubmitted with proposed monopole at 18.0m instead of 20.0m. Monopole and Cabinets coloured Green (6002)		
Checked:	T. Clifford			
Approved:	M. Venner			
Master:	MBNL / EE / H3G:	Project:	Purpose of Issue:	Issue:
M006	MBNL	NTQR	Detailed Design	C3
Date:	19/03/2024	Revision / Upgrade Description:		
Drawn:	J.Halloran	Detailed Design - Amended as per CP & TX rejections.		
Checked:	T. Clifford			
Approved:	M. Venner			
Master:	MBNL / EE / H3G:	Project:	Purpose of Issue:	Issue:
M005	MBNL	NTQR	Detailed Design	C2
Date:	30/01/2024	Revision / Upgrade Description:		
Drawn:	J.Halloran	Detailed Design - Amended as per T&T, MBNL & CP rejections - TX approved		
Checked:	T. Clifford			
Approved:	M. Venner			
Master:	MBNL / EE / H3G:	Project:	Purpose of Issue:	Issue:
M004	MBNL	NTQR	Detailed Design	C1
Date:	05/01/2024	Revision / Upgrade Description:		
Drawn:	K. Soper	Detailed Design - First Issue		
Checked:	T. Clifford			
Approved:	M. Venner			
Master:	MBNL / EE / H3G:	Project:	Purpose of Issue:	Issue:
M003	MBNL	NTQR	Planning	C
Date:	11/10/2023	Revision / Upgrade Description:		
Drawn:	W. Dean	Amended as per TX Rejection comments		
Checked:	T. Clifford			
Approved:	M. Venner			



Hutchison 3G UK Limited
Green Park, 450 Longwater Avenue
Reading, RG30 3UR
Tel: 01628 765 000
Fax: 01628 765 001

H3G Base Station Information line:
0845 6043000
Available 8am-8pm Monday to Friday



Hatfield Business Park
Hatfield
Hertfordshire
AL10 9BW

Tel: 01707 315000
Fax: 01707 319001




Mobile Broadband Network Limited
Sixth Floor, Thames Tower, Station Road, Reading, RG1 1LX



UNIT E3 PITTS CLEAVE INDUSTRIAL ESTATE, TAVISTOCK, DEVON, PL19 0PW
sales@beaconcomms.co.uk
Tel: +44 (0)1822 610610

Site Name:	VALE ROAD		
Site ID:	1707938		
Address:	VALE ROAD GRAVESHAM KENT DA11 9RE		
Title:	150 EXISTING ELEVATION A		
Project:	MBNL NTQR		
Purpose of Issue:	PLANNING DRAWING		
EE Cell ID:	30702	MBNL Cell ID:	GVM091
3UK Cell ID:	DA1149		
Master Drawing No:	1707938_GVM091_30702_DA1149_M007		
Issue:	D		

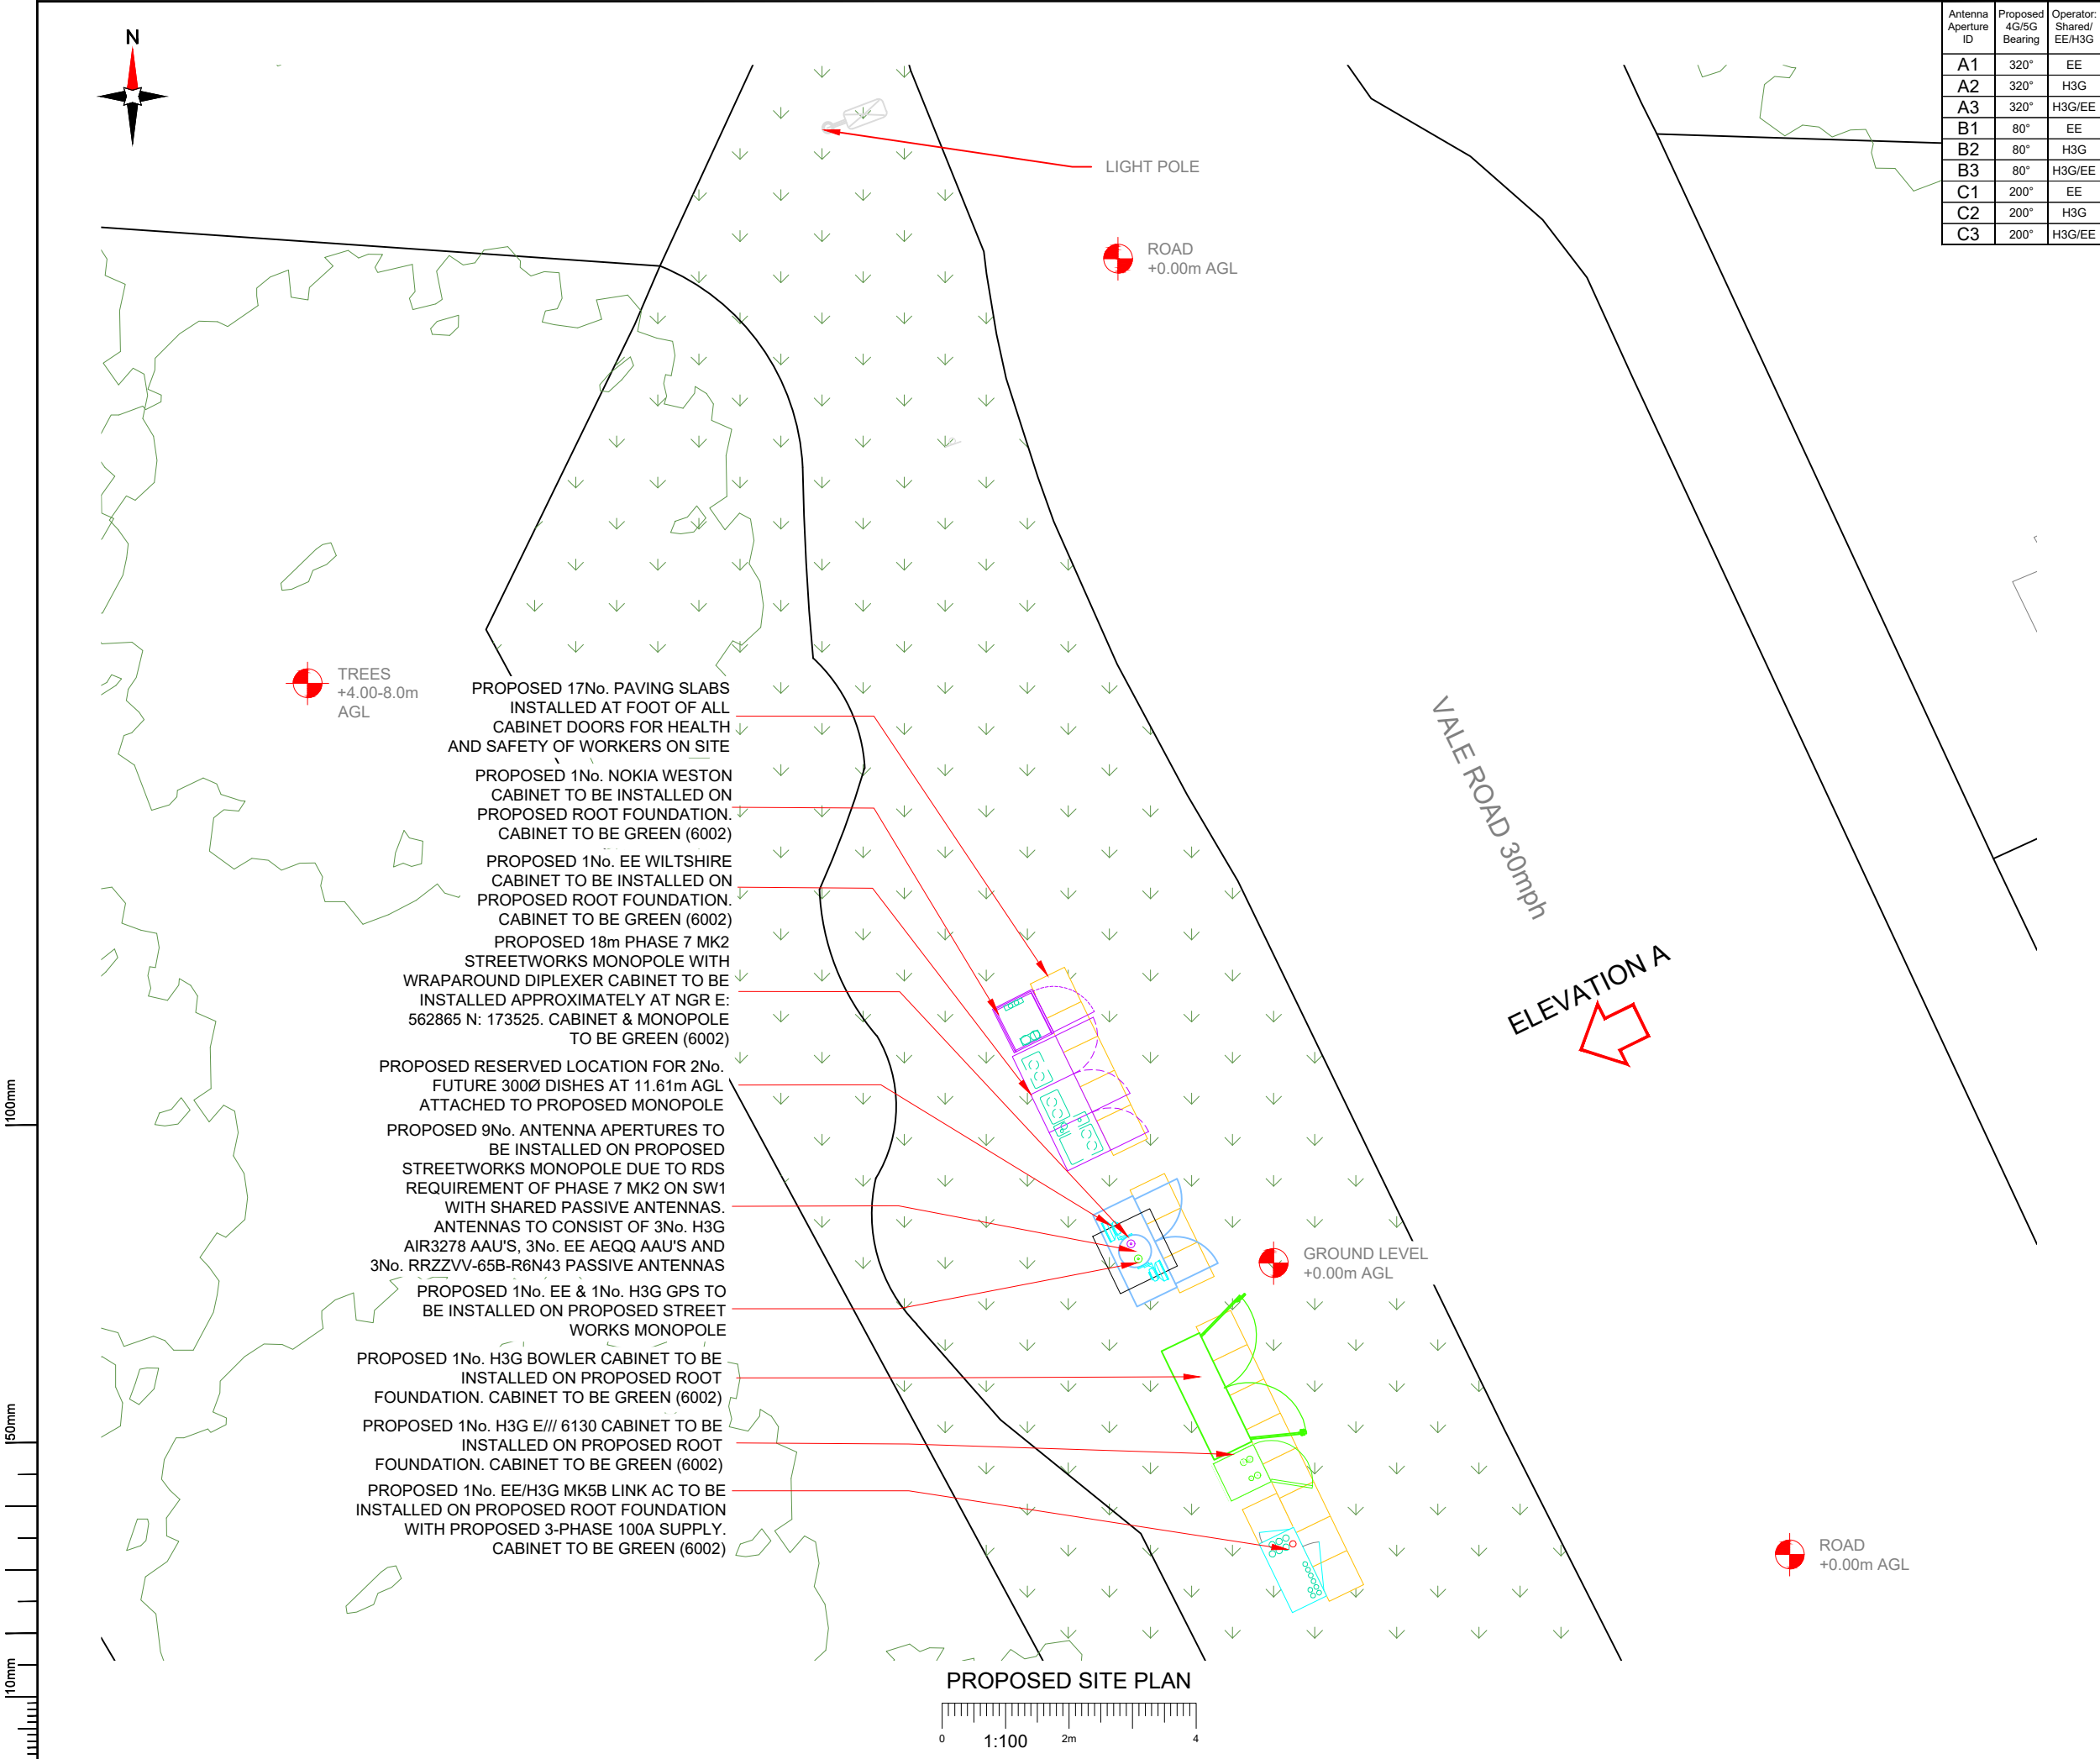

Antenna Aperture ID	Proposed 4G/5G Bearing	Operator: Shared/ EE/H3G
A1	320°	EE
A2	320°	H3G
A3	320°	H3G/EE
B1	80°	EE
B2	80°	H3G
B3	80°	H3G/EE
C1	200°	EE
C2	200°	H3G
C3	200°	H3G/EE

- NOTES:
- ALL DIMENSIONS ARE IN MM UNLESS OTHERWISE STATED
 - DRAWING TO BE READ IN CONJUNCTION WITH ALL RELEVANT DRAWINGS AND SPECIFICATIONS
 - DO NOT SCALE DRAWINGS, ALL DIMENSION TO BE CHECKED ON SITE. ALL DIMENSIONS SHOWN ON EXISTING STRUCTURES ARE APPROXIMATE AND THE CONTRACTOR IS TO OBTAIN ALL EXACT SITE DIMENSIONS NECESSARY TO CARRY OUT PROPOSED WORKS
 - DUCT ROUTES ARE SHOWN INDICATIVELY, ACTUAL ROUTES TO BE DETERMINED ON SITE
 - ALL DISCREPANCIES TO BE REPORTED TO THE DESIGN ENGINEER

Master:	MBNL / EE / H3G:	Project:	Purpose of Issue:	Issue:
M007	MBNL	NTQR	Planning	D
Date:	14/06/2024	Revision / Upgrade Description:		
Drawn:	J.Halloran	Planning - Resubmitted with proposed monopole at 18.0m instead of 20.0m. Monopole and Cabinets coloured Green (6002)		
Checked:	T. Clifford			
Approved:	M. Venner			
Master:	MBNL / EE / H3G:	Project:	Purpose of Issue:	Issue:
M006	MBNL	NTQR	Detailed Design	C3
Date:	19/03/2024	Revision / Upgrade Description:		
Drawn:	J.Halloran	Detailed Design - Amended as per CP & TX rejections.		
Checked:	T. Clifford			
Approved:	M. Venner			
Master:	MBNL / EE / H3G:	Project:	Purpose of Issue:	Issue:
M005	MBNL	NTQR	Detailed Design	C2
Date:	30/01/2024	Revision / Upgrade Description:		
Drawn:	J.Halloran	Detailed Design - Amended as per T&T, MBNL & CP rejections - TX approved		
Checked:	T. Clifford			
Approved:	M. Venner			
Master:	MBNL / EE / H3G:	Project:	Purpose of Issue:	Issue:
M004	MBNL	NTQR	Detailed Design	C1
Date:	05/01/2024	Revision / Upgrade Description:		
Drawn:	K. Soper	Detailed Design - First Issue		
Checked:	T. Clifford			
Approved:	M. Venner			
Master:	MBNL / EE / H3G:	Project:	Purpose of Issue:	Issue:
M003	MBNL	NTQR	Planning	C
Date:	11/10/2023	Revision / Upgrade Description:		
Drawn:	W. Dean	Amended as per TX Rejection comments		
Checked:	T. Clifford			
Approved:	M. Venner			



Hutchison 3G UK Limited
Green Park, 450 Longwater Avenue
Reading, RG30 3UR
Tel: 01628 765 500
Fax: 01628 765 501

H3G Base Station Information line:
0845 6043000
Available 8am-8pm Monday to Friday



Hatfield Business Park
Hatfield
Hertfordshire
AL10 9BW

Tel: 01707 315000
Fax: 01707 319001



Mobile Broadband Network Limited
Sixth Floor, Thames Tower, Station Road, Reading, RG1 1LX



UNIT E3 PITTS CLEAVE INDUSTRIAL ESTATE, TAVISTOCK, DEVON, PL19 0PW
sales@beaconcomms.co.uk Tel: +44 (0)1822 610610

Site Name:	VALE ROAD		
Site ID:	1707938		
Address:	VALE ROAD GRAVESHAM KENT DA11 9RE		
Title:	215 PROPOSED SITE PLAN		
Project:	MBNL NTQR		
Purpose of Issue:	PLANNING DRAWING		
EE Cell ID:	30702	MBNL Cell ID:	GVM091
3UK Cell ID:	DA1149		
Master Drawing No:	1707938_GVM091_30702_DA1149_M007		
Issue:	D		

PROPOSED 1No. EE & 1No. H3G GPS TO BE INSTALLED ON PROPOSED STREET WORKS MONOPOLE

TOP OF PROPOSED STRUCTURE +18.0m AGL

TOP OF AAUs +16.55m AGL

C/L of AAUs +16.25m AGL

U/S of AAUs +15.86m AGL

C/L OF DISHES +11.61m AGL

TREES APPROX +8.0m AGL

PROPOSED 9No. ANTENNA APERTURES TO BE INSTALLED ON PROPOSED STREETWORKS MONOPOLE DUE TO RDS REQUIREMENT OF PHASE 7 MK2 ON SW1 WITH SHARED PASSIVE ANTENNAS. ANTENNAS TO CONSIST OF 3No. H3G AIR3278 AAU'S, 3No. EE AEQQ AAU'S AND 3No. RRZZVV-65B-R6N43 PASSIVE ANTENNAS

TOP OF PROPOSED AAUs +17.95m AGL

C/L OF AAUs +17.55m AGL

U/S OF AAUs +17.15m AGL

TOP OF APERTURES +15.39m AGL

C/L OF APERTURES +14.34m AGL

U/S OF APERTURES +13.29m AGL

PROPOSED 18m PHASE 7 MK2 STREETWORKS MONOPOLE WITH WRAPAROUND DIPLEXER CABINET TO BE INSTALLED APPROXIMATELY AT NGR E: 562865 N: 173525. CABINET & MONOPOLE TO BE GREEN (6002)

PROPOSED RESERVED LOCATION FOR 2No. FUTURE 300Ø DISHES AT 11.61m AGL ATTACHED TO PROPOSED MONOPOLE

EXISTING LAMPOST 7.5m

PROPOSED 1No. EE/H3G MK5B LINK AC TO BE INSTALLED ON PROPOSED ROOT FOUNDATION WITH PROPOSED 3-PHASE 100A SUPPLY. CABINET TO BE GREEN (6002)

PROPOSED 1No. H3G E/// 6130 CABINET TO BE INSTALLED ON PROPOSED ROOT FOUNDATION. CABINET TO BE GREEN (6002)

 
PROPOSED 1No. H3G BOWLER CABINET TO BE INSTALLED ON PROPOSED ROOT FOUNDATION. CABINET TO BE GREEN (6002)

PROPOSED 1No. EE WILTSHIRE CABINET TO BE INSTALLED ON PROPOSED ROOT FOUNDATION. CABINET TO BE GREEN (6002)

PROPOSED 1No. NOKIA WESTON CABINET TO BE INSTALLED ON PROPOSED ROOT FOUNDATION. CABINET TO BE GREEN (6002)

Ground level

PROPOSED MAX CONFIGURATION ELEVATION



Antenna Aperture ID	Proposed 4G/5G Bearing	Operator: Shared/ EE/H3G
A1	320°	EE
A2	320°	H3G
A3	320°	H3G/EE
B1	80°	EE
B2	80°	H3G
B3	80°	H3G/EE
C1	200°	EE
C2	200°	H3G
C3	200°	H3G/EE

NOTES:

- ALL DIMENSIONS ARE IN MM UNLESS OTHERWISE STATED
- DRAWING TO BE READ IN CONJUNCTION WITH ALL RELEVANT DRAWINGS AND SPECIFICATIONS
- DO NOT SCALE DRAWINGS, ALL DIMENSION TO BE CHECKED ON SITE. ALL DIMENSIONS SHOWN ON EXISTING STRUCTURES ARE APPROXIMATE AND THE CONTRACTOR IS TO OBTAIN ALL EXACT SITE DIMENSIONS NECESSARY TO CARRY OUT PROPOSED WORKS
- DUCT ROUTES ARE SHOWN INDICATIVELY, ACTUAL ROUTES TO BE DETERMINED ON SITE
- ALL DISCREPANCIES TO BE REPORTED TO THE DESIGN ENGINEER

Master:	MBNL / EE / H3G:	Project:	NTQR	Purpose of Issue:	Planning	Issue:	D
Date:	14/06/2024	Revision / Upgrade Description:					
Drawn:	J.Halloran	Planning - Resubmitted with proposed monopole at 18.0m instead of 20.0m. Monopole and Cabinets coloured Green (6002)					
Checked:	T. Clifford						
Approved:	M. Venner						
Master:	MBNL / EE / H3G:	Project:	NTQR	Purpose of Issue:	Detailed Design	Issue:	C3
Date:	19/03/2024	Revision / Upgrade Description:					
Drawn:	J.Halloran	Detailed Design - Amended as per CP & TX rejections.					
Checked:	T. Clifford						
Approved:	M. Venner						
Master:	MBNL / EE / H3G:	Project:	NTQR	Purpose of Issue:	Detailed Design	Issue:	C2
Date:	30/01/2024	Revision / Upgrade Description:					
Drawn:	J.Halloran	Detailed Design - Amended as per T&T, MBNL & CP rejections - TX approved					
Checked:	T. Clifford						
Approved:	M. Venner						
Master:	MBNL / EE / H3G:	Project:	NTQR	Purpose of Issue:	Detailed Design	Issue:	C1
Date:	05/01/2024	Revision / Upgrade Description:					
Drawn:	K. Soper	Detailed Design - First Issue					
Checked:	T. Clifford						
Approved:	M. Venner						
Master:	MBNL / EE / H3G:	Project:	NTQR	Purpose of Issue:	Planning	Issue:	C
Date:	11/10/2023	Revision / Upgrade Description:					
Drawn:	W. Dean	Amended as per TX Rejection comments					
Checked:	T. Clifford						
Approved:	M. Venner						



Hutchison 3G UK Limited
Green Park, 450 Longwater Avenue
Reading, RG30 3UR
Tel: 01628 765 000
Fax: 01628 765 001



Hatfield Business Park
Hatfield
Hertfordshire
AL10 9BW
Tel: 01707 315000
Fax: 01707 319001



Mobile Broadband Network Limited
Sixth Floor, Thames Tower, Station Road, Reading, RG1 1LX



UNIT E3 PITTS CLEAVE INDUSTRIAL ESTATE, TAVISTOCK, DEVON, PL19 0PW
sales@beaconcomms.co.uk
Tel: +44 (0)1822 610610

Site Name:	VALE ROAD		
Site ID:	1707938		
Address:	VALE ROAD GRAVESHAM KENT DA11 9RE		
Title:	265 PROPOSED ELEVATION		
Project:	MBNL NTQR		
Purpose of Issue:	PLANNING DRAWING		
EE Cell ID:	30702	MBNL Cell ID:	GVM091
3UK Cell ID:	DA1149		
Master Drawing No:		1707938_GVM091_30702_DA1149_M007	Issue:
			D

Passive Infrastructure Equipment Capacity & Lead Operator			
A	B	C	LEAD
SW1	SW1	SW1	EE