


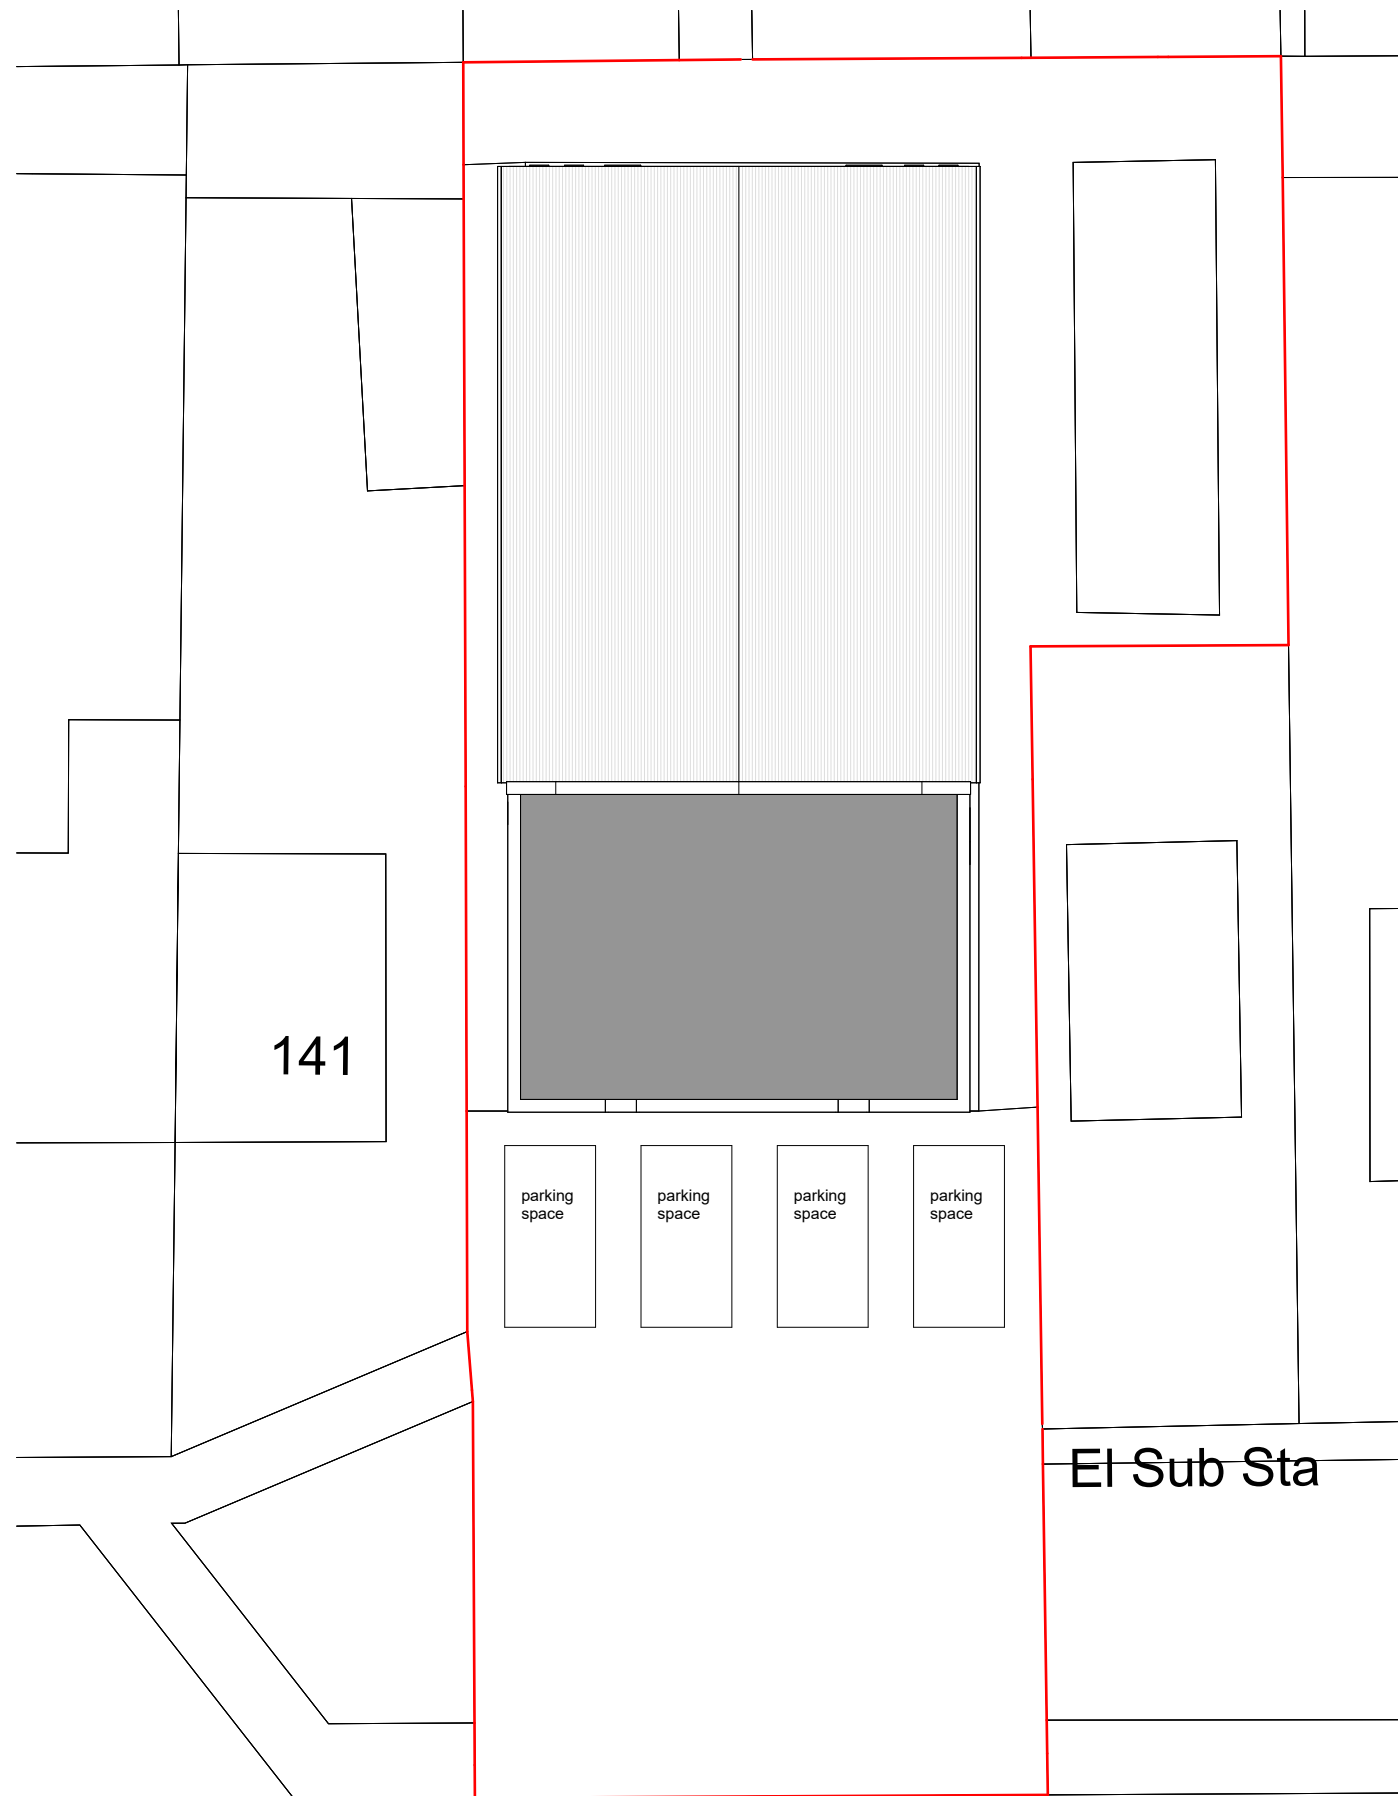


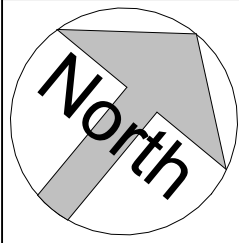

3D View 1

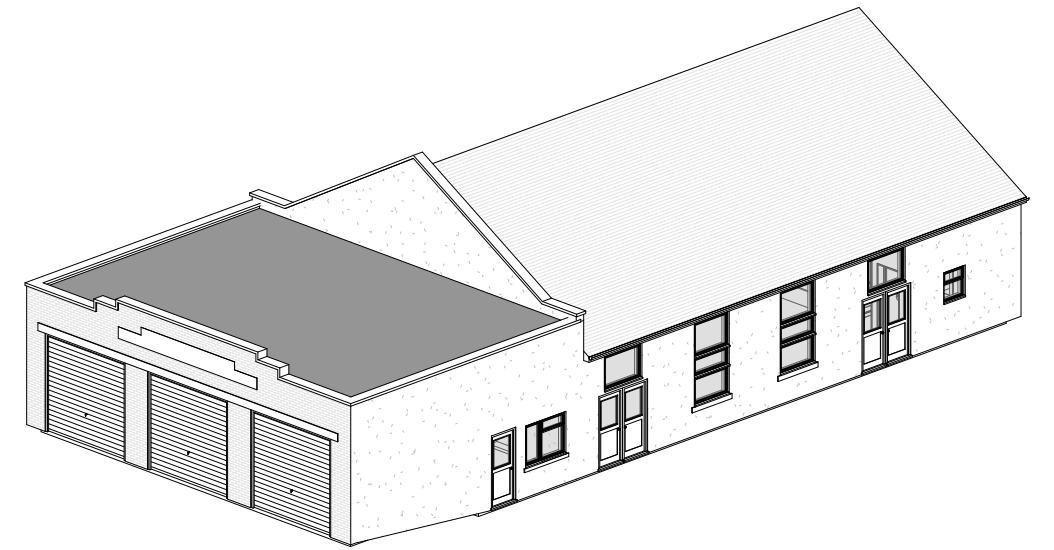

3D View 2

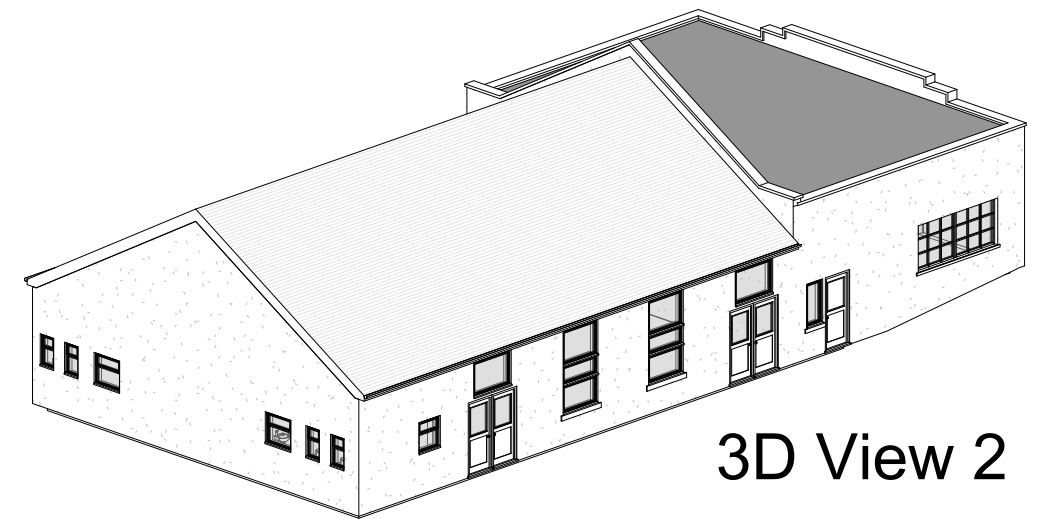

Site Plan



FLUENT
ARCHITECTURAL DESIGN SERVICES
TEL: 0800 043 8838
E-MAIL: INFO@FLUENT-ADS.CO.UK
WEB: FLUENT-ADS.CO.UK

St John Ambulance Memorial Hall, Hall Road

Existing Site Plan and 3D Views

Scale @ A3
1 : 200

Date
20.08.25

Drawn by
NM

 
Drawing number
P.M.100

Project number
2411

Rev
B

Key:

Existing Proposed SVP Boundary line
Existing drainage Proposed drainage Overhead



No.	Description	Date
0	First Draft	
A	Client's comments (1)	02.09.25
B	Client's comments (3)	08.04.26