
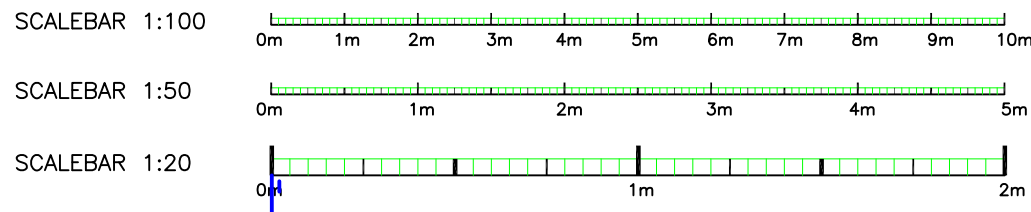
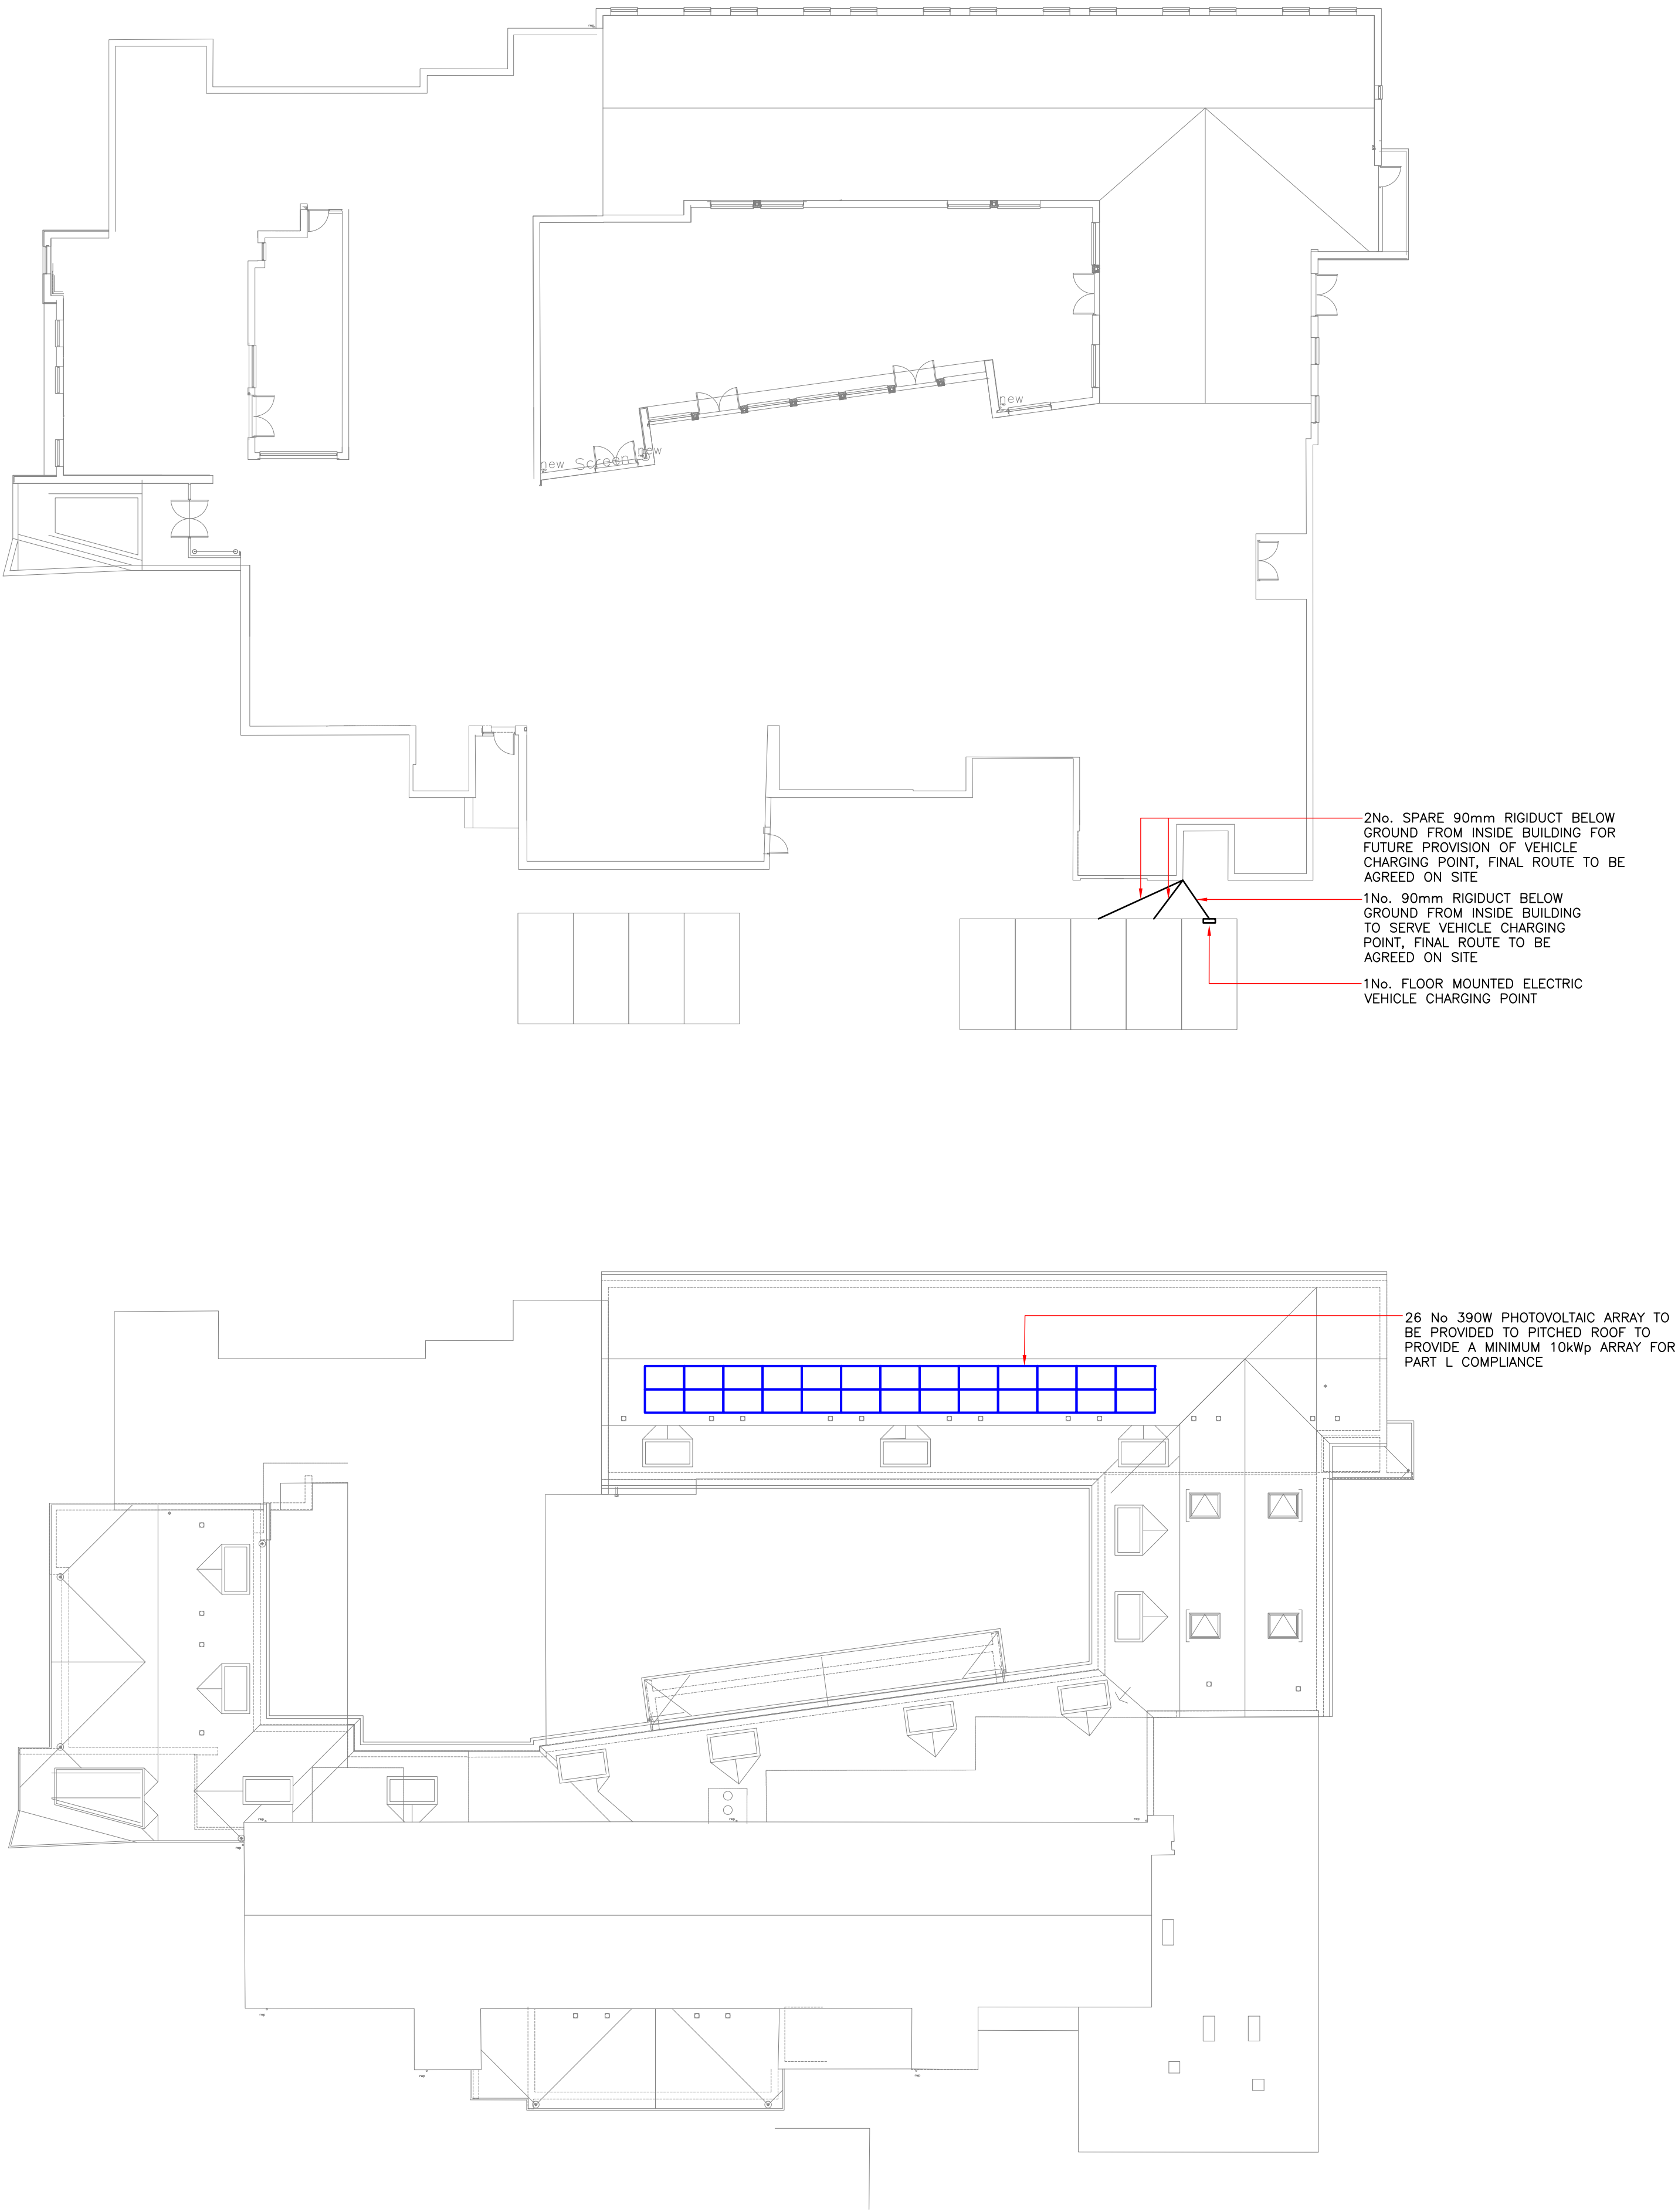


COMPANY OF ORIGIN		ARCHITECTS DRAWING No.	
mka architects		2327/201	
ORIGINAL FILE NAME	2327 Ground Floor Plan		
ORIGINAL DRAWING TITLE	Ground Floor Plan	REV.	DATE RECEIVED
		E	05-04-22

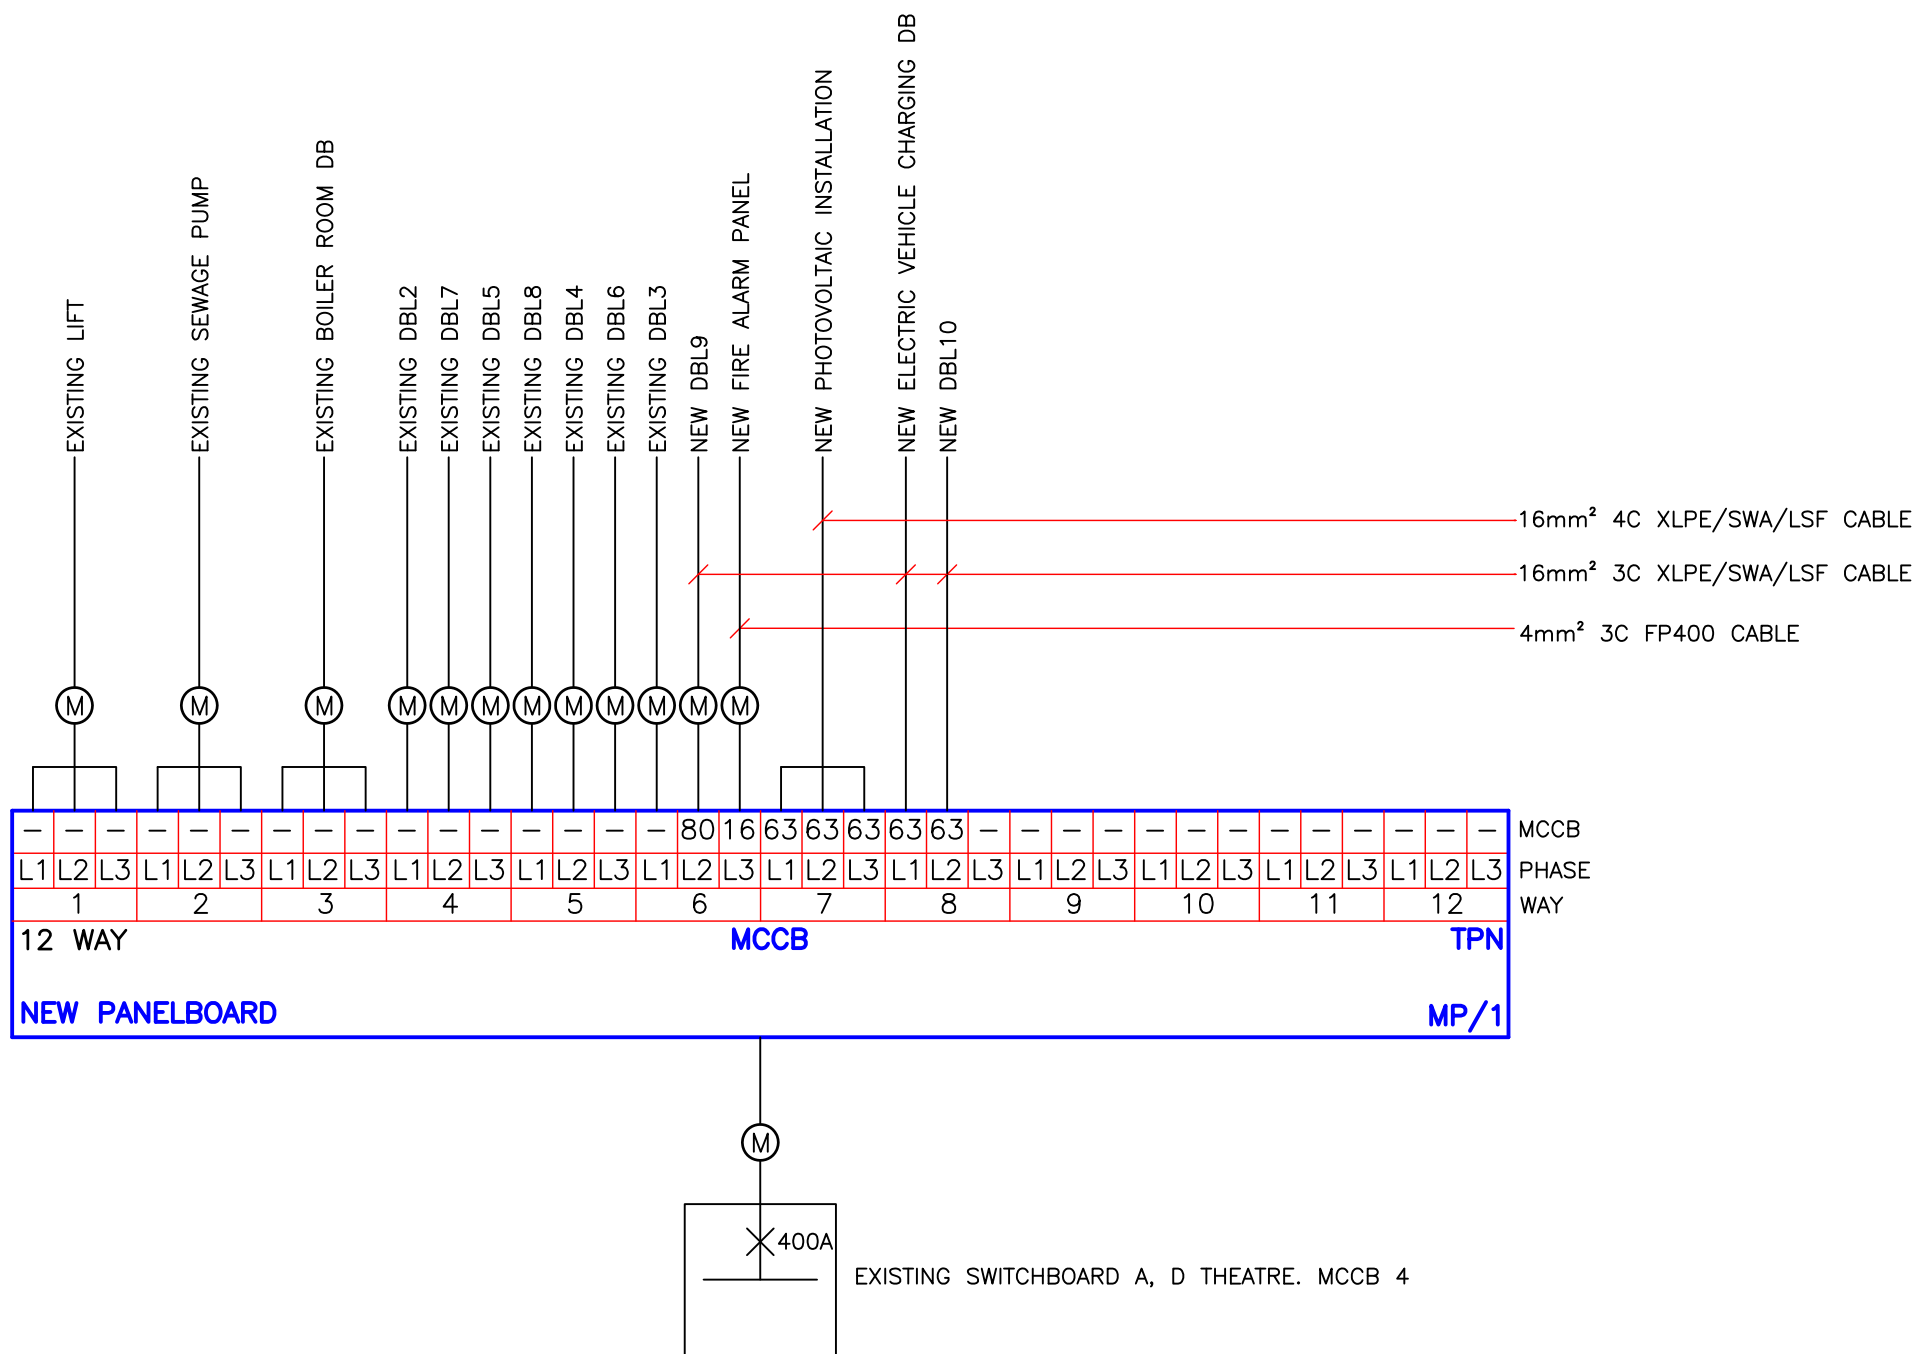

- Notes**
- THIS DRAWING SHALL BE READ IN CONJUNCTION WITH THE SPECIFICATION AND ALL OTHER ENGINEERING AND ARCHITECTURAL DRAWINGS.
 - EXACT POSITIONS AND MOUNTING HEIGHTS OF ALL EQUIPMENT TO BE AGREED WITH THE ARCHITECT BEFORE THE INSTALLATION IS COMMENCED.

T2	25.04.23	SCALEBARS ADDED	NL	MD
T1	25.04.22	TENDER ISSUE	CH	MD
Rev	Date	Notes	Dwn	Chk

NORMAN BROMLEY
PARTNERSHIP

Consulting Engineers

Bridge House,
97-101 High Street,
Tonbridge,
Kent. TN9 1DR

Tel. No. (01732) 773737 Fax No. (01732) 773353
Email: mail@normanbromley.co.uk

Client

MR & MRS GILMOUR

Project

HEVERCOURT RESIDENTIAL
HOME REFURBISHMENT

Service

ELECTRICAL ENGINEERING

Title

ELECTRICAL DISTRIBUTION SCHEMATIC
ROOF LAYOUT & SITE PLAN
ELECTRICAL SERVICES LAYOUT

Scale	Date	Drawn	Approved
1:100@A1	APR21	CH	MD
Drawing No.	Rev.		
EBS 2022/5	T2		