


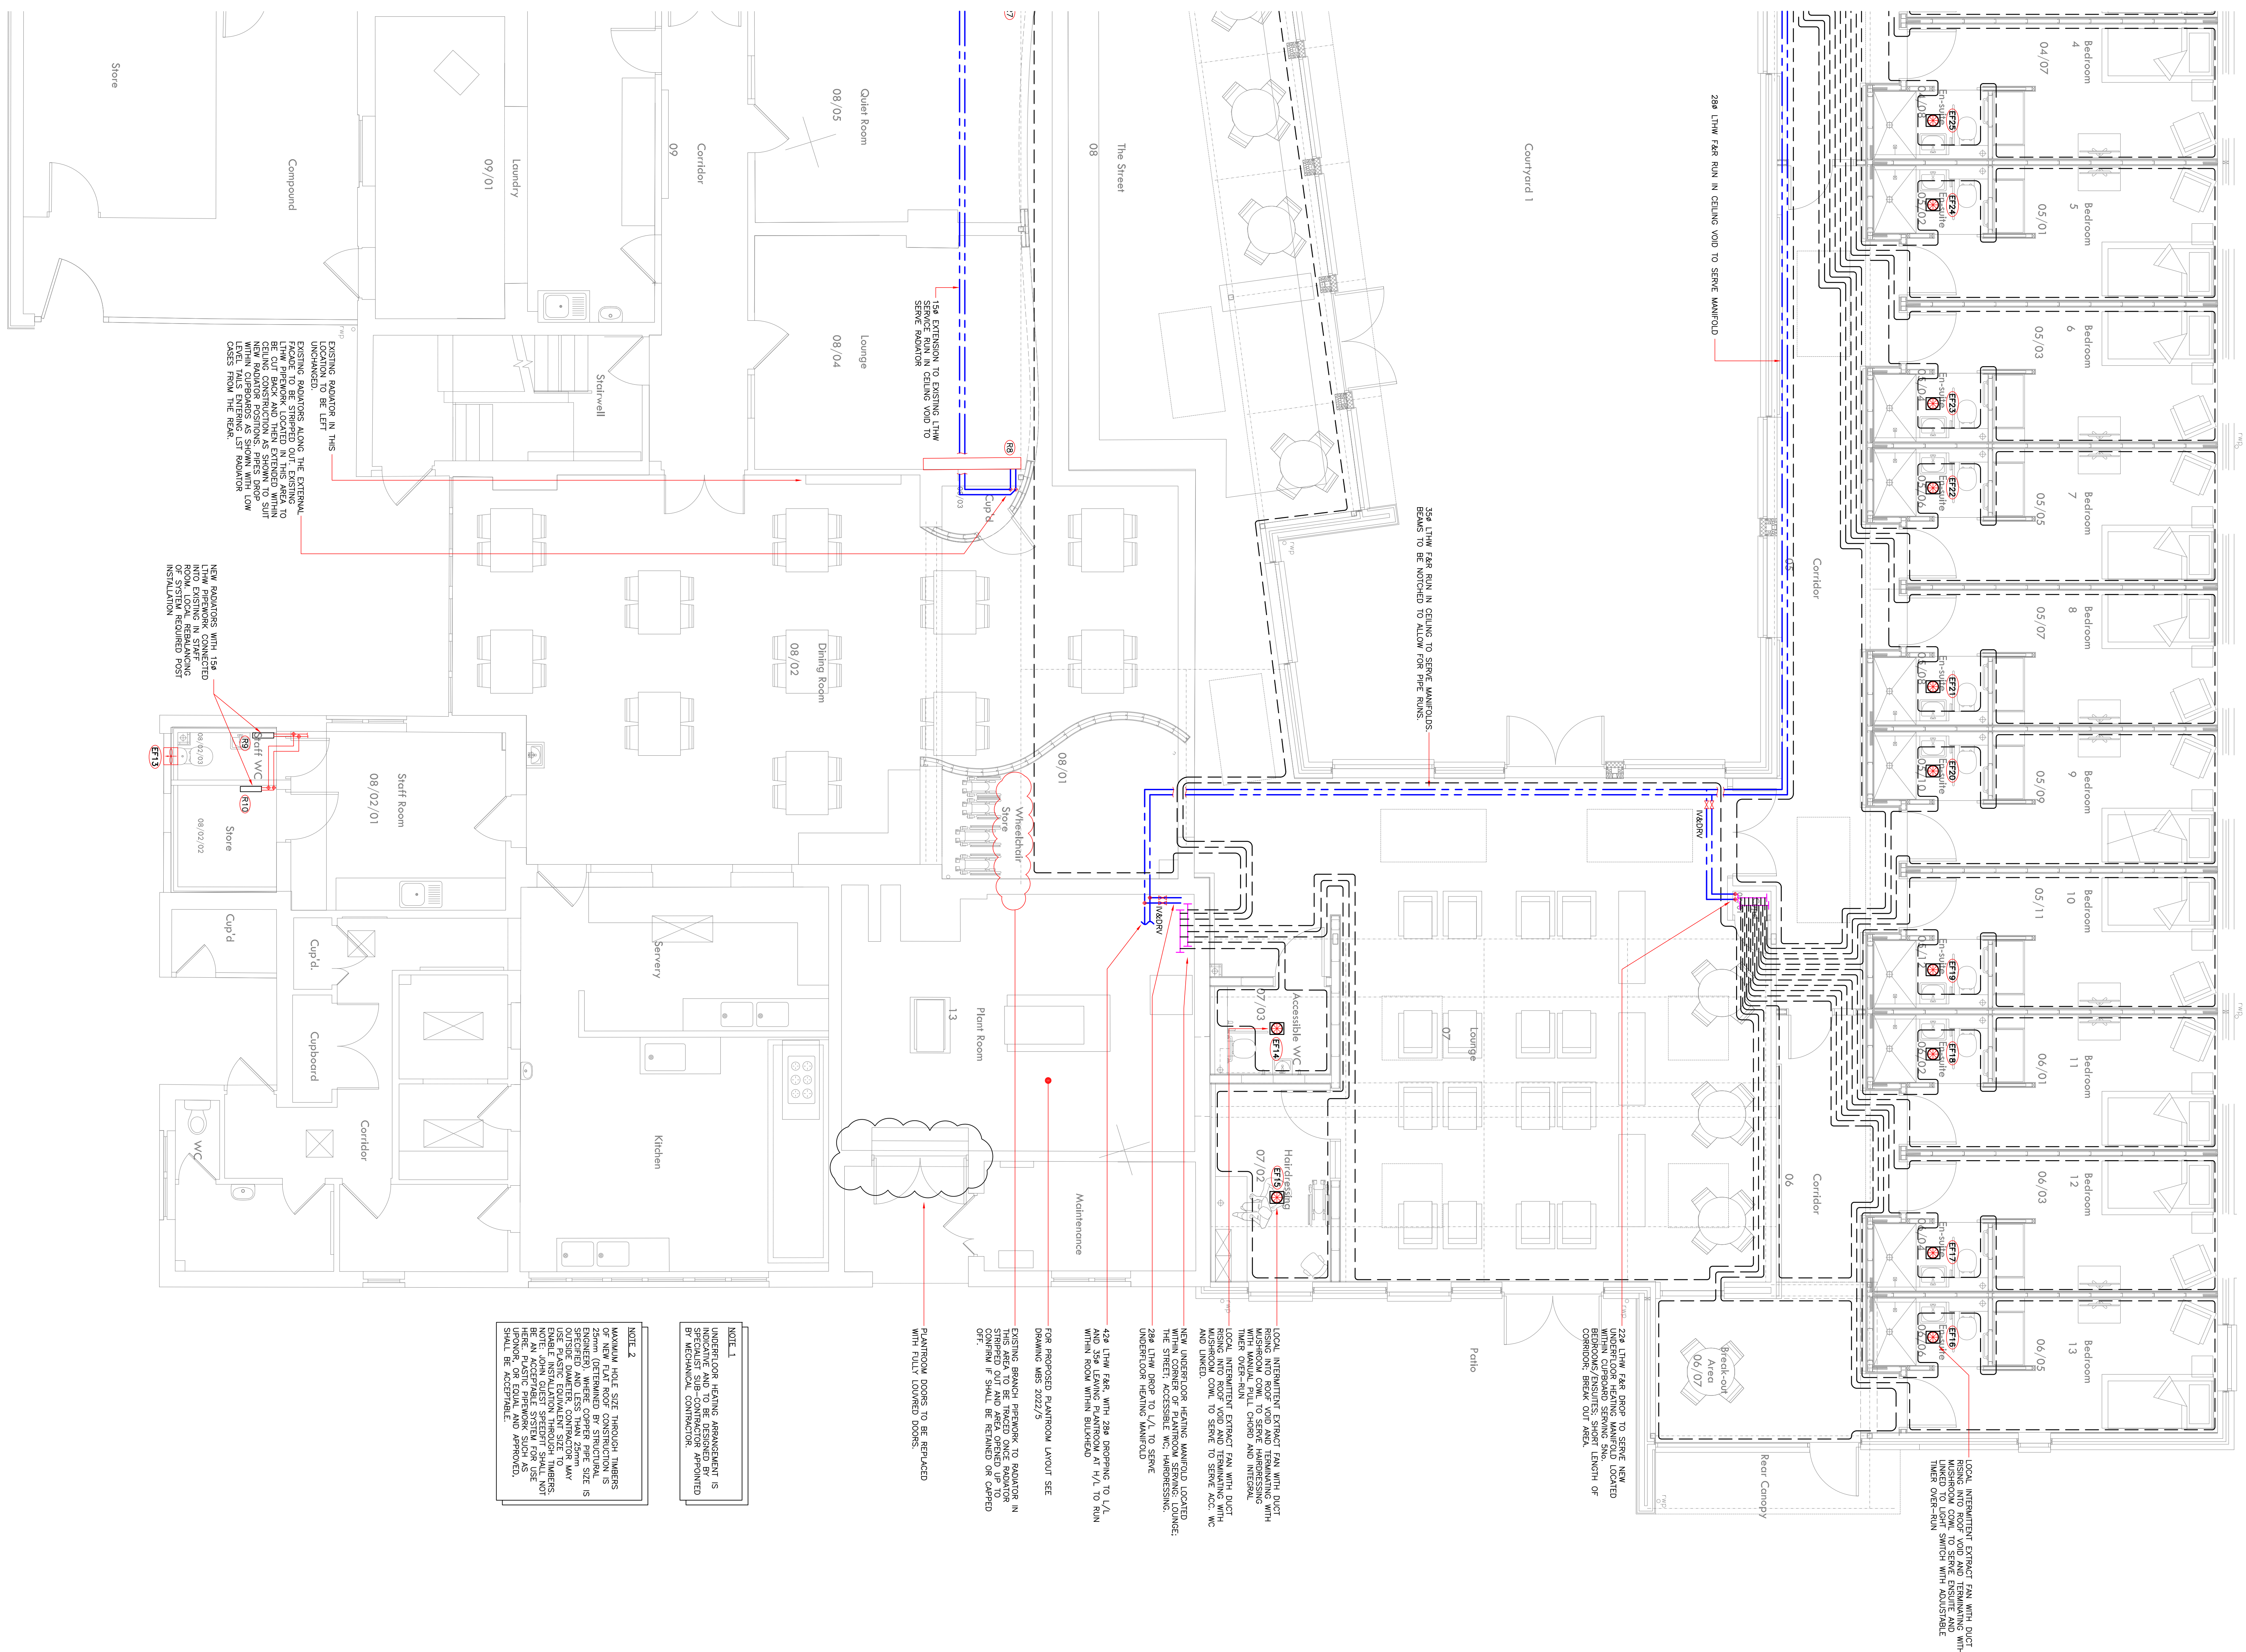


FOR CONTINUATION SEE DRG. No. MBS 2022/3

Notes

1. THIS DRAWING SHALL BE READ IN CONJUNCTION WITH THE SPECIFICATION AND ALL OTHER ENGINEERING AND ARCHITECTURAL DRAWINGS.
2. EXACT POSITIONS AND MOUNTING HEIGHTS OF ALL EQUIPMENT TO BE ASSESSED WITH THE ARCHITECT BEFORE THE INSTALLATION IS COMMENCED.

Notes	
1.	THIS DRAWING SHALL BE READ IN CONJUNCTION WITH THE SPECIFICATION AND ALL OTHER ENGINEERING AND CONTRACT DOCUMENTS.
2.	EXACT POSITIONS AND MOUNTING HEIGHTS OF ALL EQUIPMENT TO BE MATED WITH THE APPLICABLE BRAND THE MANUFACTURER IS CHARGED TO.

Rev	Date	Notes	By	Chk
T2	25/6/23	SCALEBAR ADDED	NL	MD
T1	20/6/22	TENDER ISSUE	JP	DB
			CM	CM

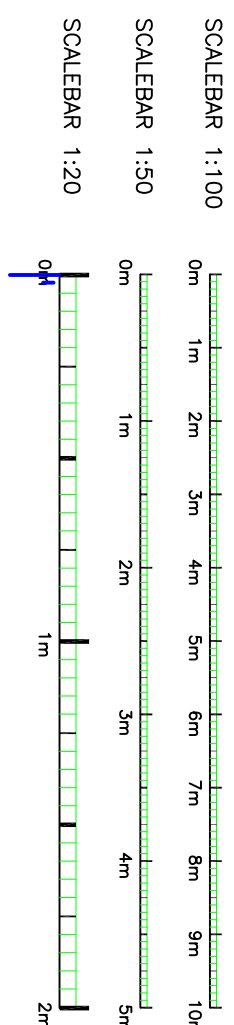

TENDER

Project HEALTHCARE RESIDENTIAL HOME RENOVATION	
Client MR & MRS GILMOUR	
Site PROPOSED HEATING & VENTILATION LAYOUTS SHEET 2 OF 2	
Drawing No. MBS 2022/4	
Scale 1:200/30	Date May22
Drawn CG	Approved CG
Rev. 12	