





100mm

50mm

10mm

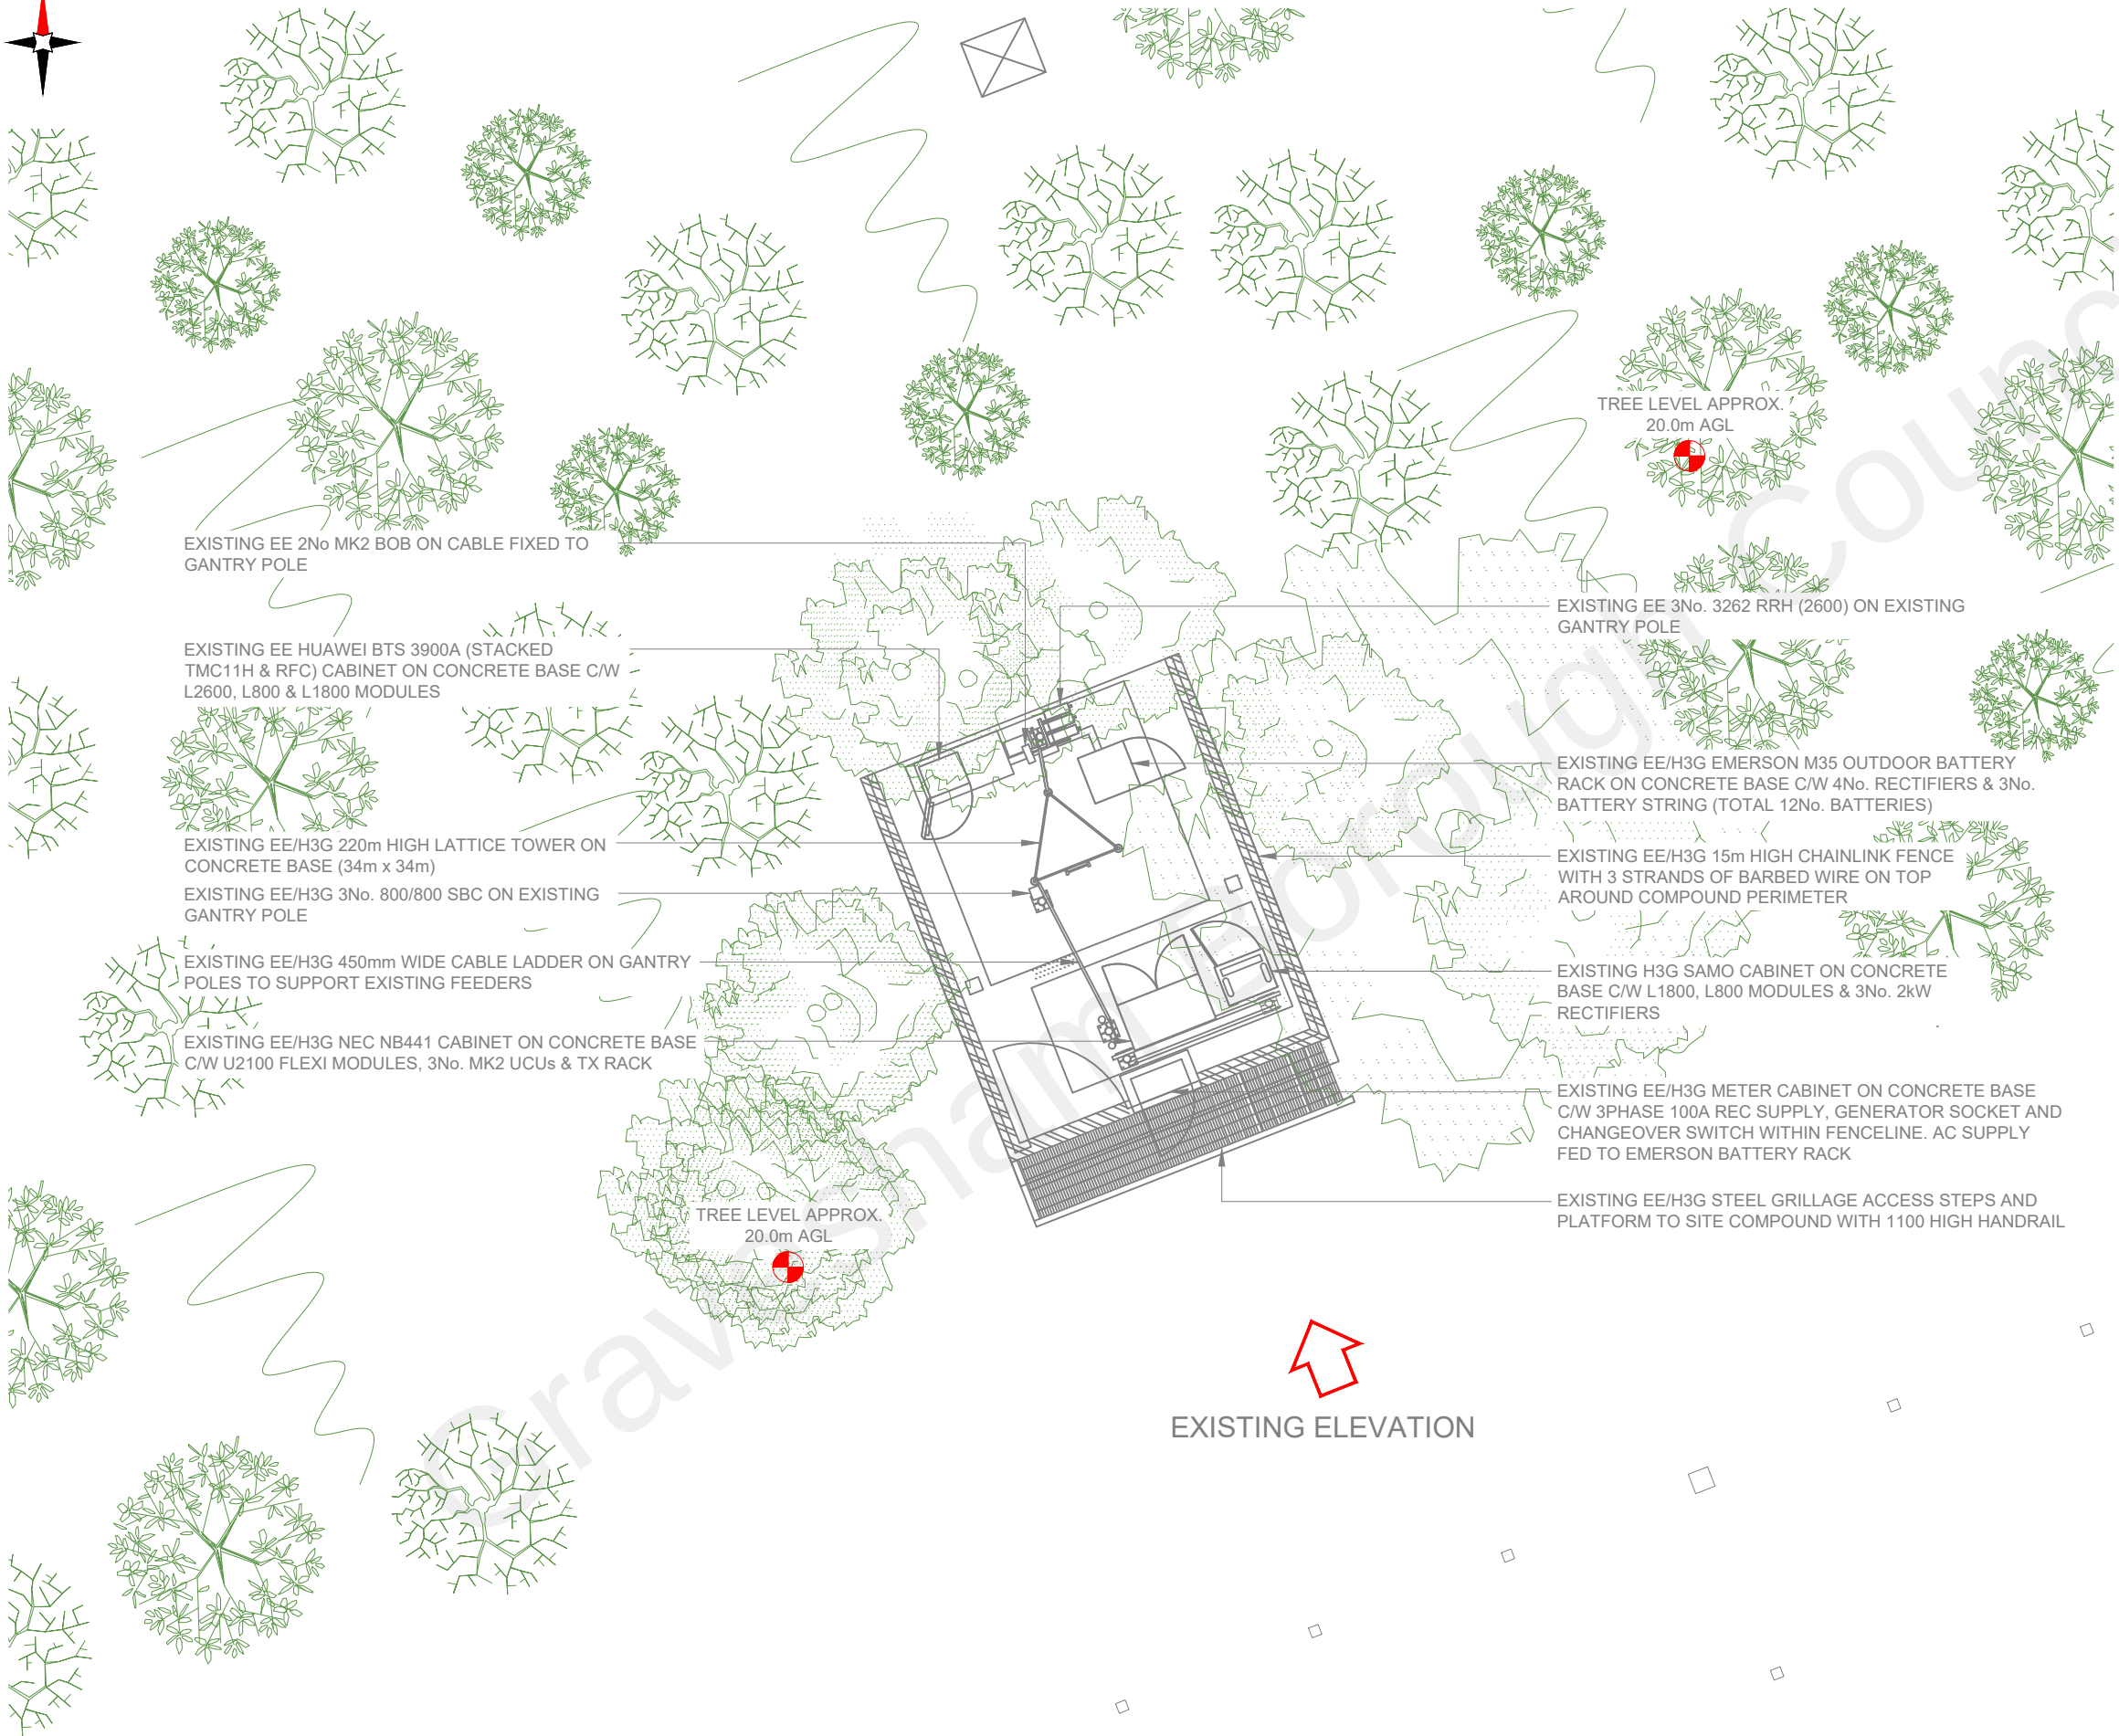

 EXISTING SITE PLAN



NOTES:

1. ALL DIMENSIONS IN MM UNLESS OTHERWISE NOTED.

Master:	MBNL / EE / H3G:	Project:	Purpose of Issue:	Issue:
M003	H3G	3UK UNILATERAL	Planning	C
Date:	11/11/2021	Revision / Upgrade Description:		
Drawn:	A.McEngo	ERS ,Routers & Filters Relocated		
Checked:	A.Fanning			
Approved:	A.Fanning			
Master:	MBNL / EE / H3G:	Project:	Purpose of Issue:	Issue:
M002	H3G	3UK UNILATERAL	Planning	B
Date:	08/09/2021	Revision / Upgrade Description:		
Drawn:	COM Group	Antenna Bearings Amended		
Checked:	B. Ormshaw			
Approved:	D. Cross			
Master:	MBNL / EE / H3G:	Project:	Purpose of Issue:	Issue:
M001	H3G	3UK UNILATERAL	Planning	A
Date:	27/07/2021	Revision / Upgrade Description:		
Drawn:	COM Group	First Issue		
Checked:	B. Ormshaw			
Approved:	D. Cross			



Hutchison 3G UK Limited
Star House, 20 Grenfell Road
Maidenhead, SL6 1EH
Tel: 01628 765 000
Fax: 01628 765 001

H3G Base Station Information line:
0845 6043000
Available 8am-8pm Monday to Friday

Design Consultant & Principal Contractor:



WHP Telecoms Ltd
Unit 1 Maple Park
Lowfields Road, Leeds
LS12 6HH

Tel: 0113 3023550 Fax: 0113 2876834
e-mail: info@whptelecoms.com

Site Name: **COLEWOOD**

Site ID: **1102392**

Address:
**COLEWOOD
NEW KNIGHTS PLACE
ROCHESTER, KENT
ME2 2TZ**

Title: **100 EXISTING SITE PLAN**

Project: **3UK UNILATERAL**

Purpose of Issue: **GENERAL ARRANGEMENT**

EE Cell ID: 21832	MBNL Cell ID: GVM026	3UK Cell ID: DA0105
-----------------------------	--------------------------------	-------------------------------

Master Drawing No: 1102392_GVM026_21832_DA0105_M003_H3G_UNI_GA_C	Issue: C
---	--------------------