


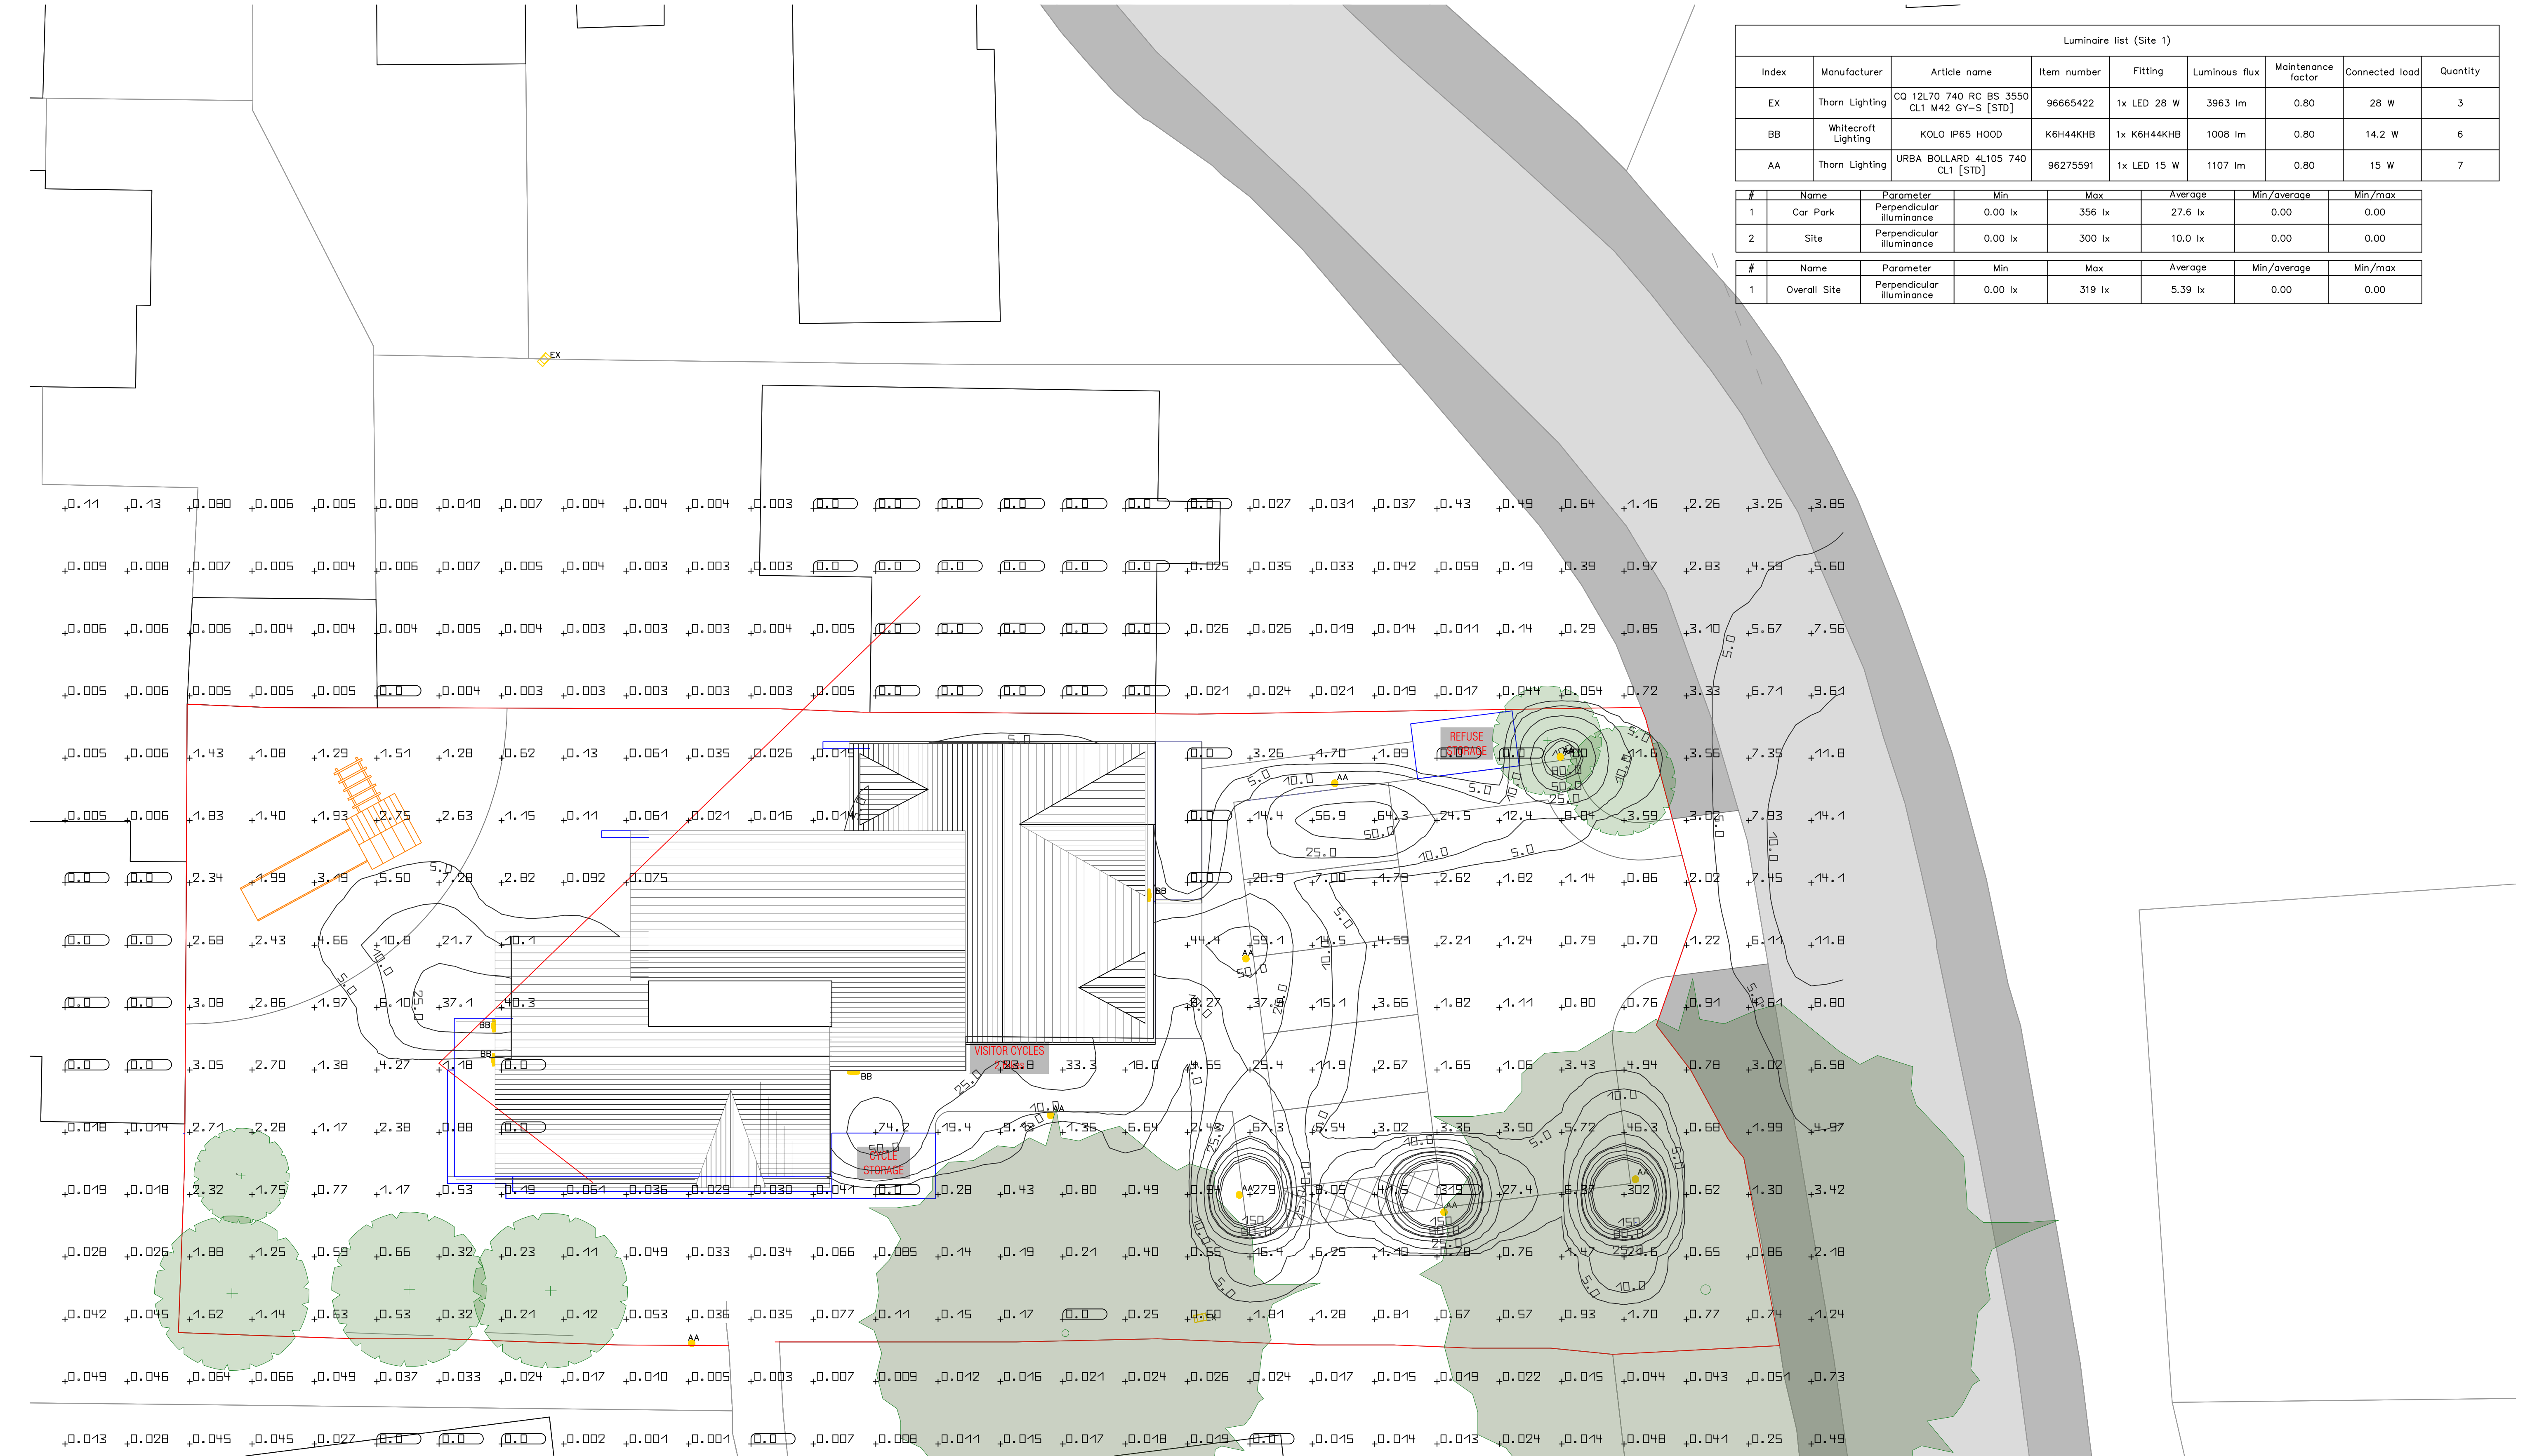

Luminaire list (Site 1)									
Index	Manufacturer	Article name	Item number	Fitting	Luminous flux	Maintenance factor	Connected load	Quantity	
EX	Thorn Lighting	CQ 12L70 740 RC BS 3550 CL1 M42 GY-S [STD]	96665422	1x LED 28 W	3963 lm	0.80	28 W	3	
BB	Whitecroft Lighting	KOLO IP65 HOOD	K6H44KHB	1x K6H44KHB	1008 lm	0.80	14.2 W	6	
AA	Thorn Lighting	URBA BOLLARD 4L105 740 CL1 [STD]	96275591	1x LED 15 W	1107 lm	0.80	15 W	7	

#	Name	Parameter	Min	Max	Average	Min/average	Min/max
1	Car Park	Perpendicular Illuminance	0.00 lx	356 lx	27.6 lx	0.00	0.00
2	Site	Perpendicular Illuminance	0.00 lx	300 lx	10.0 lx	0.00	0.00

#	Name	Parameter	Min	Max	Average	Min/average	Min/max
1	Overall Site	Perpendicular Illuminance	0.00 lx	319 lx	5.39 lx	0.00	0.00

COPYRIGHT ©

FIGURED DIMENSIONS ONLY ARE TO BE USED. FOR OTHER DIMENSIONS REFER TO CA. ALL DIMENSIONS TO BE CHECKED ON SITE PRIOR TO THE COMMENCEMENT OF WORK. DISCREPANCIES, AMBIGUITIES OR DIFFERENCES BETWEEN DRAWINGS, AND BETWEEN DRAWINGS AND SPECIFICATION OR BILLS OF QUANTITIES TO BE REFERRED TO CA WITHOUT DELAY.

DO NOT SCALE THIS DRAWING

GENERAL NOTES:

- THIS DRAWING MUST NOT BE USED FOR CONSTRUCTION PURPOSES OR INSTALLATION PURPOSES UNLESS EXPRESSLY STATED
- DO NOT SCALE OFF THIS DRAWING. ALWAYS WORK TO NOTED DIMENSIONS
- ALL DRAWINGS MUST BE VERIFIED ON SITE BEFORE COMPLETING SHOP DRAWINGS OR SETTING OUT WORKS

- THIS DRAWING IS TO BE READ IN CONJUNCTION WITH THE M&E SPECIFICATION PREPARED BY 'THE DESIGN COLLECTIVE'
- THIS DRAWING IS TO BE READ IN CONJUNCTION WITH ALL ARCHITECTURAL & STRUCTURAL ENGINEERS DRAWINGS & ASSOCIATED DESIGN DRAWINGS PRODUCED BY 'THE DESIGN COLLECTIVE'
- ALL DIMENSIONS IN MILLIMETRES (mm)
- THIS DRAWING IS UNDER COPYRIGHT AND AT NO TIME MUST ANY PORTION OF THIS DRAWING BE REPRODUCED OR COPIED IN ANY WAY WITHOUT THE PERMISSION OF 'THE DESIGN COLLECTIVE'
- ALL WORKS ON SITE ARE TO COMPLY WITH THE RELEVANT BRITISH STANDARDS, CODES OF PRACTICE AND CURRENT BUILDING REGULATIONS
- ANY DISCREPANCIES BETWEEN ALL WORKING DRAWINGS, SPECIFICATIONS & SCHEDULES OF ALL DISCIPLINES TO BE NOTIFIED TO 'THE DESIGN COLLECTIVE' FOR CLARIFICATION/CORRECTION PRIOR TO CONSTRUCTION

1	13/12/25	ISSUED FOR INFORMATION-	DS	DS
0	30/10/25	ISSUED FOR INFORMATION-	DS	DS
Rev	Date	Description	Drawn	Eng
ARCHITECTS LAYOUT				
1354-48-FCG-XX-XX-DR-B-110 REV H				

THE DESIGN COLLECTIVE

Somerset House
47-49 London Road
Redhill, Surrey
RH1 1LU
Tel: 0208 391 5122
E-Mail: info@thedesigncollective.net
Web: www.thedesigncollective.net

PROJECT:

GBC STRAND CLOSE
Gravesend DA13 0HB.

CLIENT:

Frankham Projects Limited

TITLE:

PROPOSED EXTERNAL LIGHTING LAYOUT
LIGHTING LEVELS

SCALE:

1:100@A1

DRAWN:

MC

DATE:

DECEMBER 25

DWG No.

TDC25120-ALL-ALL-E-1200

REVISION: 1