


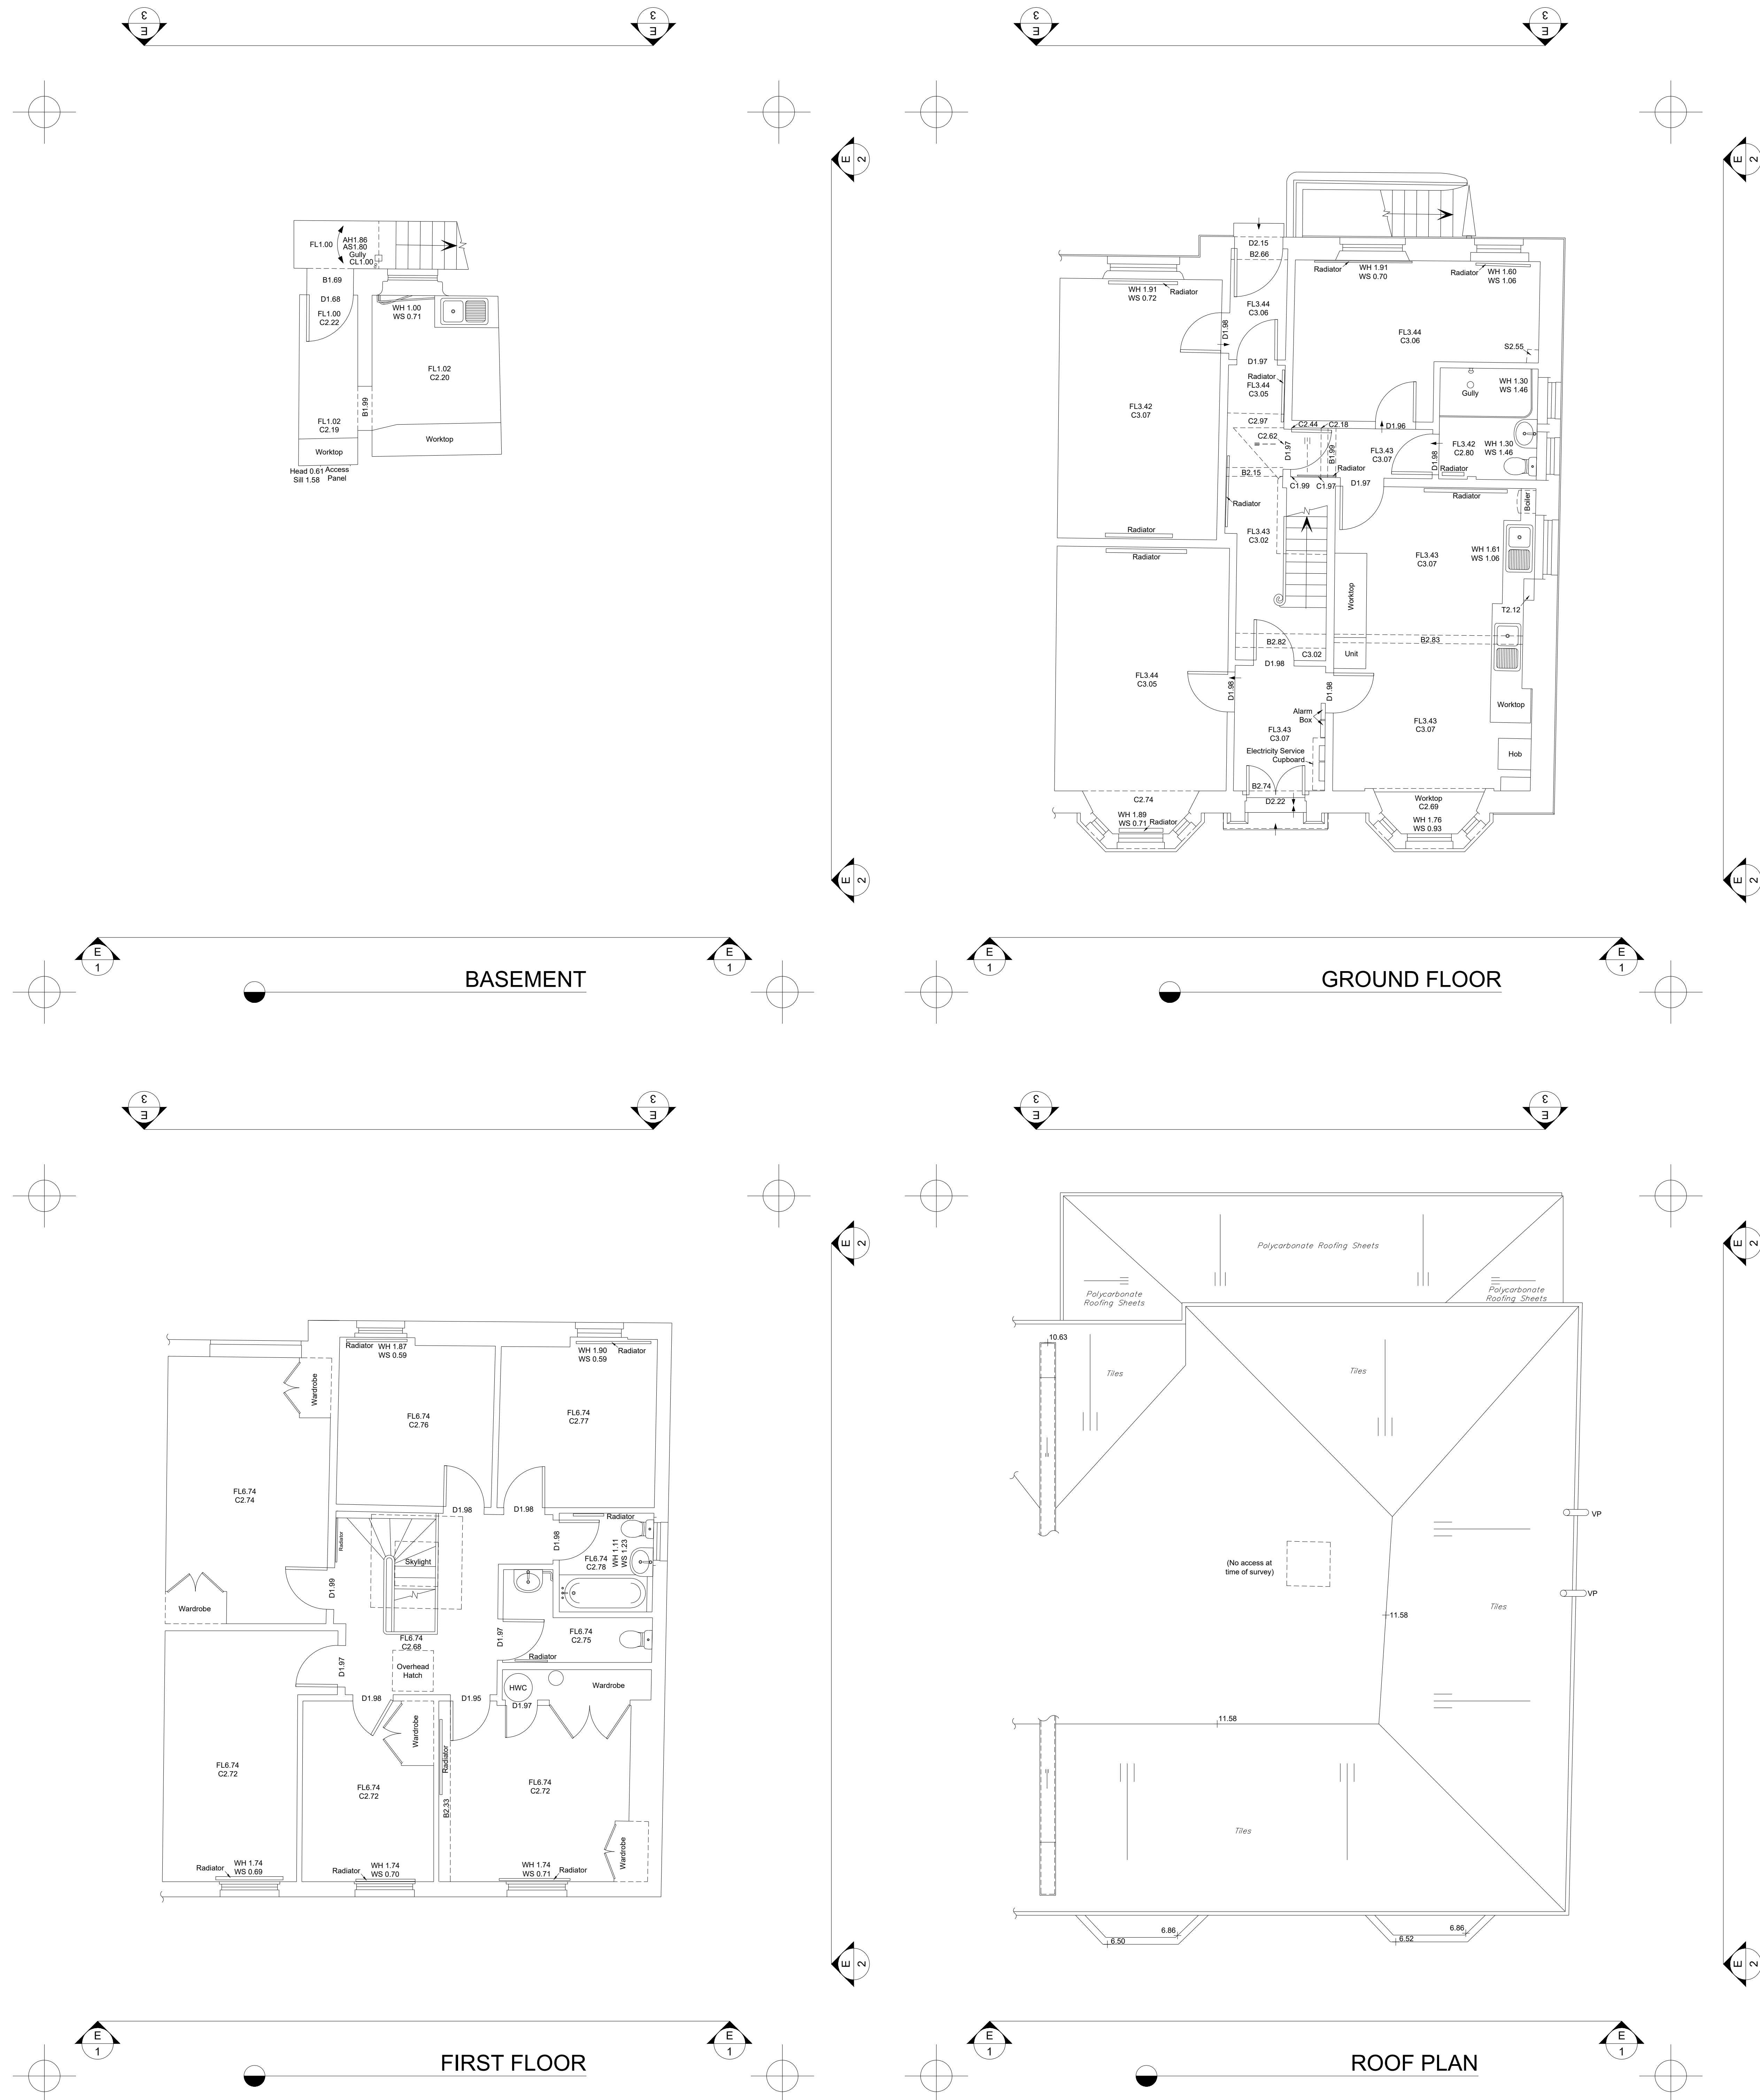

GENERAL NOTES

ALL INTERIOR DIMENSIONS INCLUDING CEILING HEIGHTS ARE TAKEN TO AND FROM FINISHED SURFACES UNLESS OTHERWISE STATED. ALL LEVELS AND DIMENSIONS MUST BE CHECKED ON SITE. ANY DISCREPANCIES WITH THE INFORMATION DETICTED IN THIS DRAWING MUST BE REPORTED TO THE DESIGN TEAM IMMEDIATELY. THE INFORMATION DETICTED IN THIS DRAWING MUST BE USED IN CONJUNCTION WITH THE INFORMATION DETICTED IN THE DRAWING. THE INFORMATION DETICTED IN THIS DRAWING MUST NOT BE REPRODUCED OR TRANSMITTED IN ANY FORM OR BY ANY MEANS, ELECTRONIC OR MECHANICAL, INCLUDING PHOTOCOPYING, RECORDING, OR BY ANY INFORMATION STORAGE AND RETRIEVAL SYSTEM. THE INFORMATION DETICTED IN THIS DRAWING MUST NOT BE USED IN ANY CONSTRUCTION WORK.

SURVEY GRID

PLEASE NOTE THAT GRID SHOWN ON THIS DRAWING IS AS FOLLOWS

● ARBITRARY

○ ARBITRARY BUT APPROXIMATELY RELATED TO GRID NORTH

○ BEST FIT TO ORDNANCE SURVEY DIGITAL DATA

○ ORDNANCE SURVEY NATIONAL GRID USING EPSG:27700

LEVELS AND HEIGHTS

AS ARCH SPRINGER HEIGHT

AM ARCH SPRINGER HEIGHT

B BEAM SOFFIT HEIGHT

C CEILING SOFFIT HEIGHT

D DOOR HEAD HEIGHT

F FLOOR LEVEL

P PLINTH HEIGHT

S SOFFIT HEIGHT

T TRUNKING HEIGHT

W WINDOW SILL HEIGHT

WH WINDOW HEAD HEIGHT

WS WINDOW SILL HEIGHT

PLEASE NOTE: ALL HEIGHTS TAKEN FROM FLOOR LANDING UNLESS OTHERWISE STATED

DATUM: ARBITRARY

DESCRIPTION: N/A

N/A

ABBREVIATIONS (Where Applicable)

AB AIR BRICK

ACU AIR CONDITIONING UNIT

SOL SOLAR

BRW BRICK WALL

BT BRITISH TELECOM

CATV CABLE TELEVISION COVER

CE CLEANING EYE

CL COVER LEVEL

CPS CONCRETE PAVING SLABS

DP DOWN PIPE

ECF ELECTRIC CABLE PIT

EP ELECTRICITY POLE

FM FIRE METER

G GULLY

GSC GAS STOP COCK

GV GAS VALVE

HWC HOT WATER CYLINDER

HTF HEATED TONGUE FILL

IC INSPECTION COVER

LP LAMP POST

MH MANHOLE

MW MANHOLE

MS MANHOLE

NI NO FURTHER INFORMATION

OH OVERHEAD

FLT PAVEMENT LIGHT

R RADIATOR

RG ROAD GULLY

RH RADIATOR HOUSING

RWB ROAD NAME BOARD

RS ROAD SIGN

RW REINFORCED WALL

RWP RADIATOR PIPE

SC STOP COCK

SG SECONDARY GLAZING

SV STOP VALVE

T TRUNKING

TIC TELECOM INSPECTION COVER

TDO TRAP DOOR OVER

TLT TRAFFIC LIGHT

TP TELEGRAPH POLE

TFS TACTILE PAVING SLABS

UL UNABLE TO LIFT

V VENT

VP VENT PIPE

W WINDOW

WM WATER METER

WP WASTE PIPE

FENCE TYPES AND ABBREVIATIONS (Where Applicable)

BRW BRICK WALL

B CLOSE BOARD

CI CORRUGATED IRON

CLX CHAIN LINK

CPX CHESTNUT PALING

IR IRON PALING

PR POST & RAIL

PW POST & WIRE

OB OPEN BOARD

WM WIRE MESH

CLIENT

PROJECT

31 OVERCLIFFE
GRAVESEND DA11 0EH

DRAWING TITLE

FLOOR PLANS &
TOPOGRAPHIC SURVEY

SCALE

1:50

SIZE

A0

DRAWING

100008

DRAWN

YCC

CHECKED

MG/HR

DATE

NOV 2025

MISURA
GEOSPATIAL

Regulated by