




7v7'S Illuminance				
Calculation Points Name	Average	Maximum	Minimum	Min/Avg
7v7 AGP	164 lx	363 lx	58 lx	0.35

9v9'S Illuminance				
Calculation Points Name	Average	Maximum	Minimum	Min/Avg
9v9 AGP	222 lx	418 lx	88 lx	0.40

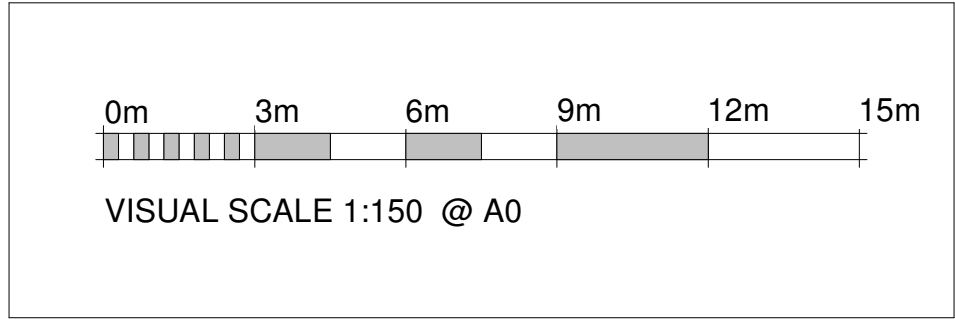



Visual Lighting Design



Energy Saving Solutions

NUMBER

JWM63099

PROJECT

Fleet Leisure

TITLE

7V7 & 9V9 PITCHES

CLIENT

Owner

Rev	Description	Date
R01	Revised 7v7 Pitches	26/05/2021
R02	Revised Pitch Lighting Layout	21/11/2021

DO NOT SCALE

SCALE (@ A0)

DRAWN BY

CHECKED BY

DATE

1: 150

JW


Checker

03/26/21

DRAWING NUMBER


L102



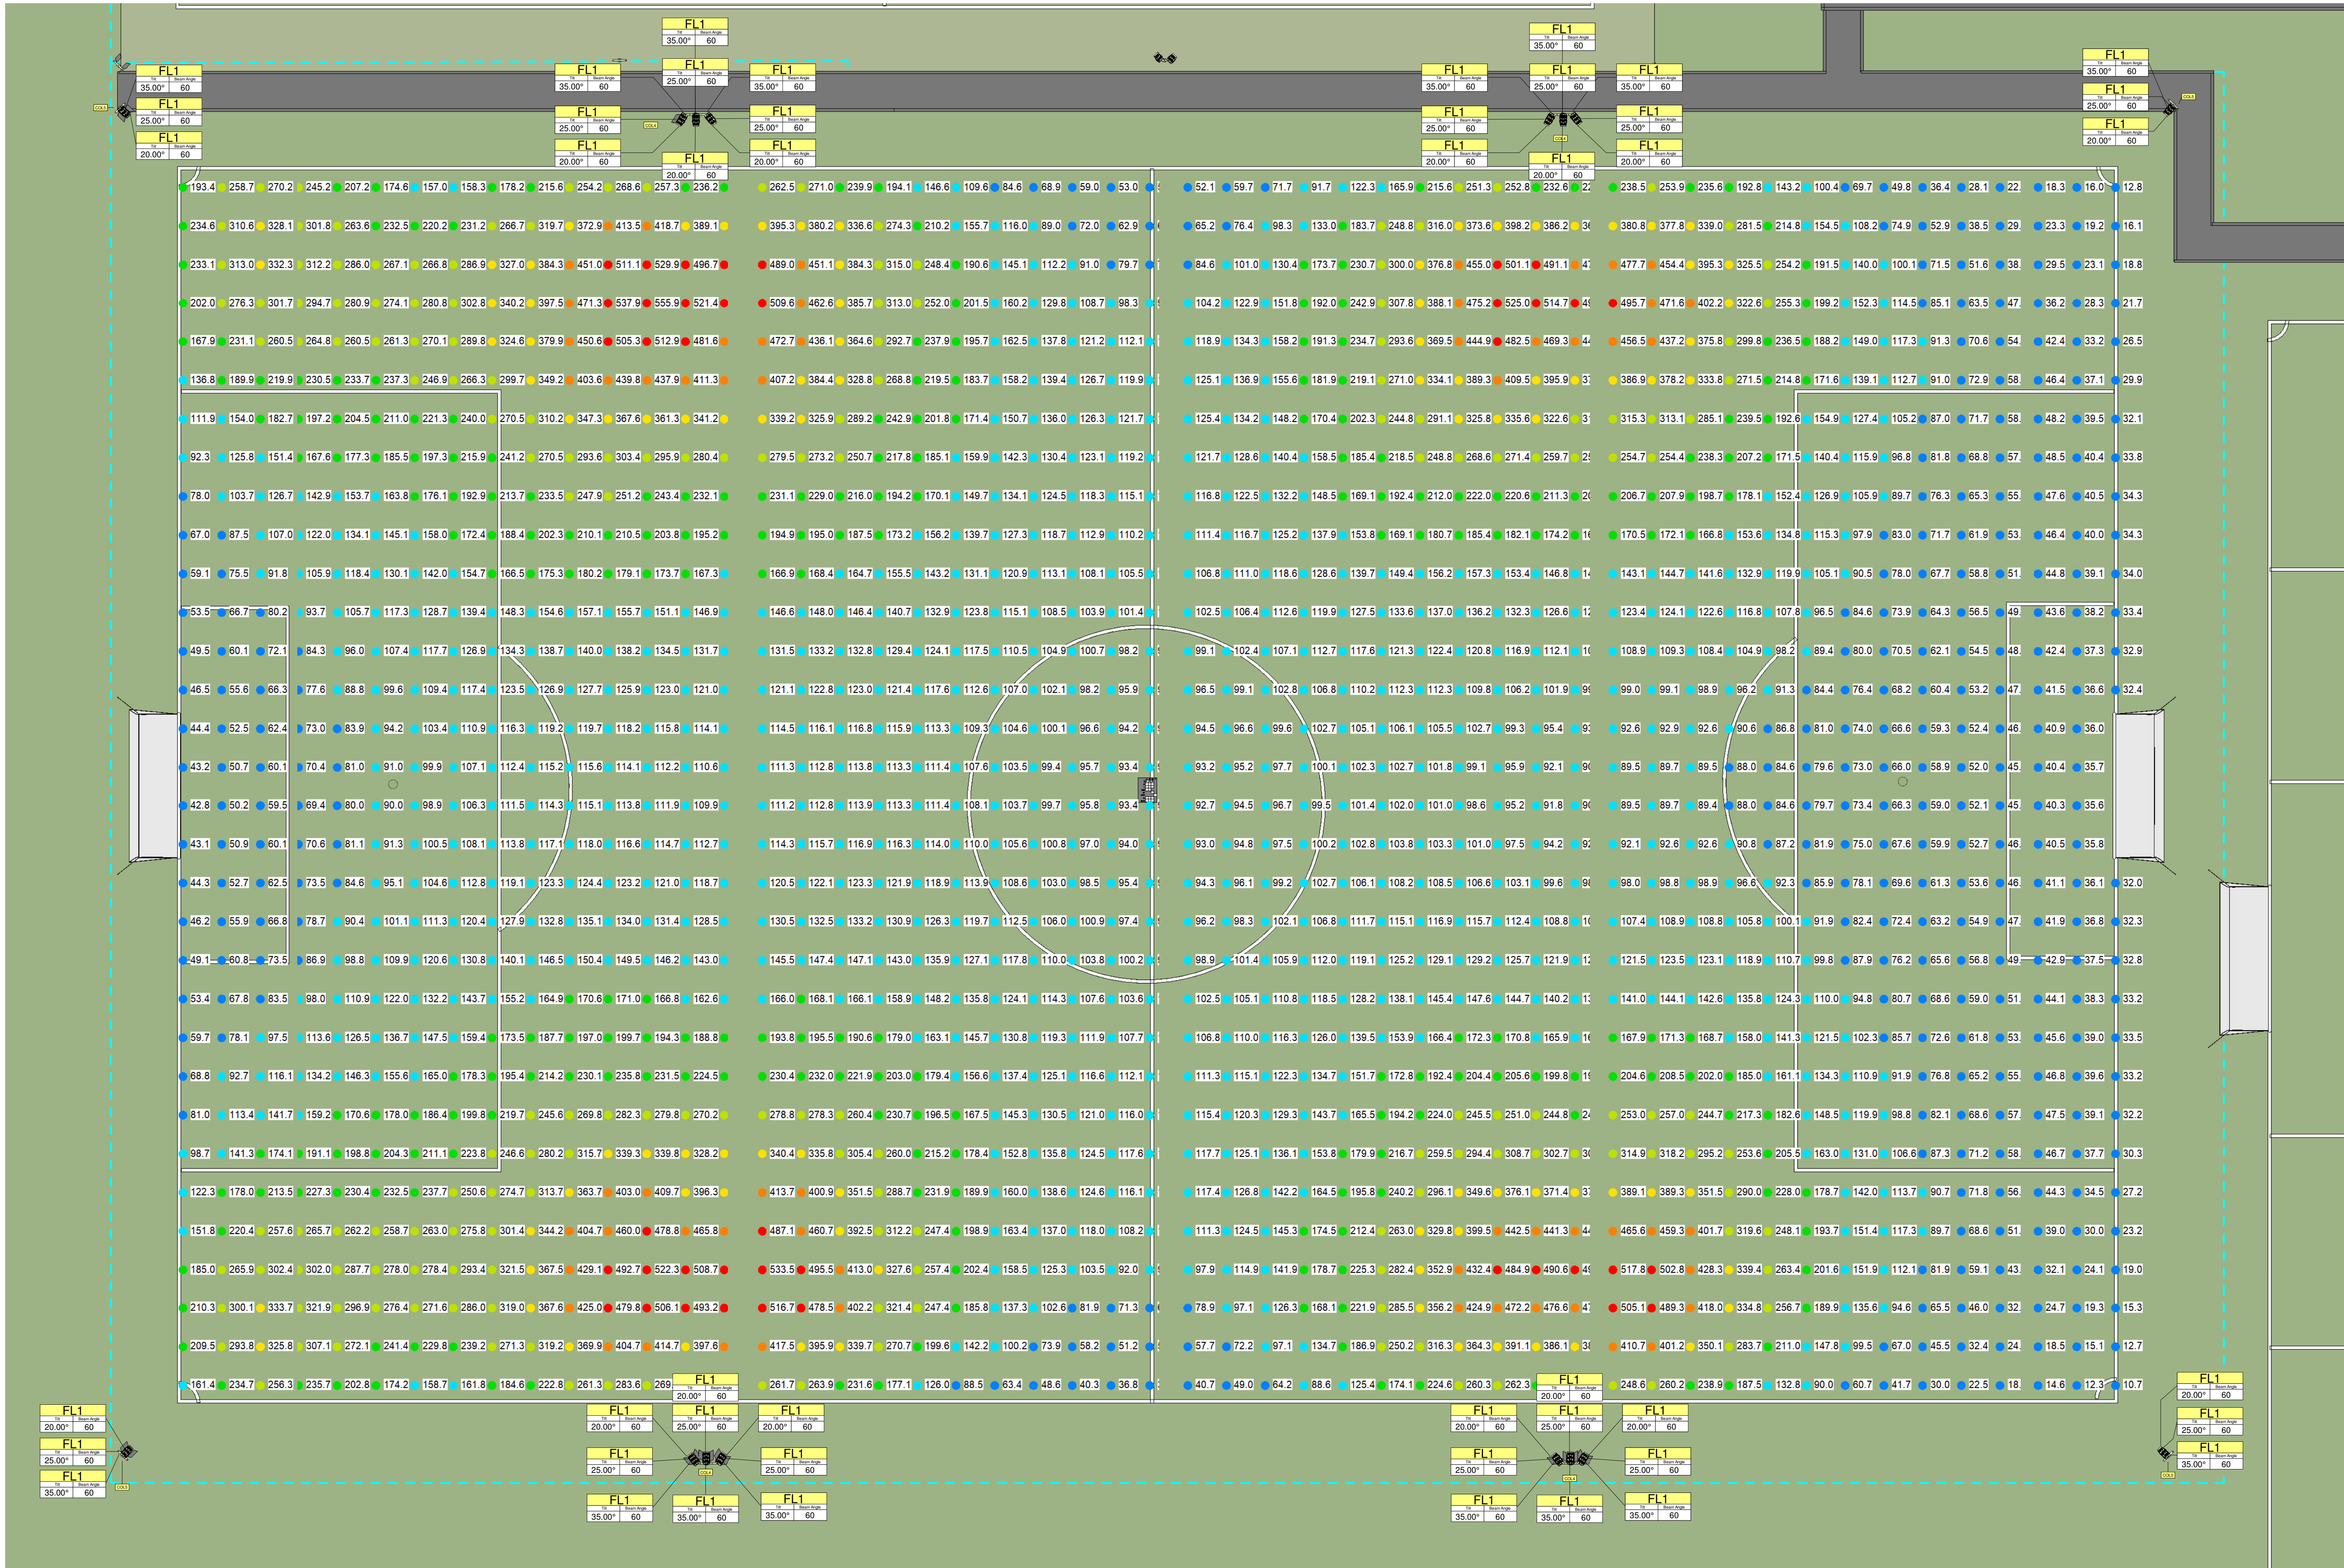

11V11'S Illuminance				
Calculation Points Name	Average	Maximum	Minimum	Min/Avg
11V11 AGP	171 lx	556 lx	11 lx	0.06

Lighting Fixture Schedule 11V11	
Type Mark	Type
COL2	ROOT MOUNT 8M GALV COLUMN 700MM BRACKET
COL4	ROOT MOUNT 10M GALV COLUMN 1300MM BRACKET
COL5	ROOT MOUNT 10M GALV COLUMN 700MM BRACKET
FL1	MGHPAF Flood Light

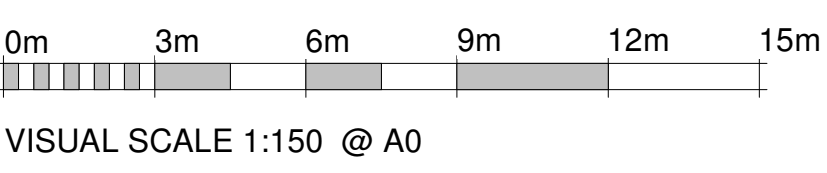

1 11V 11 PITCHES
1 : 150

NUMBER
JWM63099

PROJECT
Fleet Leisure

TITLE
11V11 PITCH

CLIENT
Owner

Rev	Description	Date
R01	Revised 7v7 Pitches	26/05/2021
R02	Revised Pitch Lighting Layout	21/11/2021


DO NOT SCALE

SCALE (@ A0) 1 : 150
DRAWN BY JW
CHECKED BY Checker
DATE 03/26/21


DRAWING NUMBER
L103

R02

EXT OB Light				
Calculation Points Name	Average	Maximum	Minimum	Min/Avg
OB East Garden	0 lx	5.1 lx	0.0 lx	0.00
OB East House Facade	0 lx	0.3 lx	0.0 lx	0.01
OB North Garden	1 lx	7.6 lx	0.0 lx	0.02
OB North House Facade	24 lx	36.2 lx	10.7 lx	0.44
OB South Garden	0 lx	0.8 lx	0.0 lx	0.01
OB South House Facade	1 lx	2.2 lx	0.0 lx	0.04
OB West Garden	1 lx	3.5 lx	0.2 lx	0.18
OB West House Facade	26 lx	34.0 lx	14.8 lx	0.57

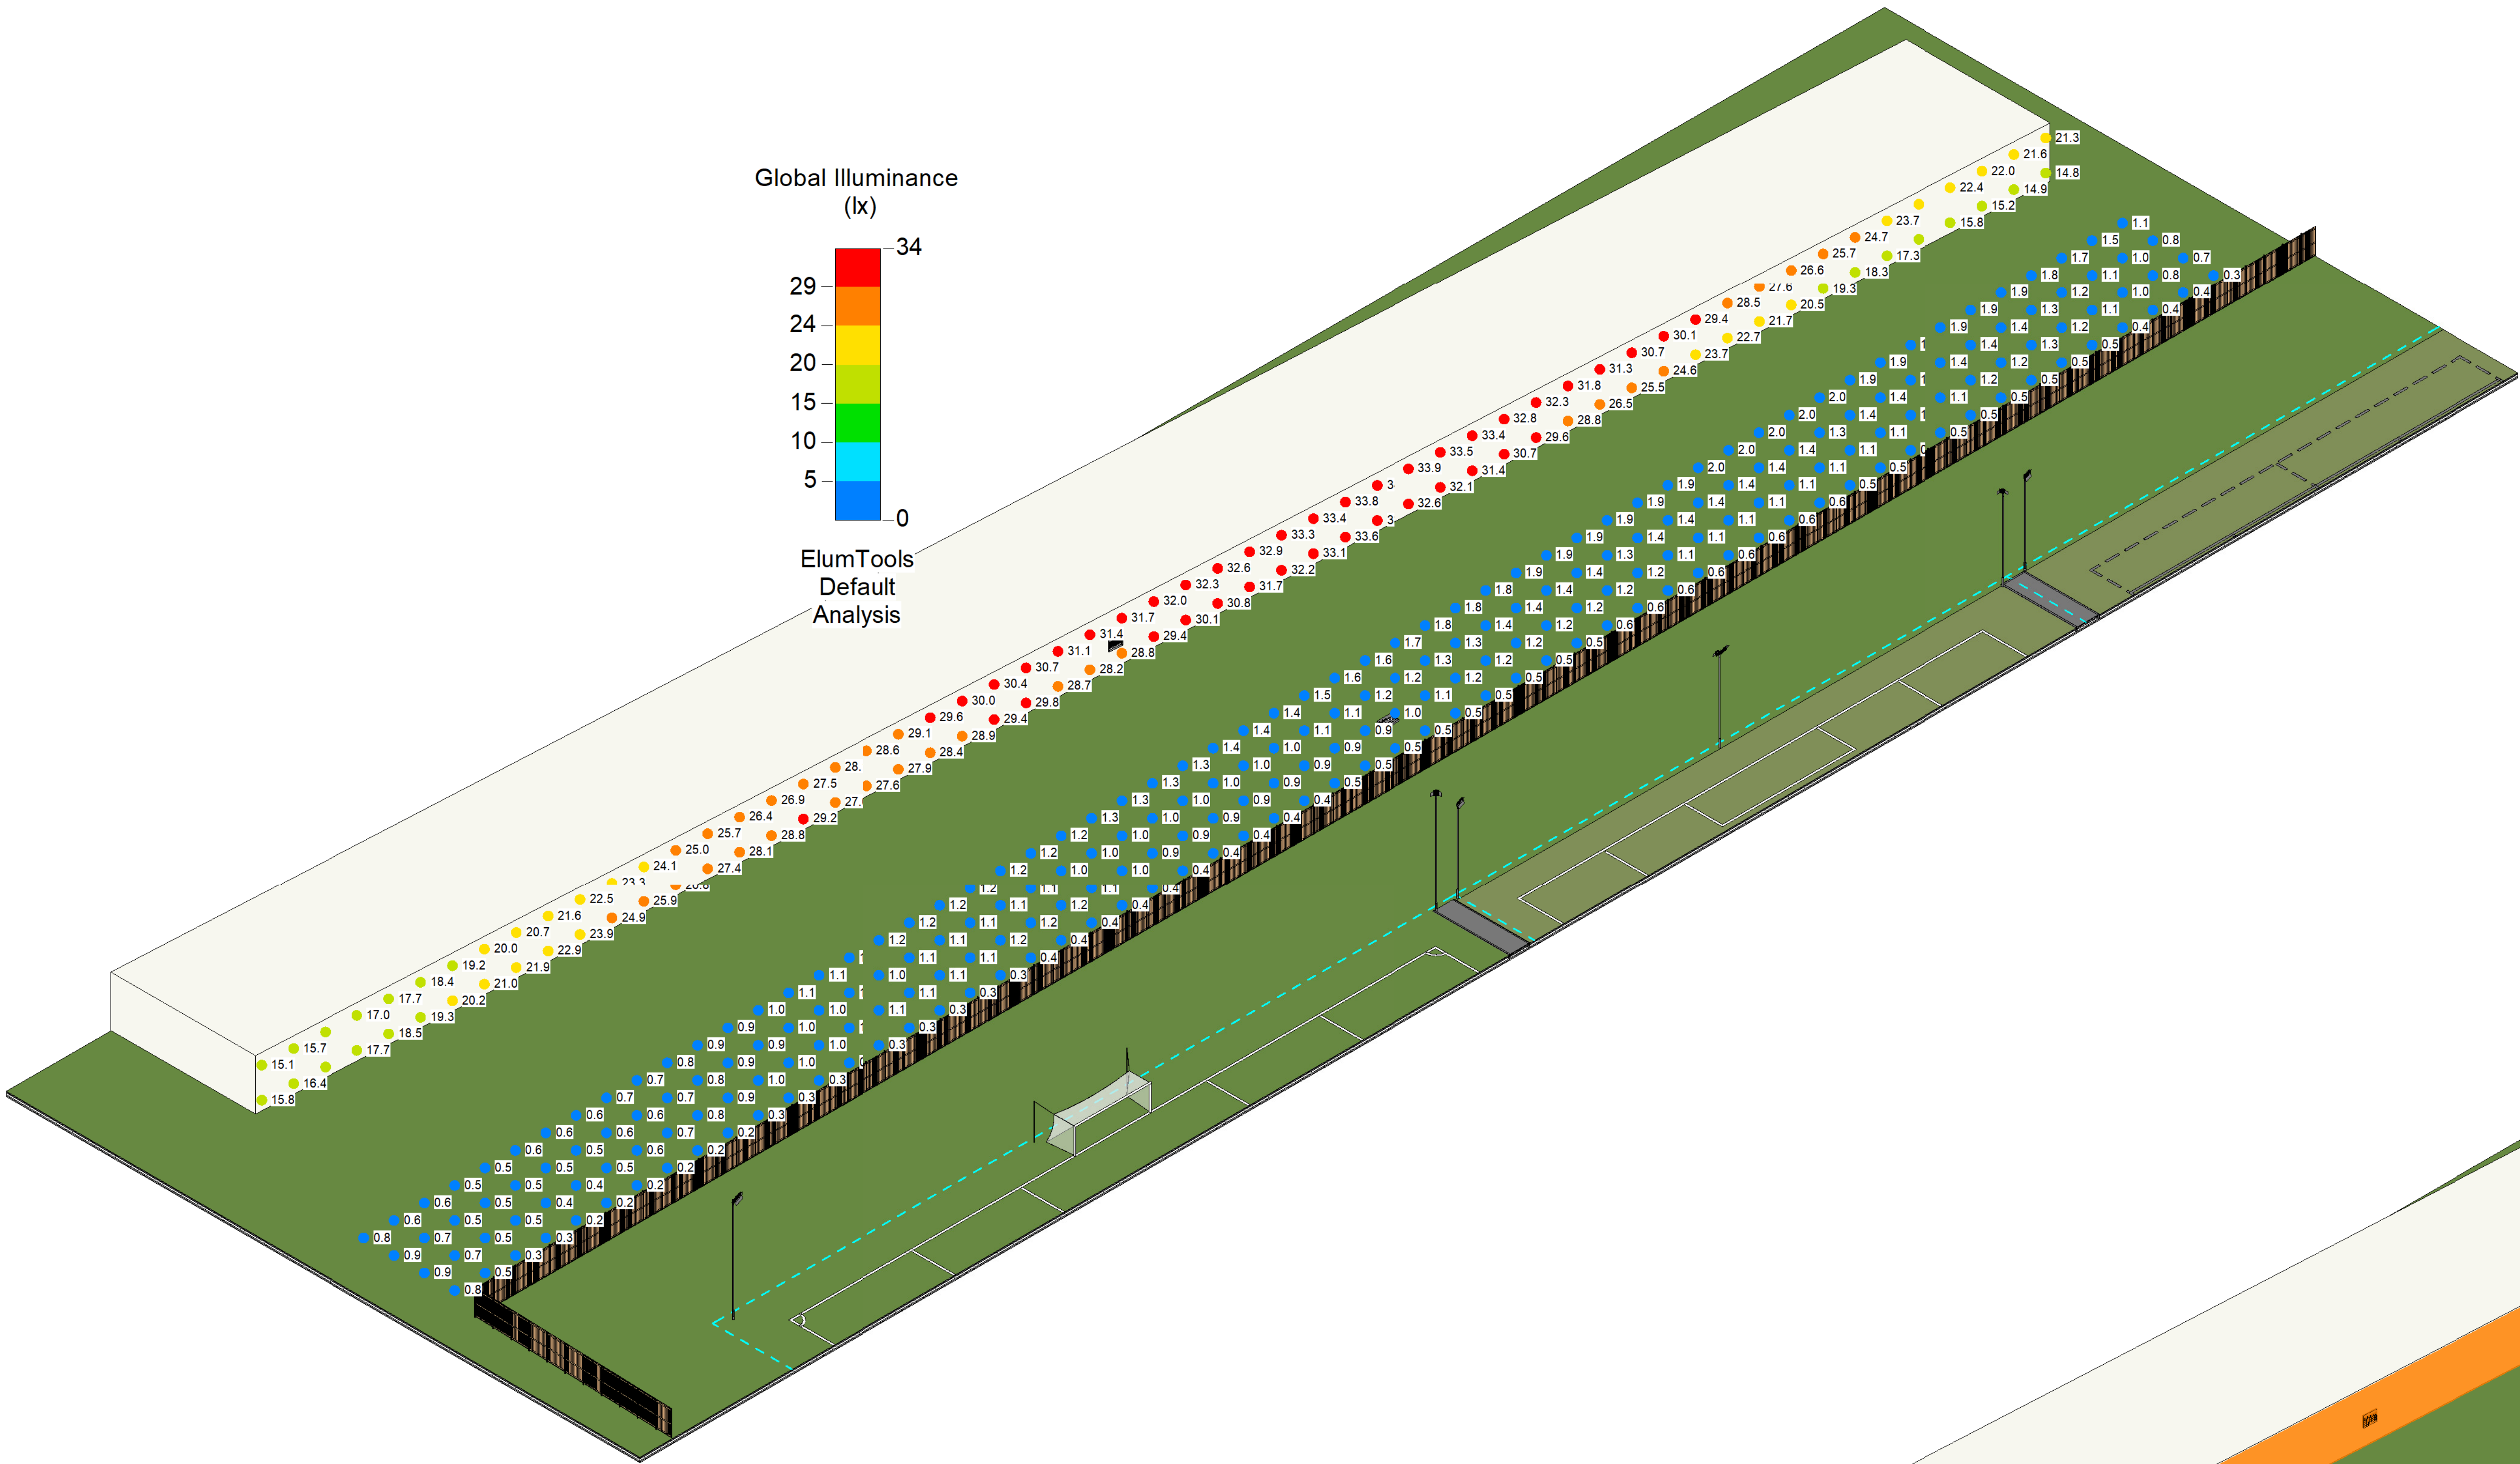

1 West OB Points

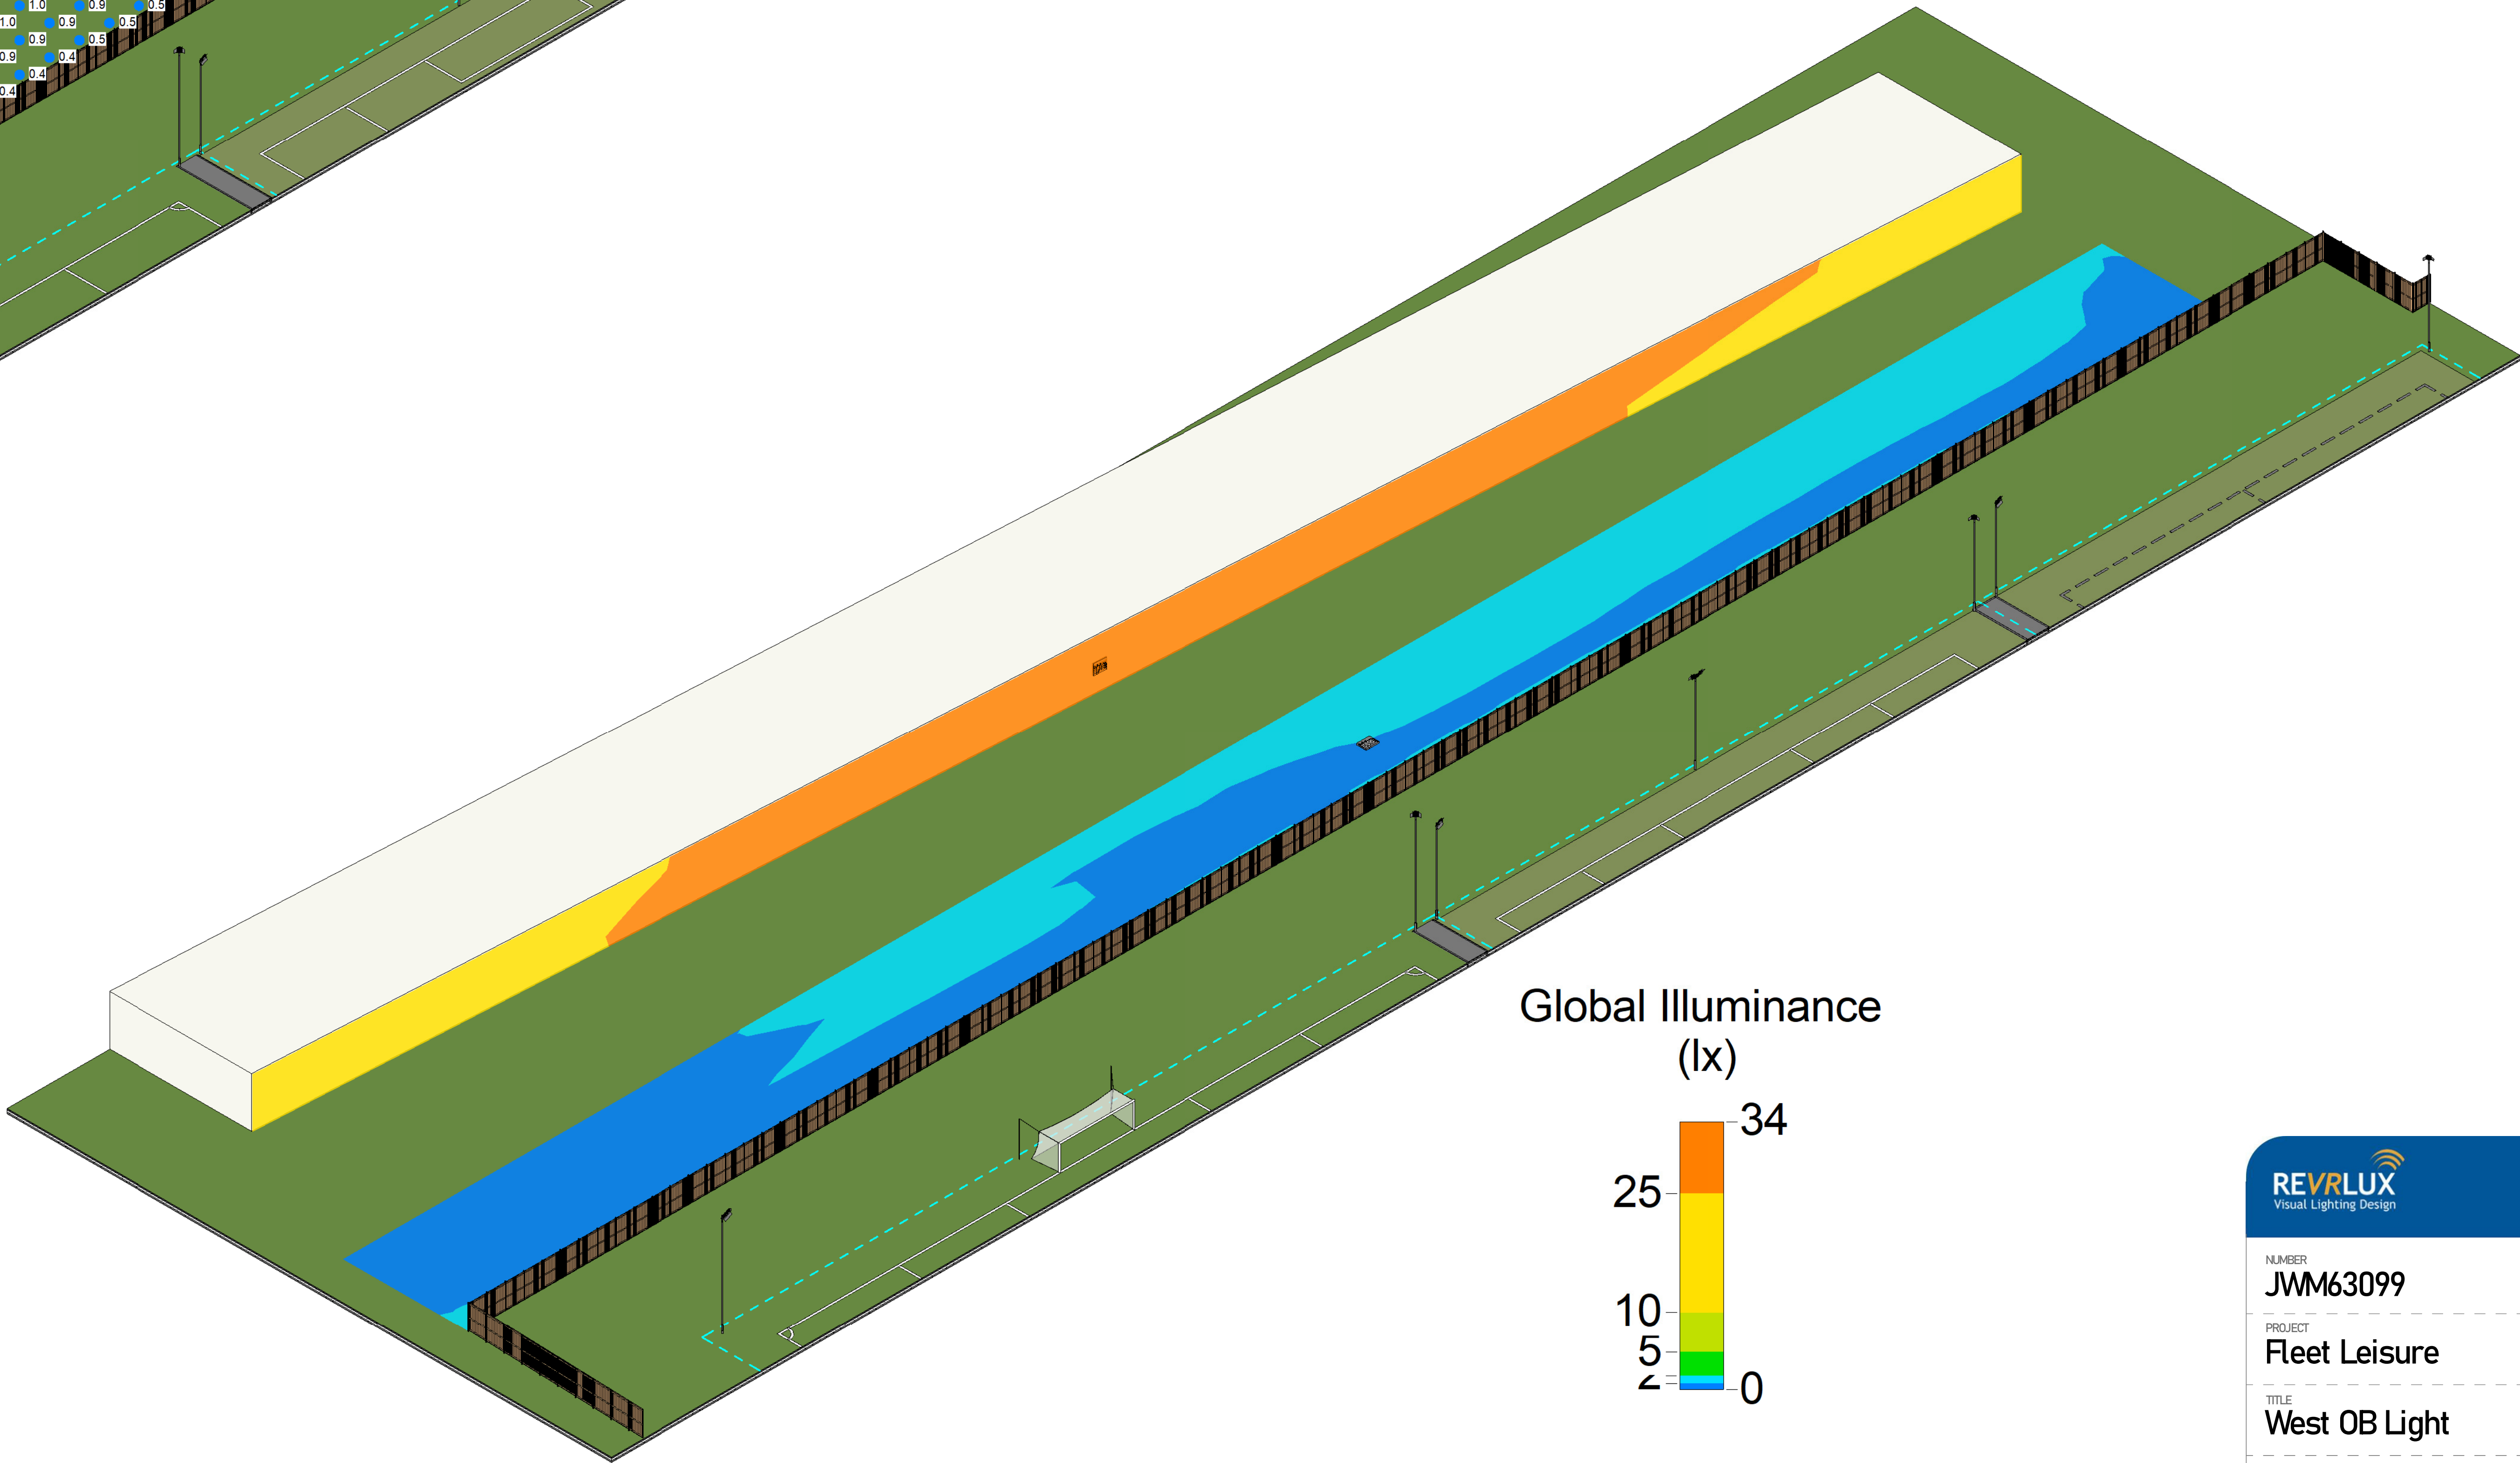

2 West OB Points Isolux

REVRLUX

Visual Lighting Design

MG Lites

Energy Saving Solutions

NUMBER

JWM63099

PROJECT

Fleet Leisure

TITLE

West OB Light

CLIENT

Owner

Rev	Description	Date
R01	Revised Pitch Lighting Layout	21/11/2021

DO NOT SCALE

SCALE (@ A0)

DRAWN BY

CHECKED BY

DATE

JW

Checker


09/23/21

DRAWING NUMBER

L115

REV

R01

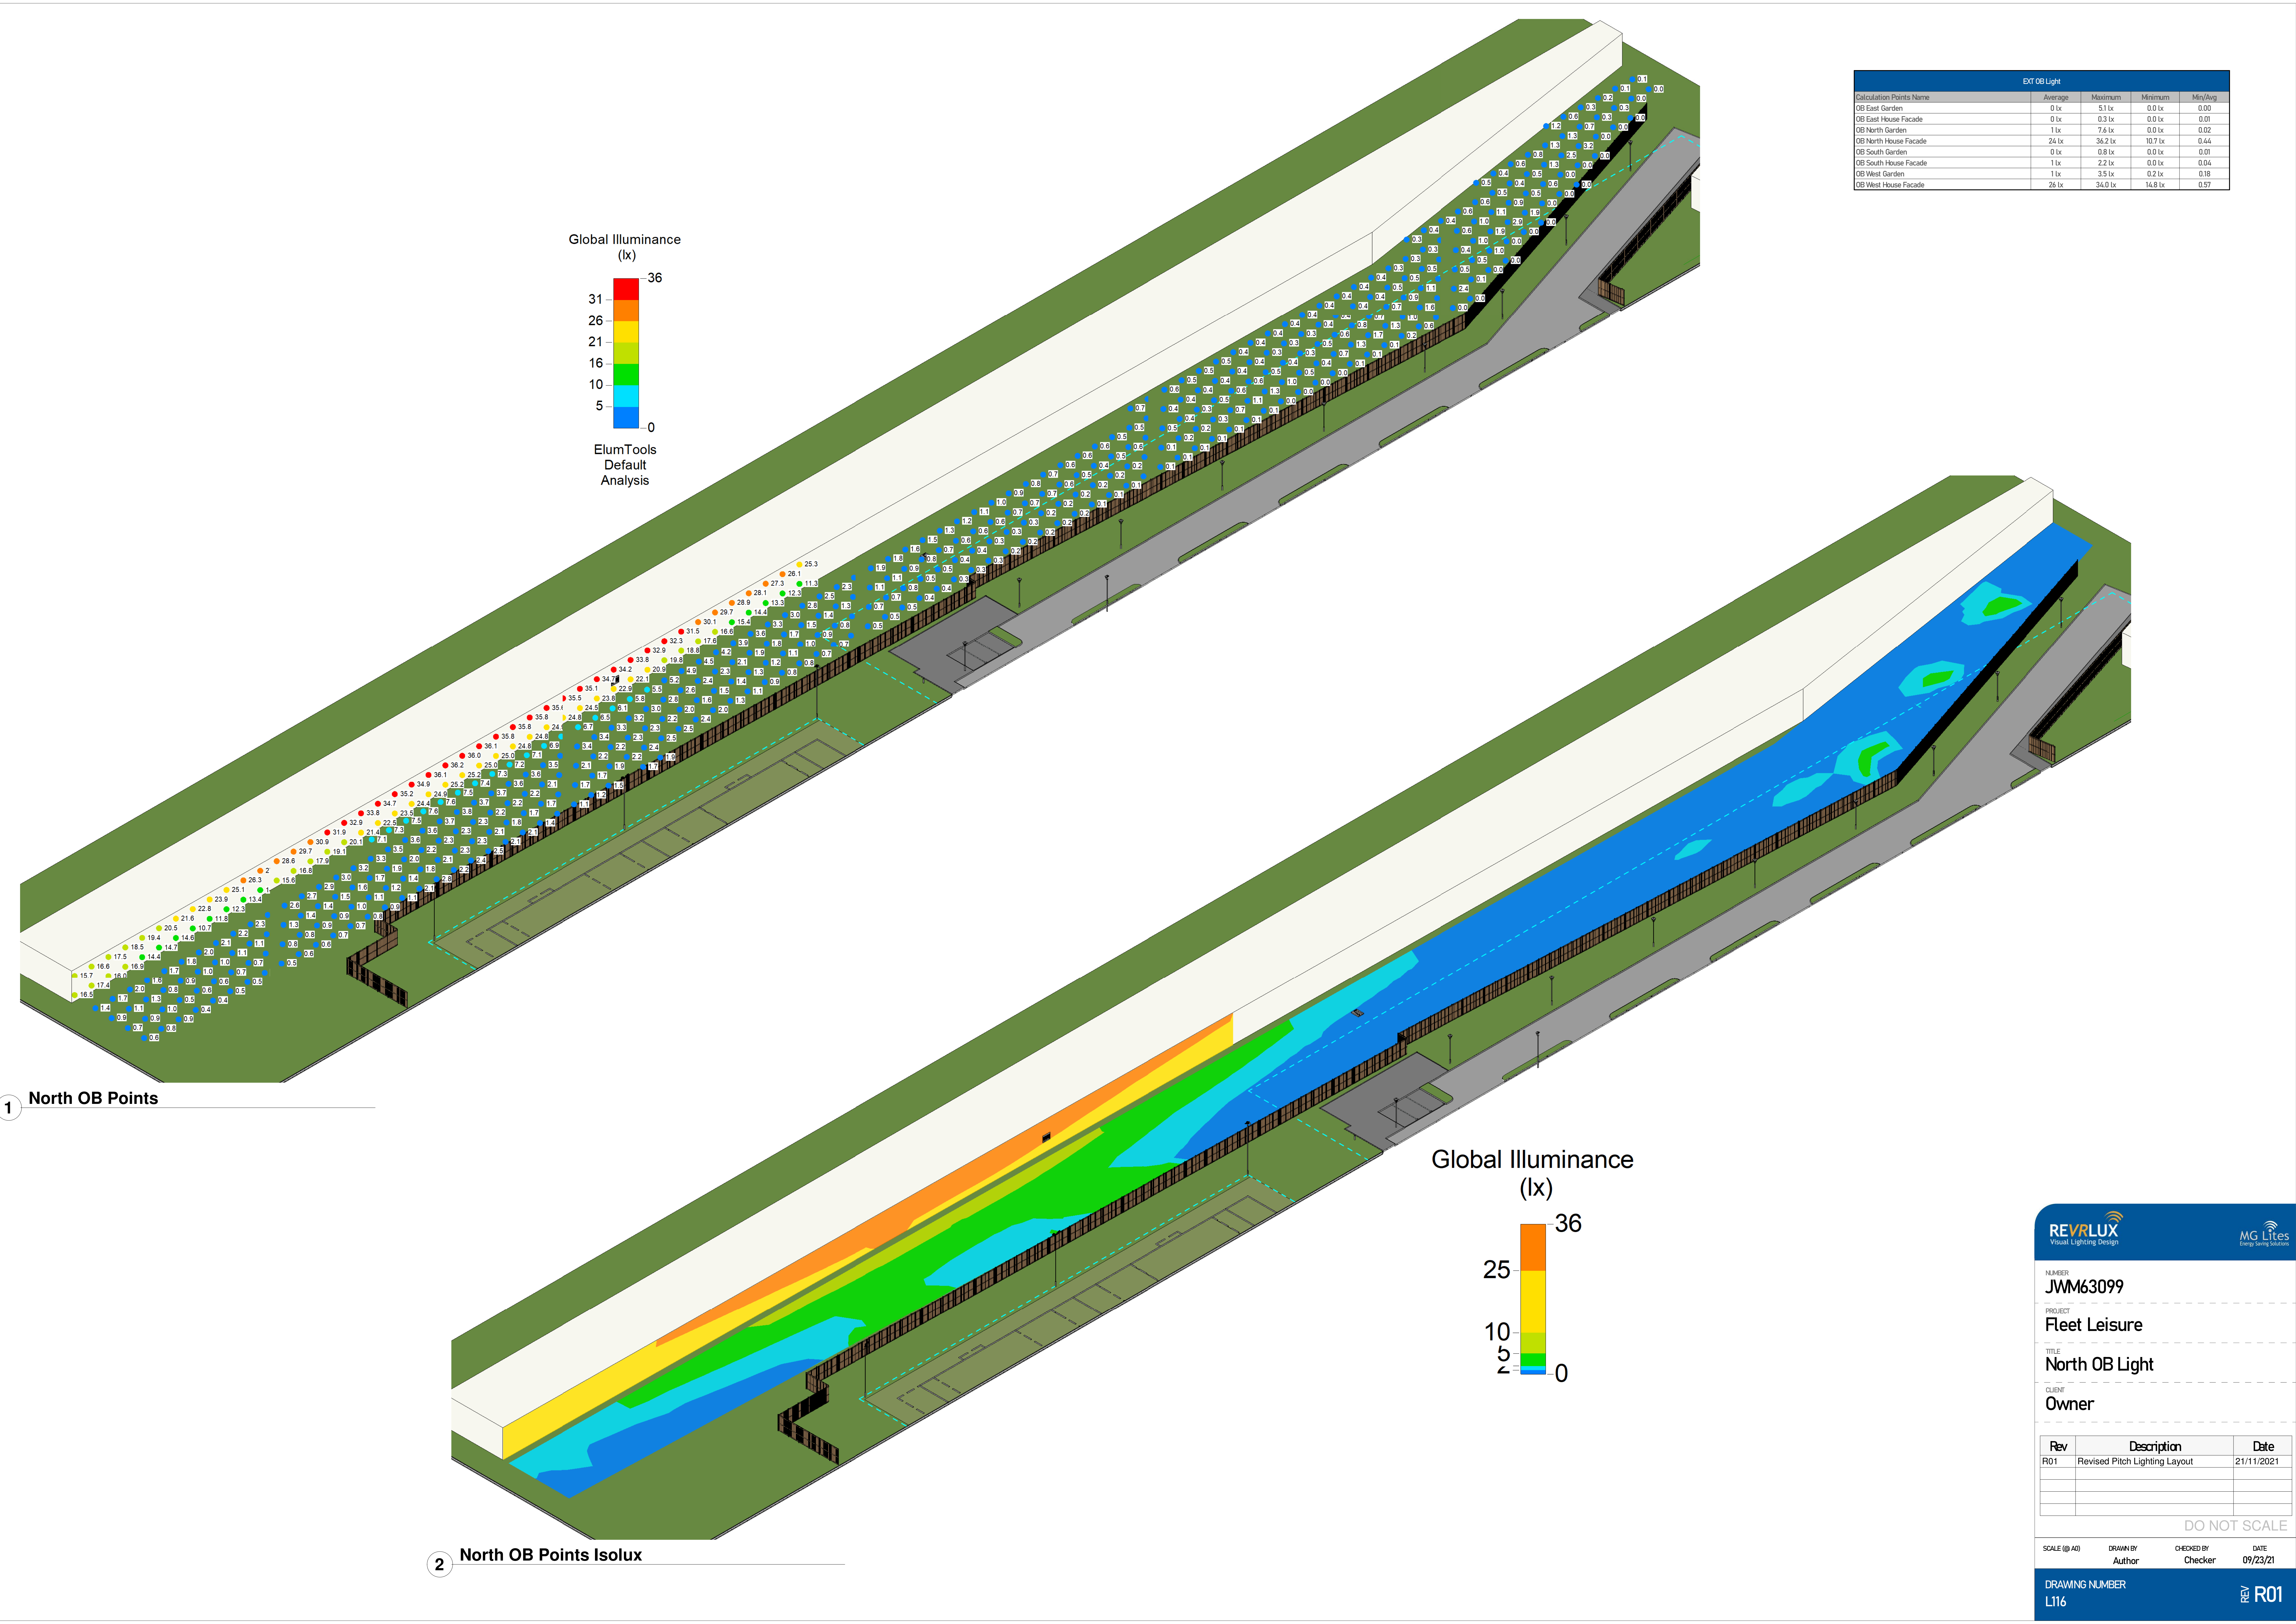

EXT OB Light				
Calculation Points Name	Average	Maximum	Minimum	Min/Avg
OB East Garden	0 lx	5.1 lx	0.0 lx	0.00
OB East House Facade	0 lx	0.3 lx	0.0 lx	0.01
OB North Garden	1 lx	7.6 lx	0.0 lx	0.02
OB North House Facade	24 lx	36.2 lx	10.7 lx	0.44
OB South Garden	0 lx	0.8 lx	0.0 lx	0.01
OB South House Facade	1 lx	2.2 lx	0.0 lx	0.04
OB West Garden	1 lx	3.5 lx	0.2 lx	0.18
OB West House Facade	28 lx	34.0 lx	14.8 lx	0.57

REVR LUX
Visual Lighting Design

MG Lites
Energy Saving Solutions

NUMBER

JWM63099

PROJECT

Fleet Leisure

TITLE

North OB Light

CLIENT

Owner

Rev	Description	Date
R01	Revised Pitch Lighting Layout	21/11/2021

DO NOT SCALE

SCALE (@ A0)

DRAWN BY
Author

CHECKED BY
Checker


DATE
09/23/21

DRAWING NUMBER


L116

REV

R01

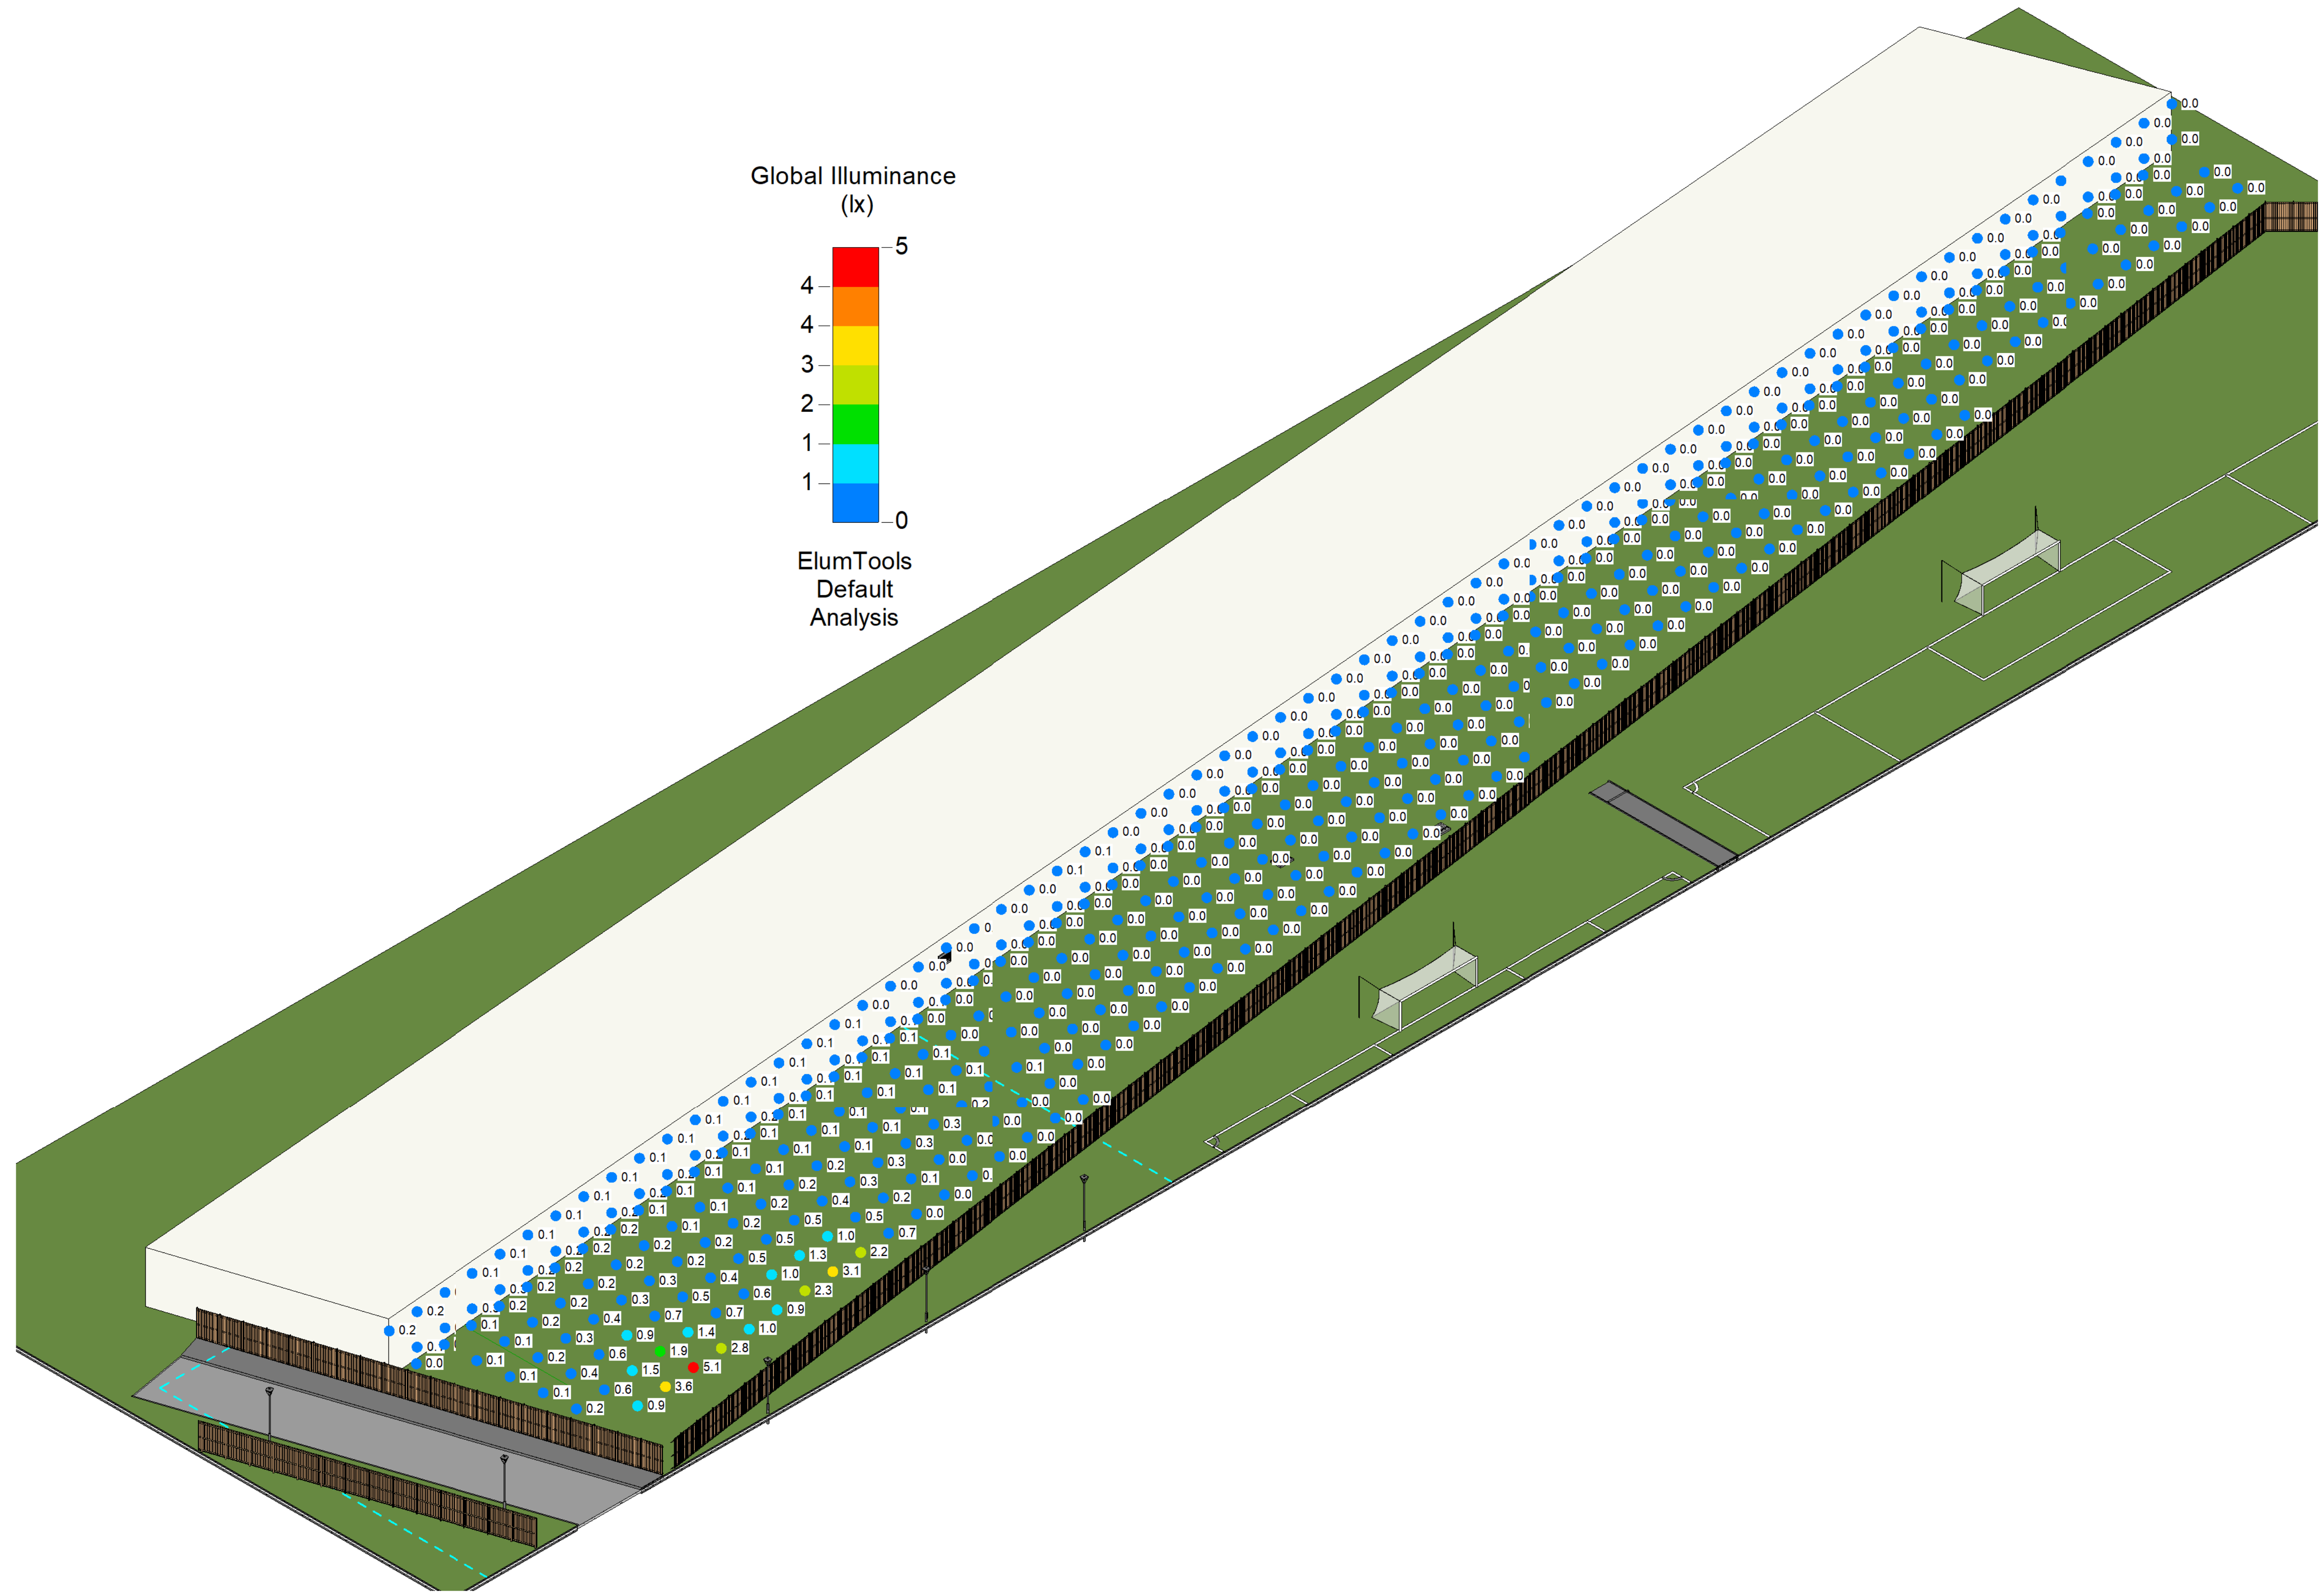

1 East OB Points

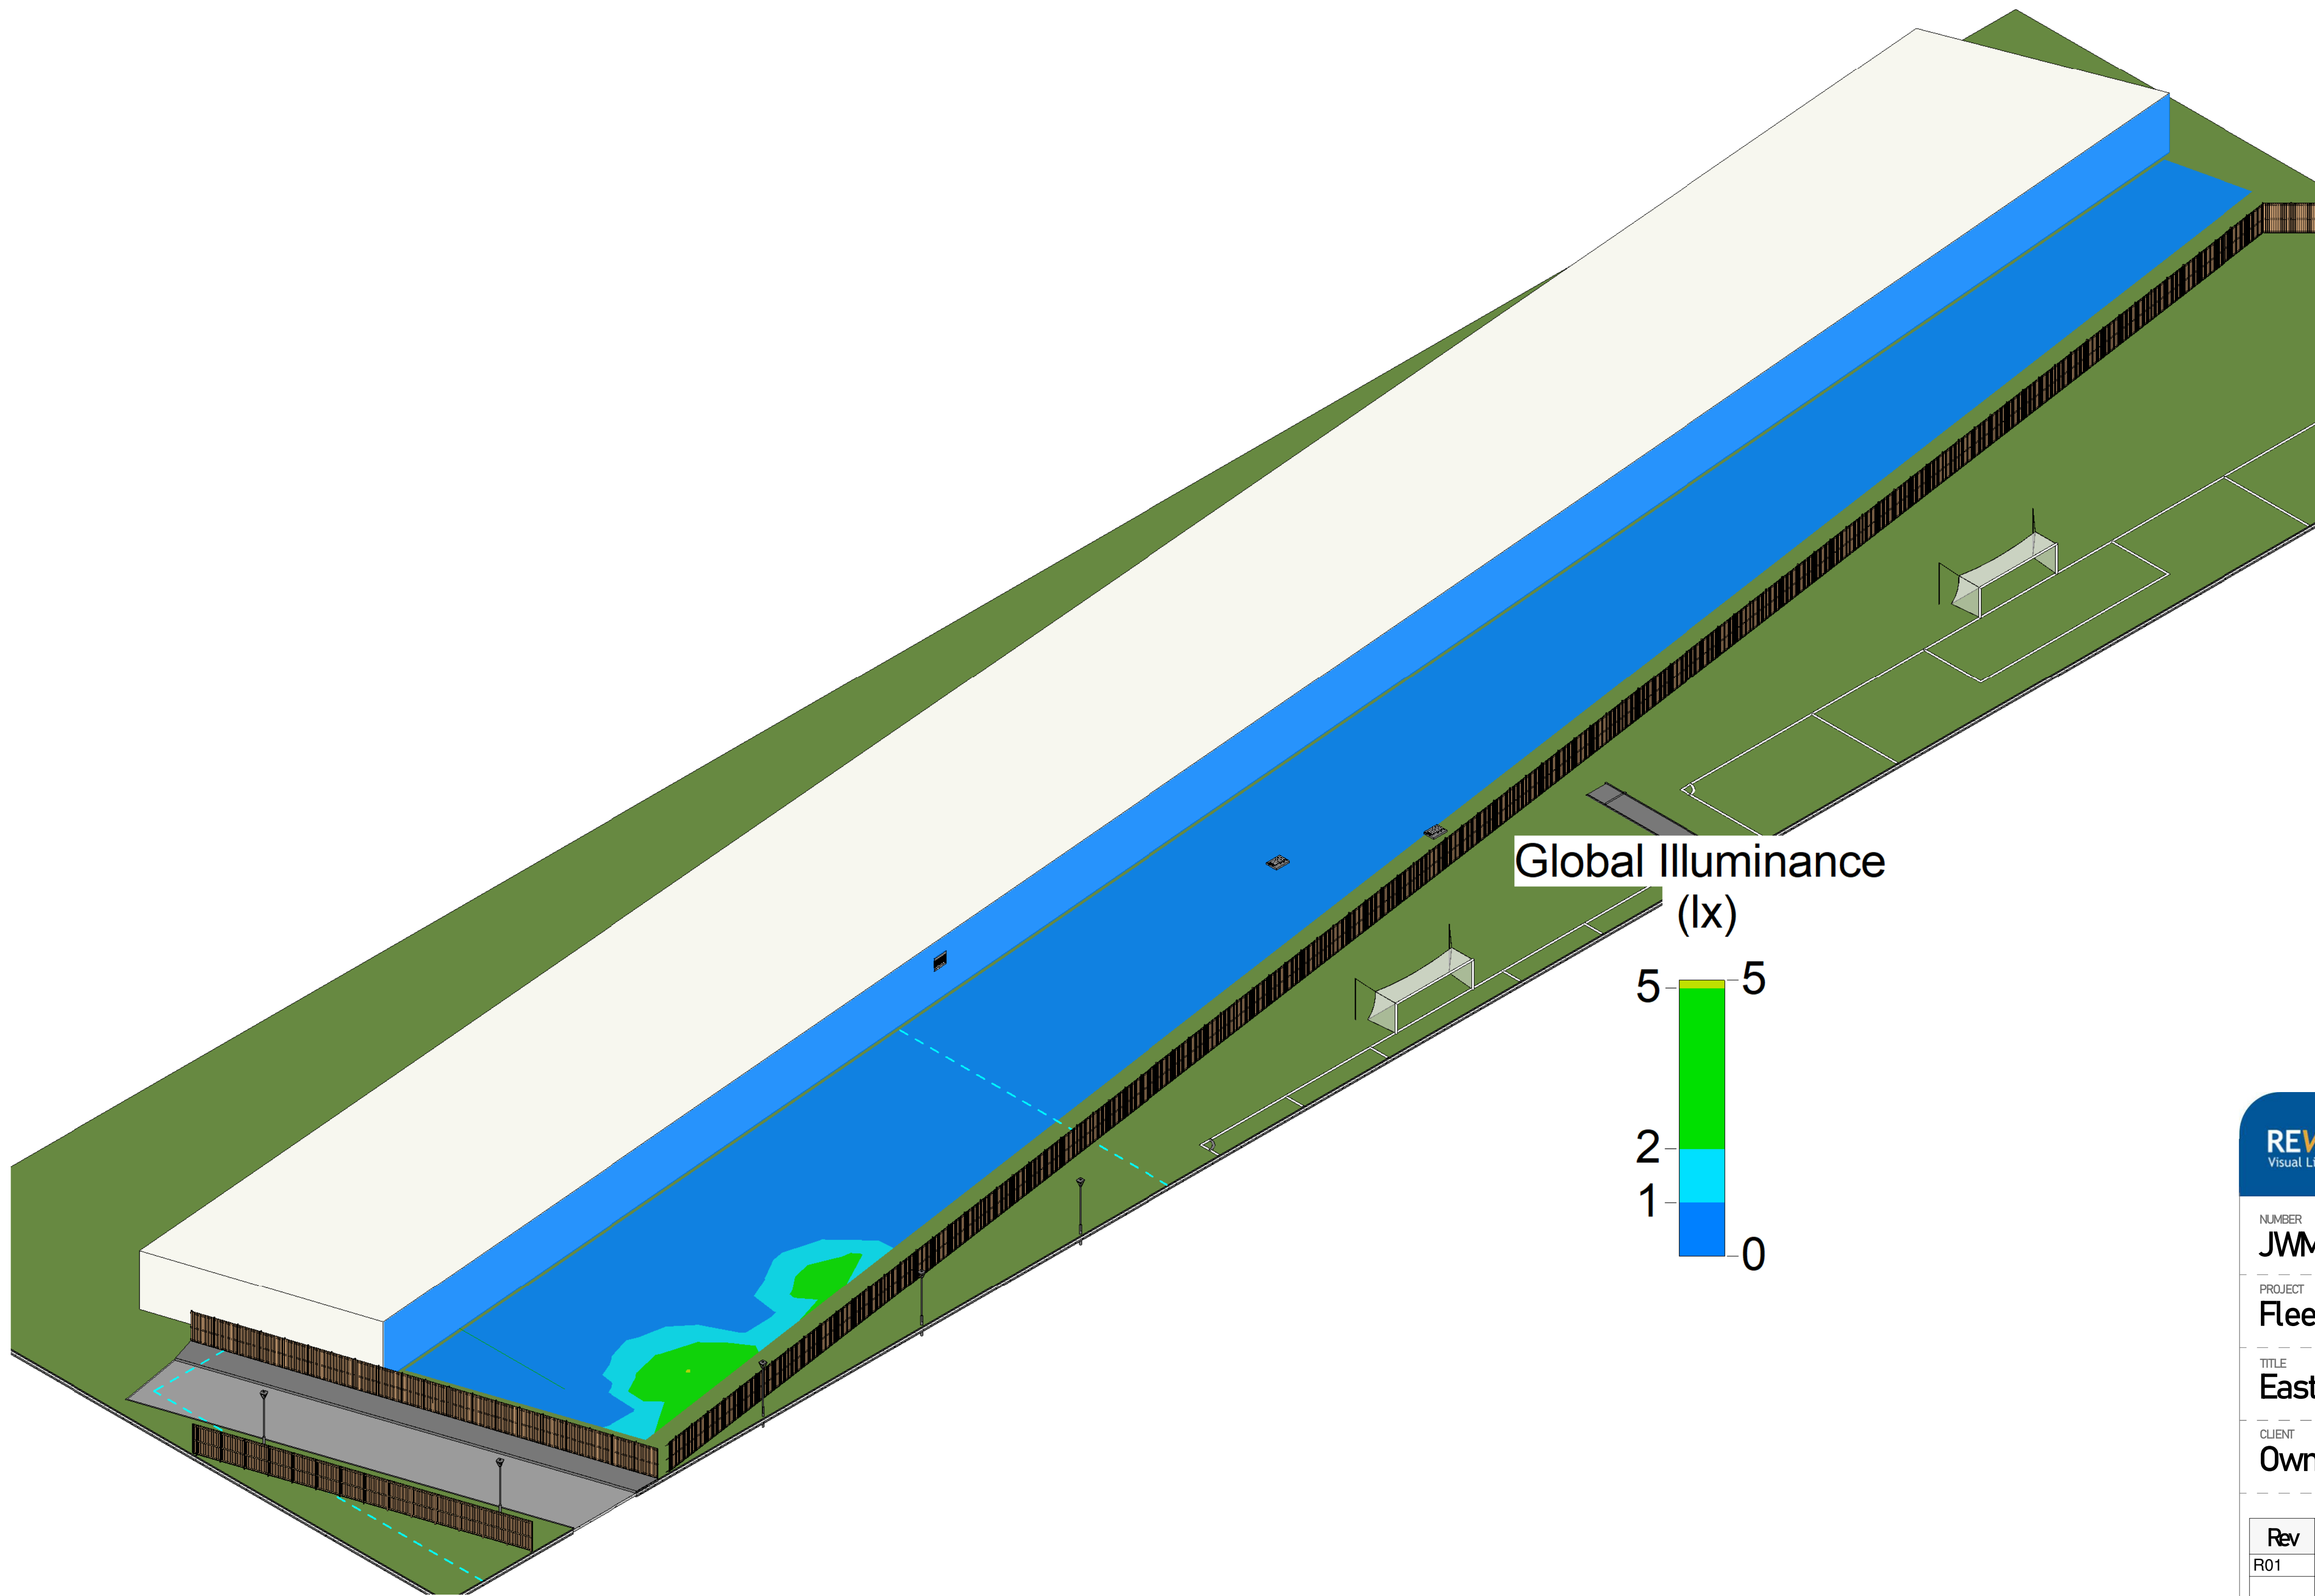

2 East OB Isolux

EXT OB Light				
Calculation Points Name	Average	Maximum	Minimum	Min/avg
OB East Garden	0 lx	5.1 lx	0.0 lx	0.00
OB East House Facade	0 lx	0.3 lx	0.0 lx	0.01
OB North Garden	1 lx	7.6 lx	0.0 lx	0.02
OB North House Facade	24 lx	36.2 lx	10.7 lx	0.66
OB South Garden	0 lx	0.8 lx	0.0 lx	0.01
OB South House Facade	1 lx	2.2 lx	0.0 lx	0.04
OB West Garden	1 lx	3.5 lx	0.2 lx	0.18
OB West House Facade	26 lx	34.0 lx	14.8 lx	0.57



Visual Lighting Design



Energy Saving Solutions

NUMBER

JWM63099

PROJECT

Fleet Leisure

TITLE

East OB Light

CLIENT

Owner

Rev	Description	Date
R01	Revised Pitch Lighting Layout	21/11/2021

DO NOT SCALE

SCALE (@ A0)

DRAWN BY

CHECKED BY

DATE

JW

Checker


09/23/21

DRAWING NUMBER


L117

REV

R01

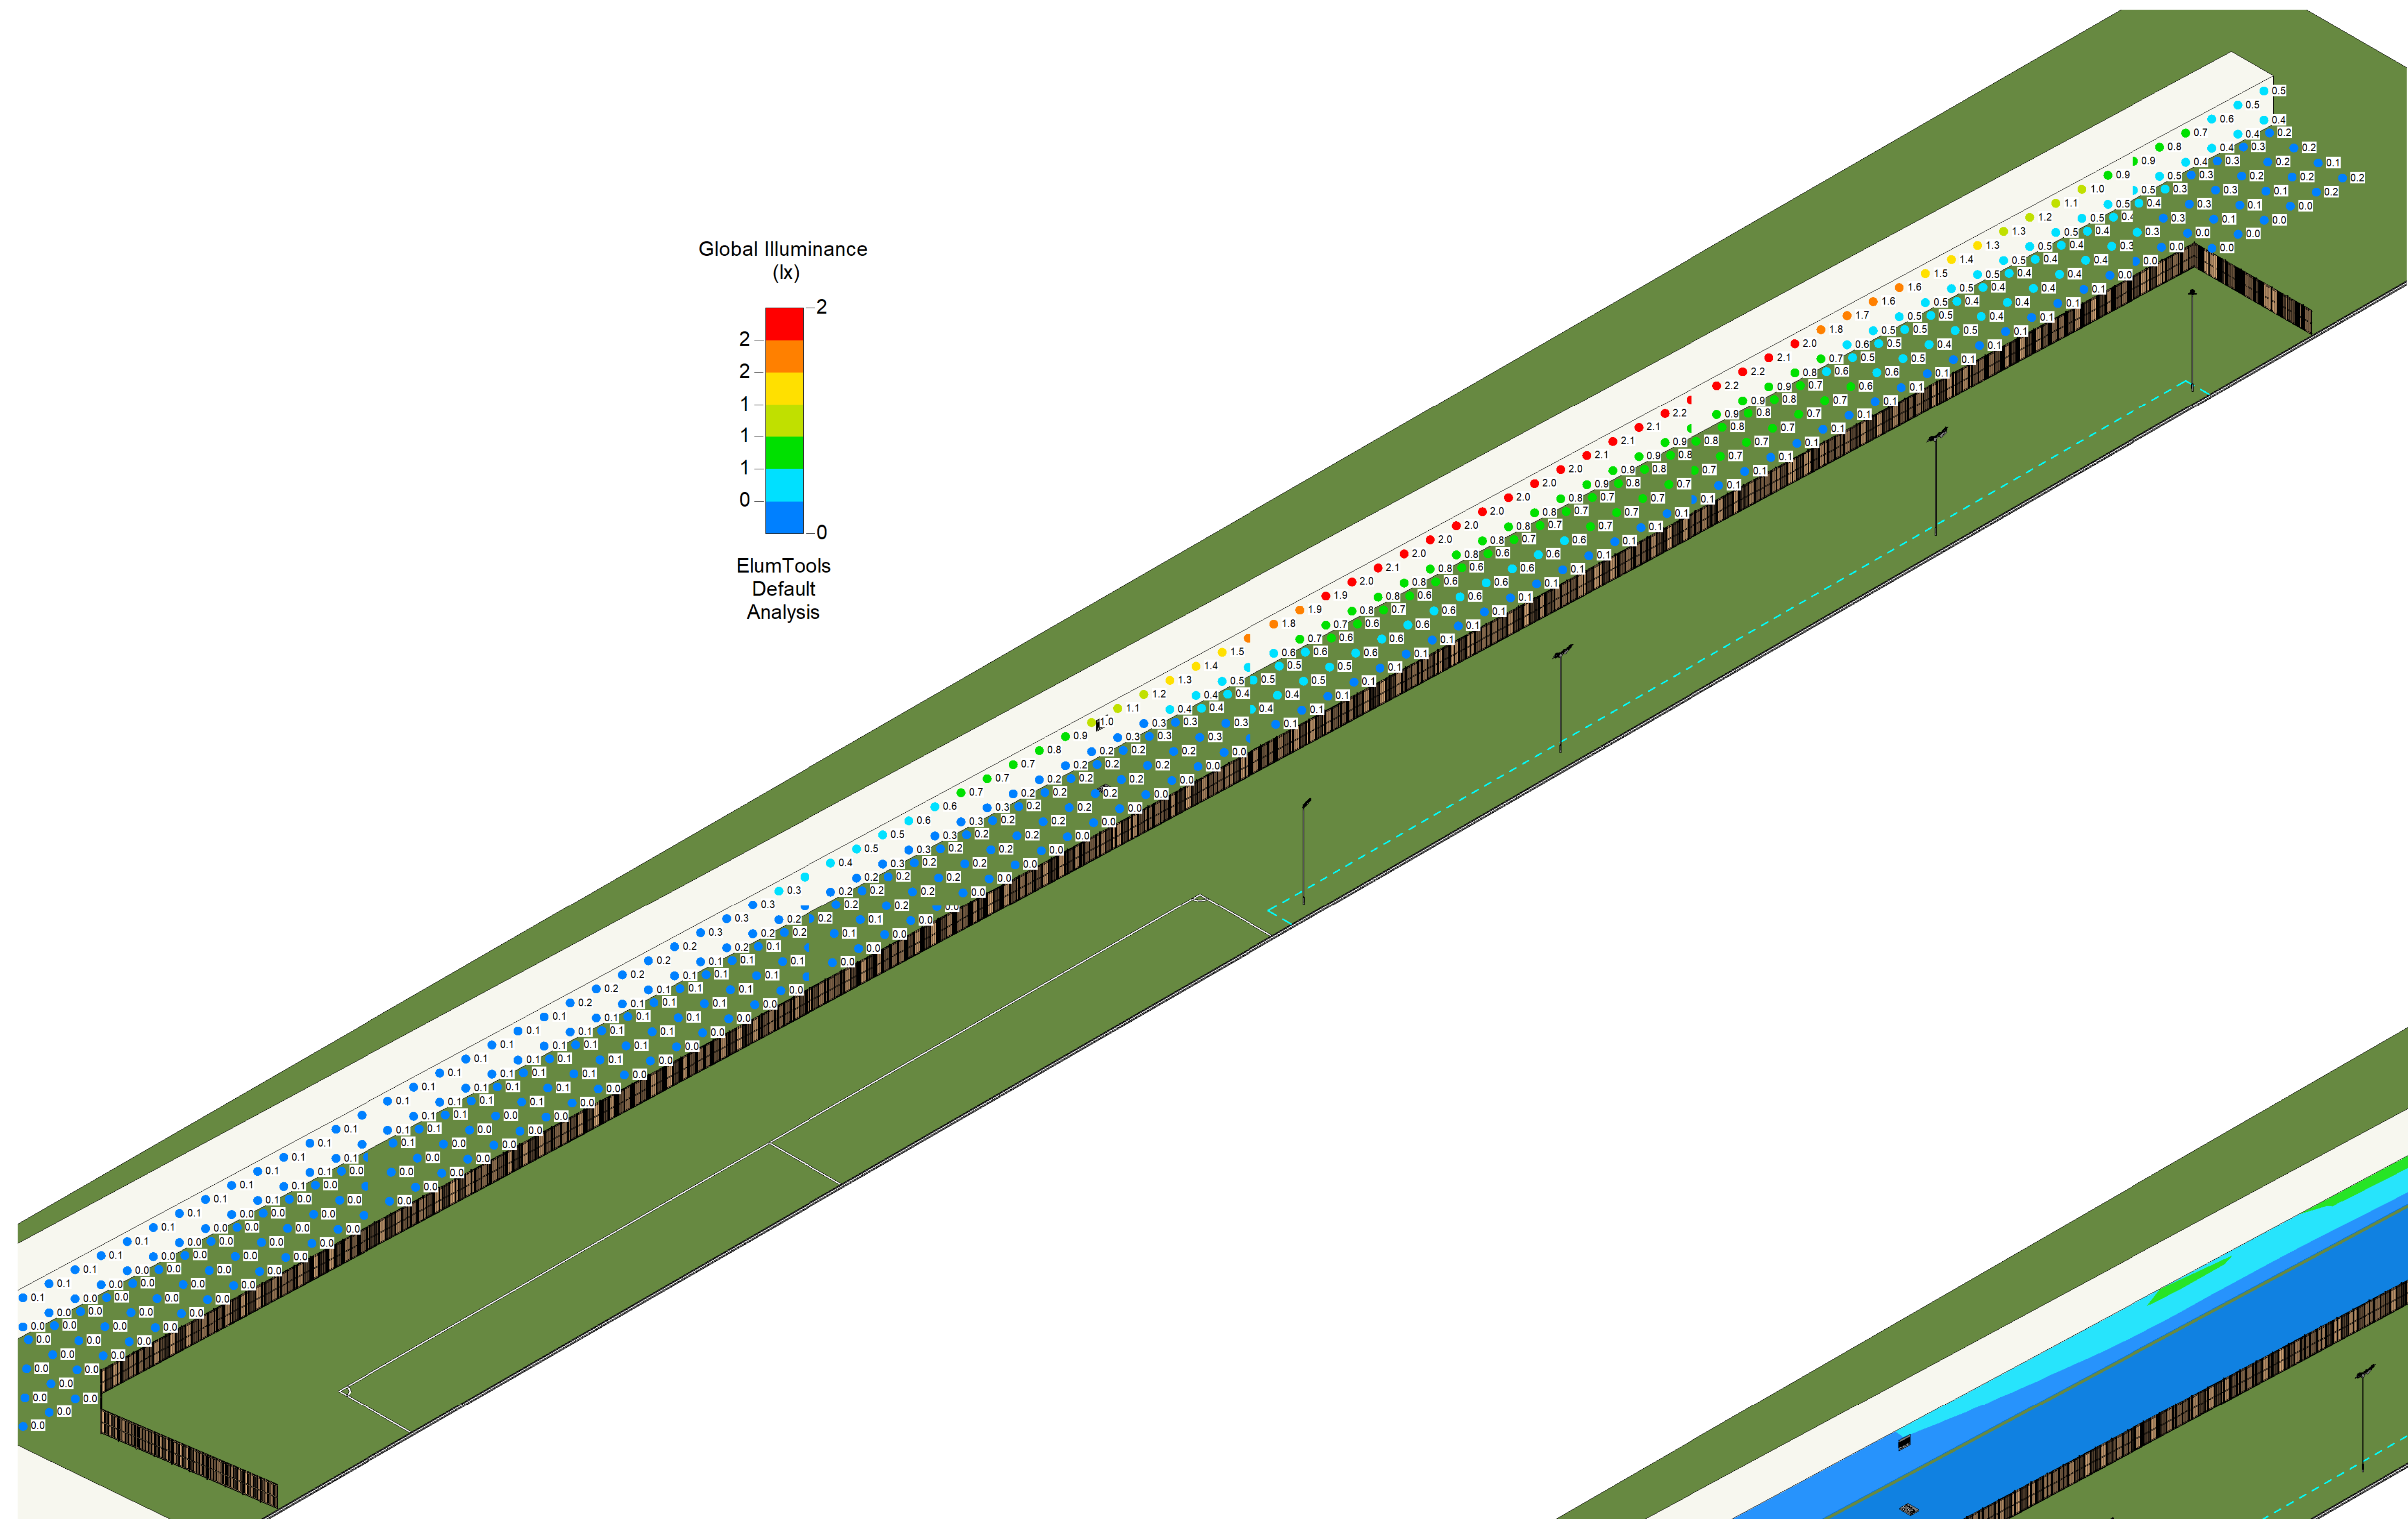

1 South OB Points

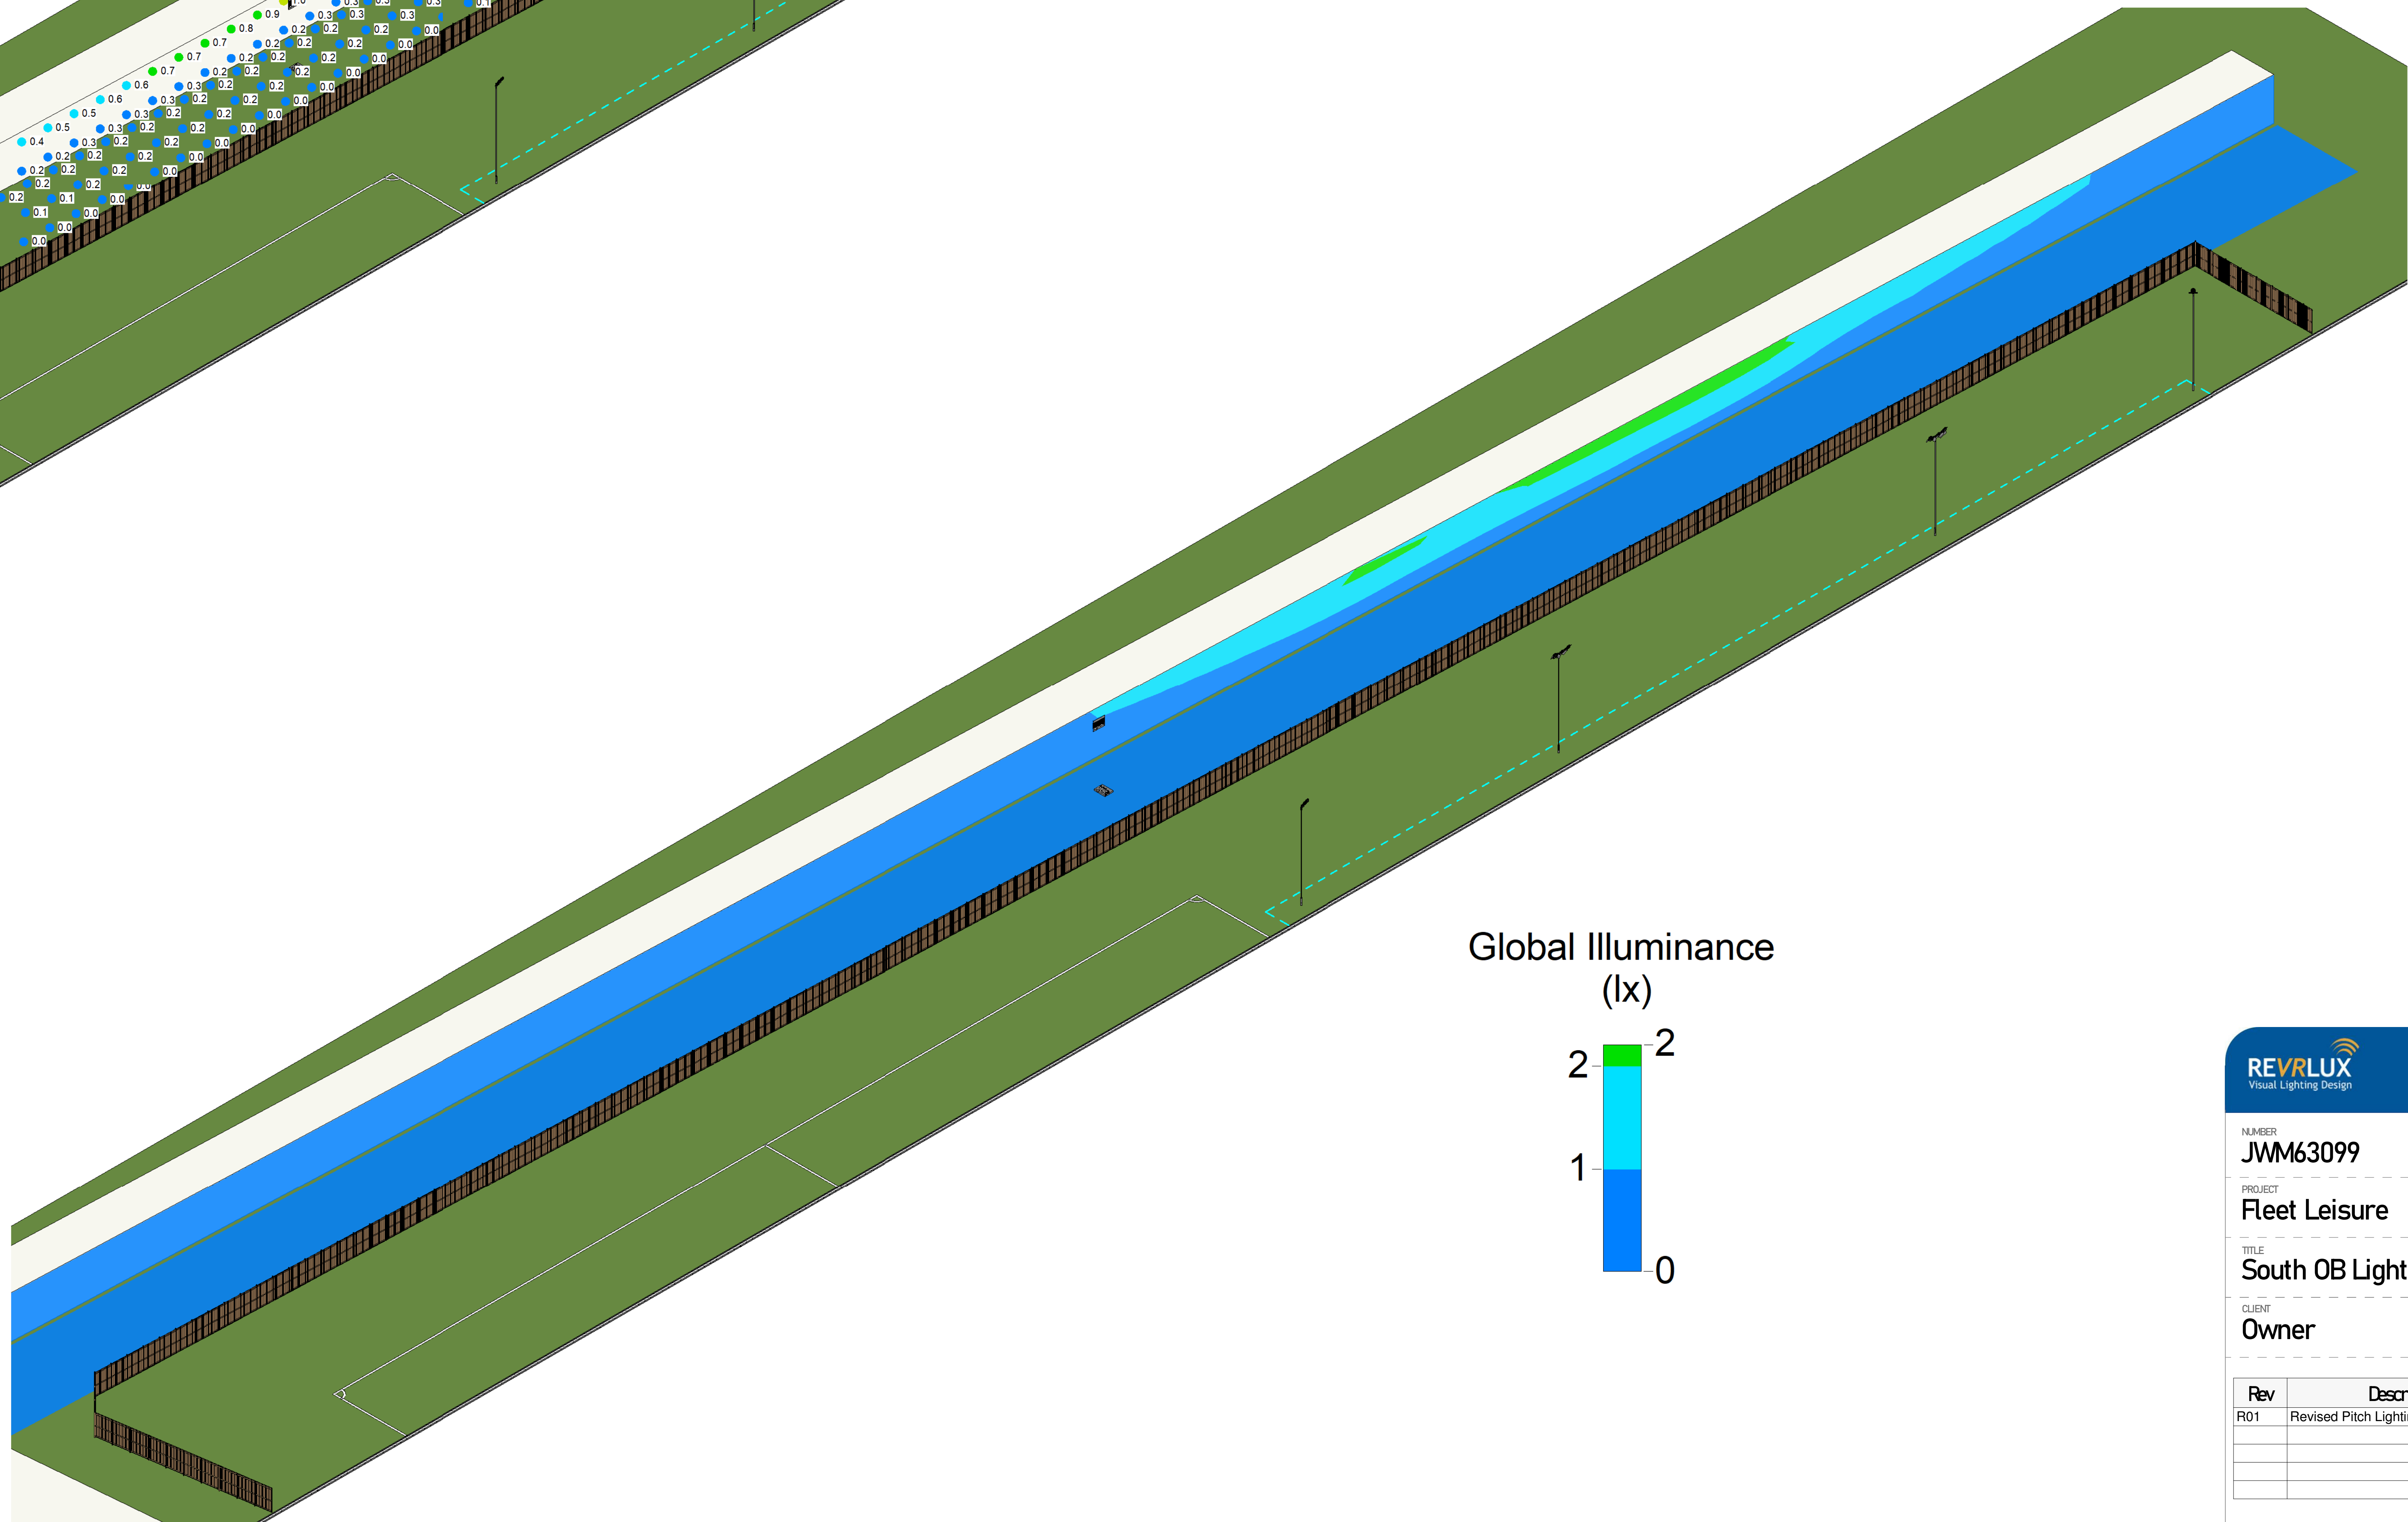

2 South OB Isolux

EXT OB Light				
Calculation Points Name	Average	Maximum	Minimum	Min/Avg
OB East Garden	0 lx	51 lx	0.0 lx	0.00
OB East House Facade	0 lx	0.3 lx	0.0 lx	0.01
OB North Garden	1 lx	7.6 lx	0.0 lx	0.02
OB North House Facade	24 lx	36.2 lx	10.7 lx	0.44
OB South Garden	0 lx	0.8 lx	0.0 lx	0.01
OB South House Facade	1 lx	2.2 lx	0.0 lx	0.04
OB West Garden	1 lx	3.5 lx	0.2 lx	0.18
OB West House Facade	26 lx	34.0 lx	14.8 lx	0.57

REVRLUX

Visual Lighting Design

MG Lites

Energy Saving Solutions

NUMBER

JWM63099

PROJECT

Fleet Leisure

TITLE

South OB Light

CLIENT

Owner

Rev	Description	Date
R01	Revised Pitch Lighting Layout	21/11/2021

DO NOT SCALE

SCALE (@ A4)

DRAWN BY

CHECKED BY

DATE

JW

Checker

09/23/21

DRAWING NUMBER

L118

REV

R01