




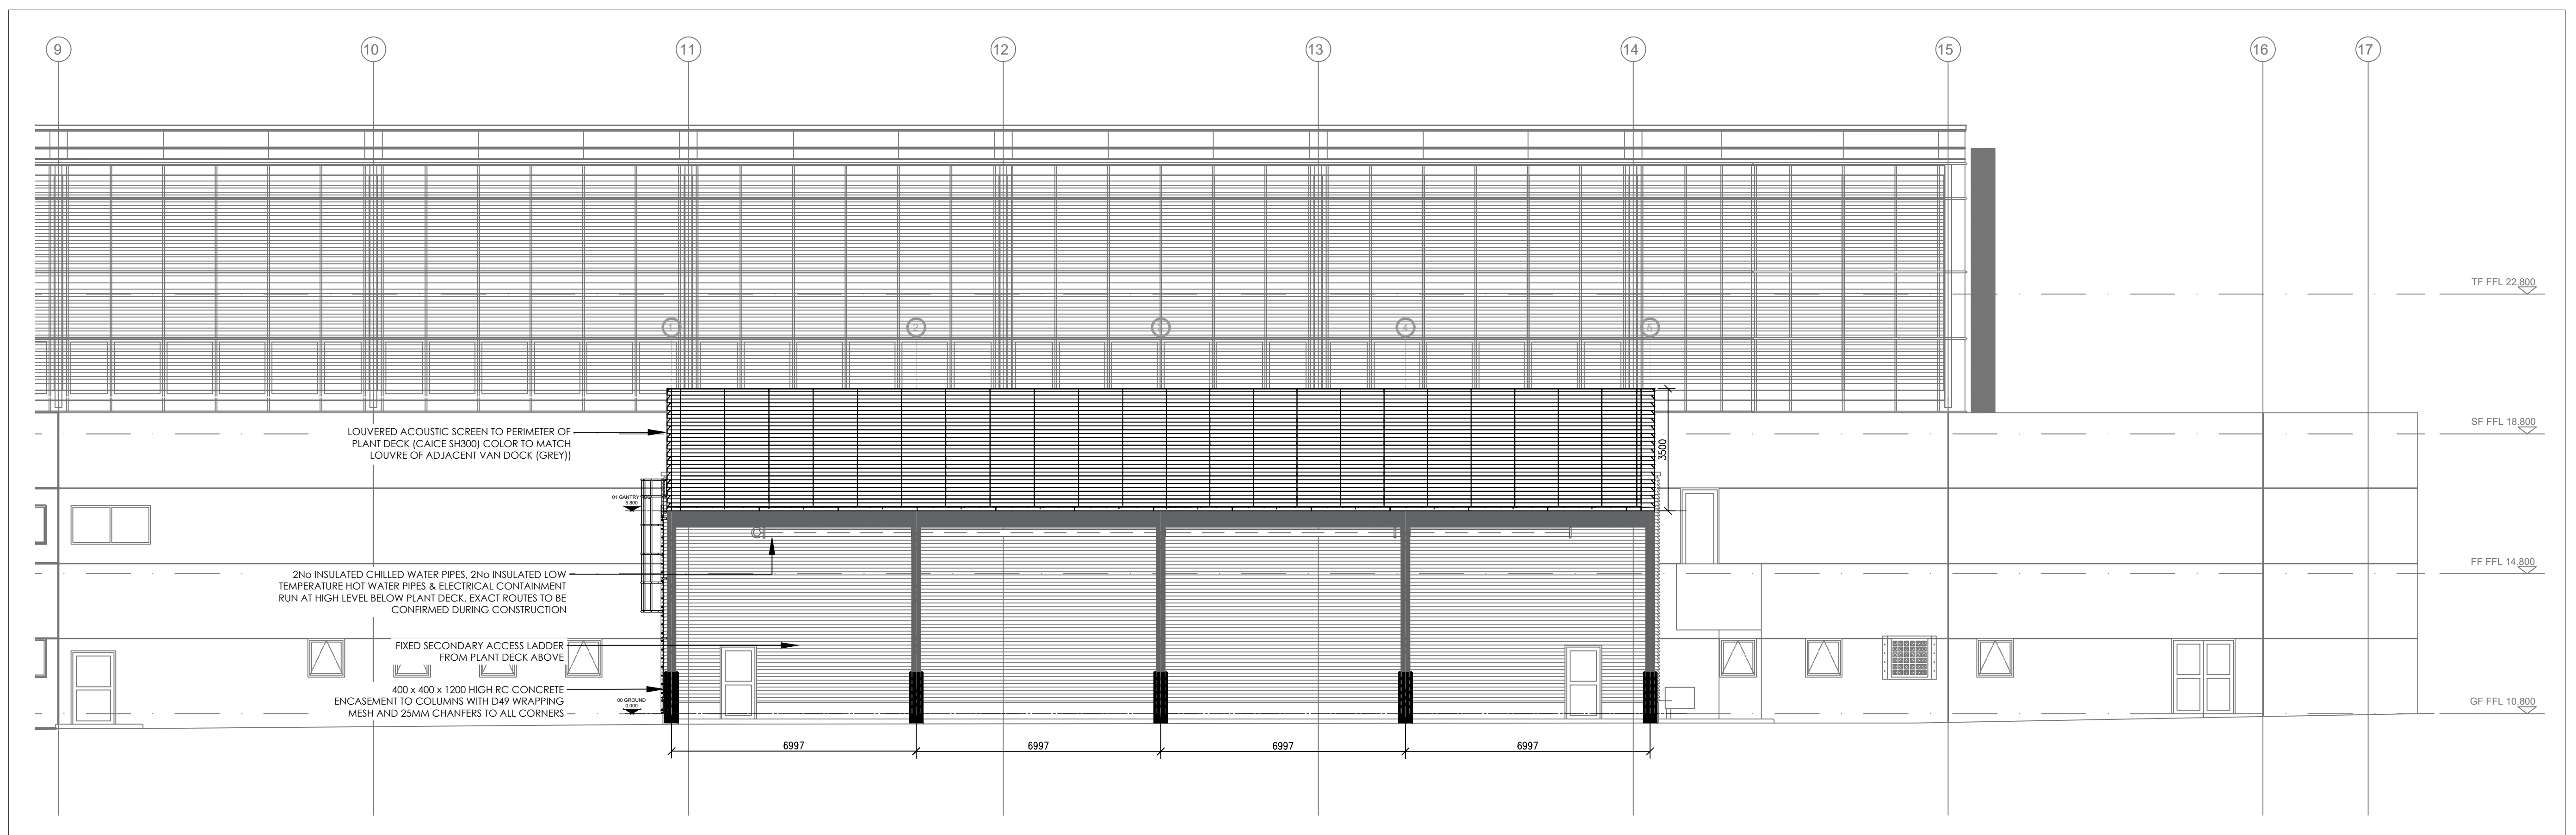

SOUTH ELEVATION

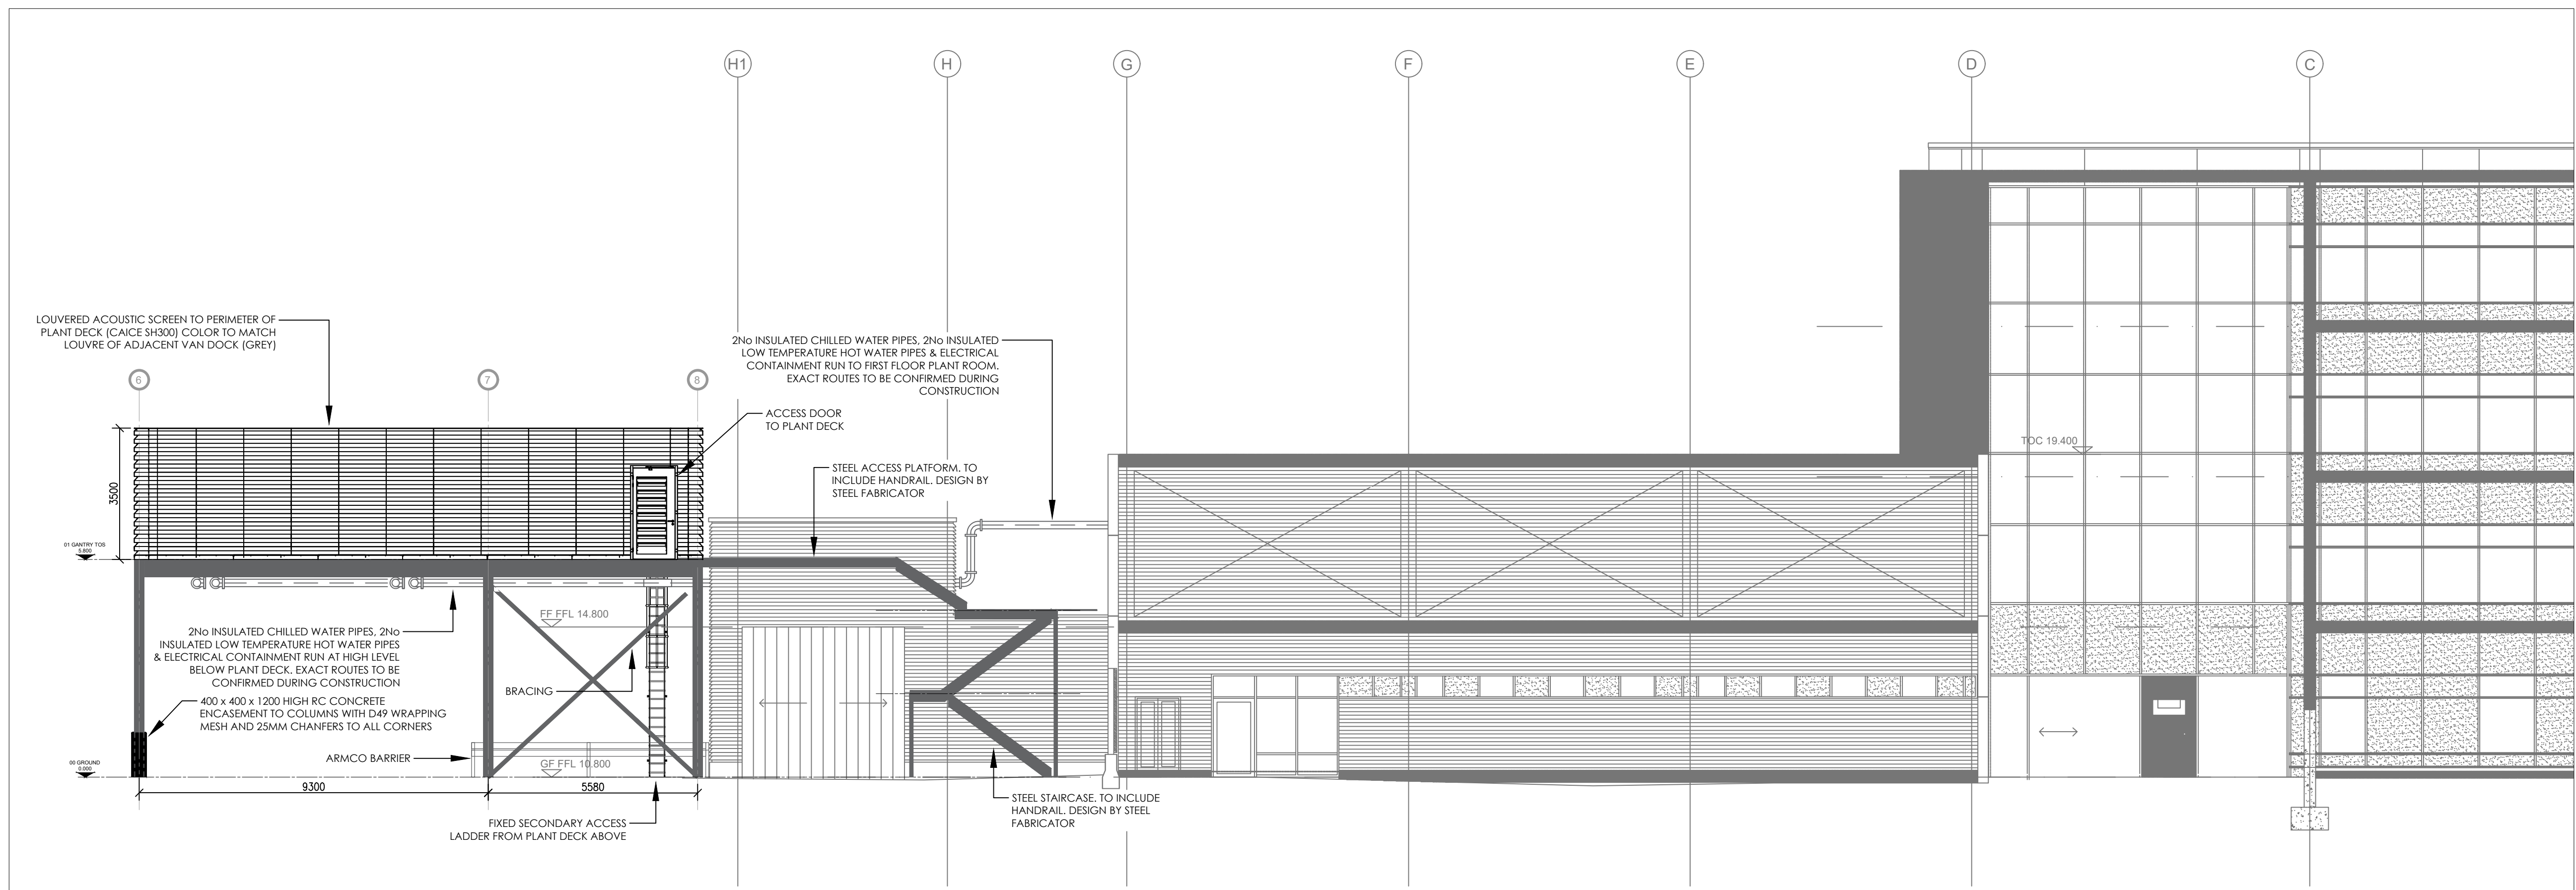

EAST ELEVATION

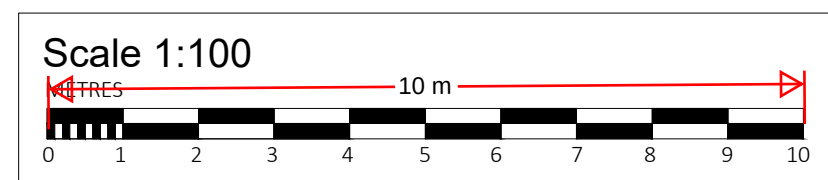

This drawing is copyright of Avison Young (UK) Limited.

Do not scale this drawing.
All dimensions to be checked on site. Drawing to be read in conjunction with any specifications, schedules and Consultants drawings and details.

P03	PLANNING UPDATE	05/09/24
P02	PLANNING APPLICATION	28/08/24
P01	PRE-PLANNING APPLICATION	28/06/24
REV	COMMENT	DATE

**AVISON
YOUNG**

08449 02 03 04
65 Gresham Street, London, EC2V 7NQ
www.avisonyoung.com

Project Name
NORTH KENT POLICE ASHP

Client
KENT POLICE

Drawing Title

PROPOSED PLANT DECK MECHANICAL
HEATING & COOLING SERVICES ELEVATIONS

Drawn By AH	Chk'd By AF	Scale @ A1 1:100	Date 28/06/2024
----------------	----------------	---------------------	--------------------

Chk'd By
AF

Scale @ A1
1:100

3/06/2024

Project No.
02C400512

Drawing No. NKP-AY-XX-XX-DR-M-1000

P03

status