


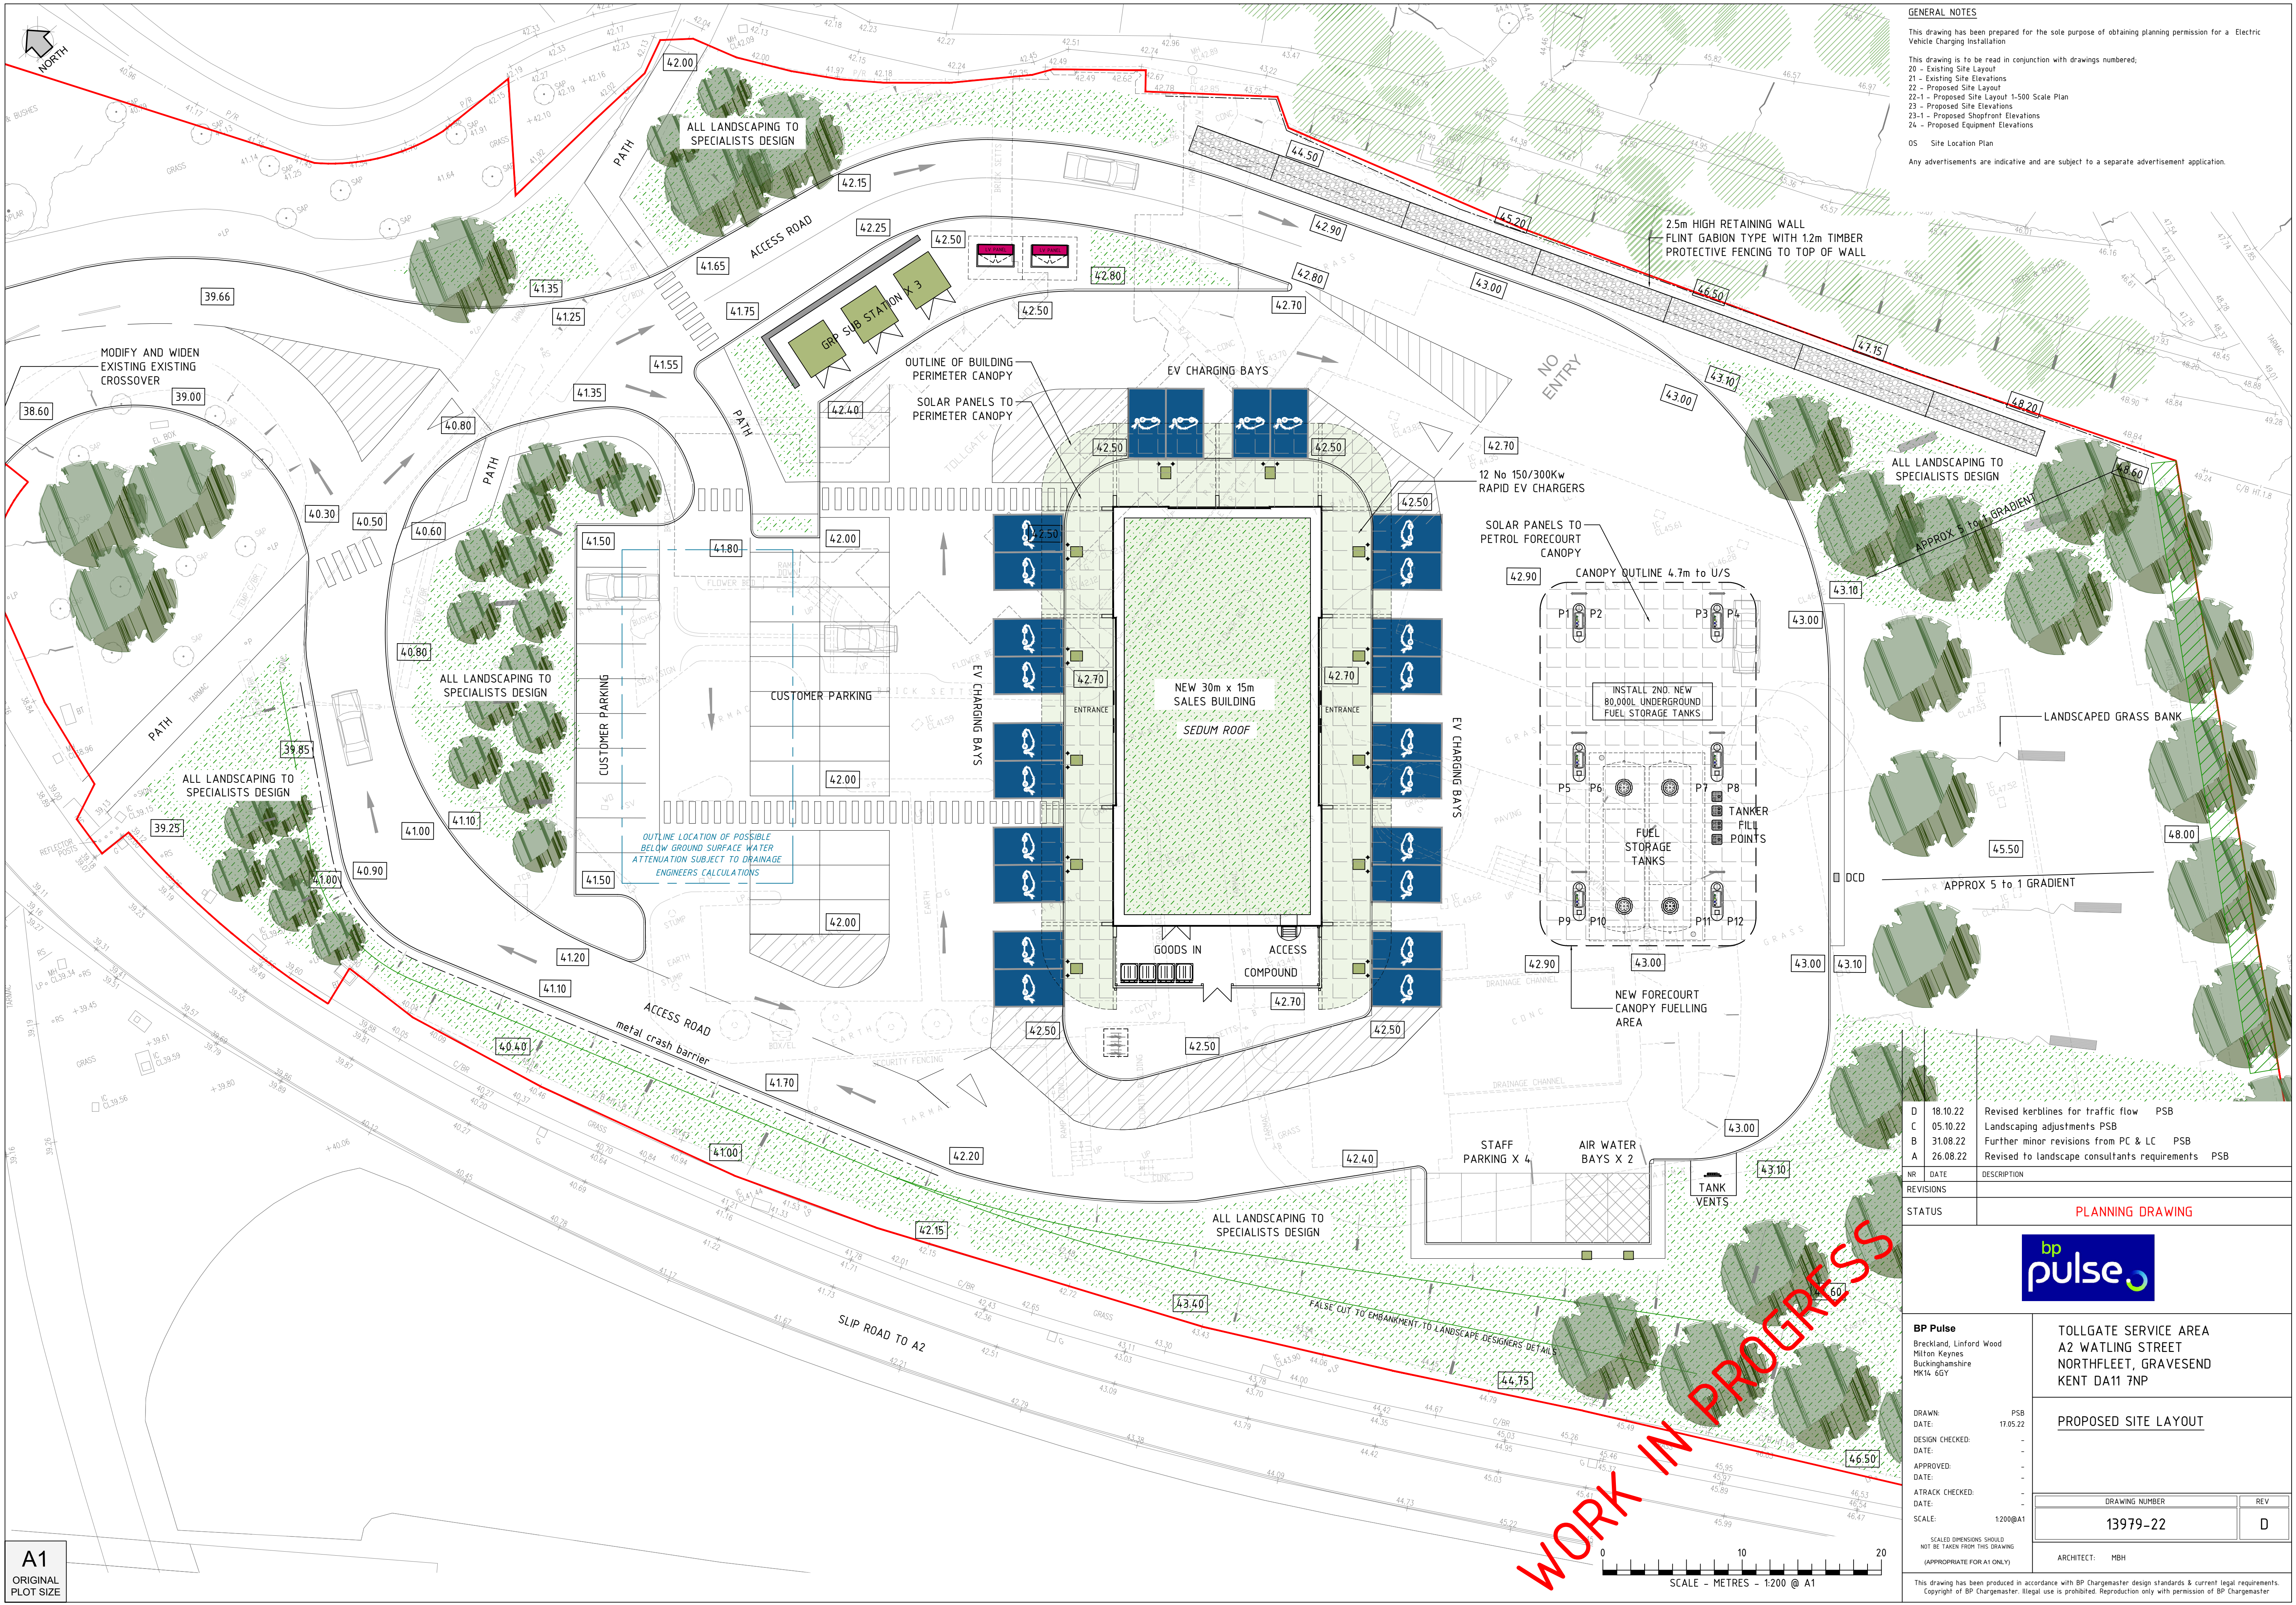

GENERAL NOTES

This drawing has been prepared for the sole purpose of obtaining planning permission for a Electric Vehicle Charging Installation

This drawing is to be read in conjunction with drawings numbered;

- 20 - Existing Site Layout
- 21 - Existing Site Elevations
- 22 - Proposed Site Layout
- 22-1 - Proposed Site Layout 1:500 Scale Plan
- 23 - Proposed Site Elevations
- 23-1 - Proposed Shopfront Elevations
- 24 - Proposed Equipment Elevations

05 Site Location Plan

Any advertisements are indicative and are subject to a separate advertisement application.

D	18.10.22	Revised kerblines for traffic flow	PSB
C	05.10.22	Landscaping adjustments	PSB
B	31.08.22	Further minor revisions from PC & LC	PSB
A	26.08.22	Revised to landscape consultants requirements	PSB
NR	DATE	DESCRIPTION	
REVISIONS			
STATUS		PLANNING DRAWING	



BP Pulse Breckland, Linford Wood Milton Keynes Buckinghamshire MK16 6GY		TOLLGATE SERVICE AREA A2 WATLING STREET NORTHFLEET, GRAVESEND KENT DA11 7NP	
DRAWN: PSB DATE: 17.05.22 DESIGN CHECKED: - DATE: - APPROVED: - DATE: - ATRACK CHECKED: - DATE: - SCALE: 1:200@A1		PROPOSED SITE LAYOUT	
SCALED DIMENSIONS SHOULD NOT BE TAKEN FROM THIS DRAWING (APPROPRIATE FOR A1 ONLY)		ARCHITECT: MBH	
		DRAWING NUMBER	REV
		13979-22	D

This drawing has been produced in accordance with BP Chargemaster design standards & current legal requirements. Copyright of BP Chargemaster. Illegal use is prohibited. Reproduction only with permission of BP Chargemaster

A1
ORIGINAL
PLOT SIZE

WORK IN PROGRESS

