




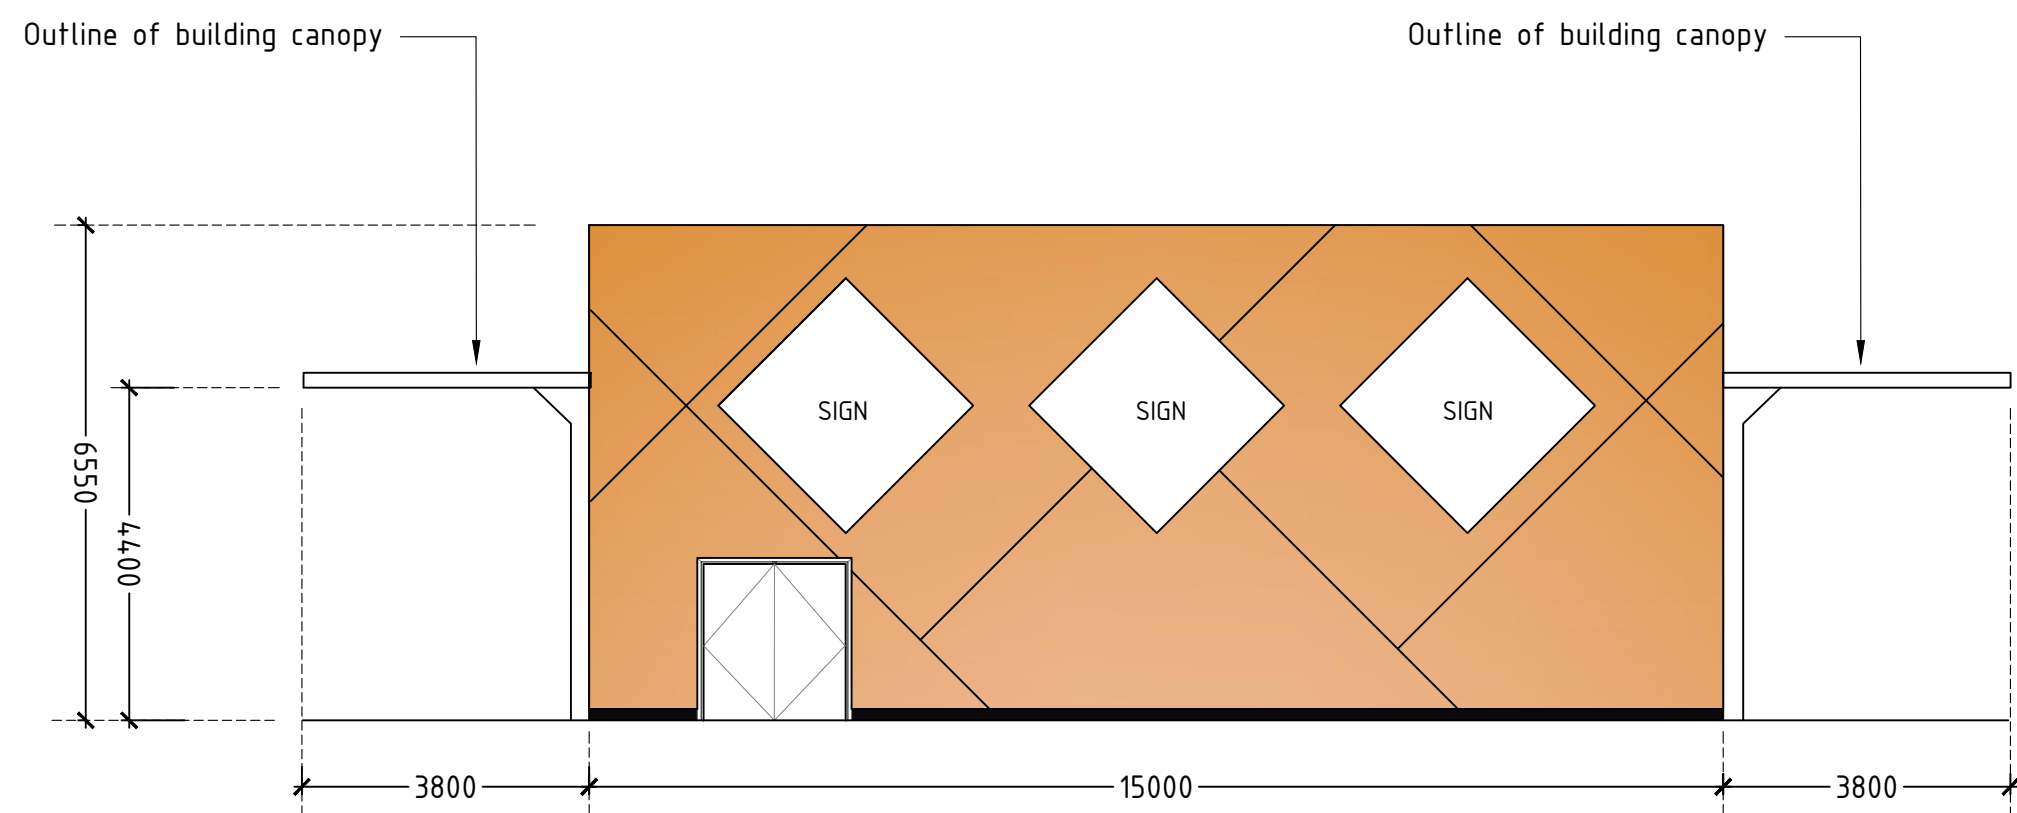


PROPOSED SHOPFRONT ELEVATION A
Scale 1:100

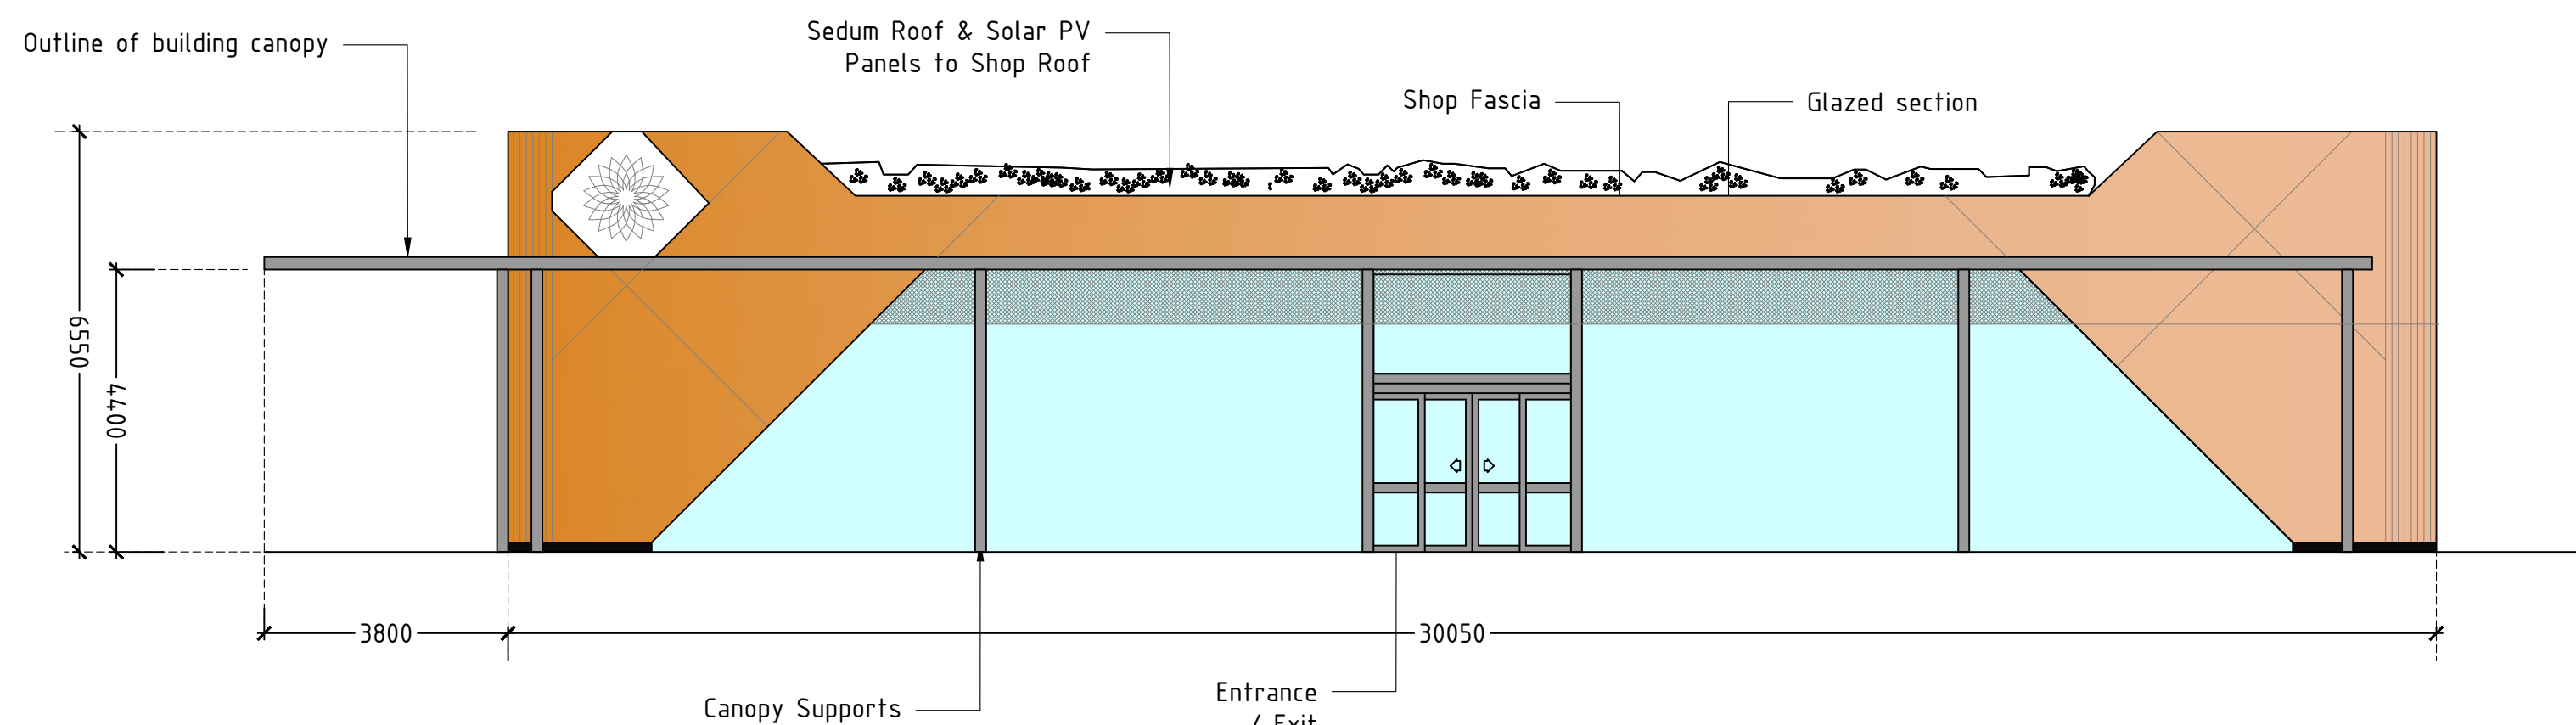


PROPOSED SHOPFRONT ELEVATION B
Scale 1:100

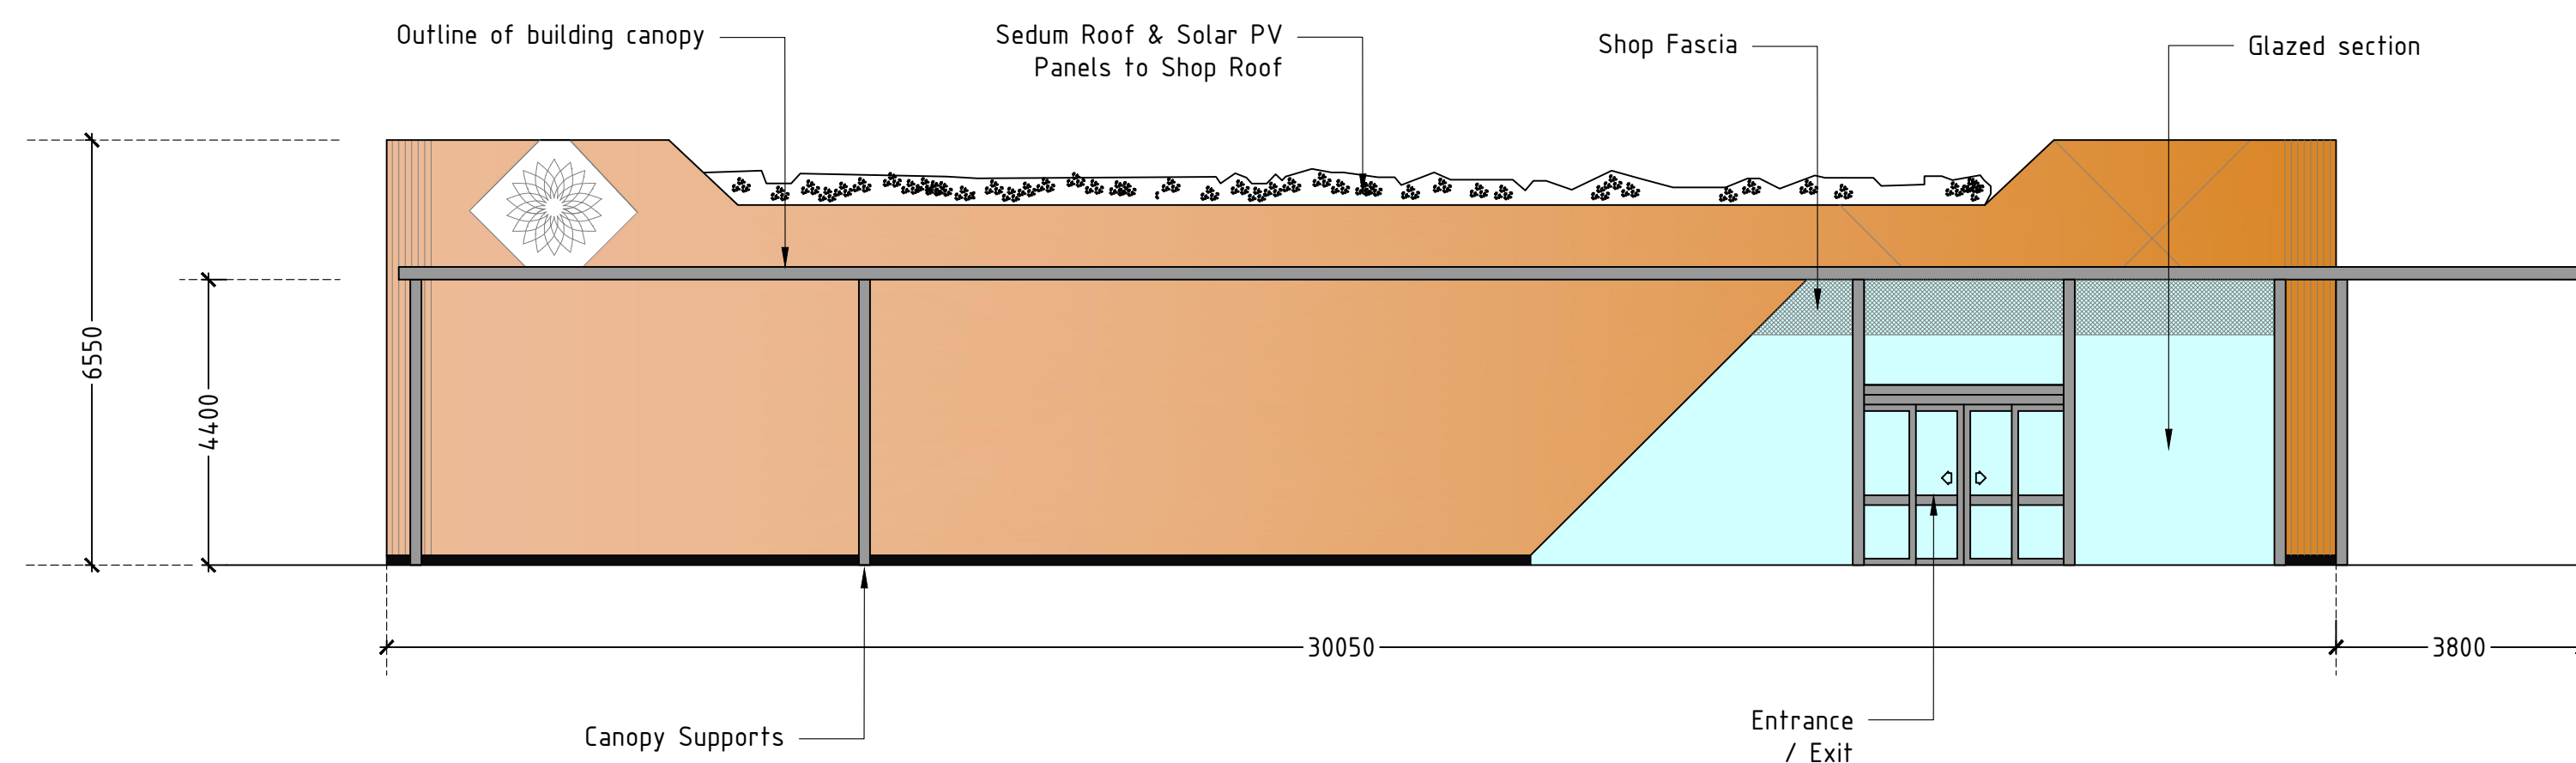

PROPOSED SHOPFRONT ELEVATION C
Scale 1:100

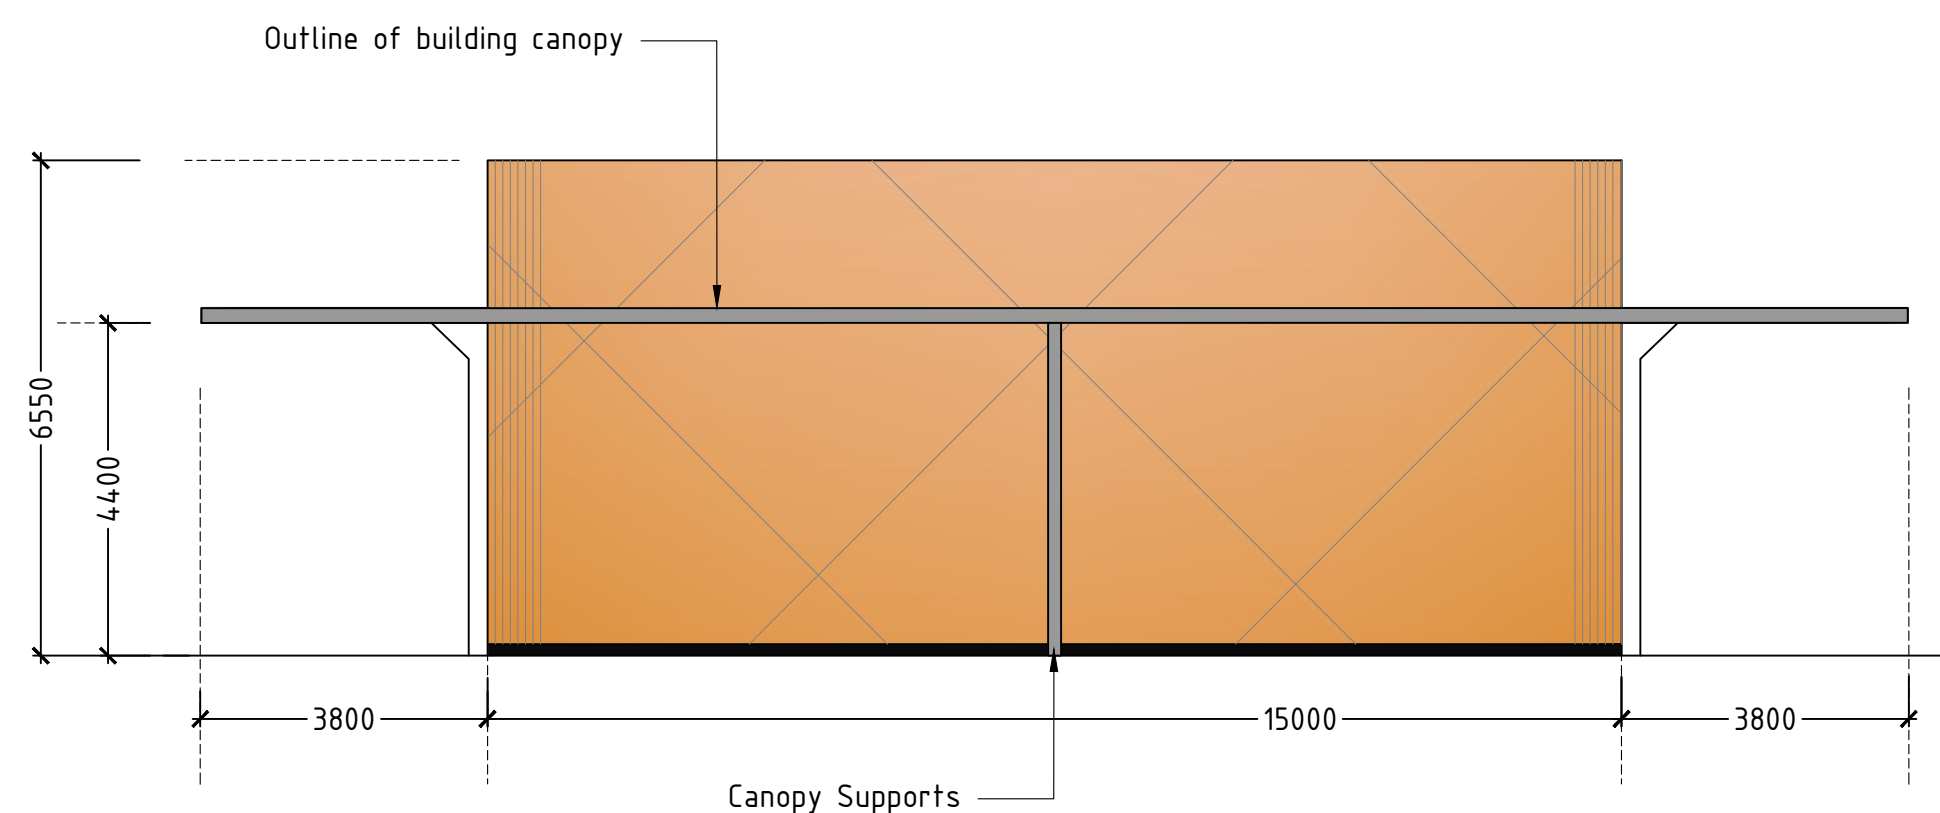

PROPOSED SHOPFRONT ELEVATION D
Scale 1:100

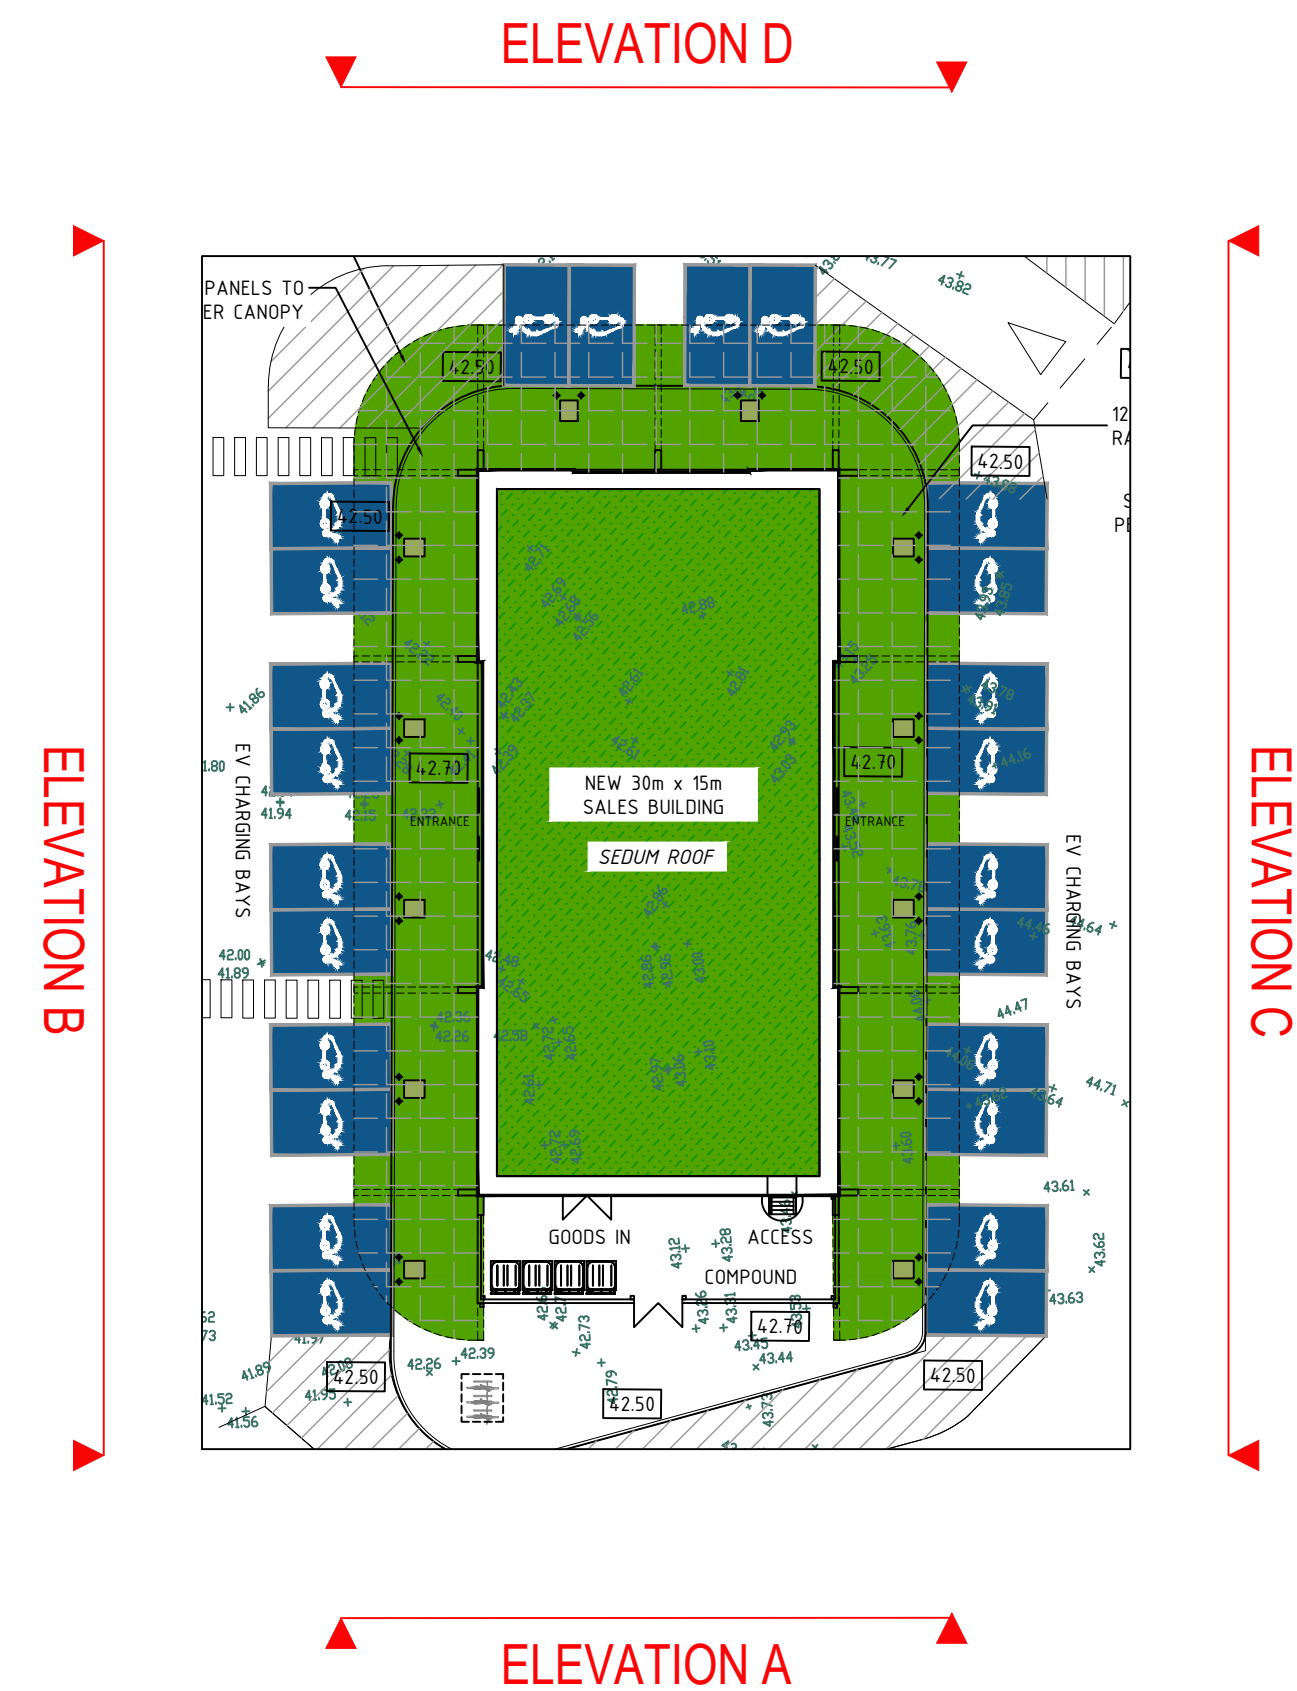

KEY PLAN
NTS

WORK IN PROGRESS

A1
ORIGINAL
PLOT SIZE

A	05.09.22	Revised to PCC	PSB				
NR	DATE	DESCRIPTION					
REVISIONS							
STATUS		PLANNING DRAWING					
							
BP Pulse Breckland, Linford Wood Milton Keynes Buckinghamshire MK14 6GY		TOLLGATE SERVICE AREA A2 WATLING STREET NORTHFLEET, GRAVESEND KENT DA11 7NP					
DRAWN: PSB DATE: 17.05.22 DESIGN CHECKED: - DATE: - APPROVED: - DATE: - ATRAK CHECKED: - DATE: - SCALE: 1:100@A1		<u>PROPOSED SHOP ELEVATIONS</u>					
SCALED DIMENSIONS SHOULD NOT BE TAKEN FROM THIS DRAWING (APPROPRIATE FOR A1 ONLY)		<table><tr><td>DRAWING NUMBER</td><td>REV</td></tr><tr><td>13979-23-1</td><td>A</td></tr></table>		DRAWING NUMBER	REV	13979-23-1	A
		DRAWING NUMBER	REV				
13979-23-1	A						
ARCHITECT: MBH							
This drawing has been produced in accordance with BP Chargemaster design standards & current legal requirements. Copyright of BP Chargemaster. Illegal use is prohibited. Reproduction only with permission of BP Chargemaster							