


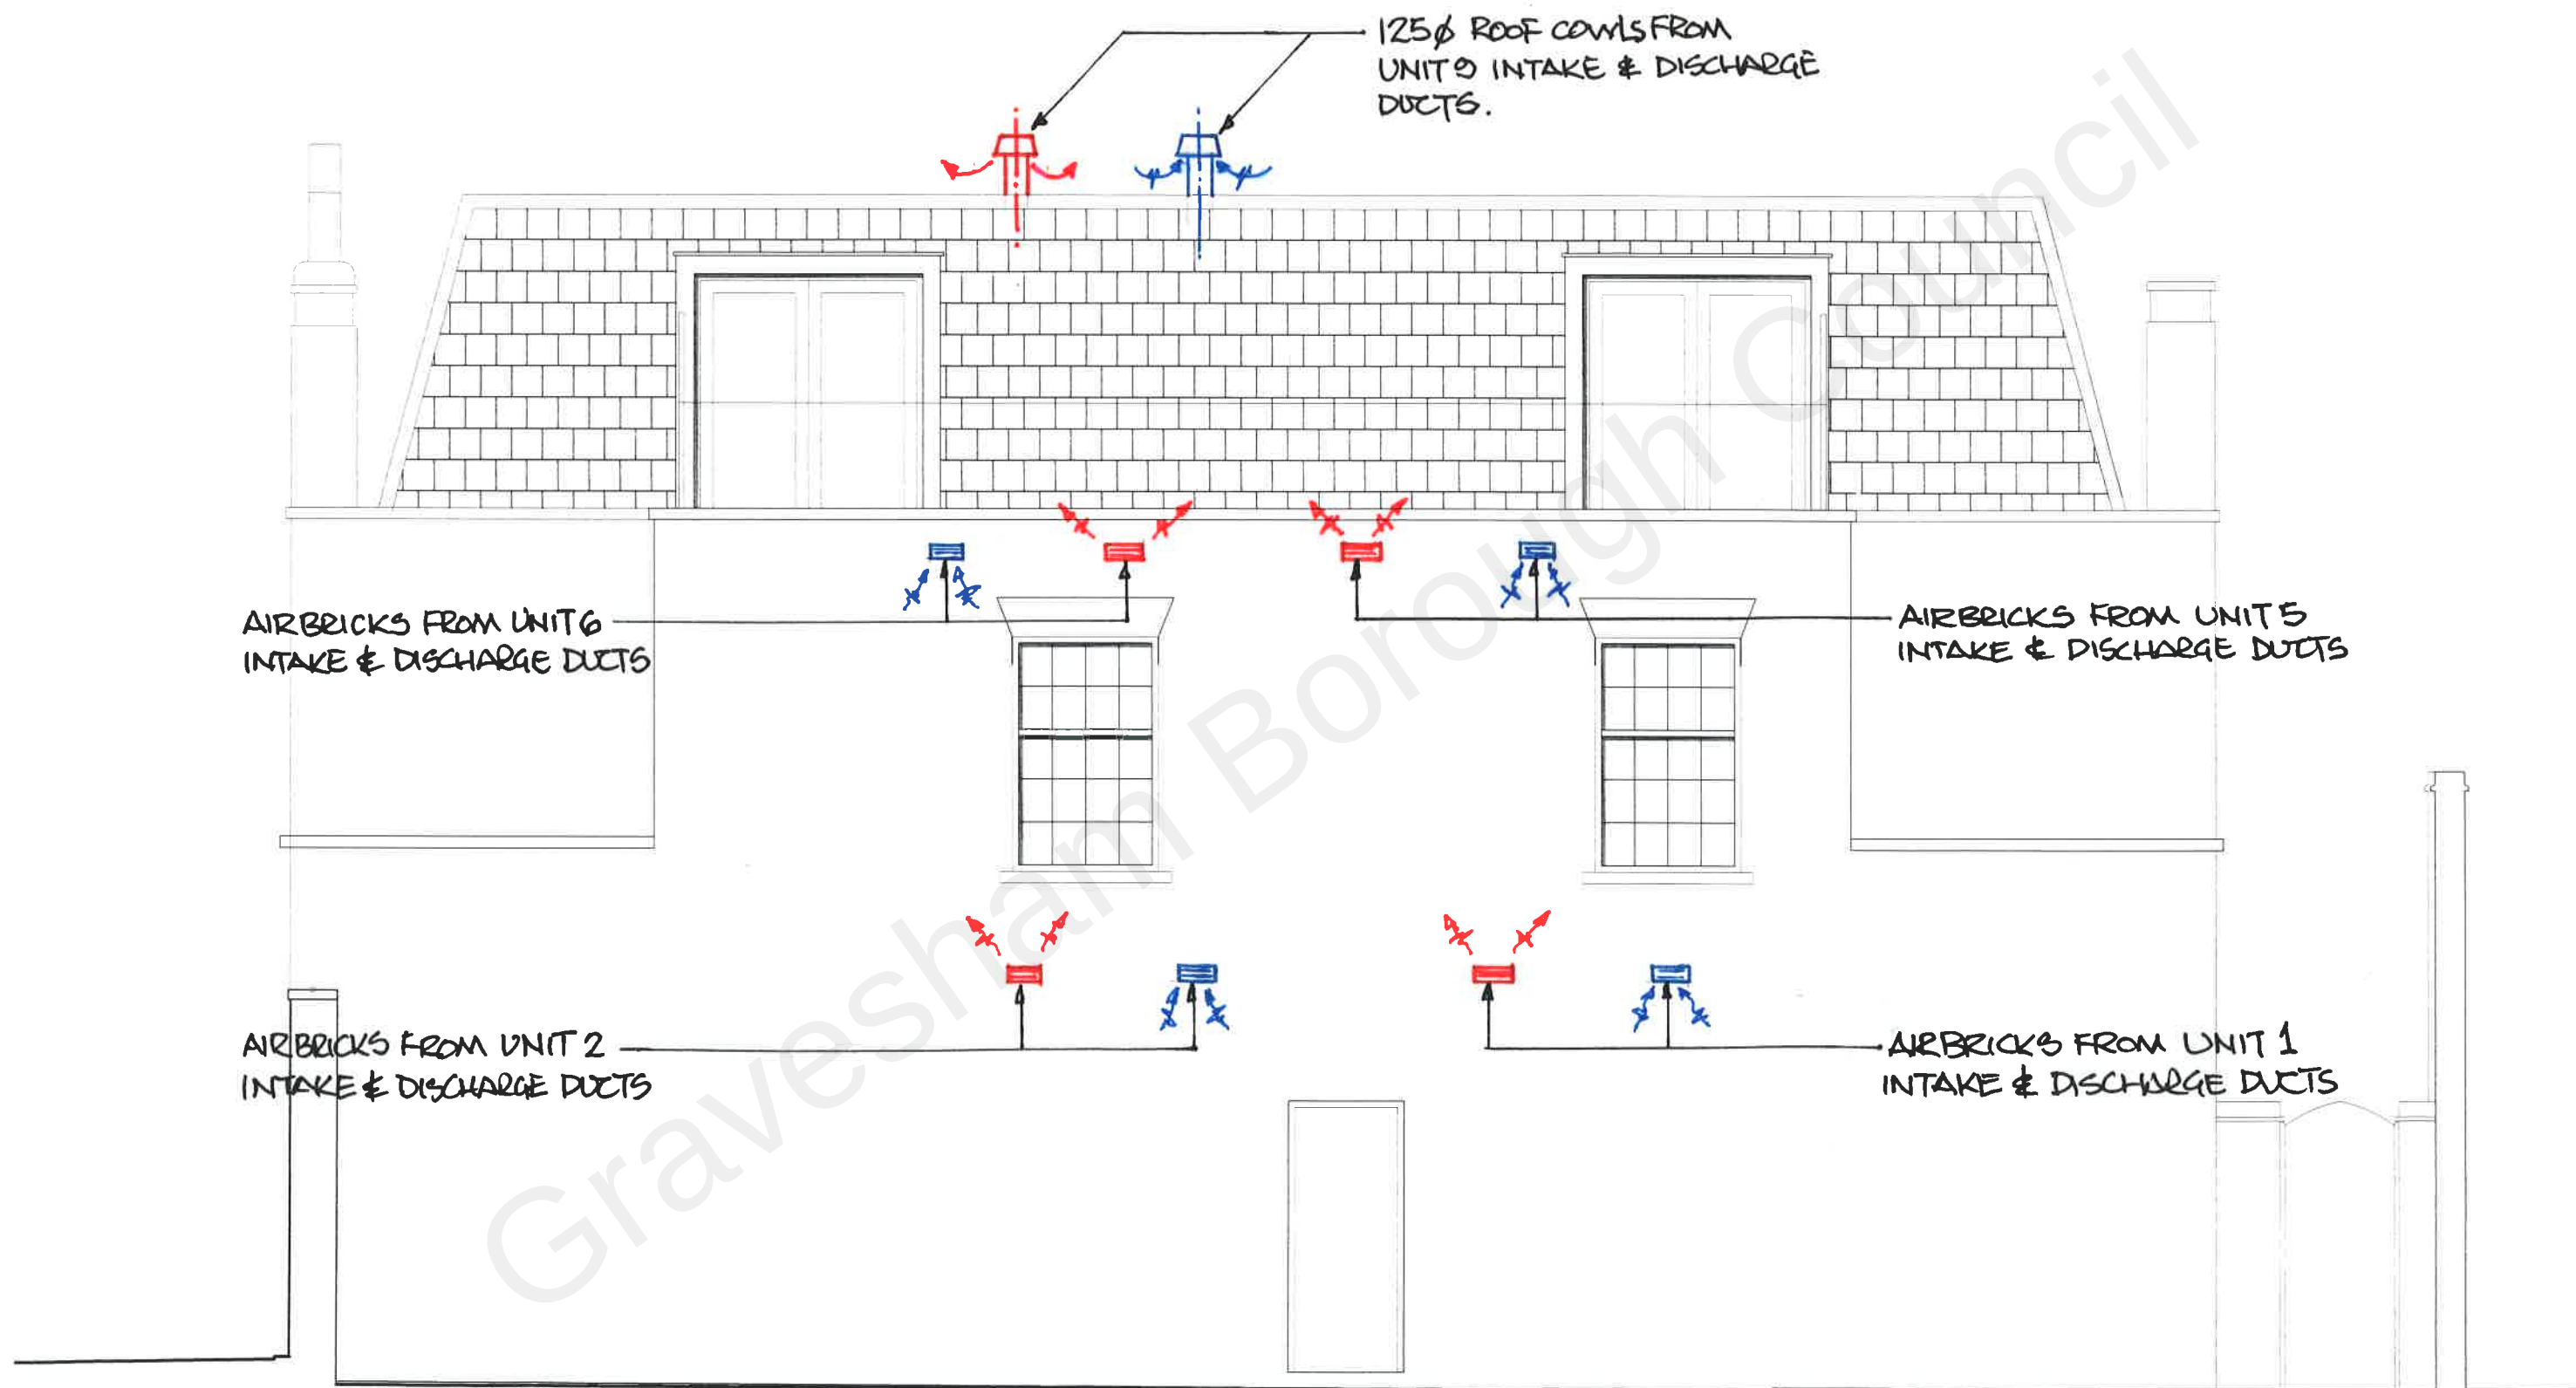

PROJECT:- THE CALLBOY, GRAVESEND
 TITLE :- REAR ELEVATION SHOWING
 VENTILATION TERMINALS

CLIENT:- BBD LTD

The Monalco Partnership LLP

42 The Bayle, Folkestone, Kent CT20 1SQ
 T 01303 232065 Email: tmp@monal.co.uk

Drawn By: PMN Checked By: PB
 Date: 27.7.2021 Scale: 1:50 @ A3
 Drawing No:

21/104 - 101