


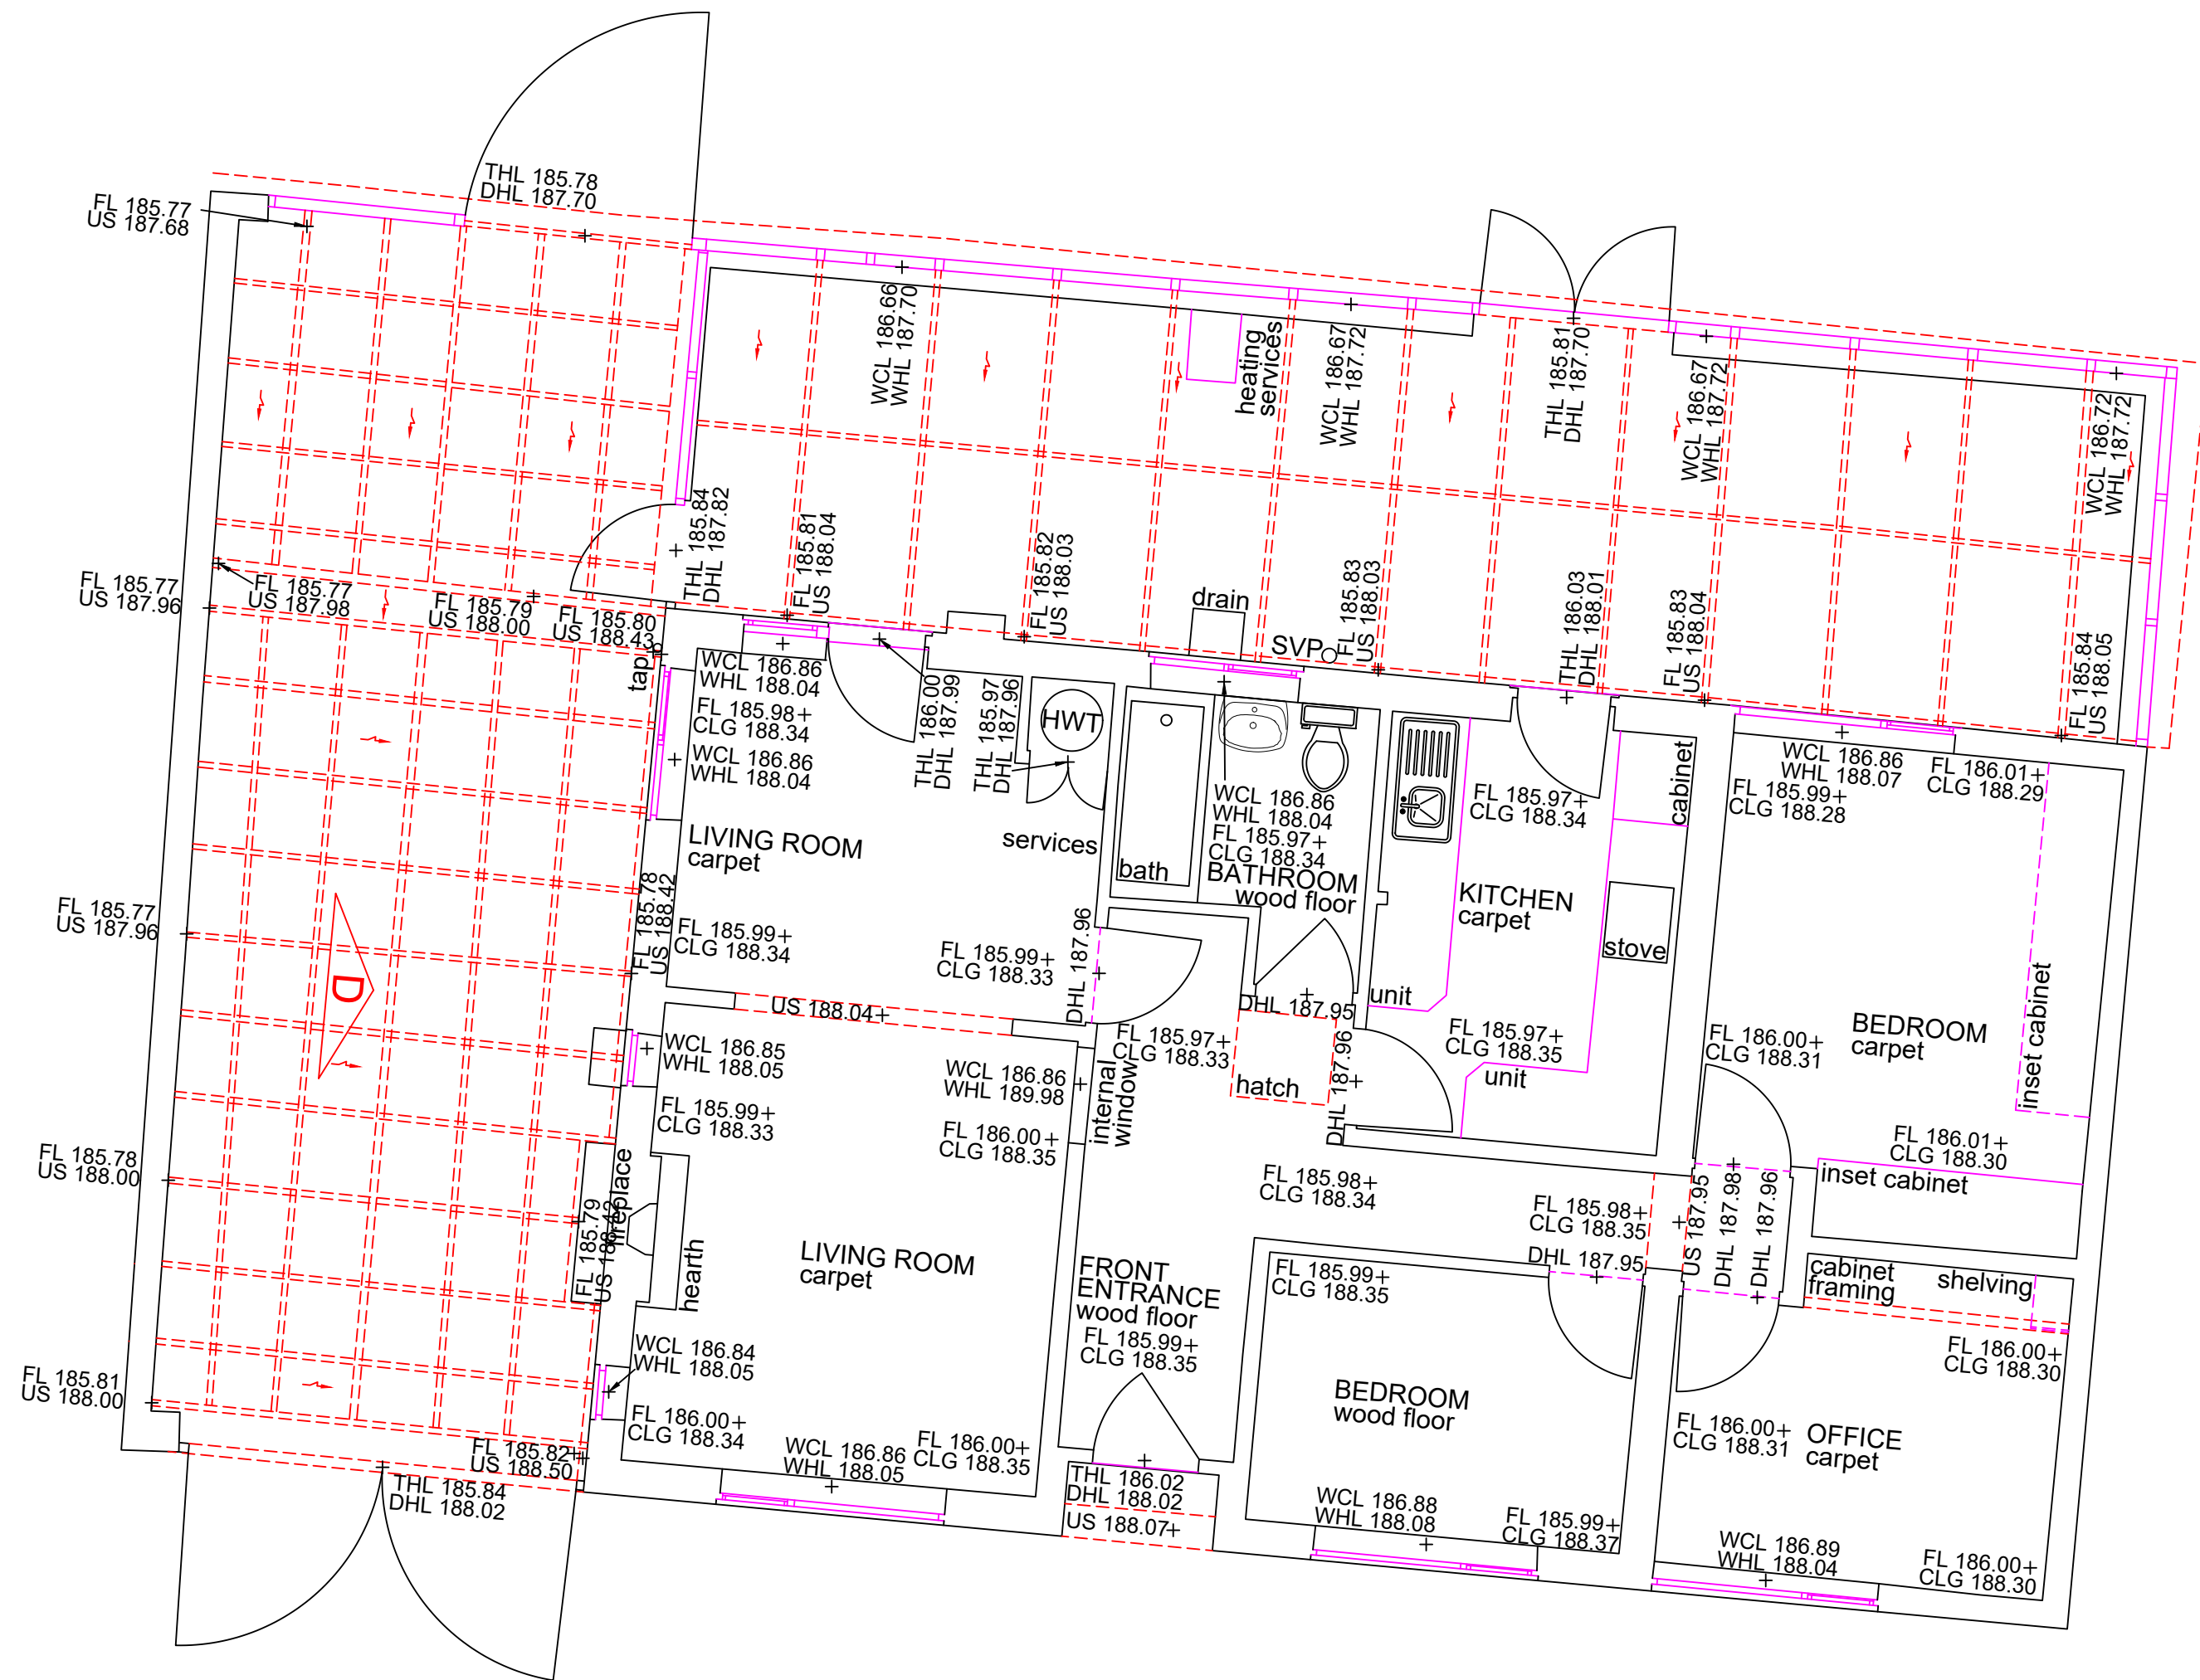

C



A



LEGEND

CLG	CEILING LEVEL
DP	DOWN PIPE
DHL	DOOR HEAD LEVEL
FL	FLOOR LEVEL
HWT	HOT WATER TANK
IC	INSPECTION COVER
SVP	SOIL VENT PIPE
RWP	RAINWATER PIPE
SCLG	SUSPENDED CEILING
SV	STOP VALVE
SVP	SOIL VENT PIPE
TOW	TOP OF WALL
US	UNDERSIDE LEVEL
USB	UNDERSIDE OF BEAM
WCL	WINDOW CILL LEVEL
WHL	WINDOW HEAD LEVEL
	CEILING/ROOF SLOPE UP

NOTES

1. ALL LEVELS RELATED TO ORDNANCE SURVEY DATUM DERIVED FROM STATIC GPS OBSERVATIONS.
2. SURVEY GRID IS RELATED TO ORDNANCE SURVEY DATUM AND DERIVED FROM STATIC GPS OBSERVATIONS, WITH A SCALE FACTOR OF 1.

ANSurveys Ltd
3 Sleigh Road, Sturry, Kent, CT2 0HR
Tel. 01227 710316
email. alan@ansurveys.co.uk
WWW.ansurveys.co.uk



Drawing Title
GROUND FLOOR PLAN OF
THREE TREES, NEWLANDS LANE, MEOPHAM, KENT, DA13 0RD

Client
DIRECT-DRYWALL LTD

Drawing Number 2

Original Sheet Size A2 AT 1/50

Drawn By:
A.NICHOLSON

Cad Filename
THREE TREES MEOPHAM FINAL.dwg

Date :
13th April 2026

Revision :