


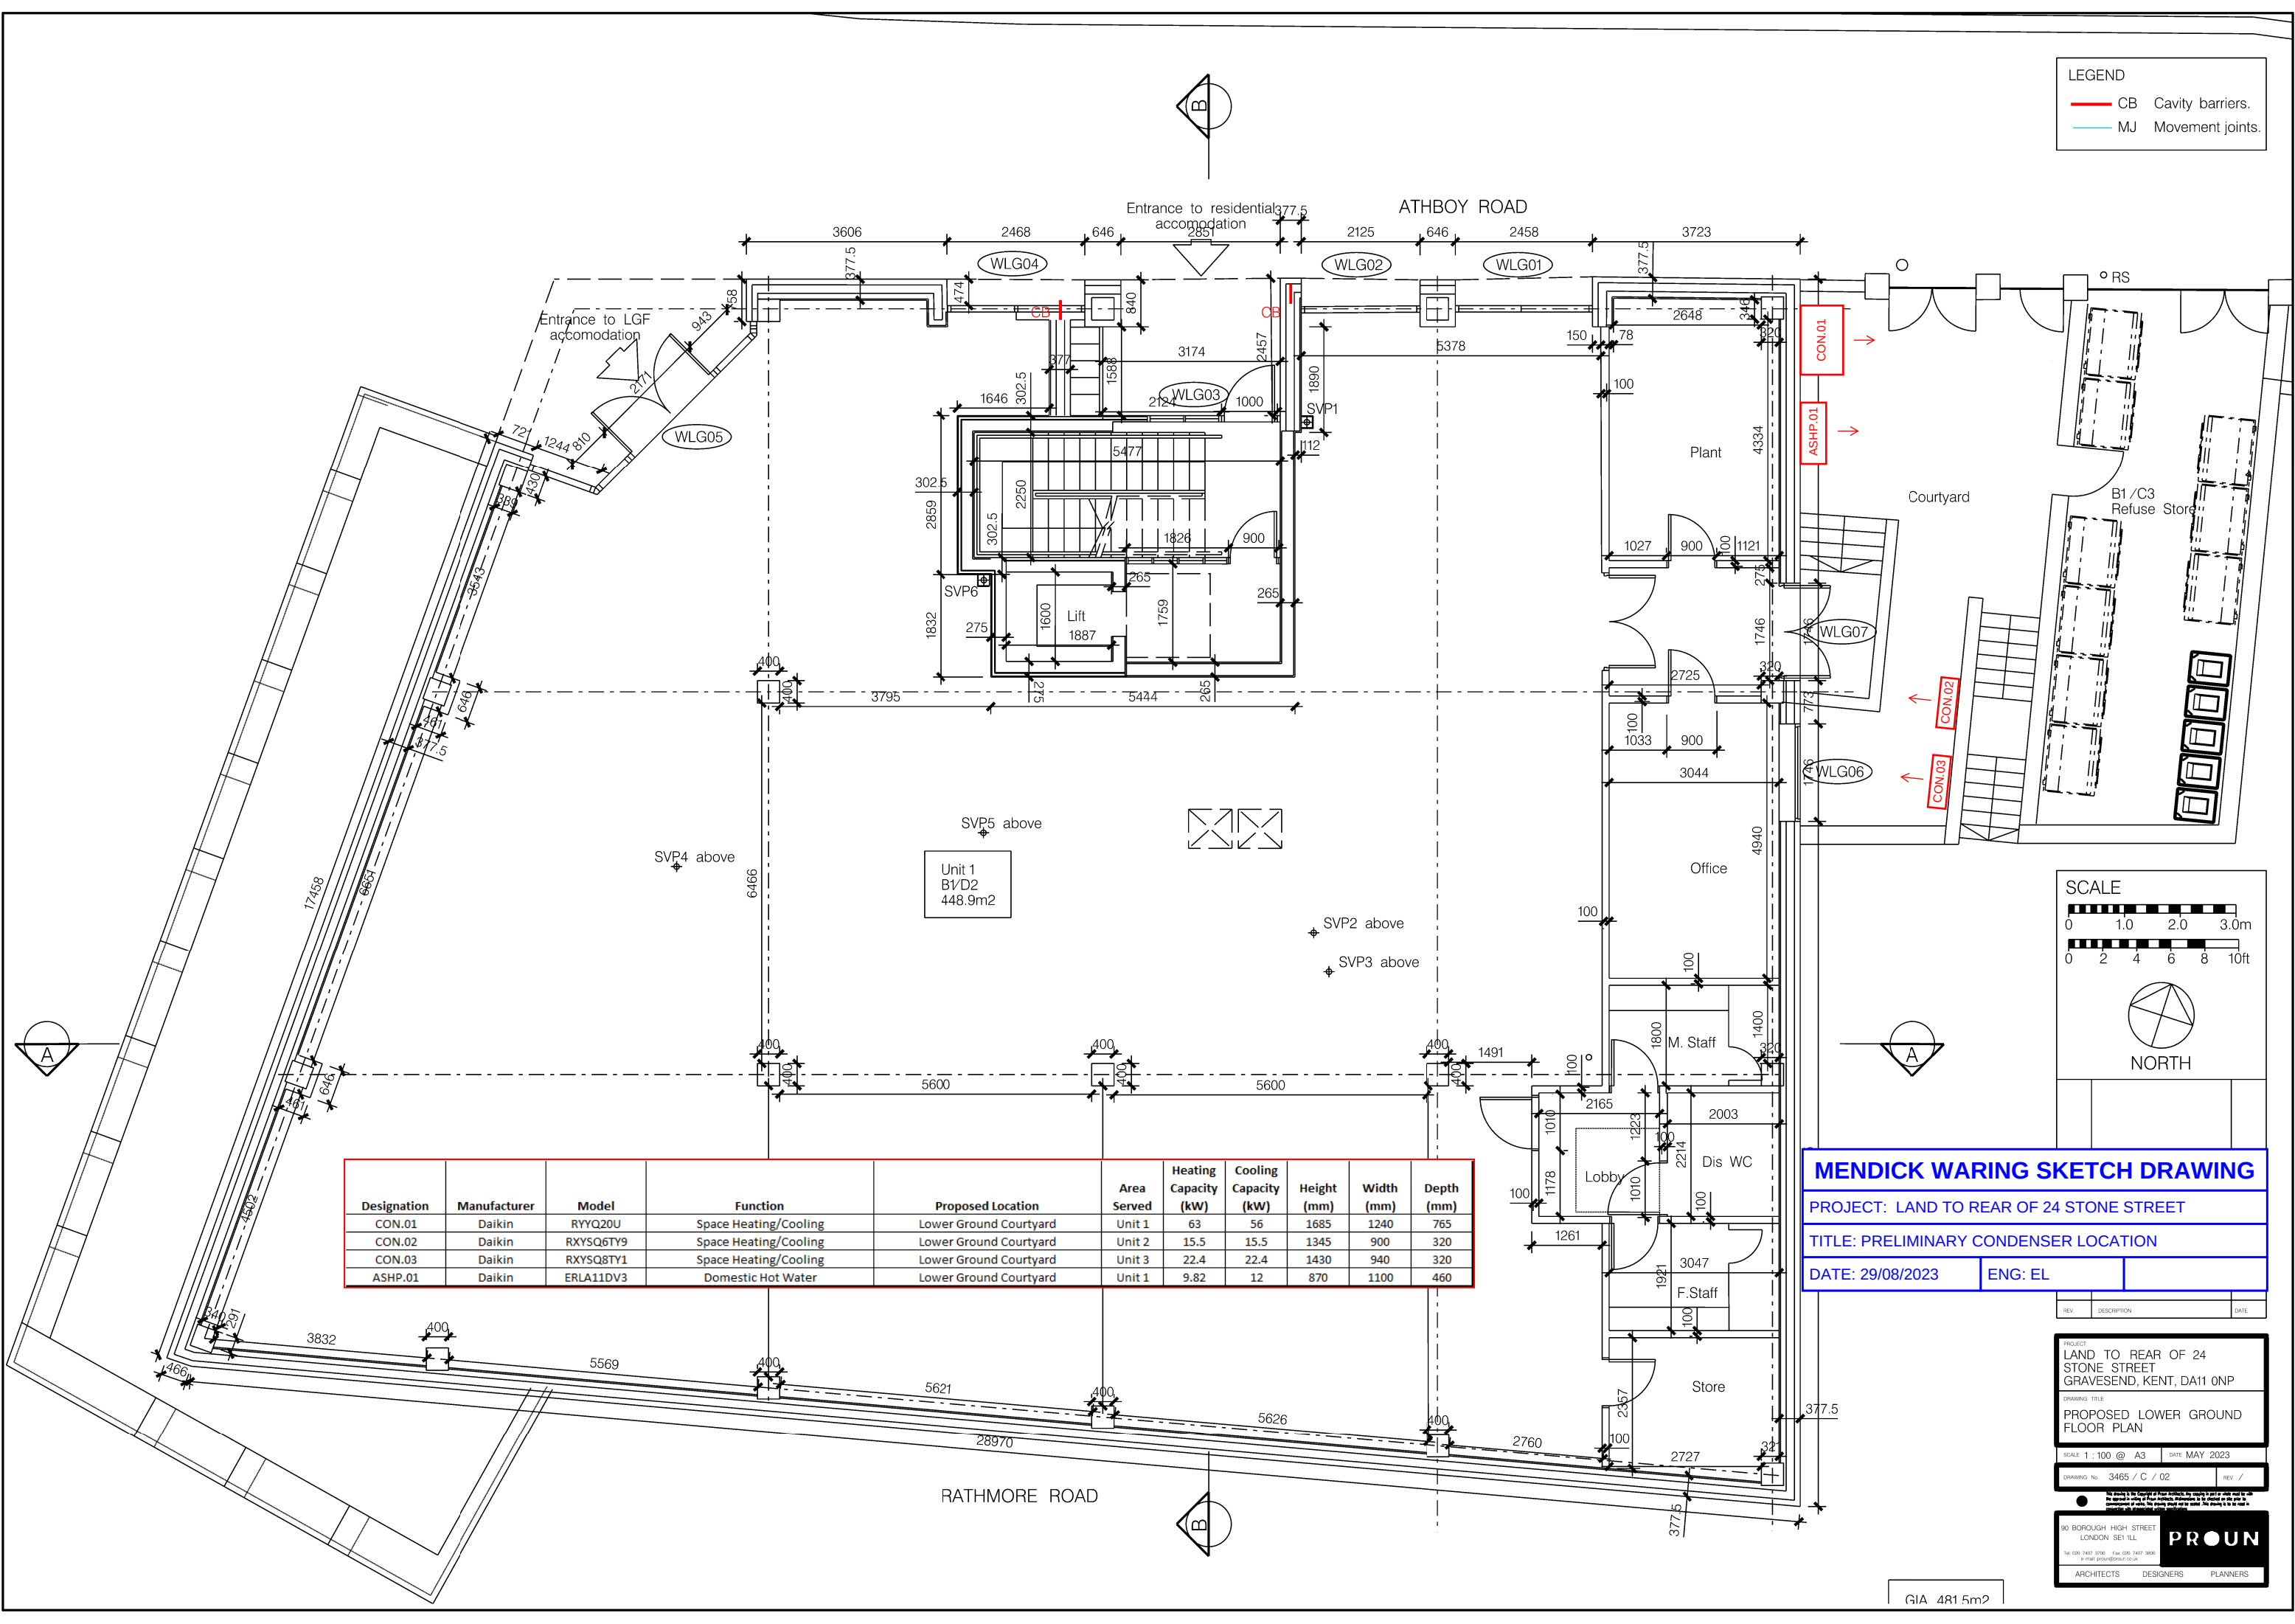

LEGEND

CB

 Cavity barriers.

MJ

 Movement joints.

Designation	Manufacturer	Model	Function	Proposed Location	Area Served	Heating Capacity (kW)	Cooling Capacity (kW)	Height (mm)	Width (mm)	Depth (mm)
CON.01	Daikin	RYYQ20U	Space Heating/Cooling	Lower Ground Courtyard	Unit 1	63	56	1685	1240	765
CON.02	Daikin	RXYSQ6TY9	Space Heating/Cooling	Lower Ground Courtyard	Unit 2	15.5	15.5	1345	900	320
CON.03	Daikin	RXYSQ8TY1	Space Heating/Cooling	Lower Ground Courtyard	Unit 3	22.4	22.4	1430	940	320
ASHP.01	Daikin	ERLA11DV3	Domestic Hot Water	Lower Ground Courtyard	Unit 1	9.82	12	870	1100	460

MENDICK WARING SKETCH DRAWING

PROJECT: LAND TO REAR OF 24 STONE STREET

TITLE: PRELIMINARY CONDENSER LOCATION

DATE: 29/08/2023

ENG: EL

REV.	DESCRIPTION	DATE
------	-------------	------

PROJECT

LAND TO REAR OF 24 STONE STREET GRAVESEND, KENT, DA11 0NP

DRAWING TITLE

PROPOSED LOWER GROUND FLOOR PLAN

SCALE 1 : 100 @ A3

DATE MAY 2023

DRAWING NO. 3465 / C / 02

REV. /


30 BOROUGH HIGH STREET LONDON SE1 1LL

PROUN

ARCHITECTS DESIGNERS PLANNERS

GIA 481.5m2

Designation	Manufacturer	Model	Function	Proposed Location	Area Served	Heating Capacity (kW)	Cooling Capacity (kW)	Height (mm)	Width (mm)	Depth (mm)
ASHP.02	Daikin	ERLA11DV3	Domestic Hot Water, Space Heating	4th Floor Rooftop	Flat 1	9.82	12	870	1100	460
ASHP.03	Daikin	ERLA11DV3	Domestic Hot Water, Space Heating	4th Floor Rooftop	Flat 2	9.82	12	870	1100	460
ASHP.04	Daikin	ERLA11DV3	Domestic Hot Water, Space Heating	4th Floor Rooftop	Flat 3	9.82	12	870	1100	460
ASHP.05	Daikin	ERLA11DV3	Domestic Hot Water, Space Heating	4th Floor Rooftop	Flat 4	9.82	12	870	1100	460
ASHP.06	Daikin	ERLA11DV3	Domestic Hot Water, Space Heating	4th Floor Rooftop	Flat 5	9.82	12	870	1100	460
ASHP.07	Daikin	ERLA11DV3	Domestic Hot Water, Space Heating	4th Floor Rooftop	Flat 6	9.82	12	870	1100	460
ASHP.08	Daikin	ERLA11DV3	Domestic Hot Water, Space Heating	4th Floor Rooftop	Flat 7	9.82	12	870	1100	460
ASHP.09	Daikin	ERLA11DV3	Domestic Hot Water, Space Heating	4th Floor Rooftop	Flat 8	9.82	12	870	1100	460
ASHP.10	Daikin	ERLA11DV3	Domestic Hot Water, Space Heating	4th Floor Rooftop	Flat 9	9.82	12	870	1100	460
ASHP.11	Daikin	ERLA11DV3	Domestic Hot Water, Space Heating	4th Floor Rooftop	Flat 10	9.82	12	870	1100	460
ASHP.12	Daikin	ERLA11DV3	Domestic Hot Water, Space Heating	4th Floor Rooftop	Flat 11	9.82	12	870	1100	460
ASHP.13	Daikin	ERLA11DV3	Domestic Hot Water, Space Heating	4th Floor Rooftop	Flat 12	9.82	12	870	1100	460
ASHP.14	Daikin	ERLA11DV3	Domestic Hot Water, Space Heating	4th Floor Rooftop	Flat 13	9.82	12	870	1100	460
ASHP.15	Daikin	ERLA11DV3	Domestic Hot Water, Space Heating	4th Floor Rooftop	Flat 14	9.82	12	870	1100	460

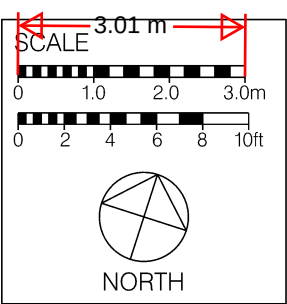

LEGEND

CB Cavity barriers.

MJ Movement joints.

24 No. REFRIGERANT PIPES IN 600mm CABLE TRAY T/B TO SERVE FLAT 1 TO 12

4 No. REFRIGERANT PIPES OFFSETS AT H/L TO SERVE FLAT 13 & 14

16 No. REFRIGERANT PIPES IN 450mm CABLE TRAY

12 No. REFRIGERANT PIPES IN 300mm CABLE TRAY

MENDICK WARING SKETCH DRAWING

PROJECT: LAND TO REAR OF 24 STONE STREET

TITLE: PRELIMINARY CONDENSER LOCATION

DATE: 29/08/2023

ENG: EL

REV.	DESCRIPTION	DATE

PROJECT

LAND TO REAR OF 24 STONE STREET GRAVESEND, KENT, DA11 0NP

DRAWING TITLE

PROPOSED FOURTH FLOOR PLAN

SCALE

1 : 100 @ A3

DATE

MAY 2023

DRAWING NO.

3465 / C / 07

REV.

/

30 BOROUGH HIGH STREET LONDON SE1 1LL

PRON

ARCHITECTS DESIGNERS PLANNERS