
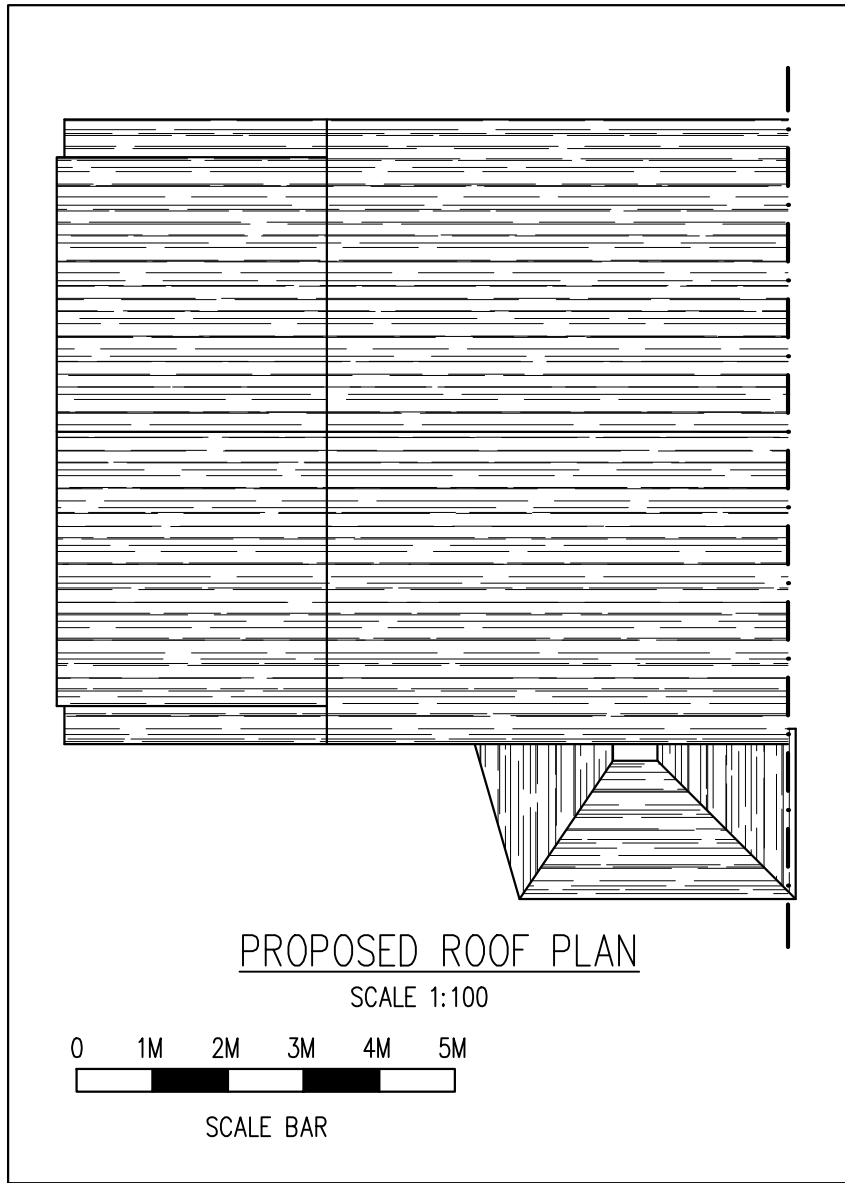
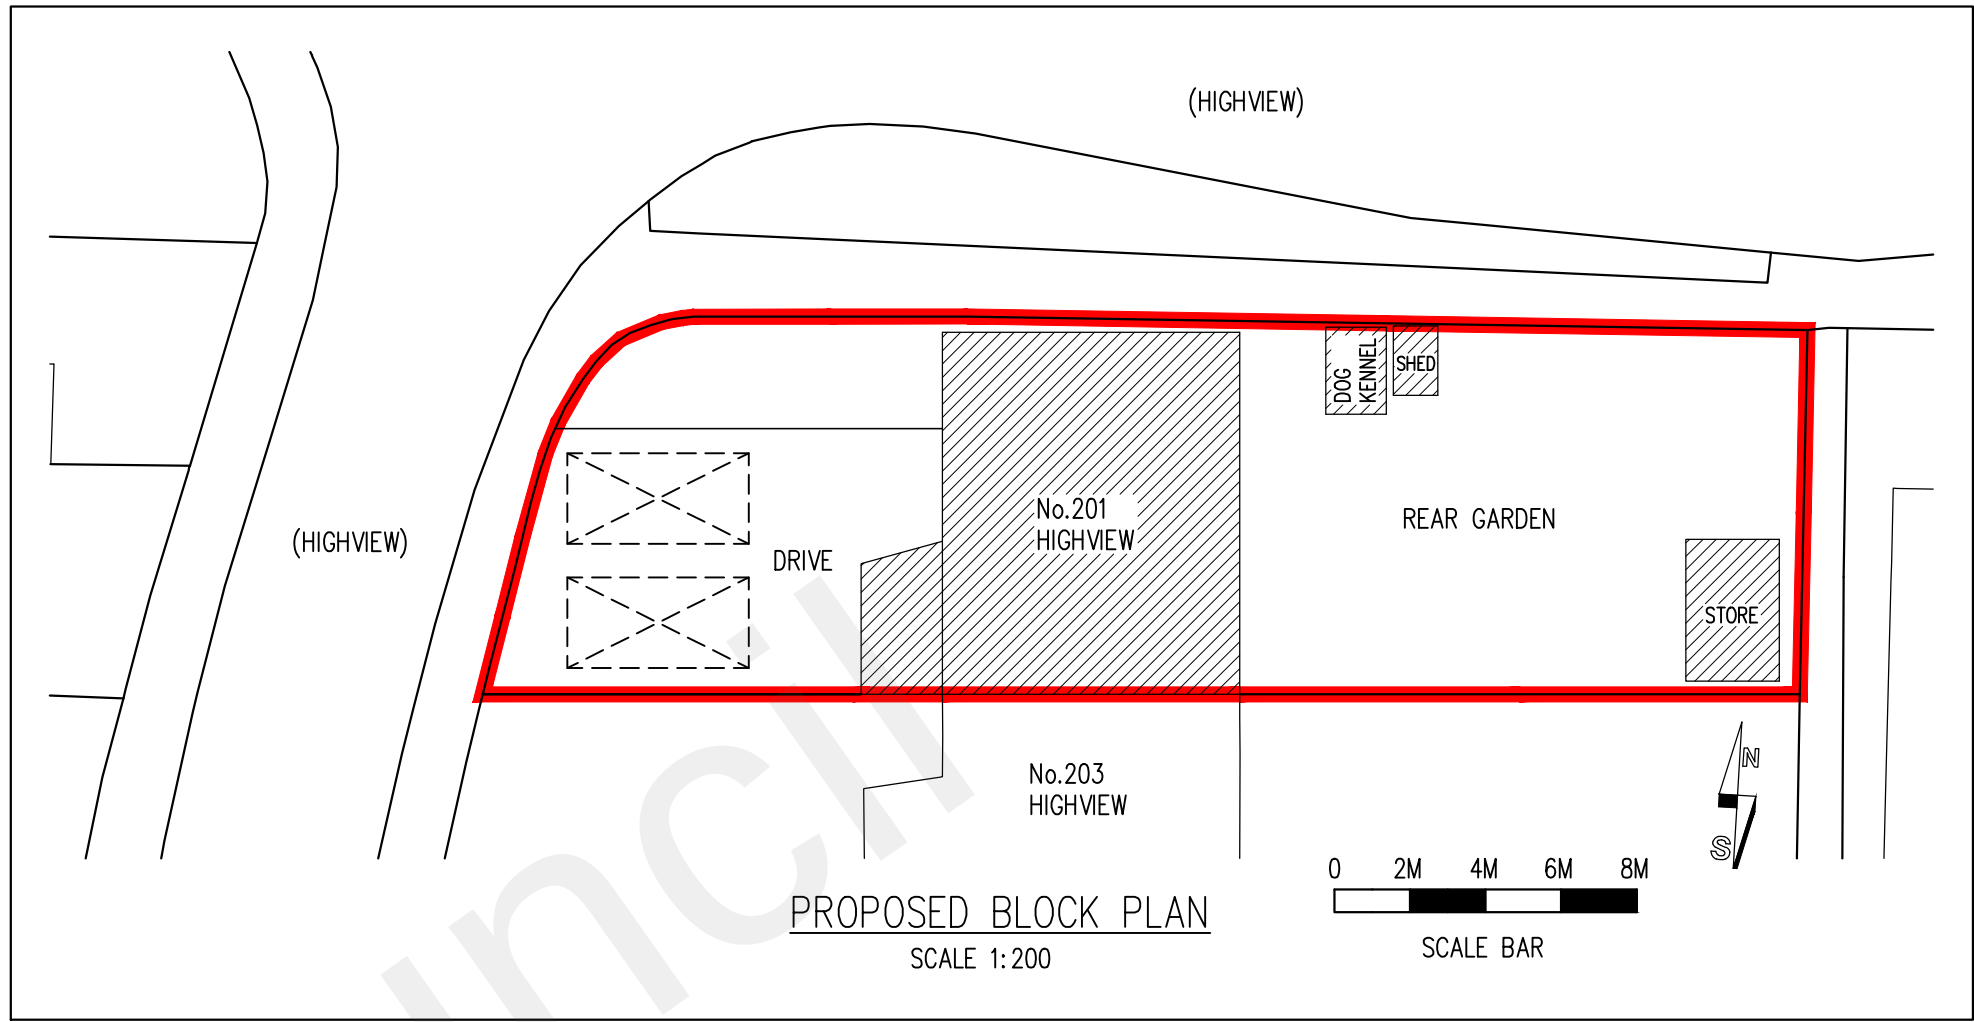
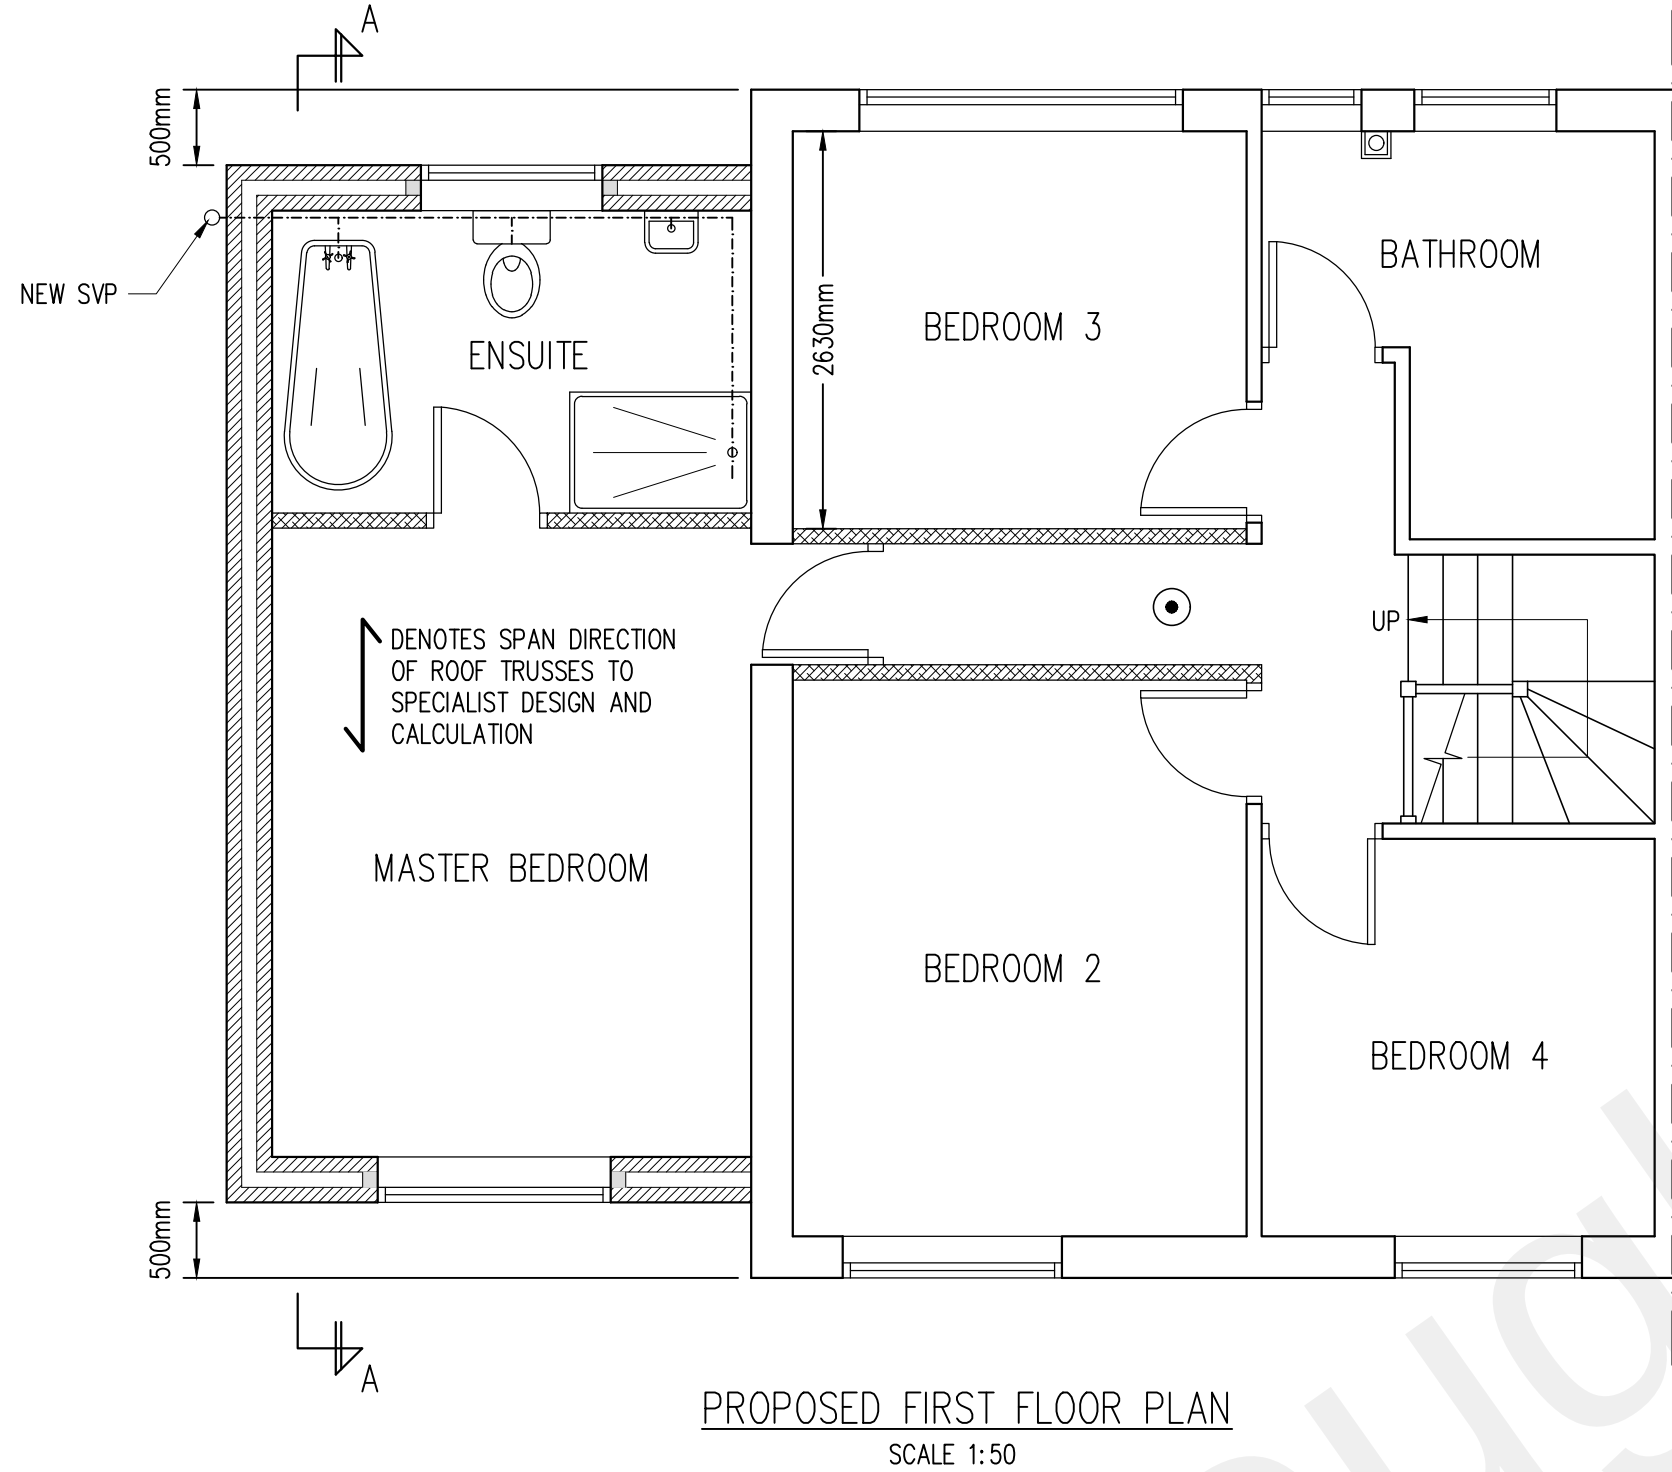


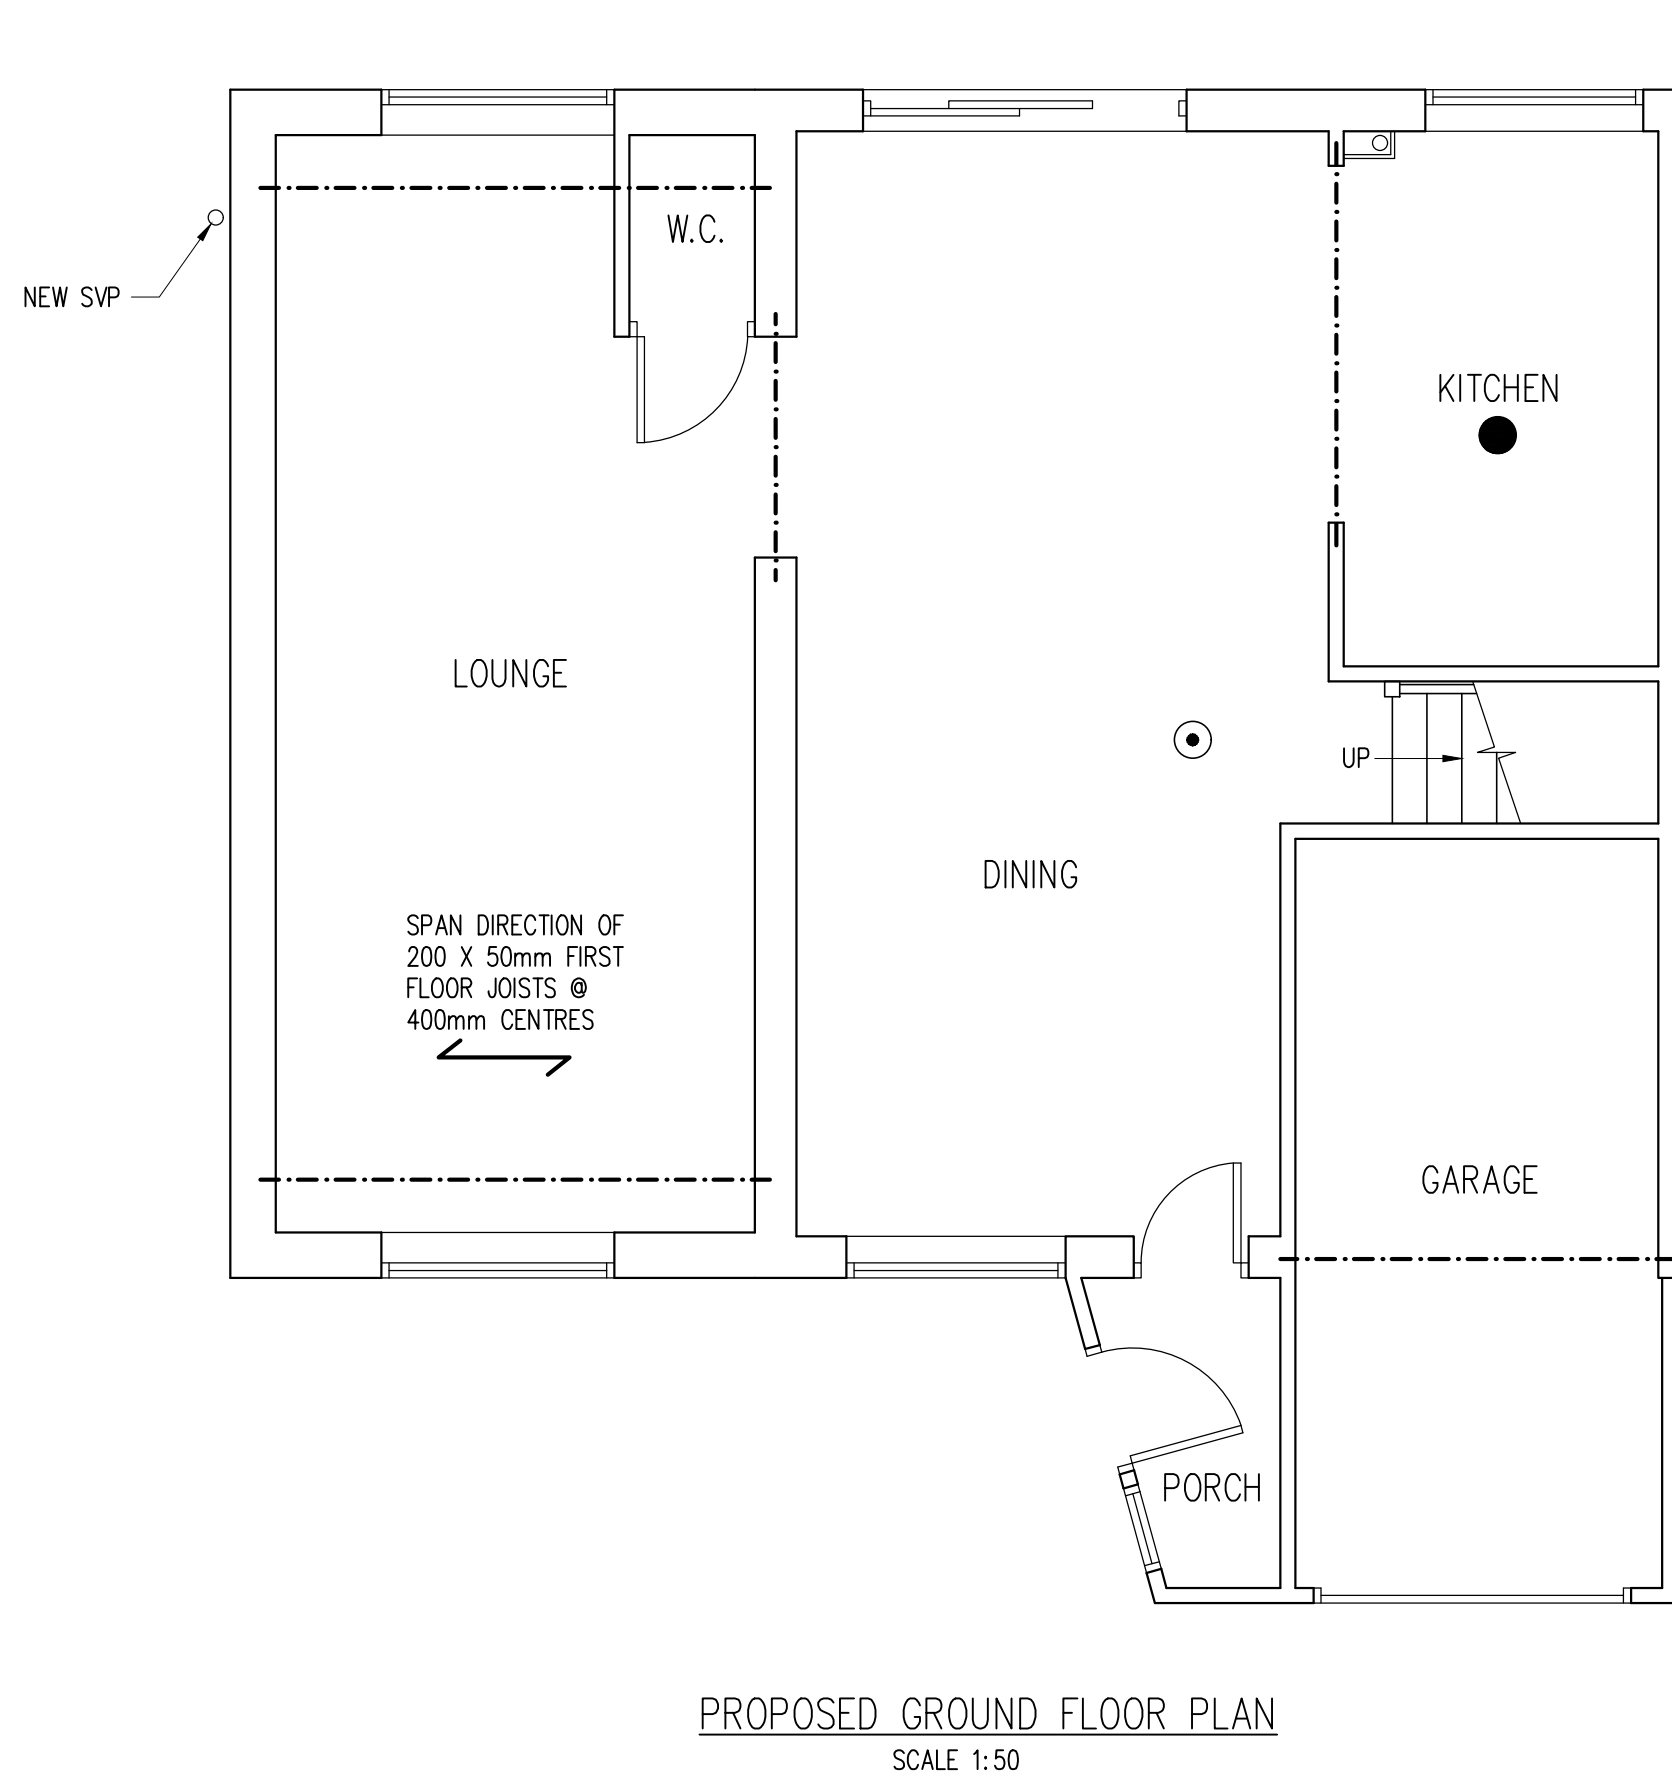

A HEAT DETECTOR IS TO BE PROVIDED TO THE KITCHEN IN ACCORDANCE WITH B.S. 5839 PART 1 & 6


SMOKE DETECTORS ARE TO BE INSTALLED AT GROUND AND FIRST FLOOR LEVEL IN THE VICINITY OF THE STAIRCASE CONNECTED TO THE MAINS ELECTRICAL SUPPLY WITH BATTERY BACK UP INTERCONNECTED WITH THE HEAT DETECTOR.


AN INSTALLATION AND COMMISSIONING CERTIFICATE IS REQUIRED IN RESPECT OF THE FIRE ALARM

THE OCCUPIERS SHOULD BE PROVIDED WITH DOCUMENTATION ALLOWING THEM TO USE AND MAINTAIN THE FIRE ALARM

LEGEND

- DENOTES MAINS WIRE LINKED SMOKE ALARMS WITH BATTERY BACK UP AND A SEPARATE FUSE ON THE DISTRIBUTION BOARD
- DENOTES MAINS WIRE LINKED HEAT DETECTOR WITH BATTERY BACK UP AND A SEPARATE FUSE ON THE DISTRIBUTION BOARD

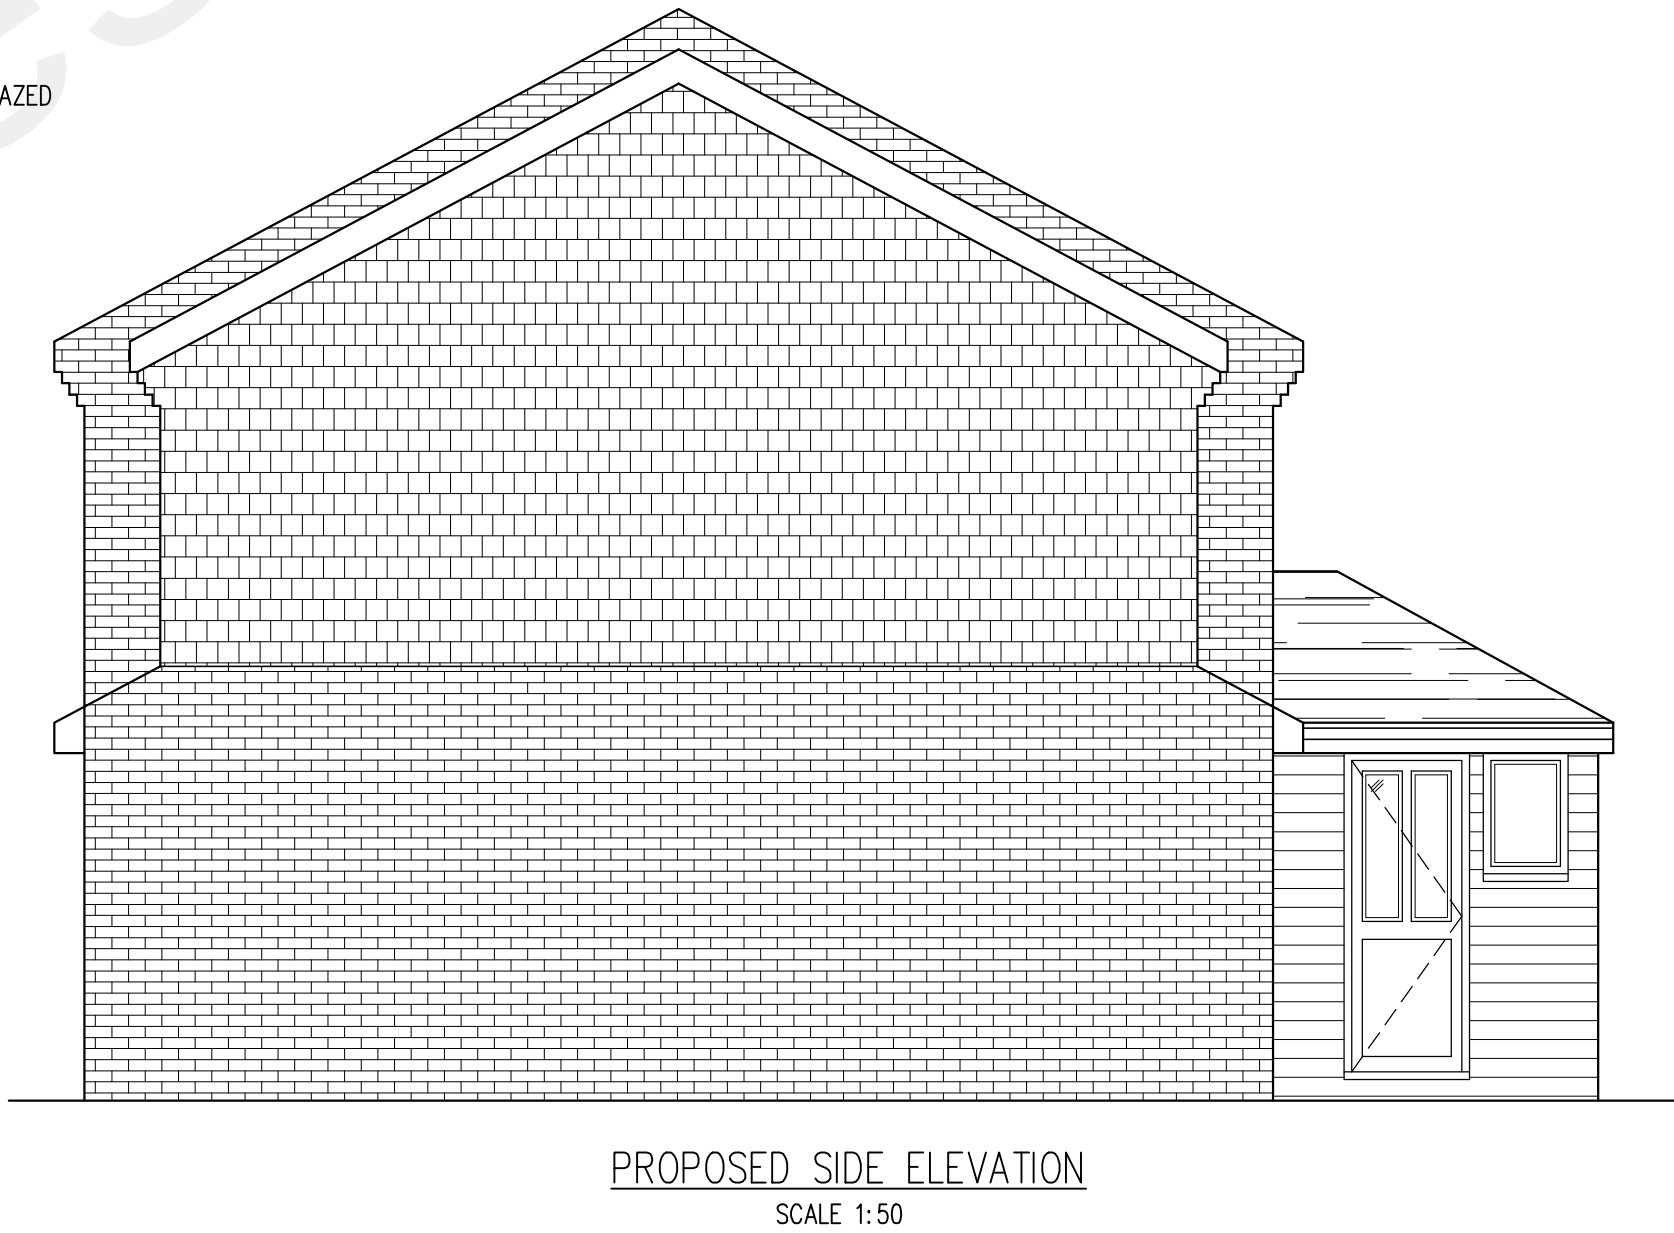

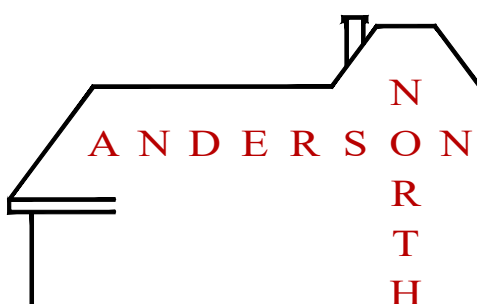D	01/07/22			PLANNING AMENDMENTS
C	12/07/22			BUILDING CONTROL AMENDMENTS
B	06/07/22			PLANNING AMENDMENTS
Rev	Date	By	Chd	Revisions
Client				
MR JAMES WENLOCK-SIMPSON				
Job Title				
FIRST FLOOR SIDE EXTENSION AT 201 HIGHVIEW VIGO GRAVESEND KENT DA13 0UU				
ARCHITECTURAL CONSULTANTS				
				
ANDERSON NORTH LIMITED				
Glen Lodge Priory Close, East Farleigh Kent ME15 0EY Tel: 01732 522 455 Mob: 07957 627 440				
Scale		Date		
AS SHOWN @ A1		12/05/22		
Drawing Title				
PROPOSED FLOOR PLANS AND ELEVATIONS				
Drawing No.				Rev.
201-HIGHVIEW-02				D