



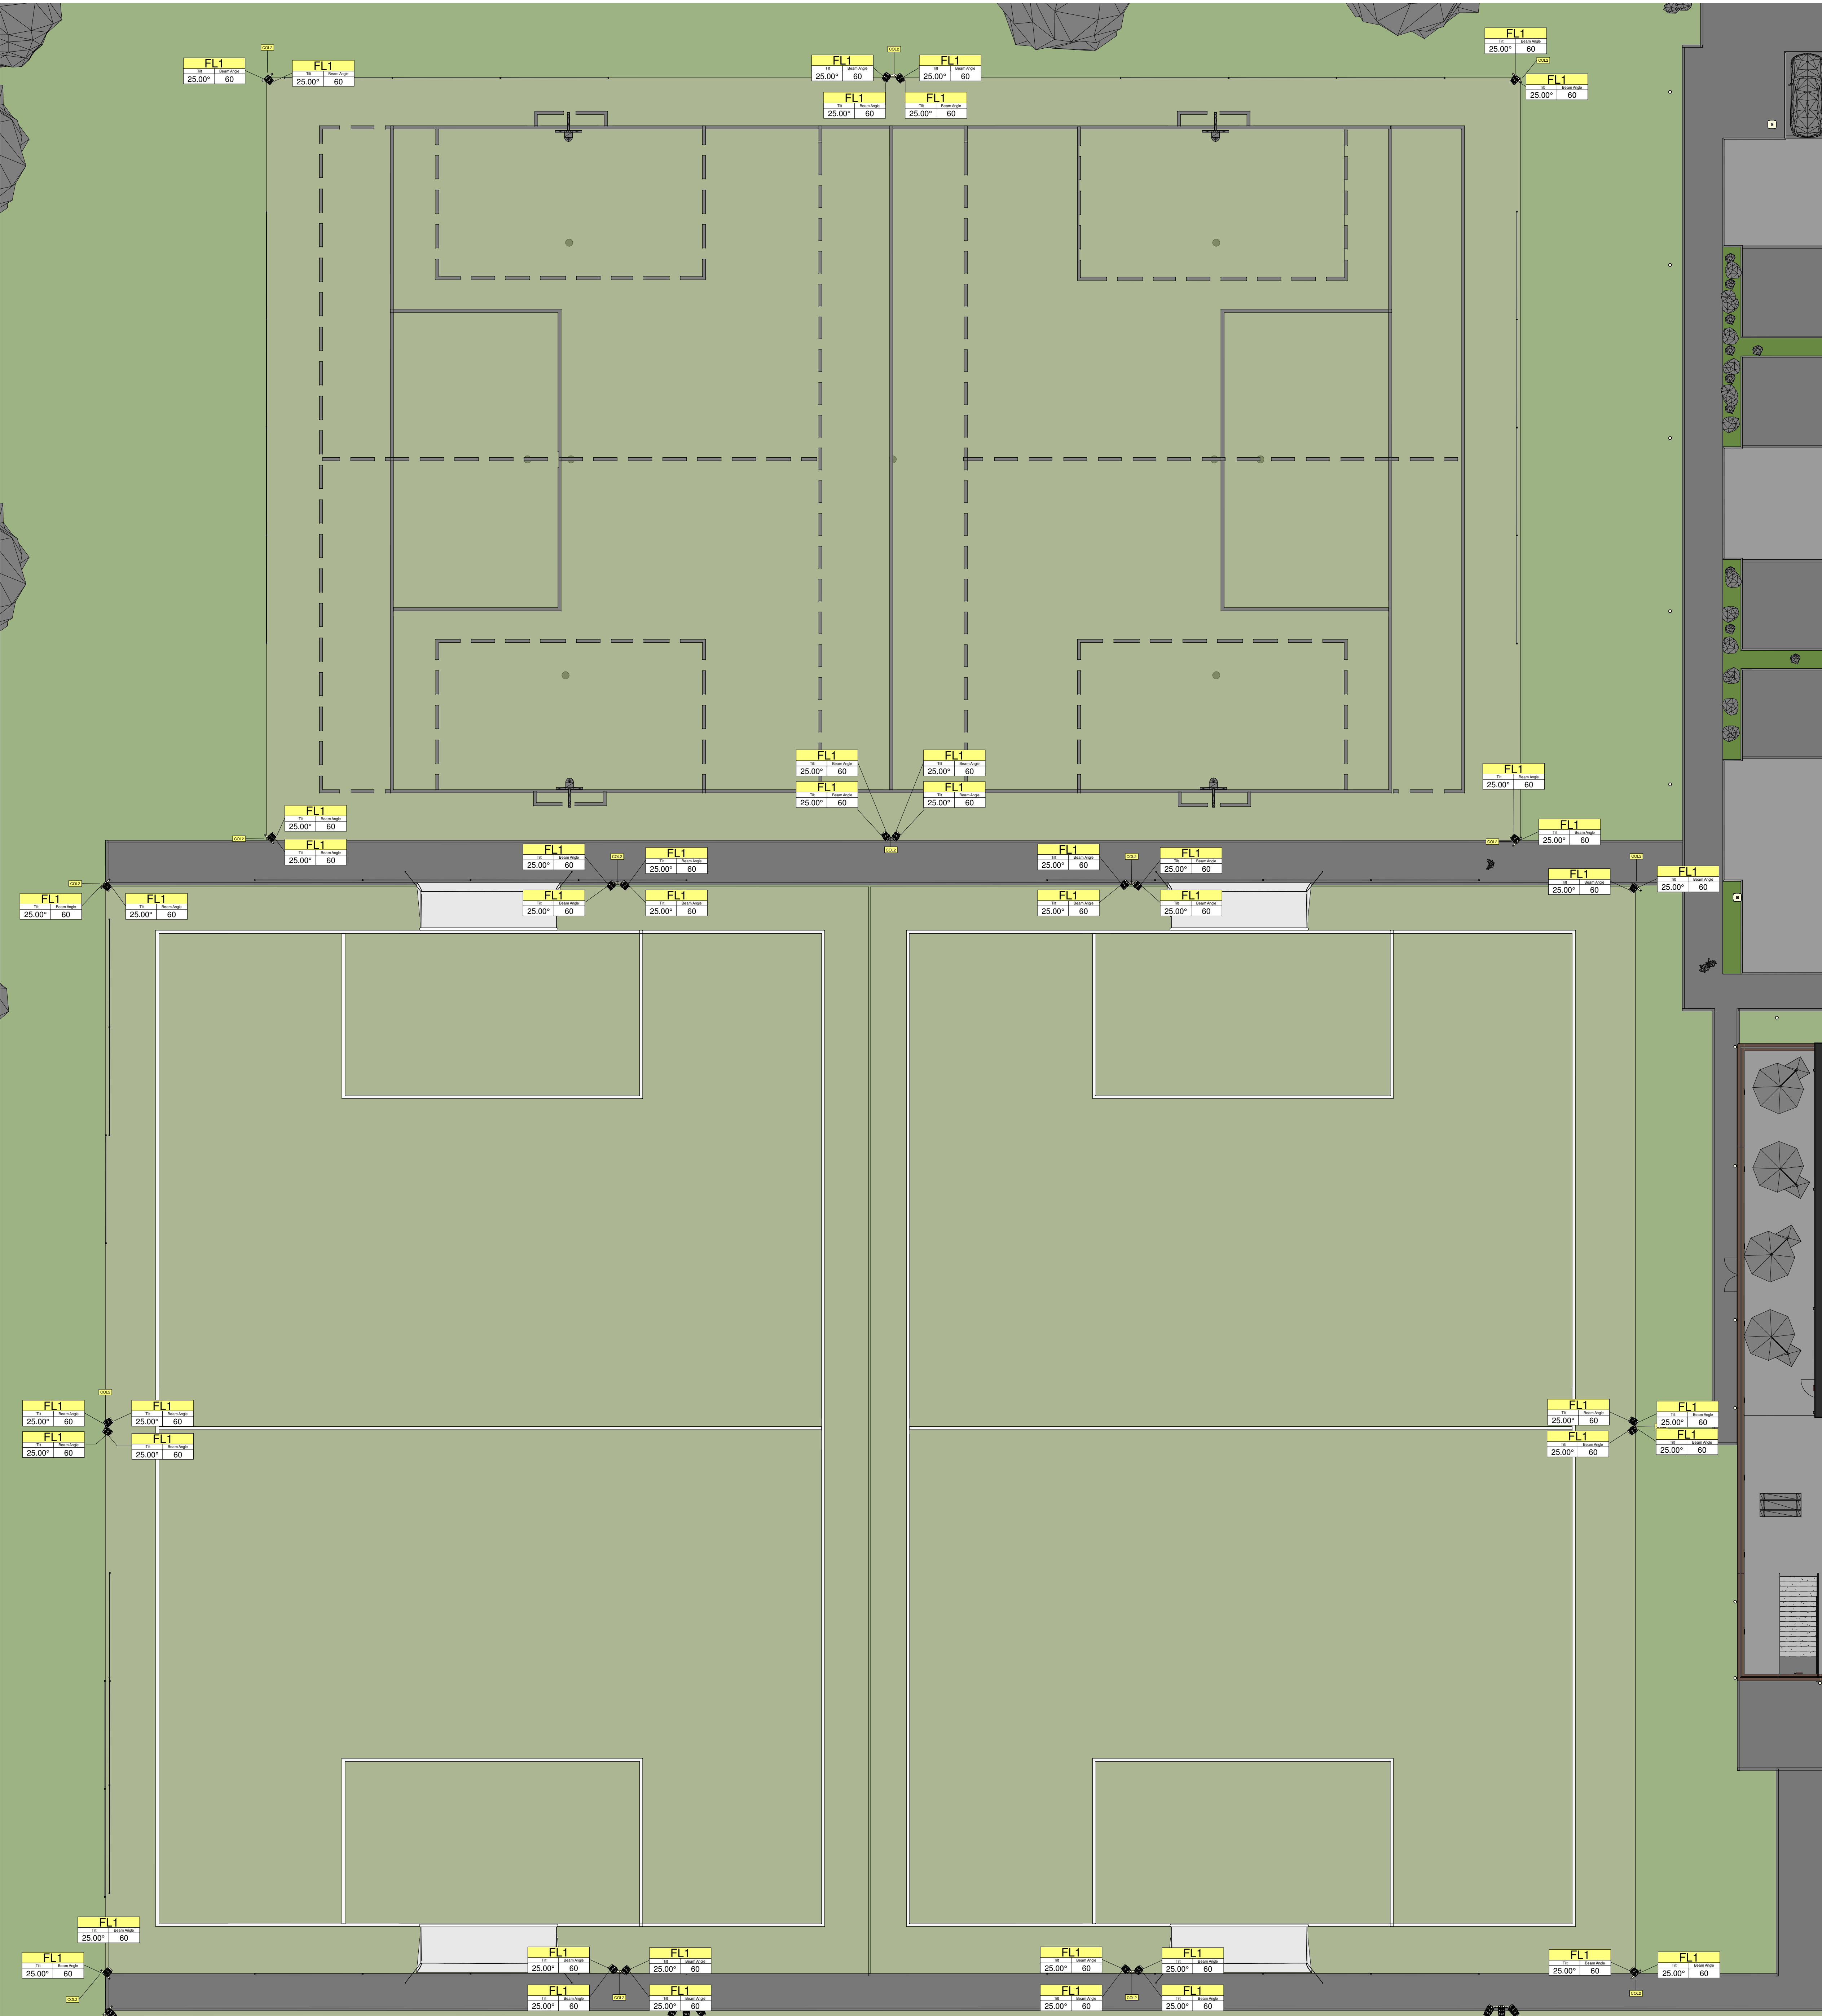

7v7'S Illuminance				
Calculation Points Name	Average	Maximum	Minimum	Min/Avg
7v7 PITCH 1	171 lx	352 lx	76 lx	0.44
7v7 PITCH 2	187 lx	384 lx	63 lx	0.34
7v7 PITCH 2	185 lx	397 lx	63 lx	0.34

Lighting Fixture Schedule Mugas	
Type Mark	Type
COL2	ROOF MOUNT 8M GALV COLUMN 700MM BRACKET
FL1	M3HPAF flood light

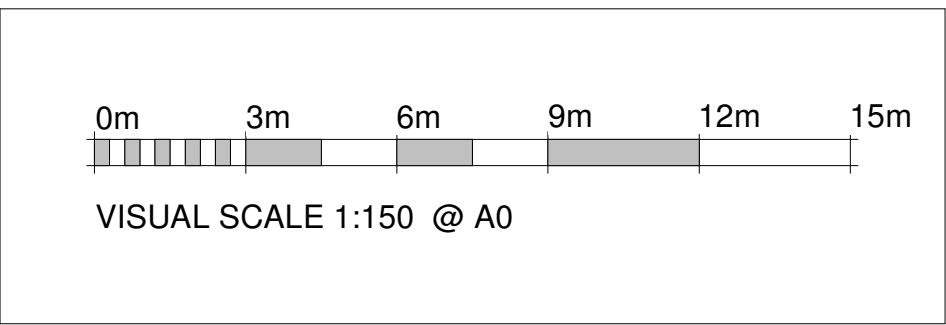

NUMBER JWM63099		
PROJECT Fleet Leisure		
TITLE 7v7 PITCHES		
CLIENT Owner		

Rev	Description	Date
R01	Revised 7v7 Pitches	26/05/2021

DO NOT SCALE

SCALE (@ A0) 1: 150	DRAWN BY Author	CHECKED BY Checker	DATE 03/26/21
------------------------	--------------------	-----------------------	------------------

DRAWING NUMBER L102	REV R01
------------------------	------------