




Lighting Fixture Schedule Car Park	
Type Mark	Type
COL1	ROOT MOUNT 6M GALV COLUMN, BLACK FINISH
EX1	LED POST TOP, 3000K, DALI DIM, ASYM
EX2	LED POST TOP, 3000K, DALI DIM, DOUBLE ASYM
EX3	800MM, 1W09 LED BOLLARD, DALI DIM
EXT	STD EXT. WIRELESS UNIT

CAR PARK				
Calculation Points Name	Average	Maximum	Minimum	Min/Avg
CAR PARK	26 lx	88 lx	4 lx	0.17

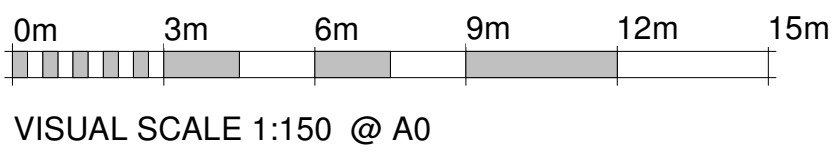

REVRLUX
Visual Lighting Design

MG Lites
Energy Saving Solutions

NUMBER
JWM63099

PROJECT
Fleet Leisure

TITLE
CAR PARK

CLIENT
Owner


Rev	Description	Date

DO NOT SCALE

SCALE (@ A0) 1:150 DRAWN BY JW CHECKED BY Checker DATE 26/03/2021


DRAWING NUMBER
L101

REV

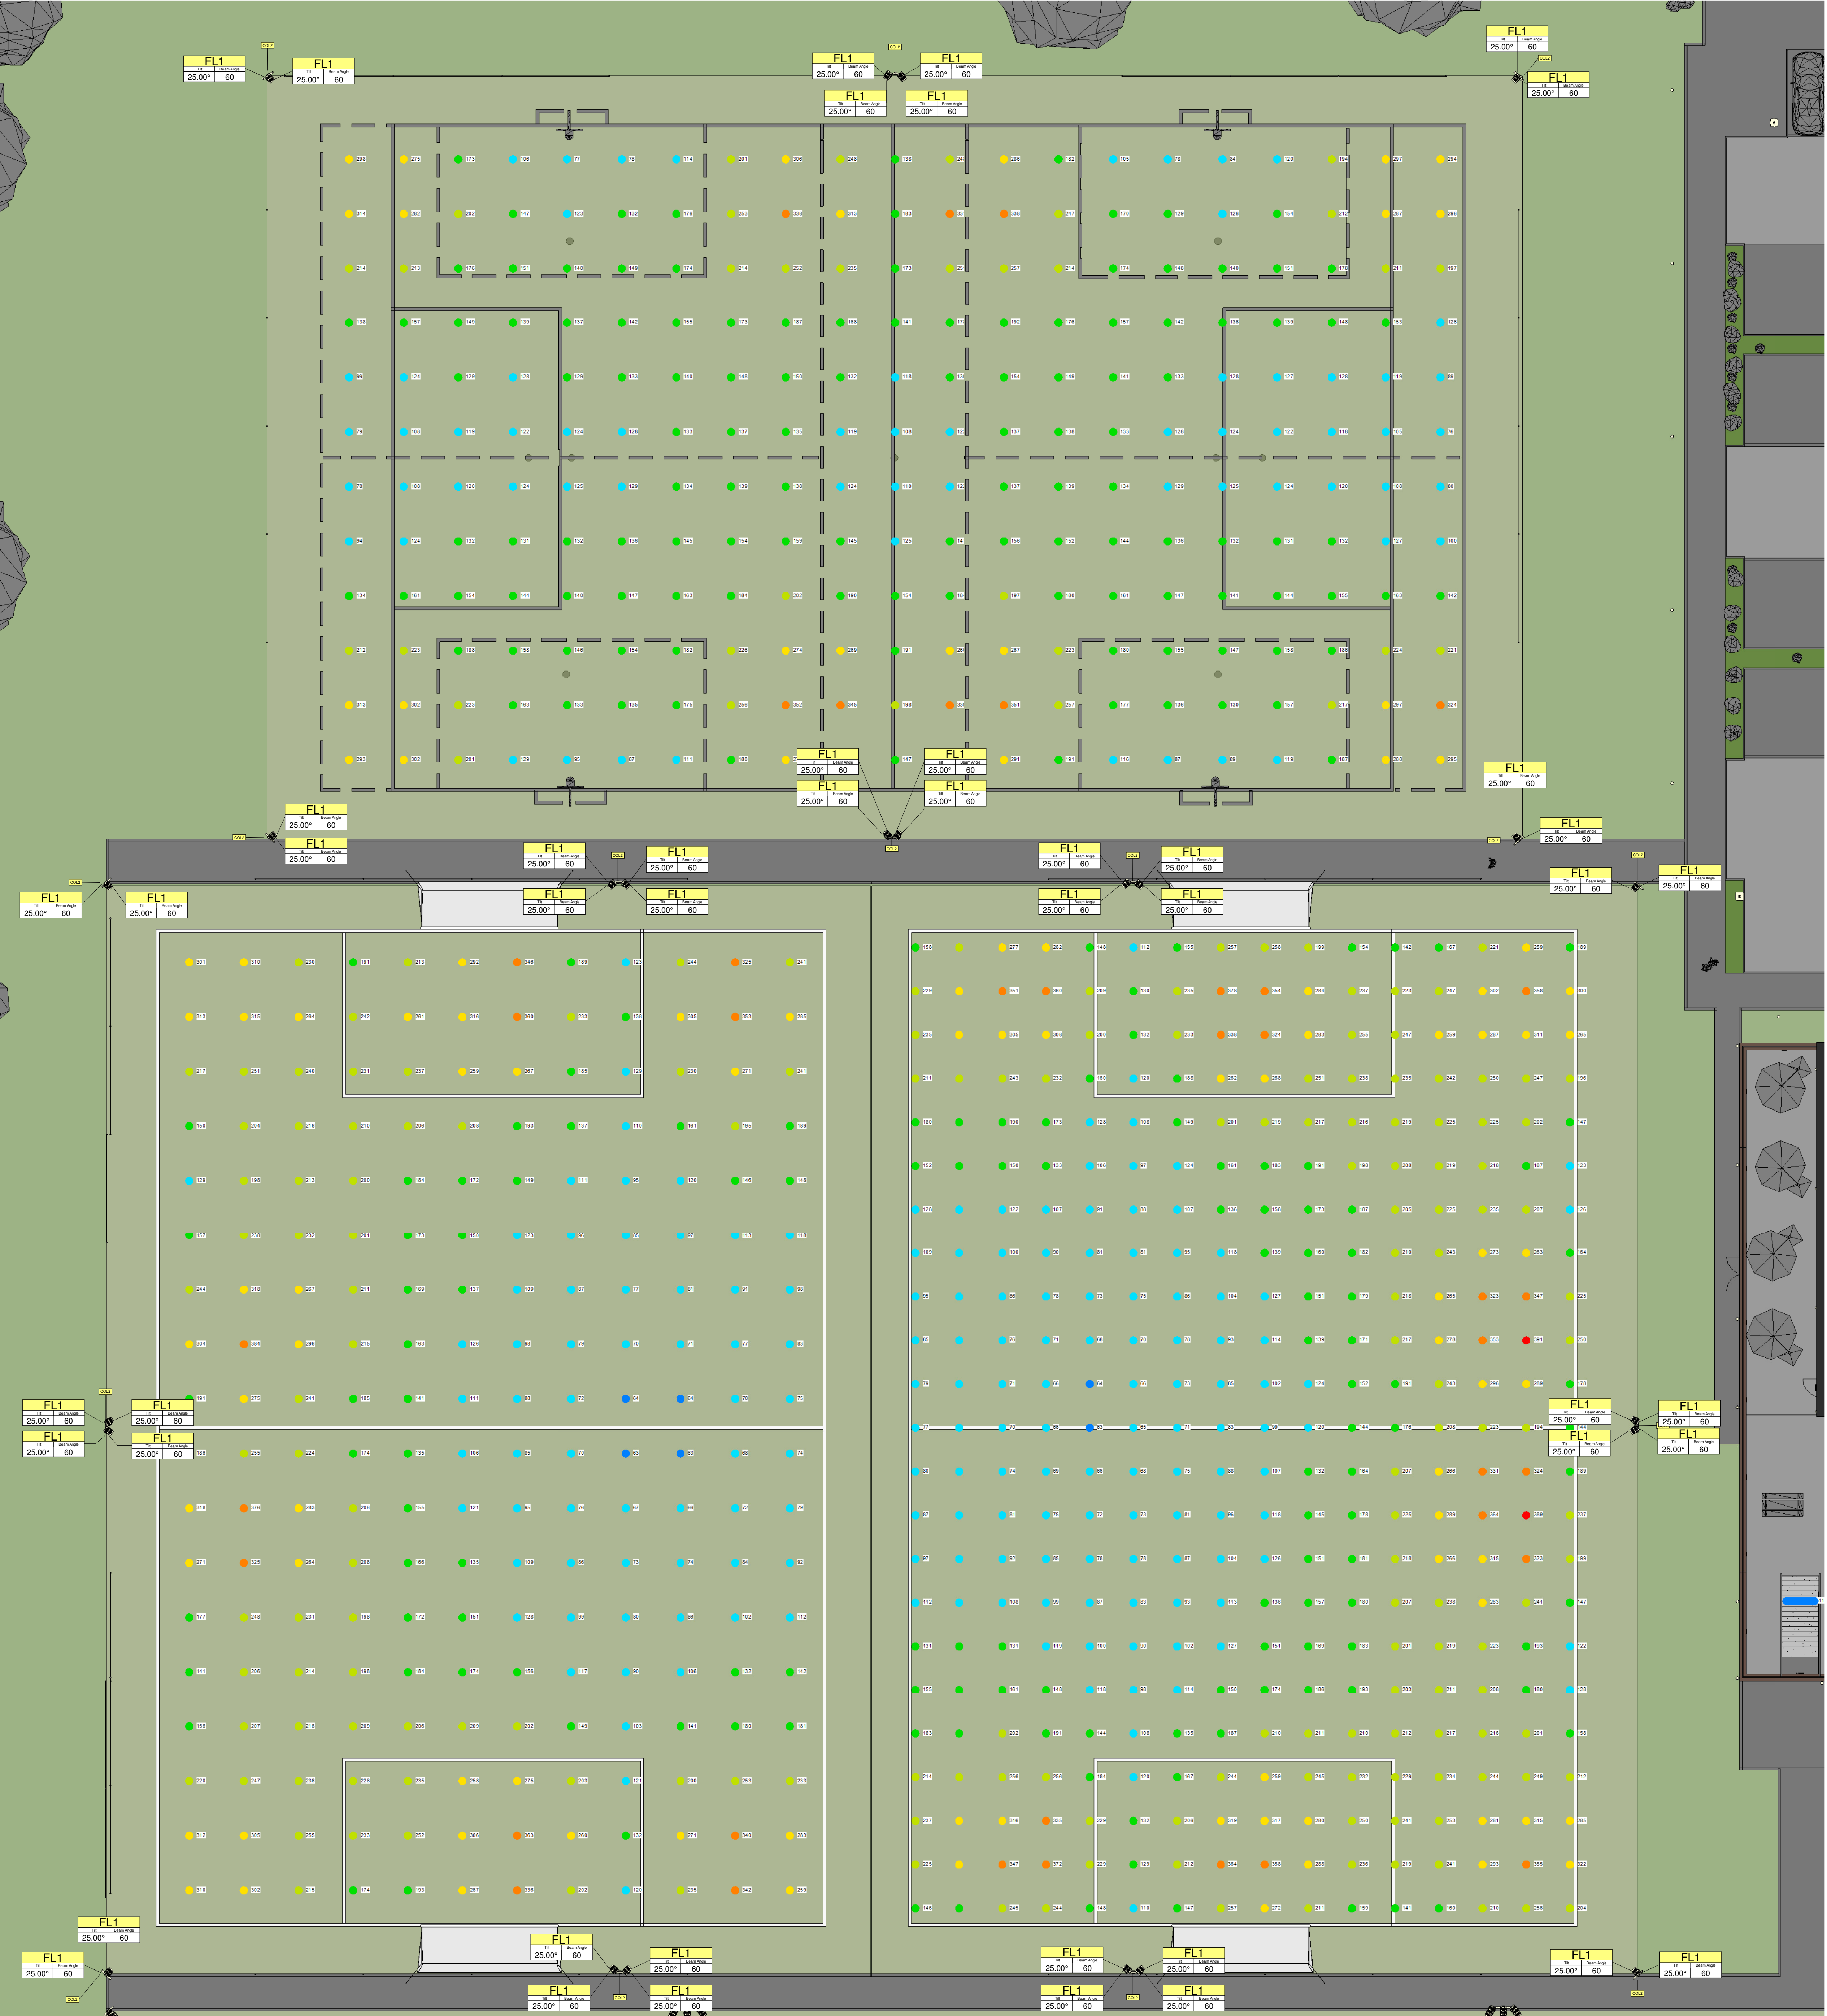

7v7'S Illuminance				
Calculation Points Name	Average	Maximum	Minimum	Min/Avg
7v7 PITCH 1	171 lx	352 lx	76 lx	0.44
7v7 PITCH 2	187 lx	384 lx	63 lx	0.34
7v7 PITCH 2	185 lx	397 lx	63 lx	0.34

Lighting Fixture Schedule Mugas	
Type Mark	Type
COL2	ROOT MOUNT 8M GALV COLUMN 700MM BRACKET
FL1	M8HPAF flood light

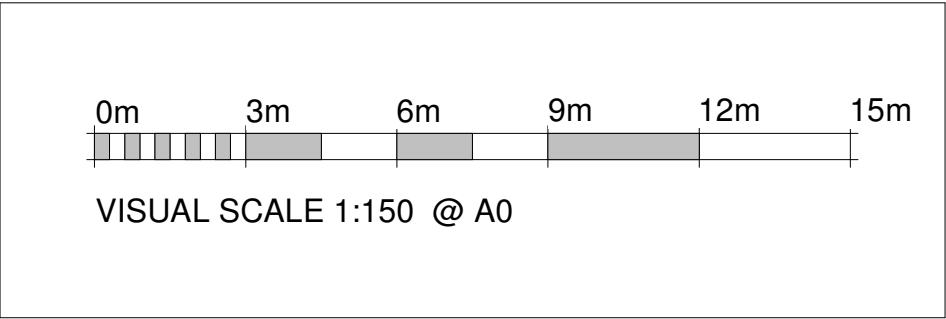

NUMBER
JWM63099

PROJECT
Fleet Leisure


TITLE
7v7 PITCHES

CLIENT
Owner

Rev	Description	Date
R01	Revised 7v7 Pitches	26/05/2021


DO NOT SCALE

SCALE (@ A0) 1:150
DRAWN BY Author
CHECKED BY Checker
DATE 03/26/21

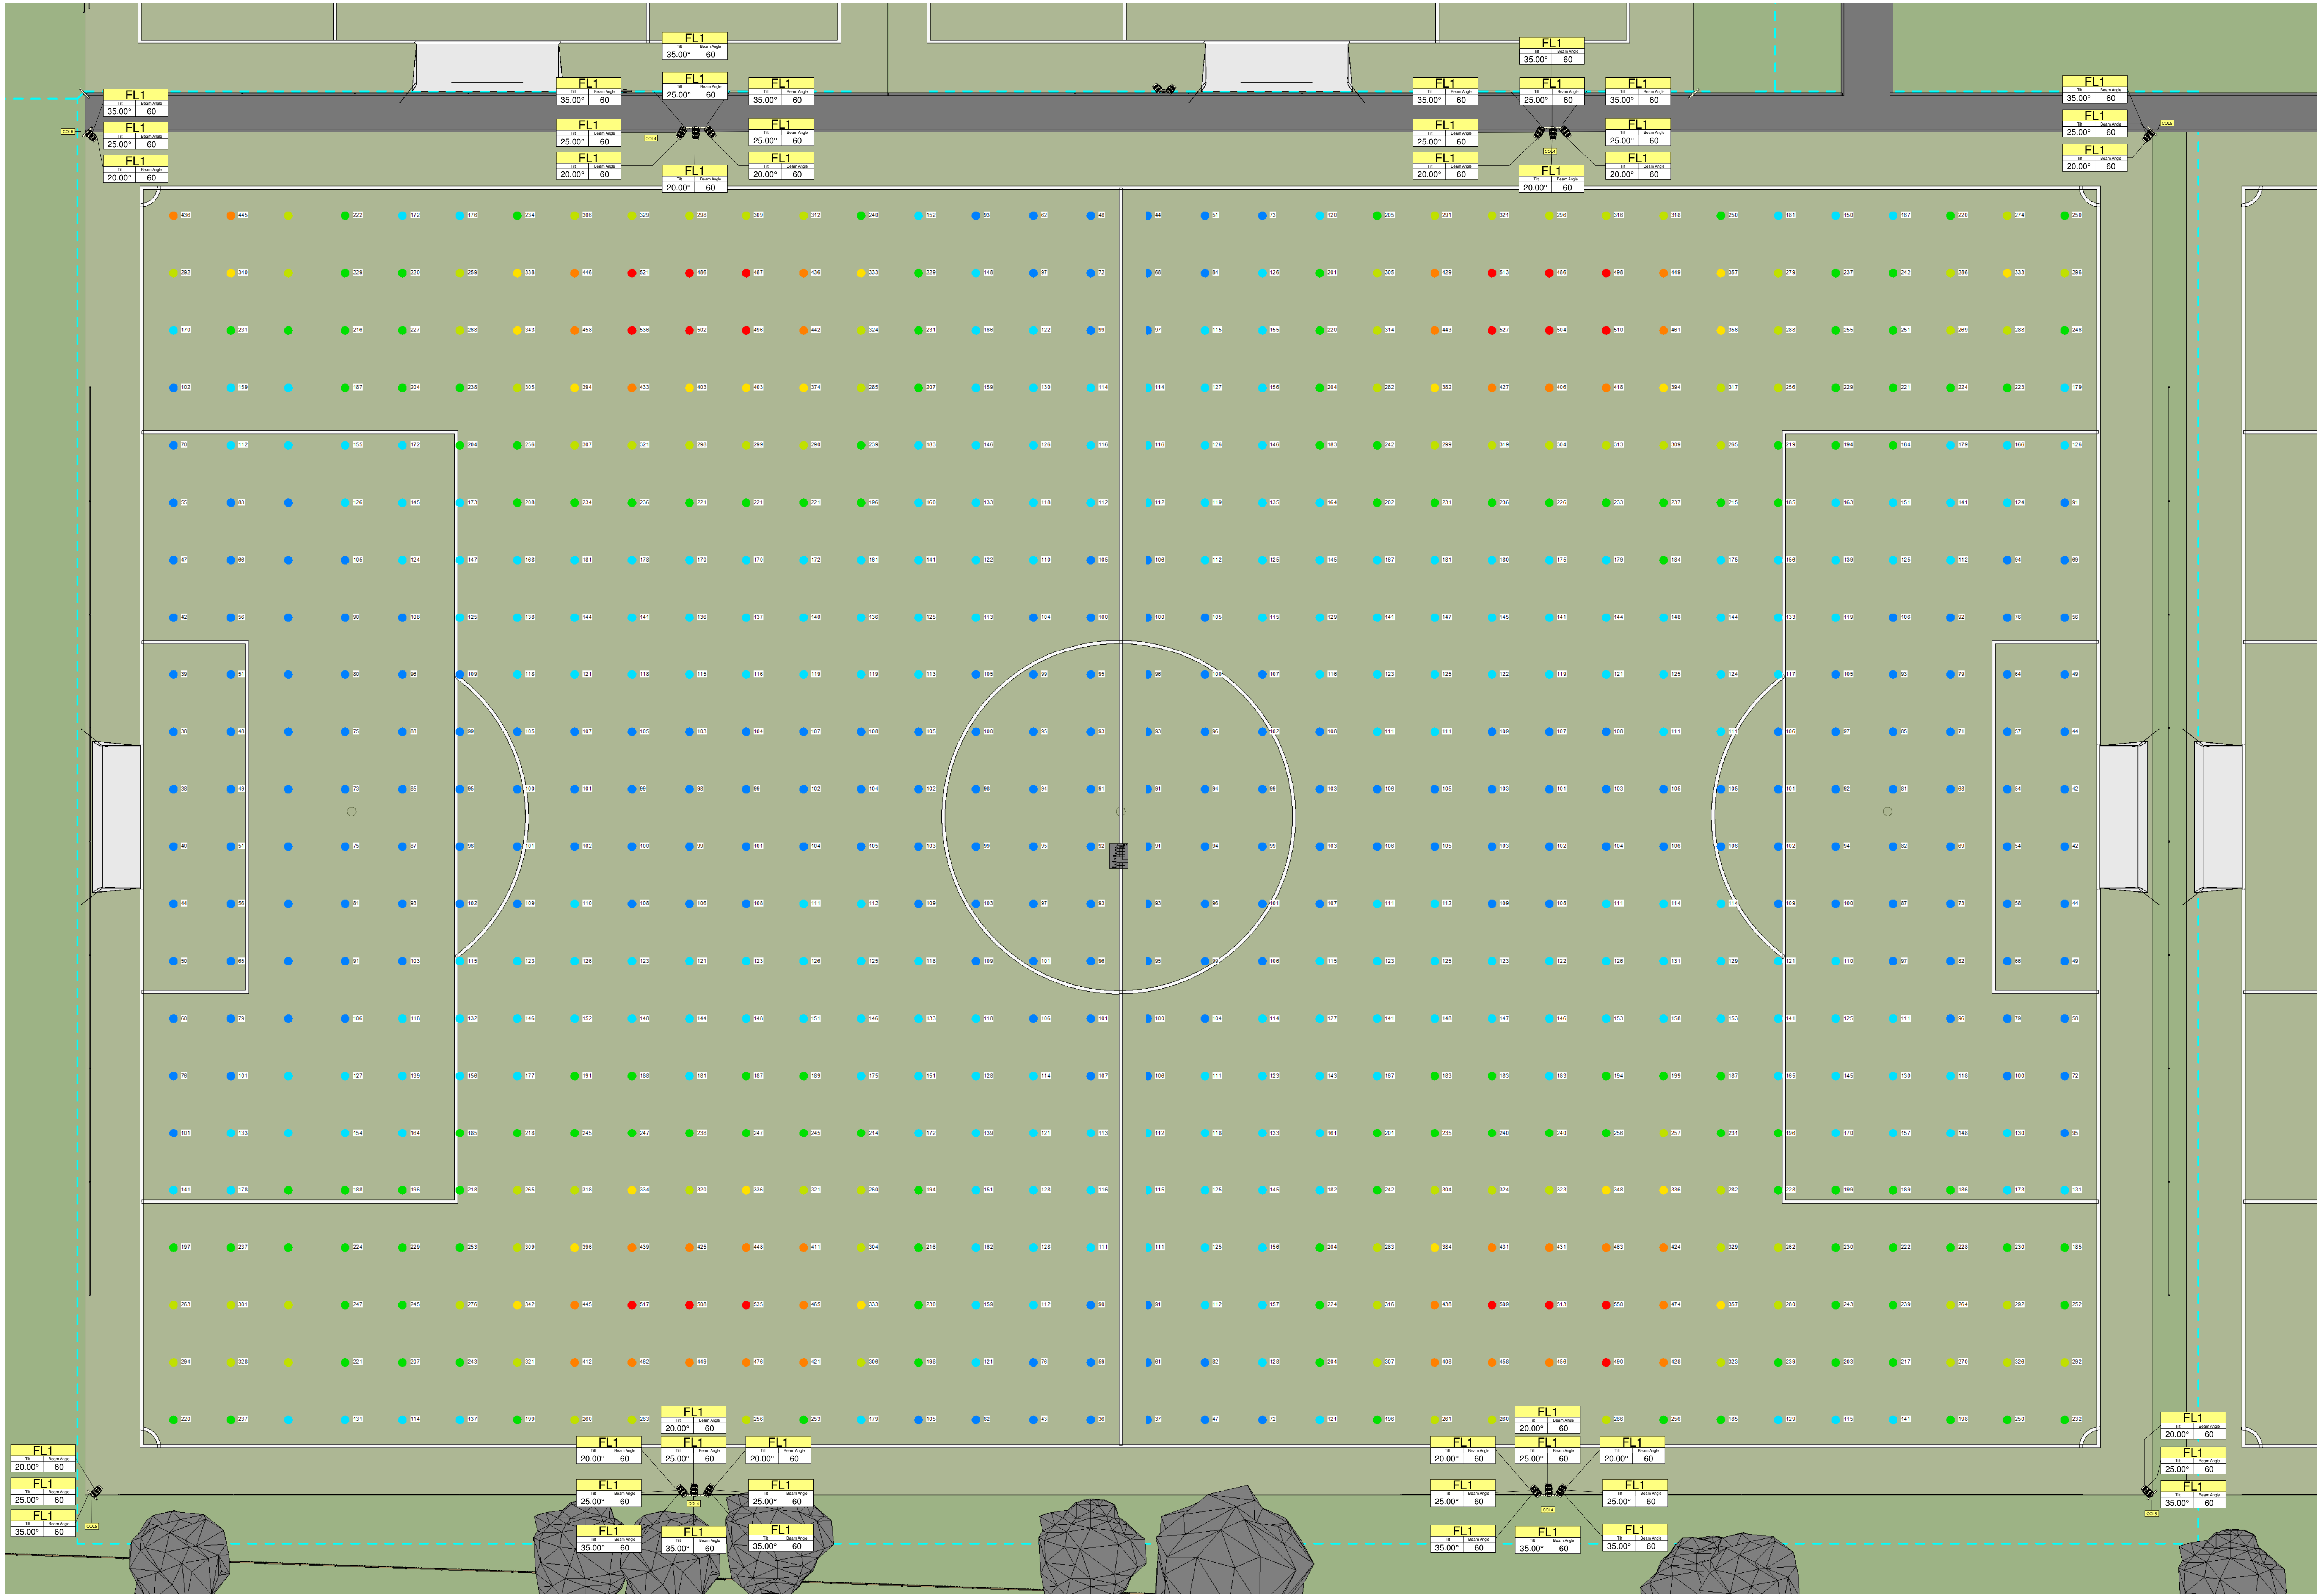

11V1'S Illuminance				
Calculation Points Name	Average	Maximum	Minimum	Min/Avg
11V1 PITCH	183 lx	550 lx	36 lx	0.20

Lighting Fixture Schedule 11V1	
Type Mark	Type
COL2	ROOT MOUNT 8M GALV COLUMN 700MM BRACKET
COL4	ROOT MOUNT 10M GALV COLUMN 1300MM BRACKET
COL5	ROOT MOUNT 10M GALV COLUMN 700MM BRACKET
FL1	MGH-PAF Flood Light

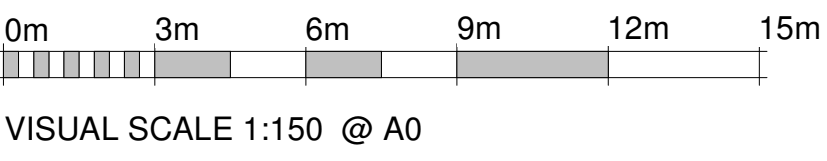

VISUAL SCALE 1:150 @ A0

REVRLUX
Visual Lighting Design

MG Lites
Energy Saving Solutions

NUMBER
JWM63099

PROJECT
Fleet Leisure

TITLE
11V1 PITCH

CLIENT
Owner

Rev	Description	Date
R01	Revised 7v7 Pitches	26/05/2021

DO NOT SCALE

SCALE (@ A0) 1: 150	DRAWN BY Author	CHECKED BY Checker	DATE 03/26/21
------------------------	--------------------	-----------------------	------------------

DRAWING NUMBER
L103

R01

1 11V 11 PITCHES
1 : 150