


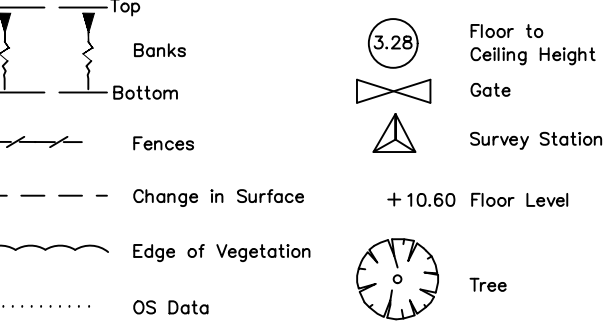

ABBREVIATIONS	
ABH Arched Beam Height	KO Kerb Outlet
B Brick	L Light
BAL Balcony	LP Lamp Post
BB Balisha Beacon	MH Manhole
BD Balard	MKR Marker
BH Beam Height	MSF Metal Security Fence
BL Bed Level	N/A No Access
BP Brick Pier	OHC Overhead Cables
BRW Brick Retaining Wall	P Post
BS Bus Stop	PALF Palisade Fence
BT British Telecom	PF Picket Fence
BW Brick Wall	PIT Trial Pit
BWF Barbed Wire Fence	PL Pavement Light
C Concrete	PM Parking Meter
CAB Cabinet	PRF Post & Rail Fence
CBF Close Boarded Fence	PWF Post & Wire Fence
CBW Concrete Block Wall	R Render
CF Corrugated Iron Fence	RAD Radiator
CL Cover Level	RE Rodding Eye
CLF Chain Link Fence	RH RH
COL Column	RS Road Sign
CPF Concrete Panel Fence	RWP Rain Water Pipe
CPS Concrete Paving Slabs	S Stone
CRW Concrete Retaining Wall	SV Stop Valve
CSU Ceiling Slopes Up	SL Skylight
CTV Cable Television	SP Soil Pipe
CW Concrete Wall	SFS Stone Paving Slabs
CZY Crazy Paving	SRW Stone Retaining Wall
D Door	SW Stone Wall
DH Door Height	SWS Surface Water Sewer
EC Electricity Cover	TJ Top of Joist
ESG Electrical Switch Gear	T TILE
EH EH	TI Timber
EP Electricity Pole	TRW Timber Retaining Wall
FB Flower Bed	UJ Underside of Joist
FC False Ceiling	UR Underside of Ridge Board
F/E Fire Escape	UWP Underside of Wall Plate
FH Fire Hydrant	V Vent
FL Floor Level	VP Vent Pipe
GY Gully	W Window
GV Gas Valve	WL Water Level
HA Hatch	WM Water Meter
IC Inspection Cover	WMP Wire Mesh Fence
IL Invert Level	WPF Wooden Panel Fence
IRF Iron Rolling Fence	WCL Window Cill Height
IWF Interwoven Fence	WHL Window Head Height
	WRW Wooden Retaining Wall



NOTES

1. ALL LEVELS SHOWN ARE RELATED TO ORDNANCE SURVEY GPS DATUM.
2. ALTHOUGH CARE HAS BEEN TAKEN, DUE TO ACCESS LIMITATIONS ALL HIGH LEVEL DETAIL HAS BEEN SURVEYED REMOTELY AND NOT CHECKED BY PHYSICAL MEASUREMENTS.
3. ALL CRITICAL MEASUREMENTS MUST BE CHECKED / VERIFIED.

REVISIONS

REVISIONS	DATE
SCALE: 1:100@A1	
DATE: AUGUST 2021	
DRAWN: GR	

TITLE: FLOOR PLAN

JOB: MID KENT GOLF CLUB

CLIENT: MID KENT GOLF CLUB

DWG. No: LUG / 9.1



LAND UTILITY GROUP LTD.

MIDLANDS OFFICE

UNIT 10
STRENSHAM BUSINESS PARK
TWYNING ROAD
WORCESTER
WR8 9JZ

LONDON OFFICE

BRICKFIELD HOUSE
HIGH ROAD
THORNWOOD
EPPING
ESSEX
CM16 6TH

T: 0845 602 3966
M: 07979 367282

T: 01992 566698
M: 07977 112286
M: 07977 111935

