



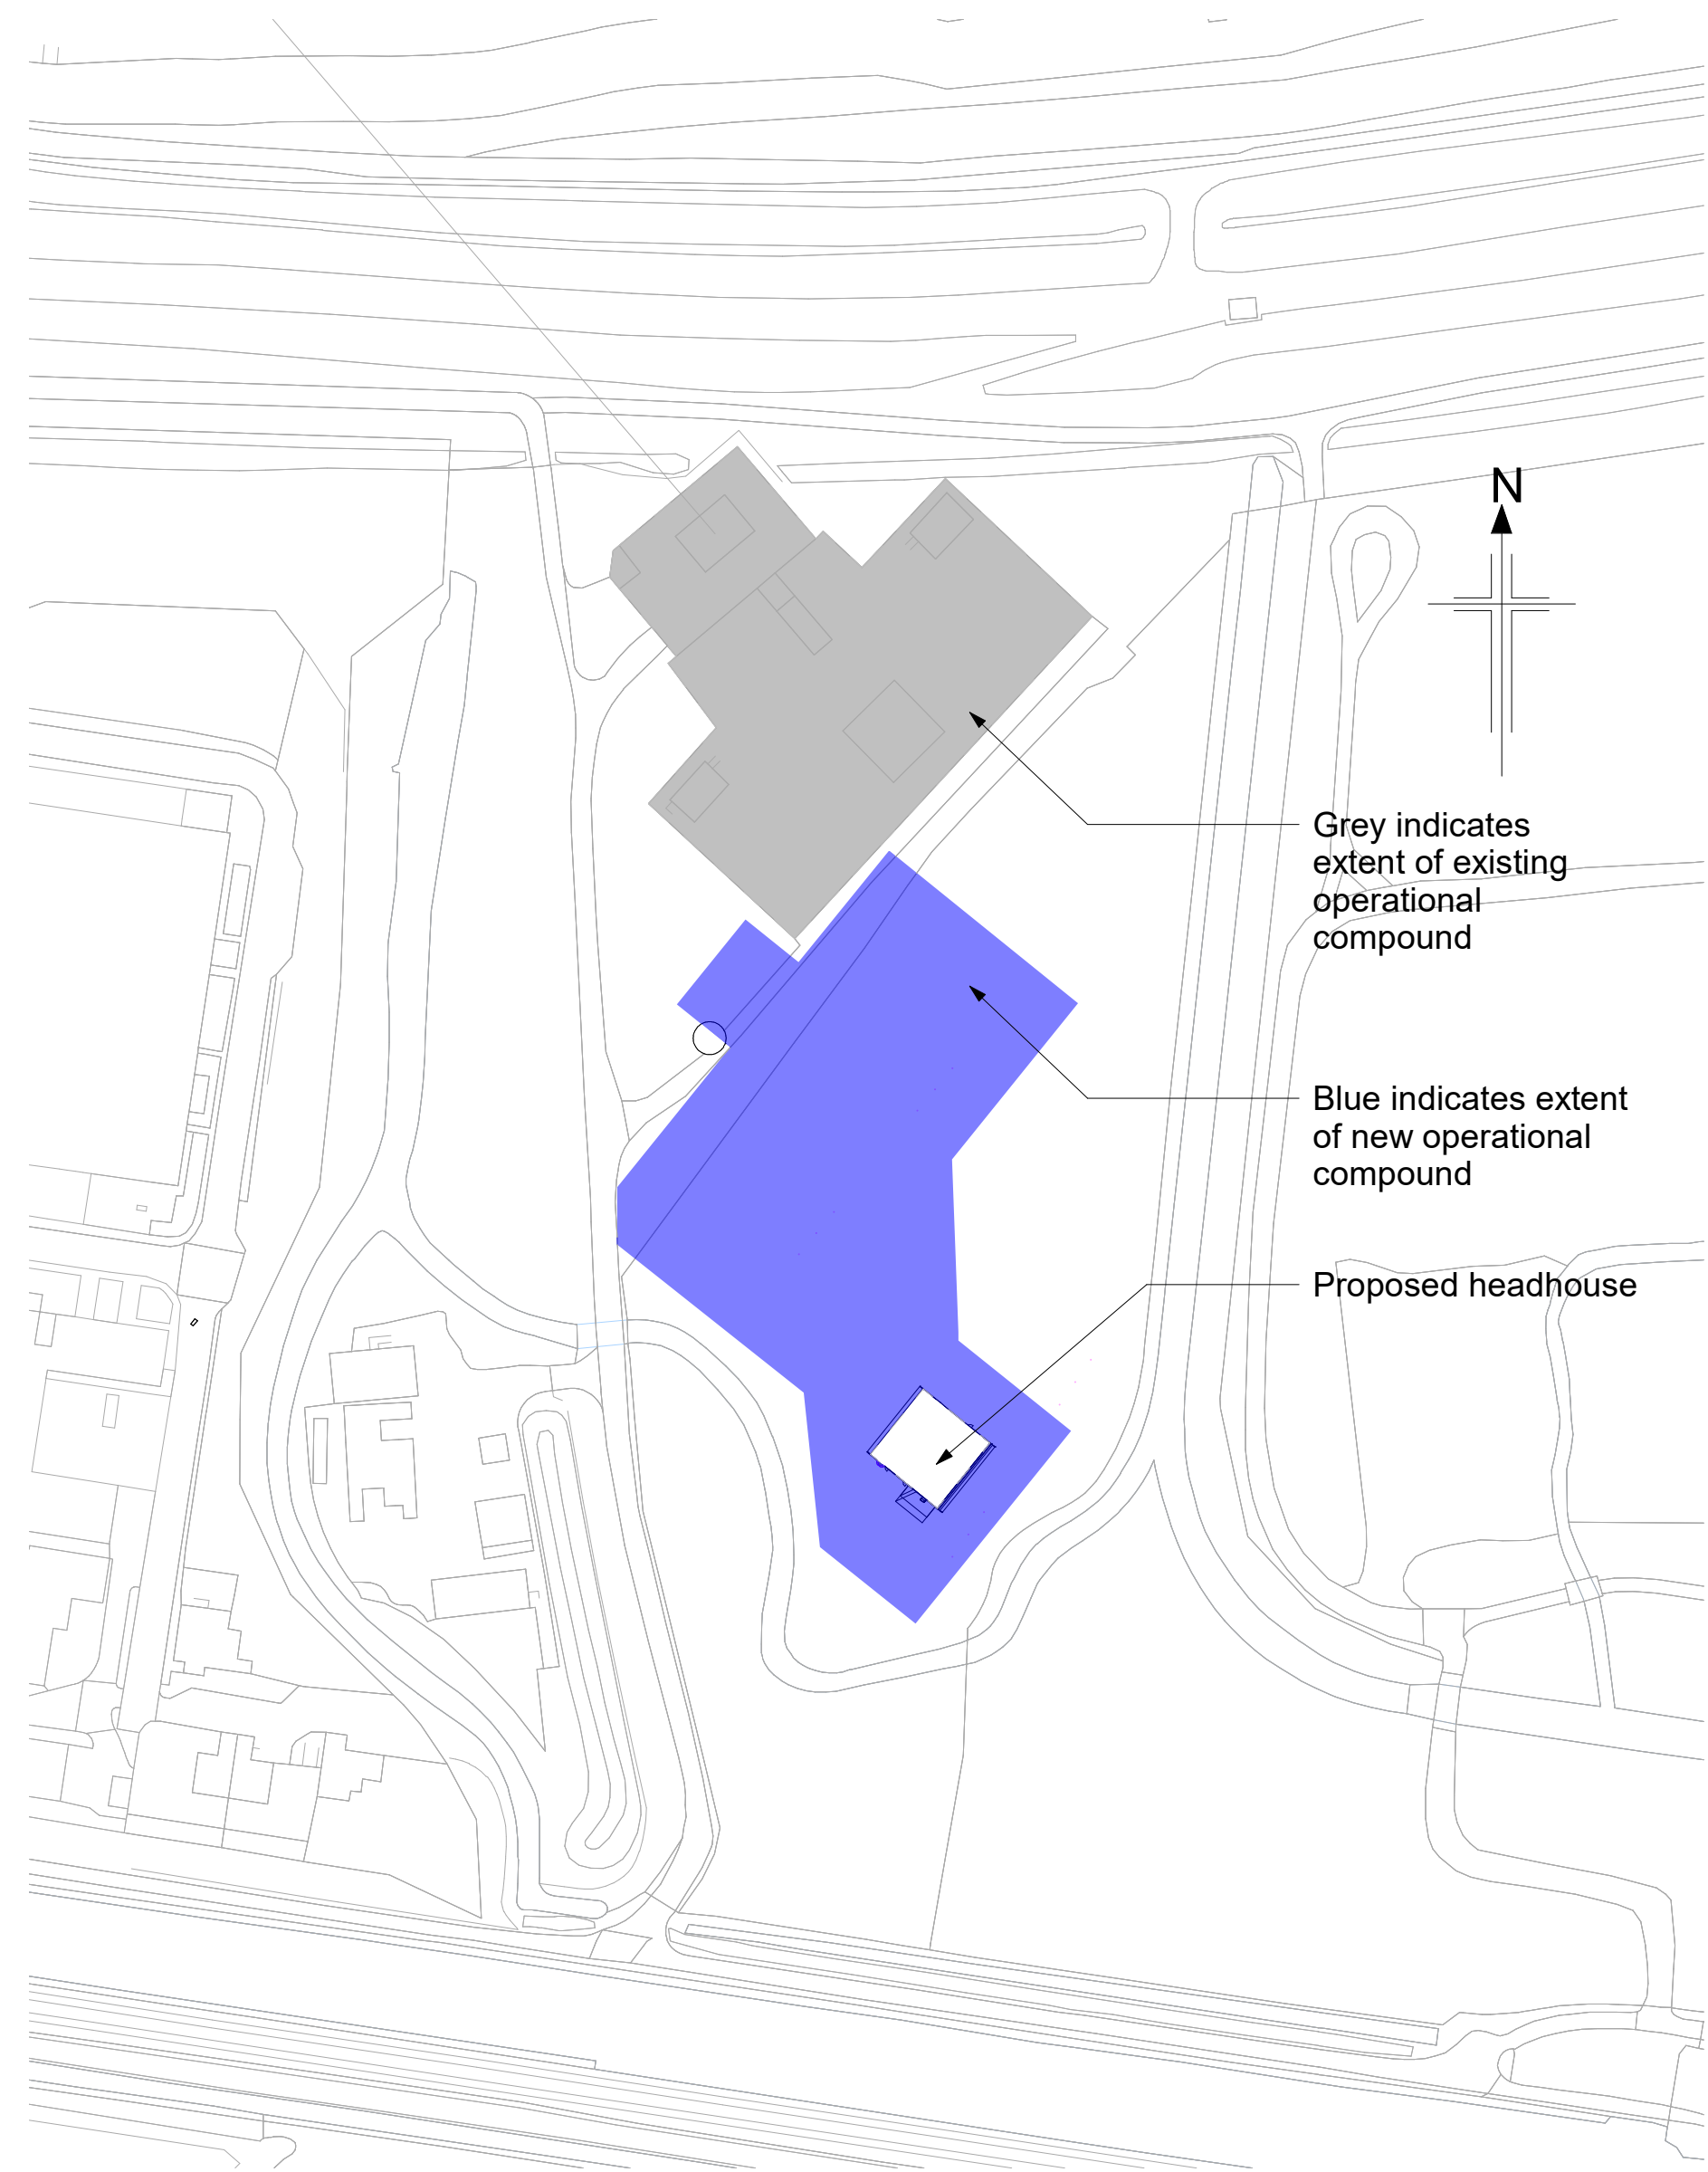

Key Plan - Extent of Compound
Scale: 1 : 1250

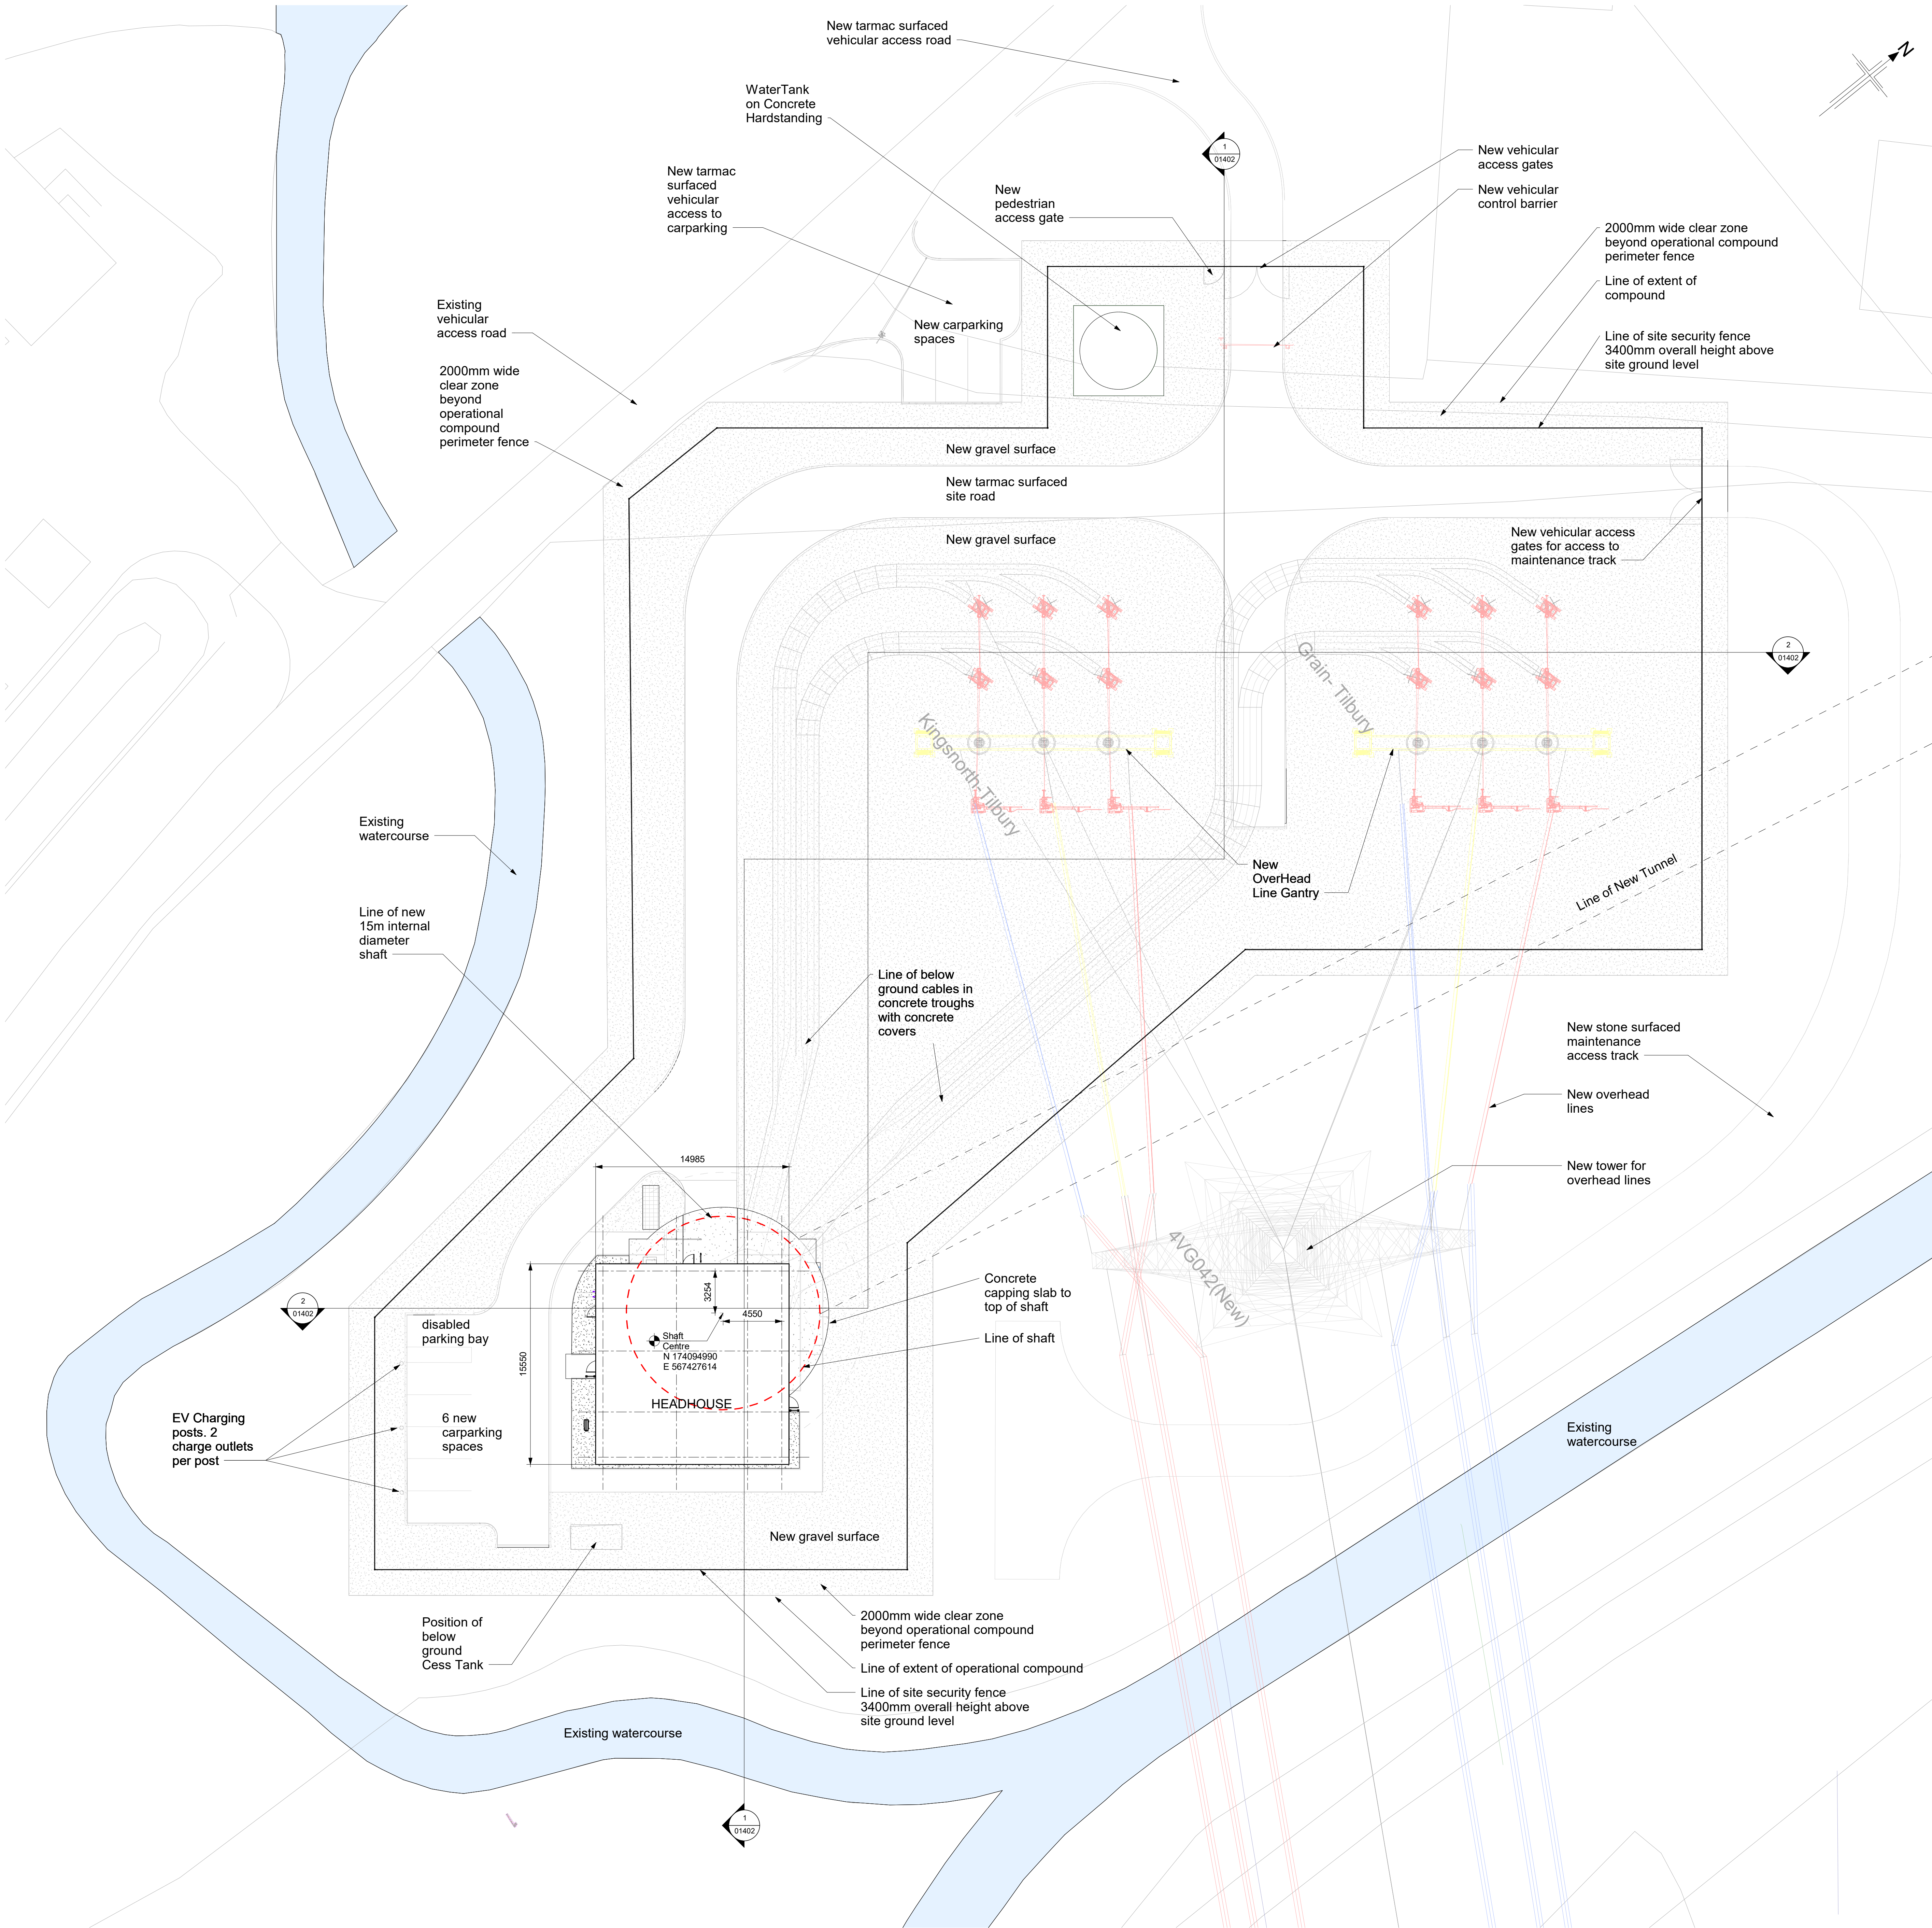


Proposed Site Plan
Scale: 1 : 200

NOTES

1. ALL DIMENSIONS IN MILLIMETERS UNLESS OTHERWISE STATED
2. ALL LEVELS ARE IN METERS ABOVE ORDNANCE DATUM (mAOD)
3. FOR GRAVESEND SHAFT SEE PDD-100116-LAY-123
4. SHAFT CENTRE POINT AT: East = 567427 615, North = 174094 990
5. ROAD AND FOOTPATH ALIGNMENTS SHOWN ARE INDICATIVE ONLY
6. SVP - SOIL & VENT PIPE
RWP - RAINWATER PIPE
UPS - UNINTERRUPTED POWER SUPPLY

REFERENCE DRAWINGS

PDD-100116-LAY-102 - CSE Layout with cable termination arrangement (Gravesend site) (A784/A785)
PDD-100116-LAY-123 - GRAVESEND SHAFT GENERAL ARRANGEMENT
PDD-100116-LAY-037 - GRAVESEND COMPOUND LEVELS

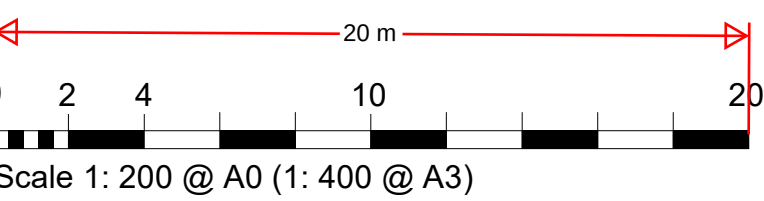

P03	Updated to include water tank	RW	JK	NS	16/10/23
P02	Updated to comments received	RD	RW	JK	24/09/23
P01	Initial Issue	RD	RW	JK	07/09/23
Rev	Description	Chk'd	Chk'd	App'd	Date

nationalgrid

Master Scheme No: 100116 Sub-Scheme No: - Site: NEW GRAVESEND CSEC

Scheme Name: TKRE GRAIN-TILBURY AND KINGSNORTH-TILBURY 400kV UPRATING

Document Title: Gravesend Headhouse - Planning - Site Plan

Created by: RD	Date: 07/09/23	Checked by: RW	Date: 07/09/23	Approved by: JK	Date: 07/09/23
Development Eng: BT	Document Type: Drawing	Scale: As Indicated	Format: A0	Sheet(s): 1 of 1	Rev: P03

National Grid Document Number: PDD-100116-LAY-053

FEED Document Number: 30003364-BHK-XX-XX-DR-A-01400